

**WILLIAM J CLINTON
PRESIDENTIAL
CENTER**

LITTLE ROCK, ARKANSAS

Architect

POLSHEK PARTNERSHIP LLP
320 West 13th Street
New York, New York 10014
212.607.7171

Coordinating Architects

POLK STANLEY YEARY ARCHITECTS Ltd
700 South Schiller Street
Little Rock, Arkansas 72201
501.378.0878

WITSELL EVANS RASCO
501 West Third Street
Little Rock, Arkansas 72201
501.374.5300

WOODS CARADINE ARCHITECTS
2200 South Main Street
Little Rock, Arkansas 72206
501.374.4060

Landscape Architects

HARGREAVES ASSOCIATES
118 Magazine Street
Cambridge, Massachusetts 02139
617.661.0070

LANDSCAPE ARCHITECTURE Inc.
2300 Cottondale Lane Suite 202
Little Rock, Arkansas 72202
501.374.5510

Structural Engineer

LESLIE E. ROBERTSON ASSOC. RLLP
30 Broad Street 47th Floor
New York, New York 10004
212.750.9000

MEP Engineers

FLACK + KURTZ Inc.
475 Fifth Avenue
New York, New York 10017
212.532.9600

CROMWELL ARCHITECTS ENGINEERS
101 South Spring Street
Little Rock, Arkansas 72201
501.372.2900

Curtilwall Consultant


R. A. HEINTGES ARCHITECTS
125 Fifth Avenue 9th Floor
New York, New York 10011
212.652.2966

**100% PLUMBING
CONSTRUCTION DRAWINGS
ISSUE - JULY 1, 2002**

Seal



Issue	Date
100% Construction Documents	09/27/02
90% Progress Printing	08/29/02
Plumbing Contract Documents	07/01/02
100% Design Development Filed as part of P104d	03/01/02

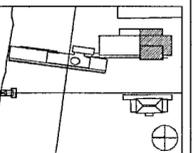

Job No. POLSHEK & PARTNERS ARCH. 9908
CROMWELL AE 99-114

 
Scale 1/8" = 1'-0"

Date JULY 01, 2002


Title **ARCHIVES
THIRD LEVEL ROOF
PLUMBING
PARTIAL PLAN**

Sheet No.

P104d



FOR OFFICIAL USE ONLY

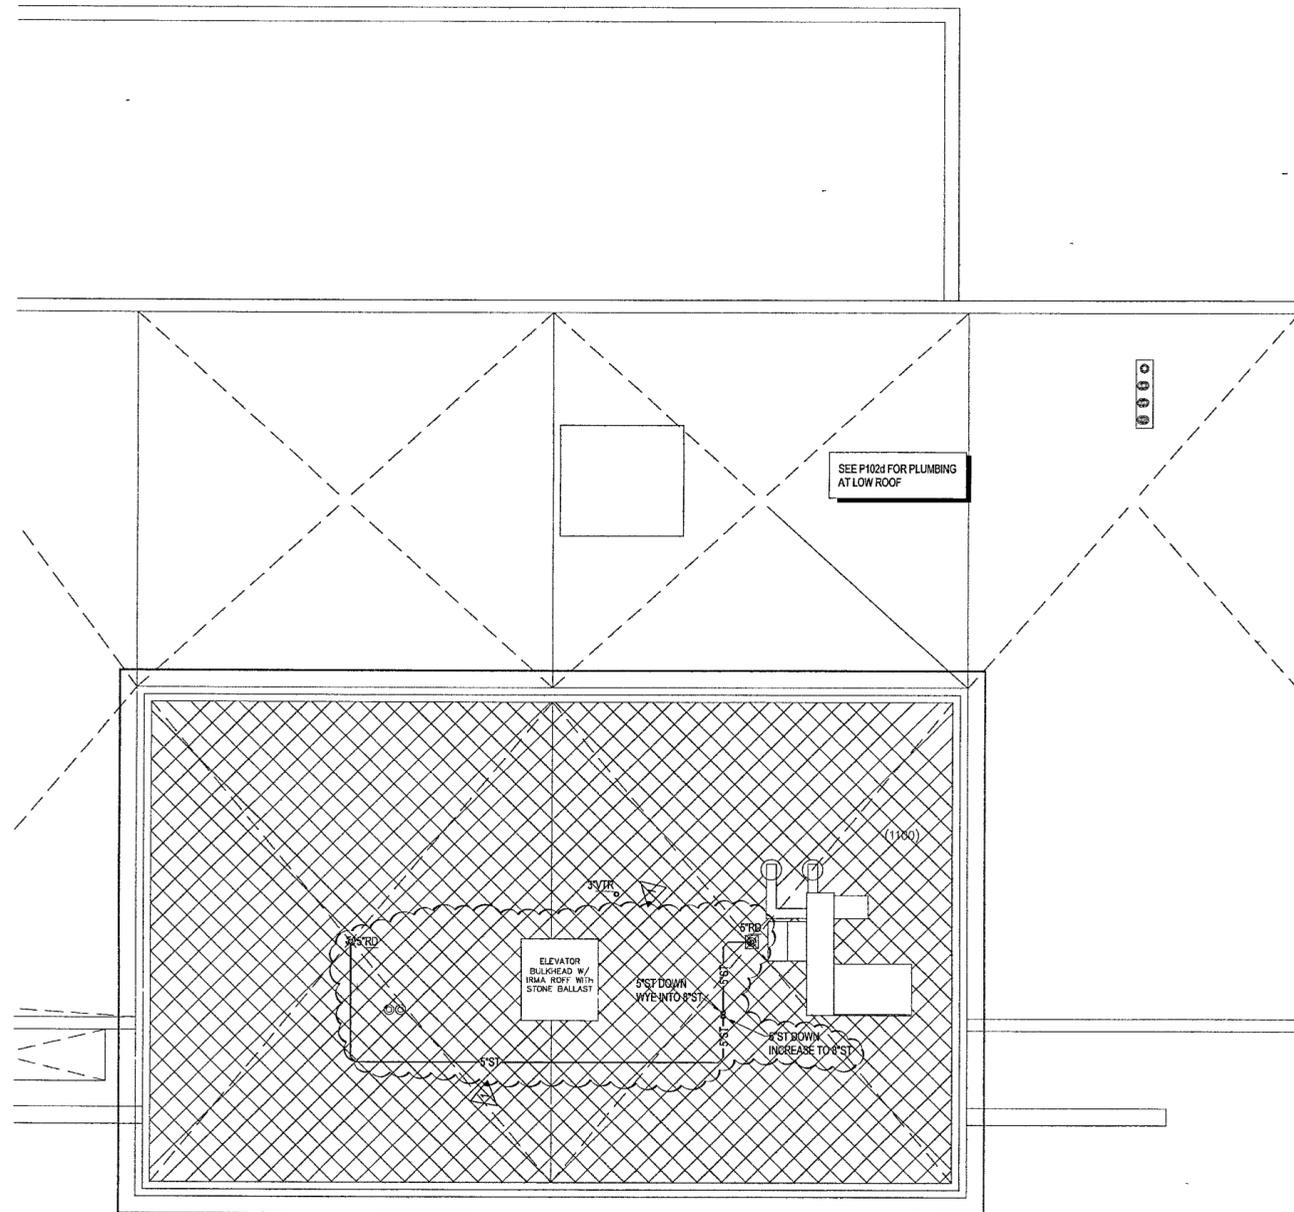

SEE P102d FOR PLUMBING
AT LOW ROOF

1 ARCHIVES - THIRD LEVEL ROOF PLUMBING PLAN
P104d | P104d 1/8" = 1'-0"

