

**WILLIAM J CLINTON
PRESIDENTIAL
CENTER**

LITTLE ROCK ARKANSAS

Architect
POLSHEK PARTNERSHIP LLP
320 West 13th Street
New York, New York 10014
212.807.7171

Coordinating Architects
POLK STANLEY YEARY ARCHITECTS, Ltd
700 South Schiller Street
Little Rock, Arkansas 72201
501.378.0878

WITSELL EVANS RASCO
901 West Third Street
Little Rock, Arkansas 72201
501.374.5300

WOODS CARADINE ARCHITECTS
2200 South Main Street
Little Rock, Arkansas 72206
501.374.4060

Landscape Architects
HARGREAVES ASSOCIATES
118 Magazine Street
Cambridge Massachusetts 02139
617.661.0070

LANDSCAPE ARCHITECTURE, Inc
2300 Cottondale Lane Suite 202
Little Rock, Arkansas 72202
501.374.5510

Structural Engineer
LESLIE E. ROBERTSON ASSOC. RLLP
30 Broad Street, 4th Floor
New York, New York 10004
212.750.9000

MEP Engineers
FLACK + KURTZ Inc.
475 Fifth Avenue
New York, New York 10017
212.532.9600


CROMWELL ARCHITECTS ENGINEERS
101 South Spring Street
Little Rock, Arkansas 72201
501.372.2900

Curriculum Consultant
R. A. HEINTGES ARCHITECTS
126 Fifth Avenue 9th Floor
New York, New York 10011
212.632.2995

**100% PLUMBING
CONSTRUCTION DRAWINGS
ISSUE - JULY 1, 2002**



Issue	Date
100% Construction Documents	09/27/02
90% Progress Printing	08/20/02
General Revisions ASI #3	9 Aug 02
Plumbing Contract Documents	07/01/02
100% Design Development	03/01/02

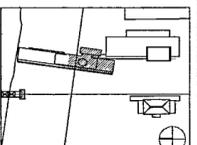

Job No. POLSHEK & PARTNERS ARCH 9908
CROMWELL AE 90-114

Scale 1/8" = 1'-0"

Date JULY 01, 2002


Title EXECUTIVE LEVEL
PLUMBING
PARTIAL PLAN

Sheet No.

P105b



FOR OFFICIAL USE ONLY

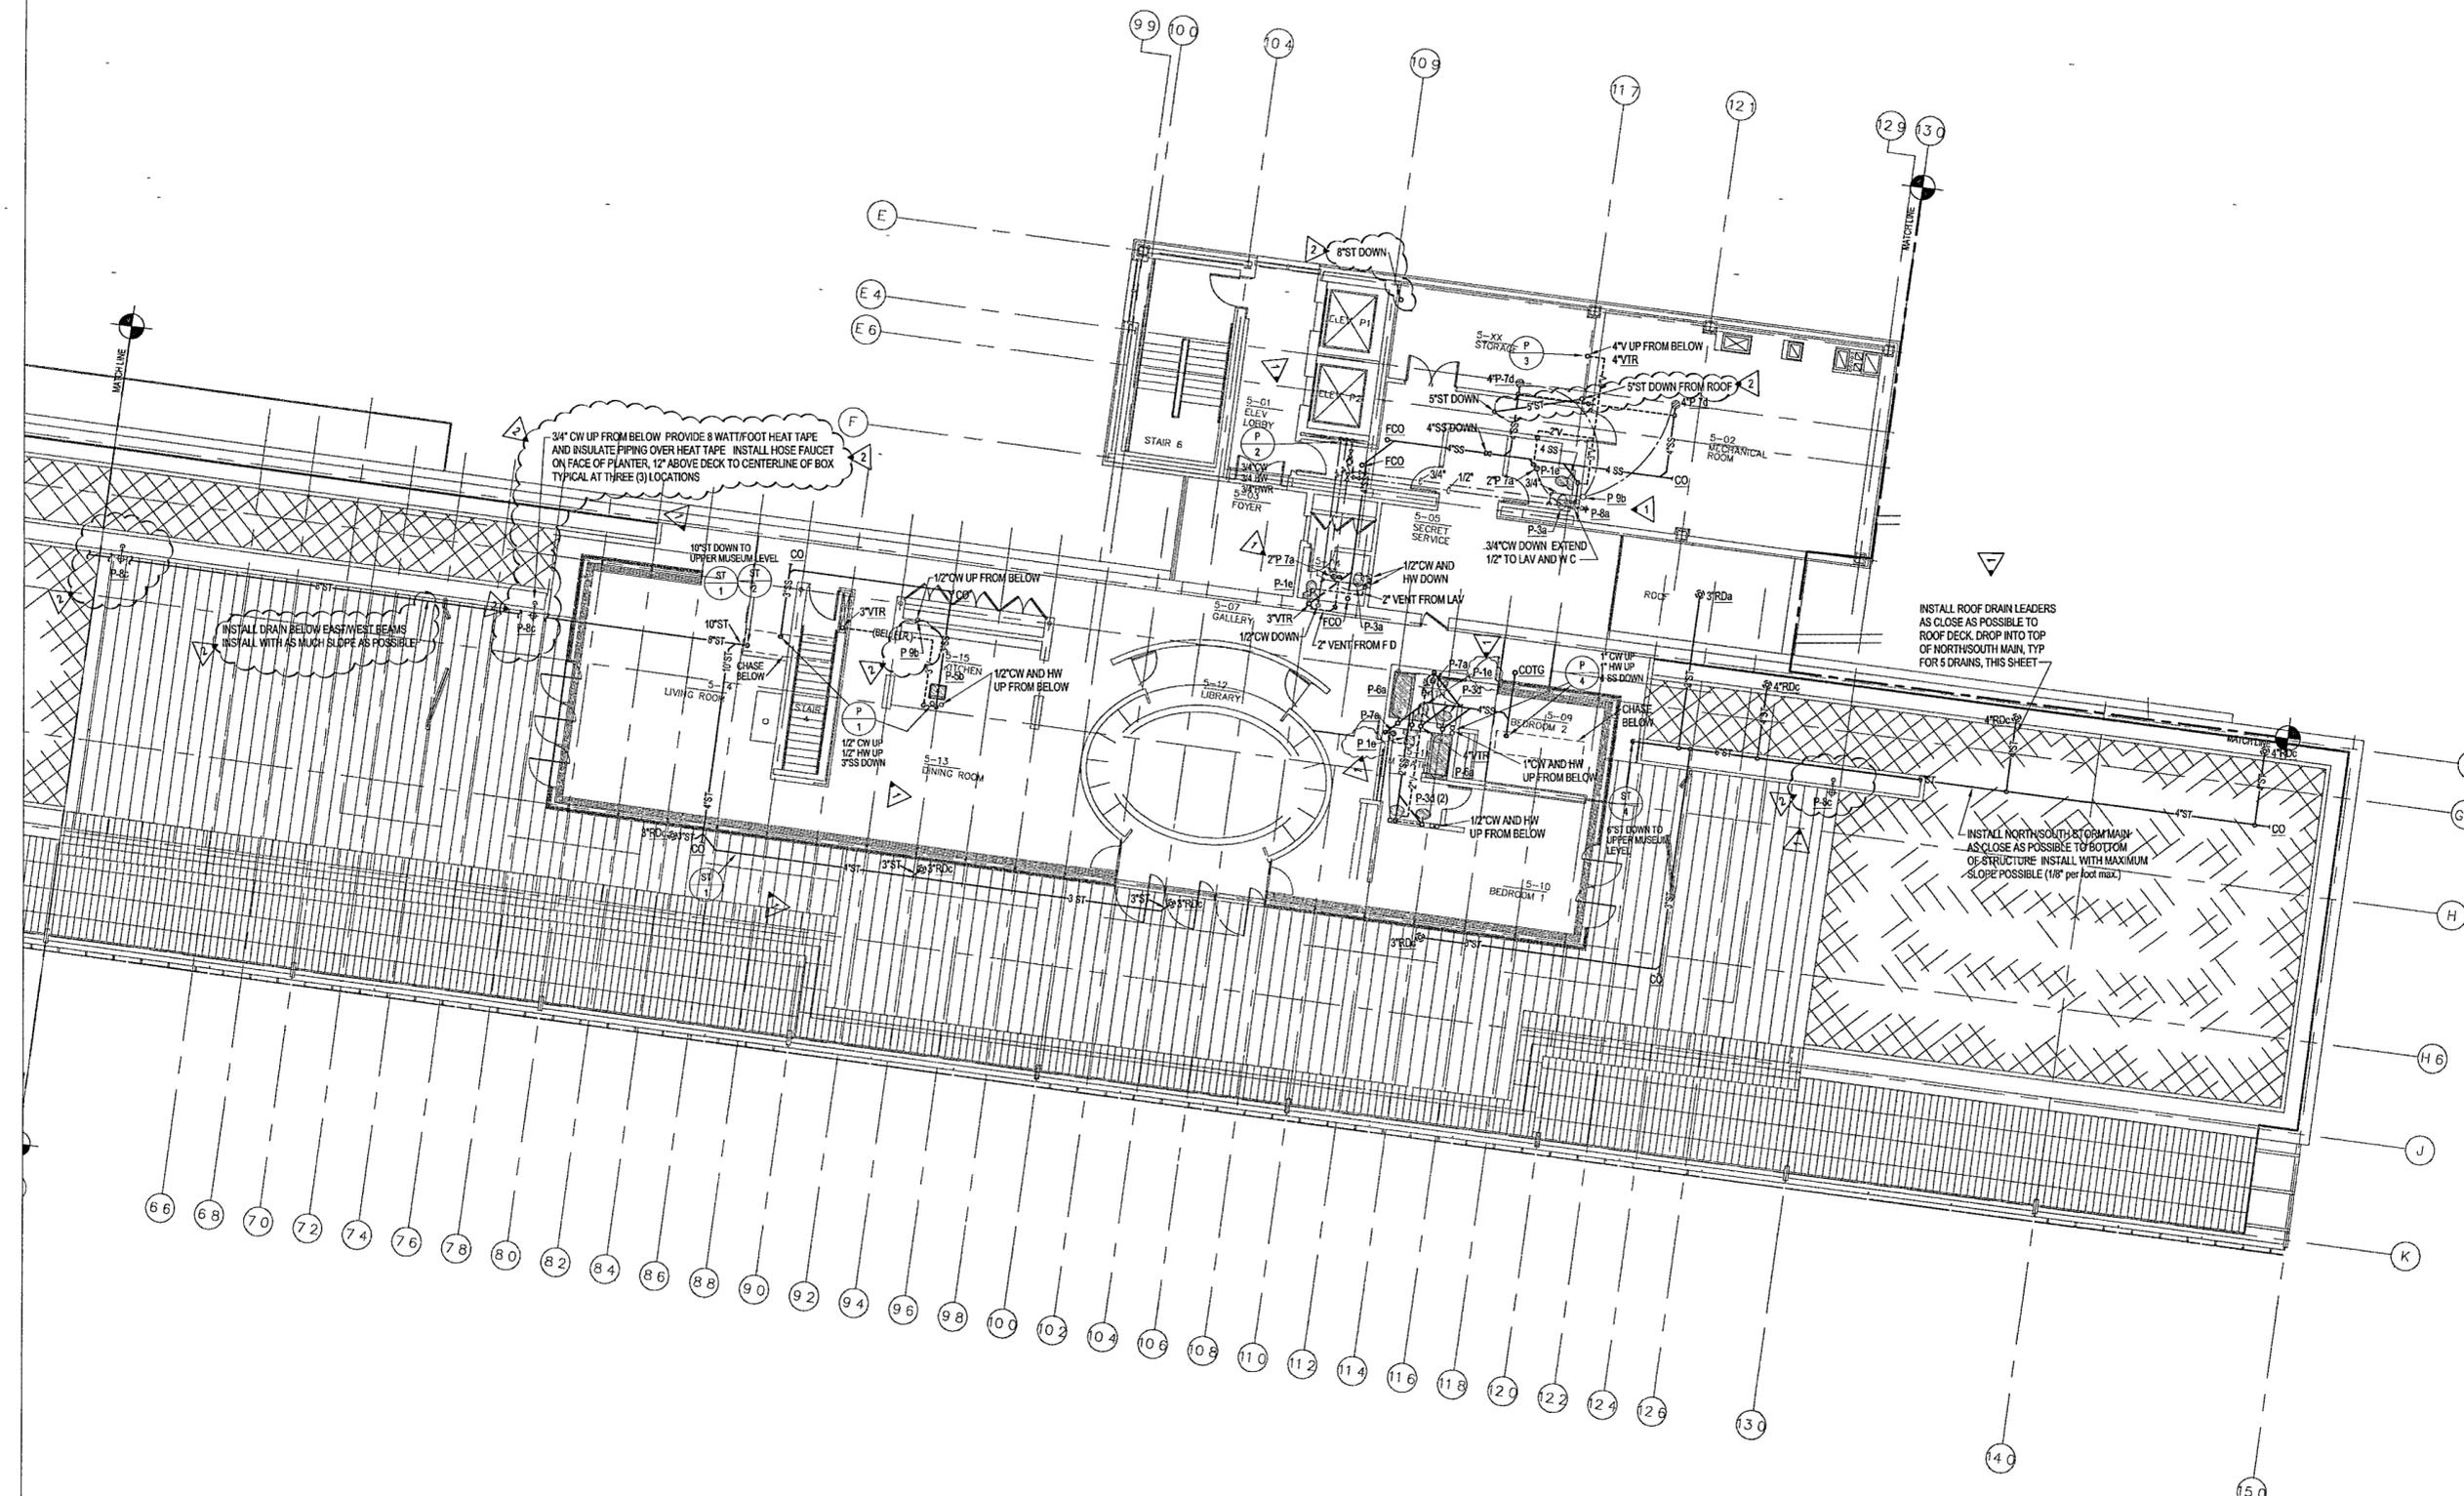

1 EXECUTIVE LEVEL - PLUMBING PLAN

P105b | P105b 1/8" = 1'-0"



154B