


GENERAL NOTES

- 1 ALL OUTLETS ON THIS FLOOR SERVED VIA 1" EC RUN TO NEAREST CABLE TRAY OR TELECOM CLOSET, U O N
- 2 (1) 1" EC TO BE HOME RUN FROM NEAREST TELECOM CLOSET TO EACH ELEVATOR MACHINE ROOM. INSTALL (2) 4-PAIR UTP CABLE TERMINATED ON (2) 8-PIN MODULAR CONNECTORS SEATED IN A STAINLESS STEEL FACEPLATE ON A SURFACE MOUNTED OUTLET BOX INSTALLED ADJACENT TO ELEVATOR CONTROLLER FOR ELEVATOR VOICE SERVICES

NOTES

- | | |
|----------------------------------------------------------------------------------------------------------------------|-----------------------------------------------------------------------------------------------------------------------------------------------------------------------------------------------|
| 1 12" WIDE X 4" DEEP OPEN STEEL MESH FLEXIBLE CABLE TRAY TRAPEZE HUNG FROM CEILING SLAB | 7 1" EC RUN TO INDIVIDUAL OUTLET LOCATIONS ON FLOOR ABOVE (TYP) (QUANTITIES AS REQUIRED) |
| 2 (3) 4" EC TO SECRET SERVICE ROOM ON EXECUTIVE LEVEL | 8 (3) 4" EC STUB UP THRU FLOOR SLAB INTO WALL MOUNTED TELECOMMUNICATIONS PULLBOX CONFIGURED ACCORDING TO U S GOVERNMENT STANDARDS FOR SECURE PATHWAYS PULLBOX SHALL MEASURE 30"W x 60"L x 8"D |
| 3 (1) 4" EC TO SERVE DISTRIBUTION BOX | 9 (6) 4" EC STUB UP THRU FLOOR SLAB |
| 4 TELECOMMUNICATIONS IDF CLOSET (TO SERVE PART OF BASEMENT LEVEL AND GROUND LEVEL OUTLETS IN BUILDING SEGMENT SHOWN) | 10 6" WIDE X 4" DEEP OPEN STEEL MESH FLEXIBLE CABLE TRAY TRAPEZE HUNG FROM CEILING SLAB |
| 5 16" WIDE X 8" DEEP X 60" LONG TELECOMMUNICATIONS DISTRIBUTION BOX (TYP) | |
| 6 (6) 4" EC TO FEED TELECOM IDF CLOSETS IN FLOORS ABOVE AND | |

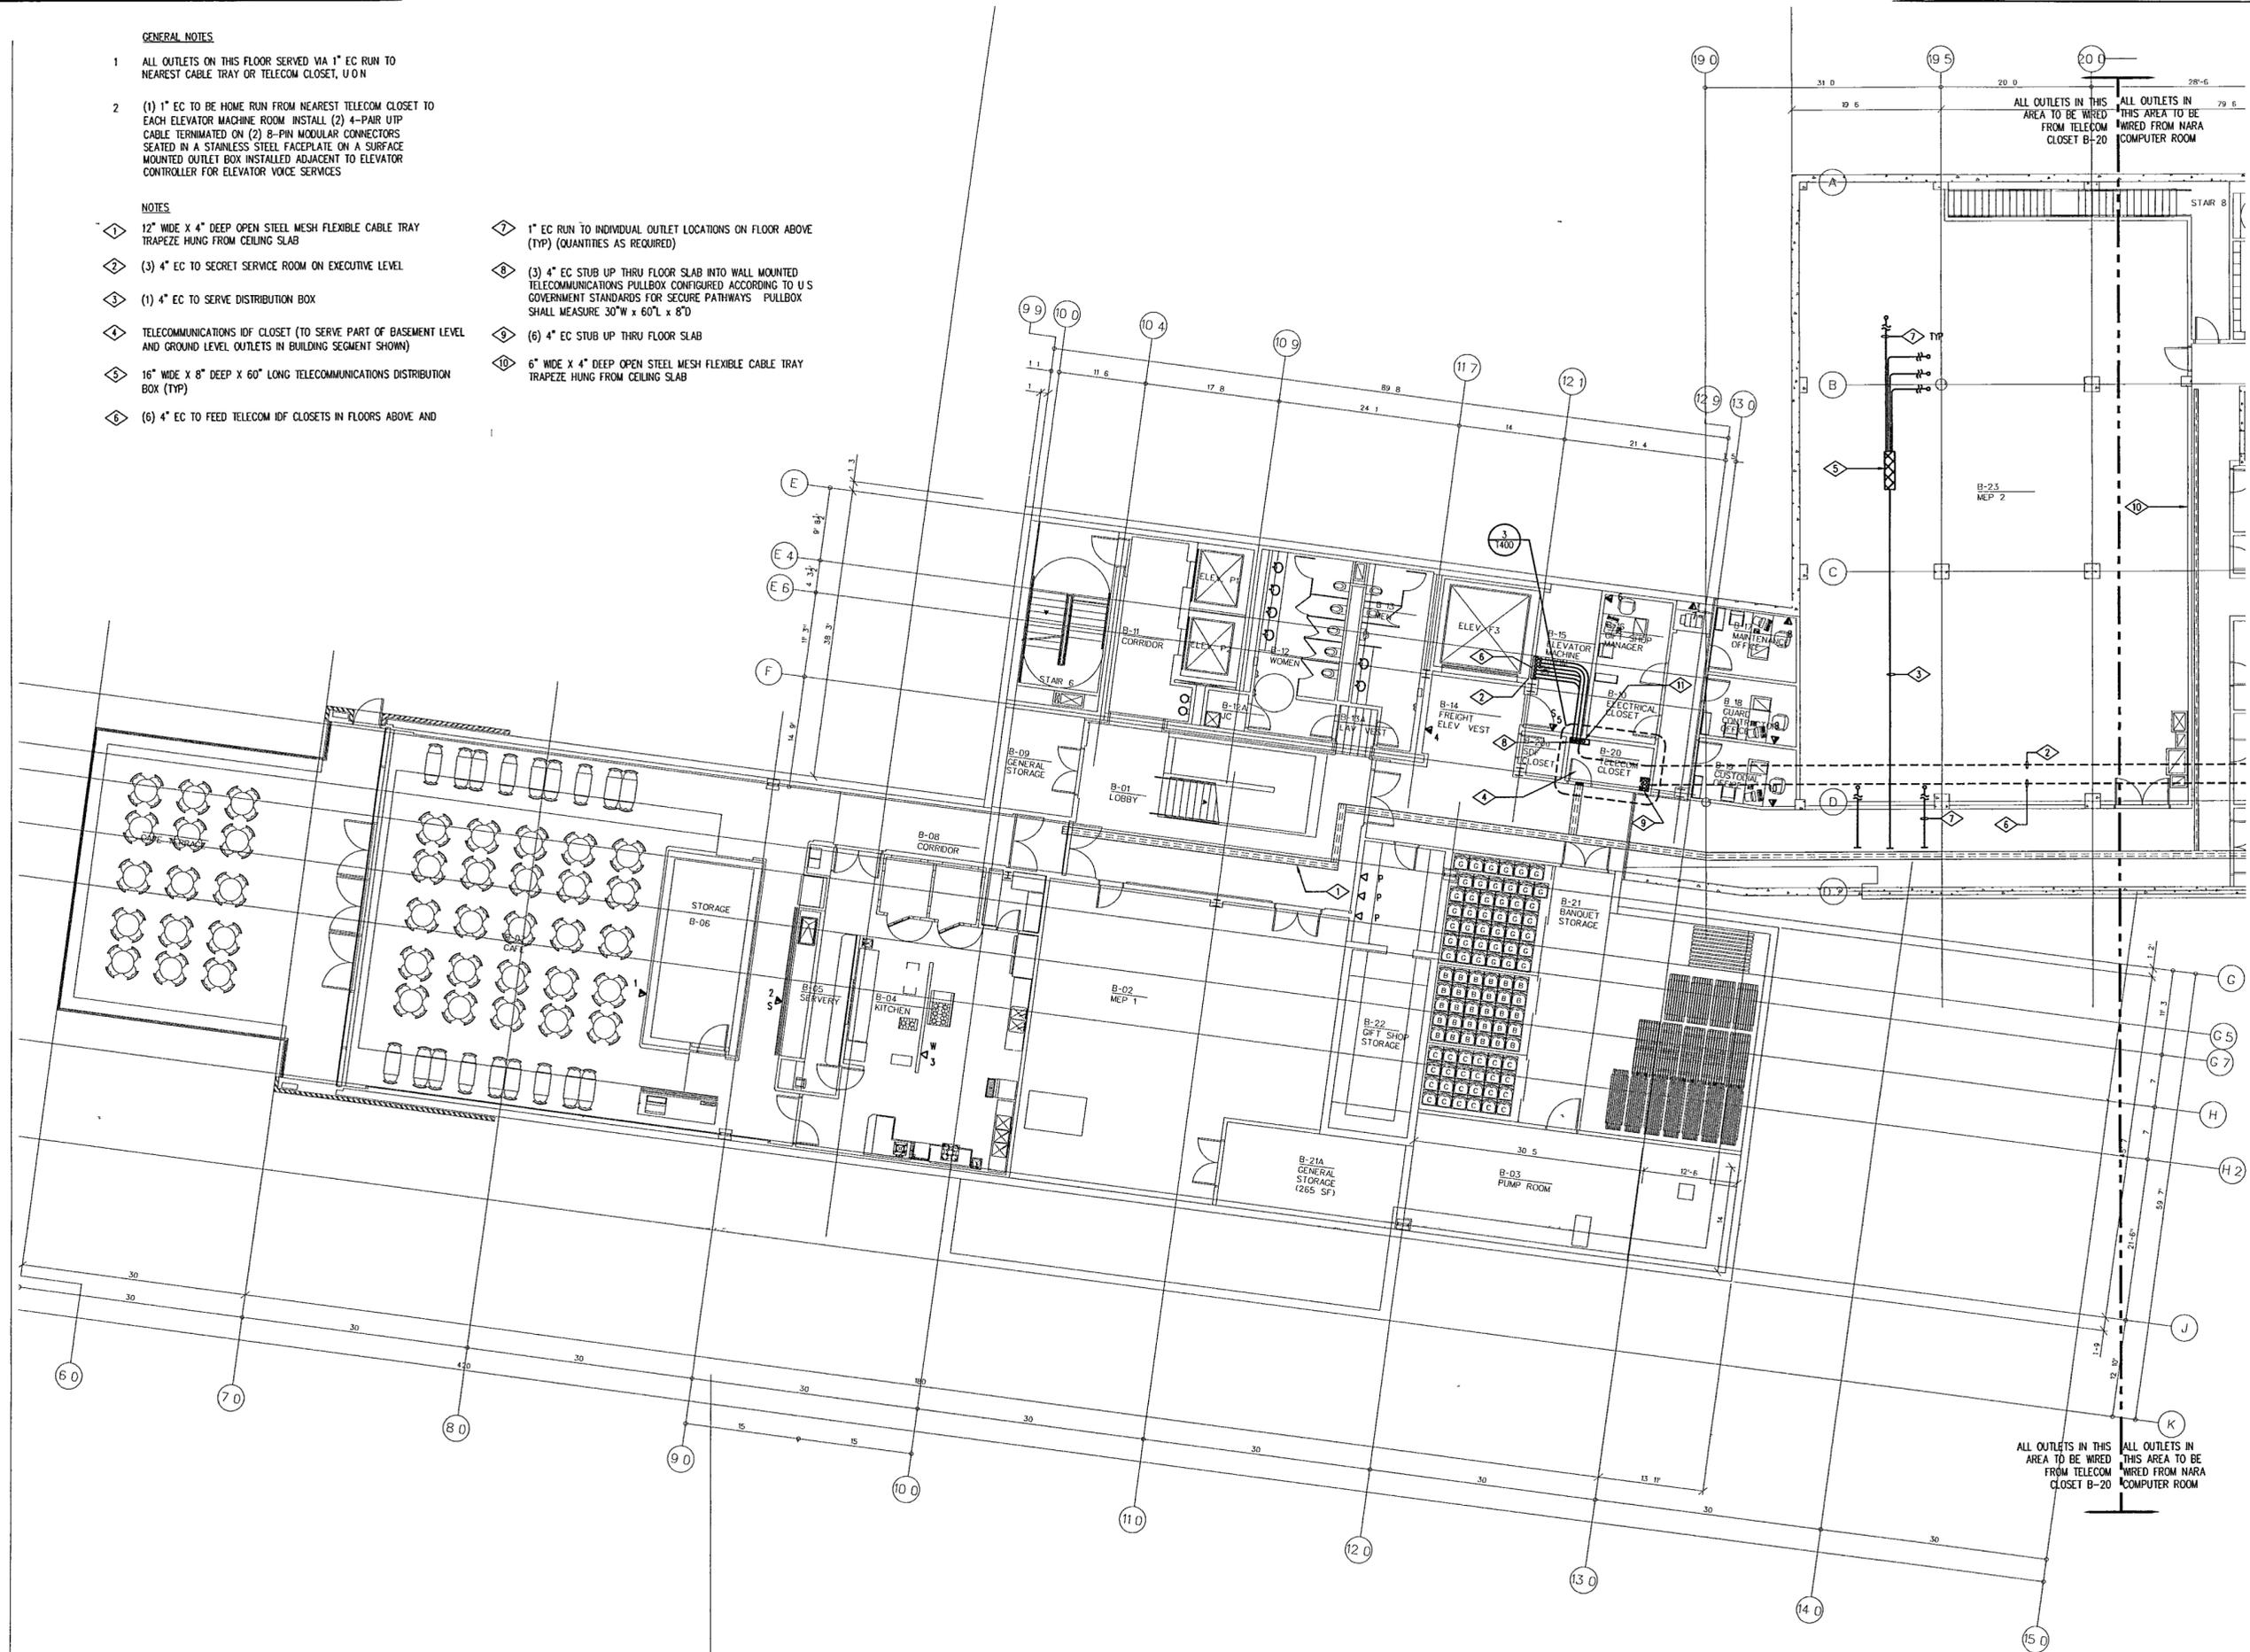

**WILLIAM J. CLINTON
PRESIDENTIAL
CENTER**

LITTLE ROCK, ARKANSAS

Architect
POLSHEK PARTNERSHIP LLP
320 West 13th Street
New York, New York 10014
212.507.7171

Coordinating Architects
POLK STANLEY YEARY ARCHITECTS LTD
700 South Schiller Street
Little Rock, Arkansas 72201
501.574.0678

WITSELL EVANS & RASCO
124 West Capitol Avenue, Suite 1750
Little Rock, Arkansas 72201
501.574.6300

WOODS CARADINE ARCHITECTS
2200 South Main Street
Little Rock, Arkansas 72206
501.574.4080

Landscape Architects
HARGREAVES ASSOCIATES
118 Magazine Street
Cambridge, Massachusetts 02139
617.861.0070

LANDSCAPE ARCHITECTURE, Inc.
400 West Capitol Avenue
Suite 1000 Regions Center
Little Rock, Arkansas 72201
501.574.5910

Structural Engineer
LESLIE E. ROBERTSON ASSOC., RLLP
30 Broad Street, 47th Floor
New York, New York 10004
212.750.9000

MEP Engineers
FLACK + KURTZ Inc.
475 Fifth Avenue
New York, New York 10017
212.632.9000

CROMWELL ARCHITECTS ENGINEERS
101 South Spring Street
Little Rock, Arkansas 72201
501.572.2900

100% Construction Documents 09/27/02
90% Progress Printing 08/30/02
100% Design Development 03/01/02

Issue Date

Job No 9908
Scale 1/8"=1'-0"
Date September 27, 2002
Title **BASEMENT LEVEL
TELECOM PLAN**
Sheet No **T300b**

FOR OFFICIAL USE ONLY