

**WILLIAM J. CLINTON
PRESIDENTIAL
CENTER**

LITTLE ROCK, ARKANSAS

Architect
POLSHAK PARTNERSHIP LLP
320 West 15th Street
New York, New York 10014
212.807.7171

Coordinating Architects
POLK STANLEY YEARY ARCHITECTS LTD
700 South Schiller Street
Little Rock, Arkansas 72201
501.378.0578

WITSELL EVANS & RASCO
124 West Capitol Avenue, Suite 1750
Little Rock, Arkansas 72201
501.374.5300

WOODS CARADINE ARCHITECTS
2200 South Main Street
Little Rock, Arkansas 72206
501.374.4000

Landscape Architects
HARGREAVES ASSOCIATES
118 Magazine Street
Cambridge, Massachusetts 02139
617.861.0070


LANDSCAPE ARCHITECTURE, Inc.
400 West Capitol Avenue
Suite 1000 Regional Center
Little Rock, Arkansas 72201
501.374.5510

Structural Engineer
LESLIE E. ROBERTSON ASSOC., RLLP
30 Broad Street, 47th Floor
New York, New York 10004
212.760.9000

MEP Engineers
FLACK + KURTZ Inc.
478 Fifth Avenue
New York, New York 10017
212.852.8600


CROMWELL ARCHITECTS ENGINEERS
101 South Spring Street
Little Rock, Arkansas 72201
501.372.2300

- NOTES**
- 1 ALL OUTLETS IN THIS AREA SERVED VIA DISTRIBUTION BOXES IN BASEMENT LEVEL OR VIA INDIVIDUAL 1" EC TO TELECOM CLOSET B-20
 - 2 (6) 4" EC TO SERVE TELECOM CLOSETS ABOVE
 - 3 (3) 4" EC TO SECRET SERVICE ROOM ON EXECUTIVE LEVEL
 - 4 (2) 3" EC FROM EXHIBIT ROOM ABOVE TO BROADCAST BOX AT BUILDING EXTERIOR
 - 5 15" WIDE X 60" LONG X 6" DEEP PULL BOX MOUNTED TIGHT TO CEILING WITH HINGED COVER OPENING DOWNWARD
 - 6 WEATHERPROOF PULL BOX WITH LOCKABLE COVER, FOR AV BROADCAST (PULL BOX FURNISHED AND INSTALLED BY AV CONTRACTOR)

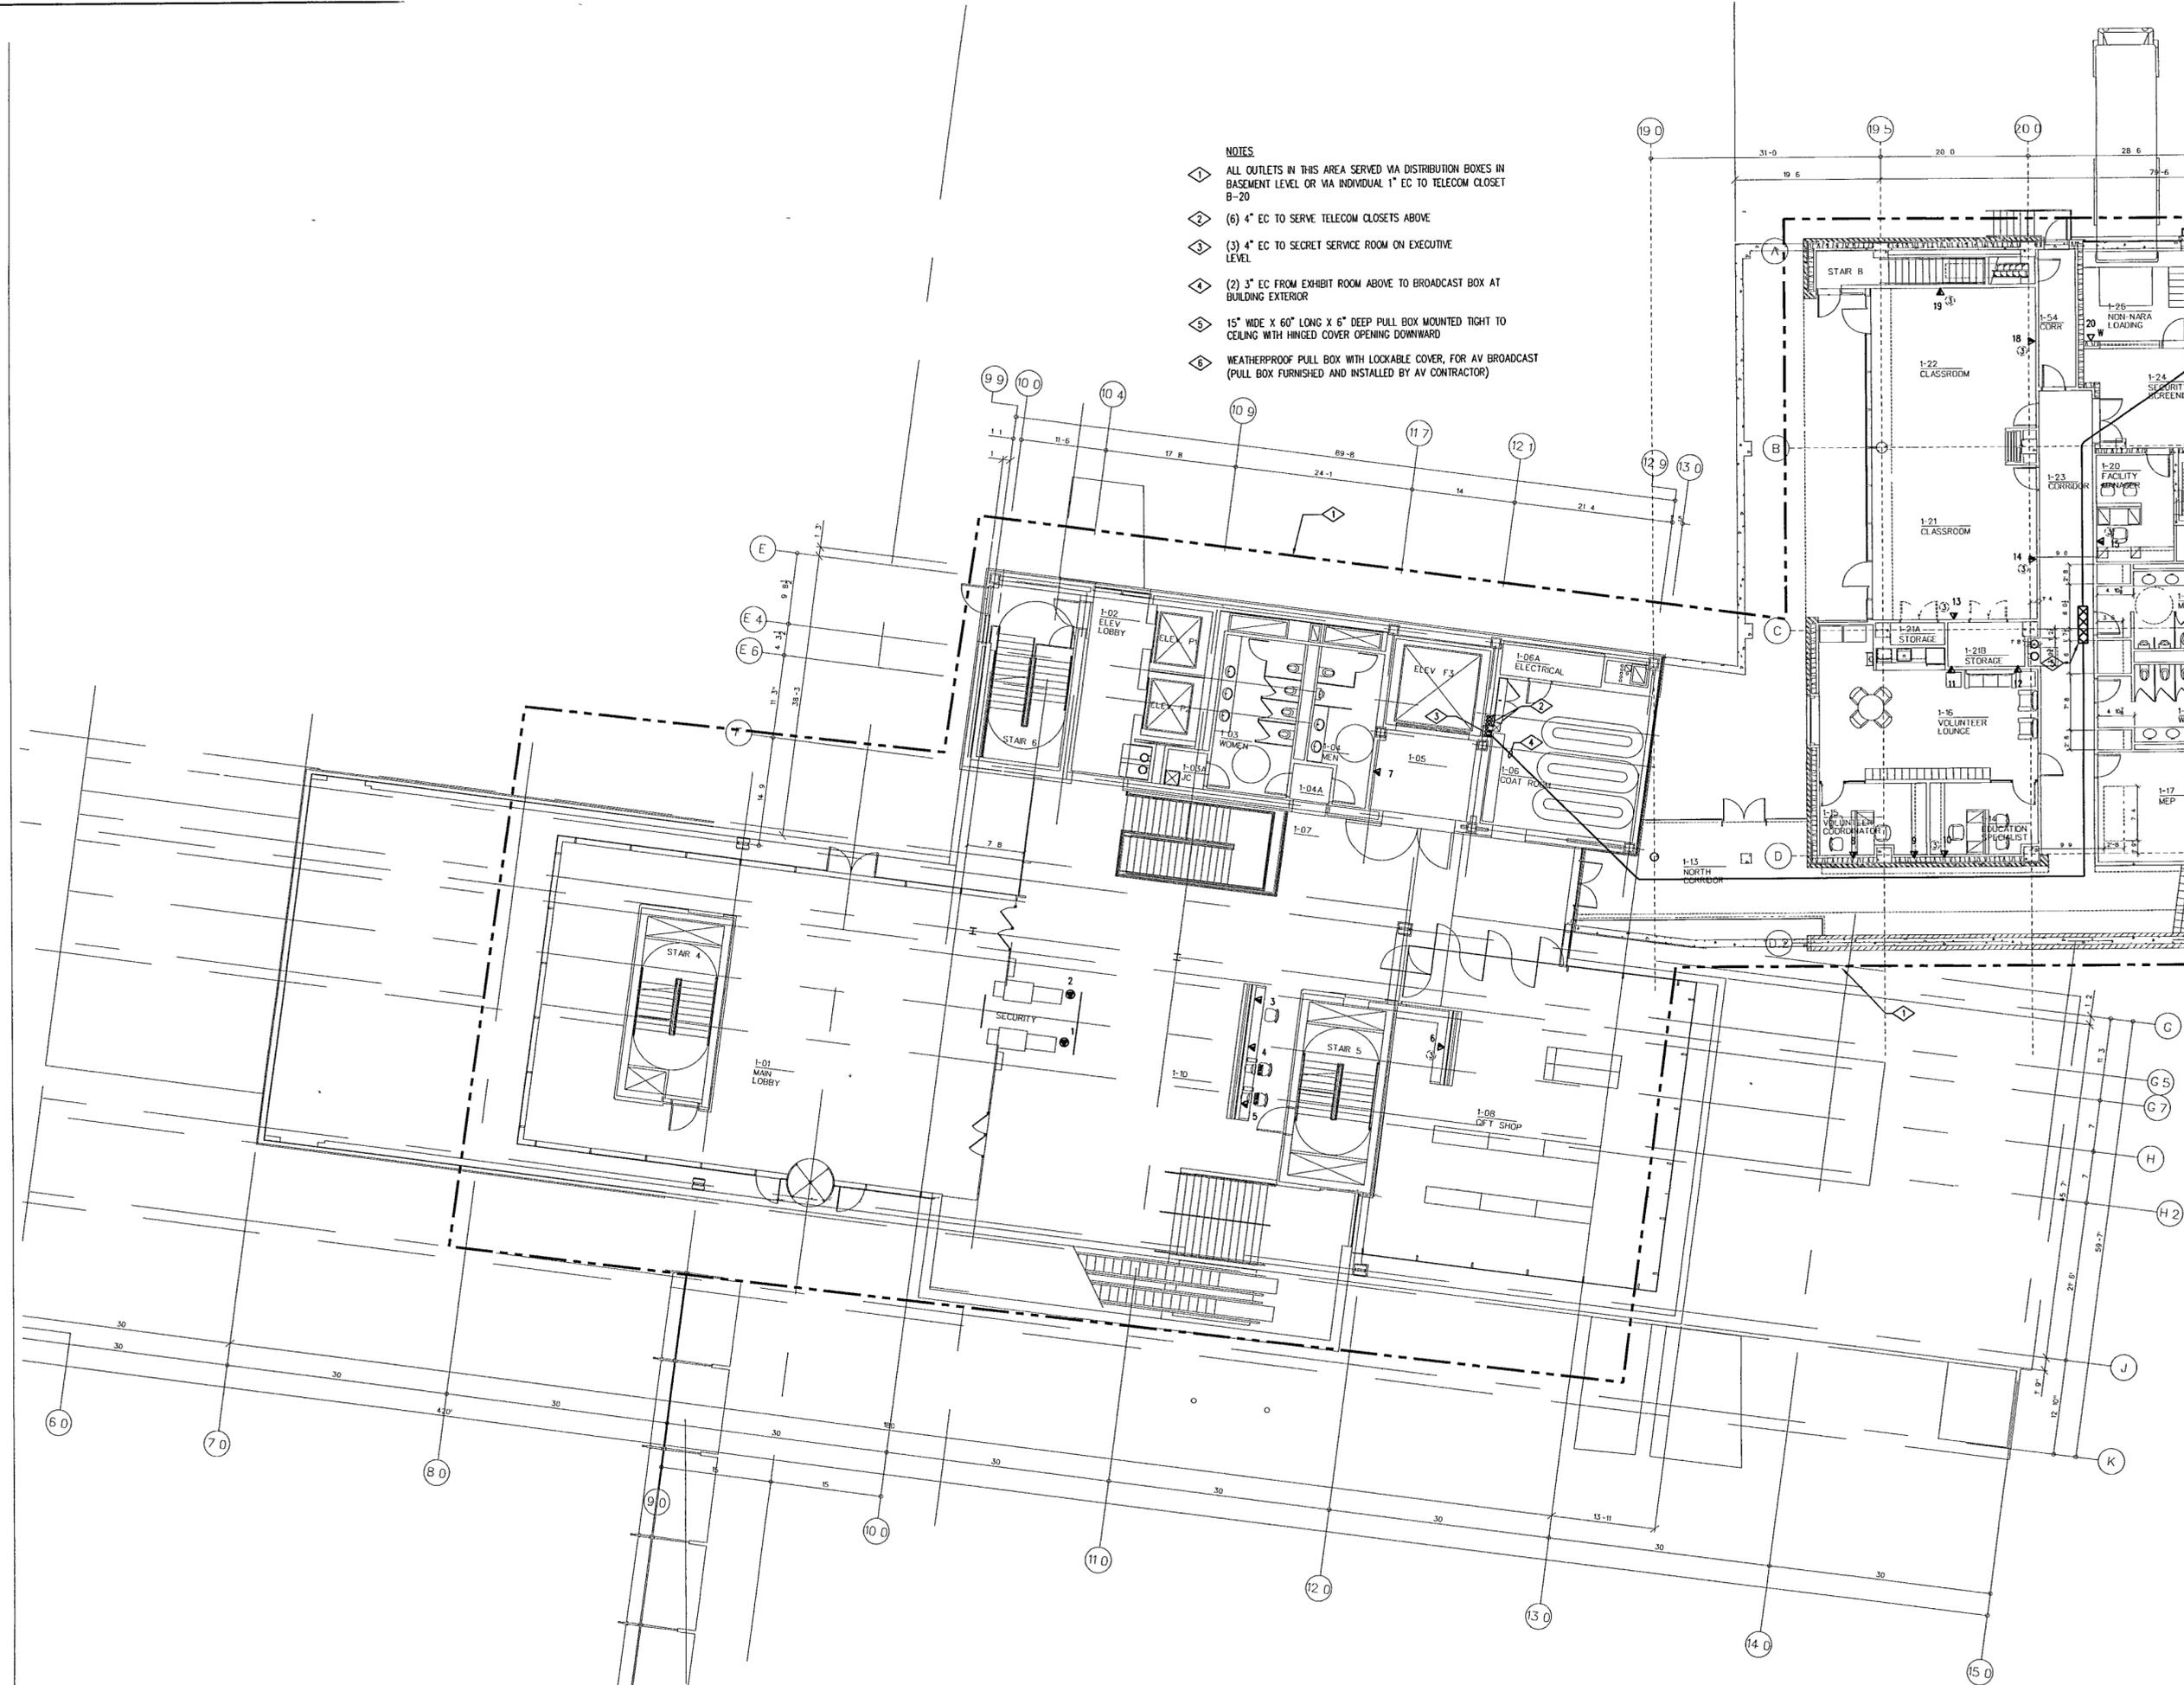

Seal

Issue	Date
100% Construction Documents	09/27/02
90% Progress Printing	08/30/02
100% Design Development	03/01/02

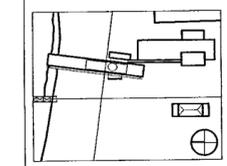

Job No 9908
Scale 1/8"=1'-0"
Date September 27, 2002
Title **GROUND LEVEL
TELECOM PLAN**
Sheet No **T301b**

FOR OFFICIAL USE ONLY