


GENERAL NOTES

- 1 J-HOOKS TO BE INSTALLED ABOVE ACCESSIBLE CEILINGS ONLY, EVERY 5' ON CENTER NO MORE THAN 25 CABLES TO BE SUPPORTED BY AN INDIVIDUAL J-HOOK
- 2 SEE ARCHITECTURAL DRAWINGS FOR OUTLET LOCATIONS

NOTES

- ① (3) 4" EC FROM FLOOR BELOW
- ② 12" WDE X 2" DEEP FLEXIBLE STEEL MESH CABLE TRAY
- ③ PATHWAY OF 'J' HOOKS (TYP)
- ④ (1) 4" EC TO FLOOR ABOVE

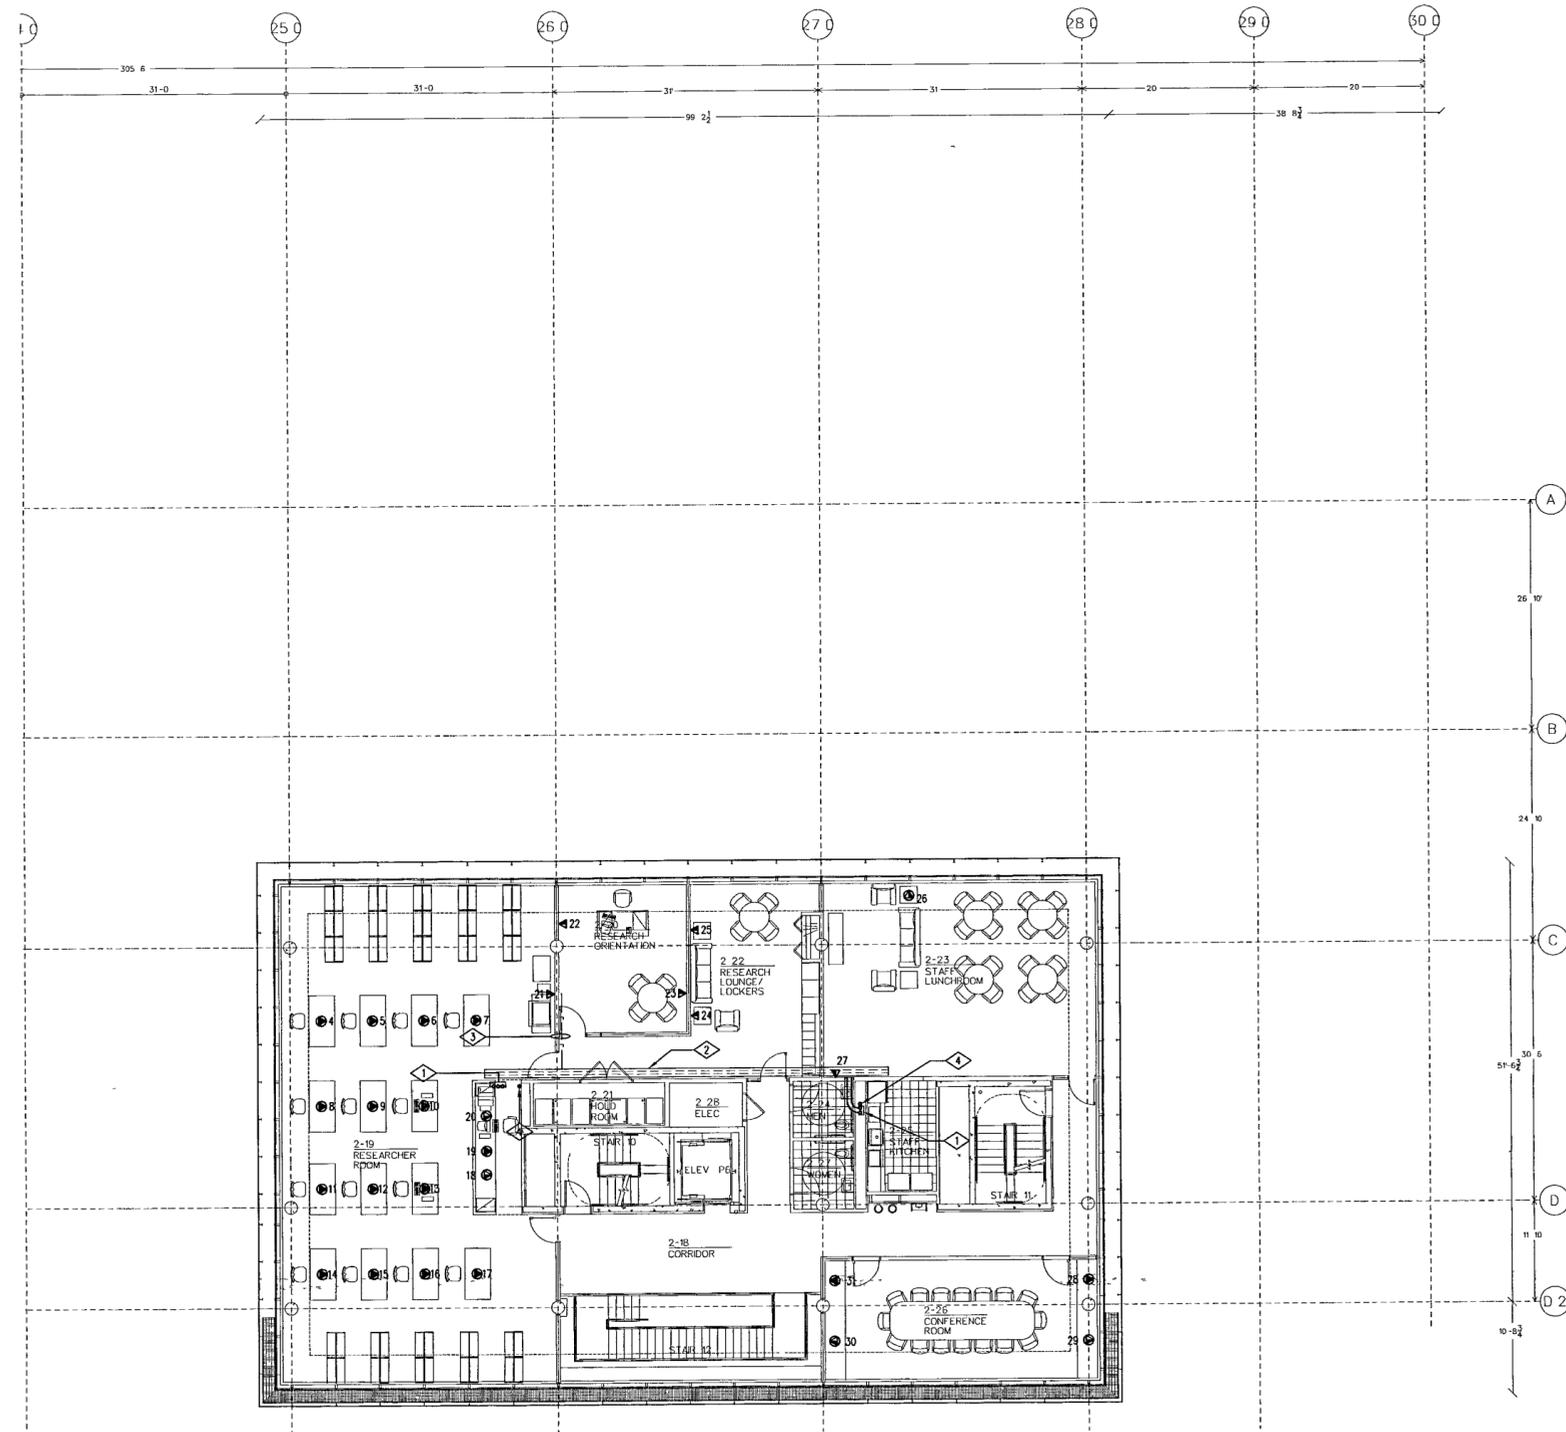

**WILLIAM J. CLINTON
PRESIDENTIAL
CENTER**

LITTLE ROCK, ARKANSAS

Architect
POLSHKE PARTNERSHIP LLP
320 West 13th Street
New York, New York 10014
212.607.7171

Coordinating Architects
POLK STANLEY YEARY ARCHITECTS LLP
700 South Schiller Street
Little Rock, Arkansas 72201
501.378.0678

WITBELL EVANS & RASCO
124 West Capitol Avenue, Suite 1750
Little Rock, Arkansas 72201
501.374.8300

WOODS CARADINE ARCHITECTS
2200 South Main Street
Little Rock, Arkansas 72206
501.374.4080

Landscape Architects
HARGREAVES ASSOCIATES
118 Magazine Street
Cambridge, Massachusetts 02139
617.861.0070

LANDSCAPE ARCHITECTURE, Inc.
400 West Capitol Avenue
Suite 1000 Regions Center
Little Rock, Arkansas 72201
501.374.5510


Structural Engineer
LESLIE E. ROBERTSON ASSOC., PLLP
30 Broad Street, 47th Floor
New York, New York 10004
212.750.9000

MEP Engineers
FLACK + KURTZ Inc.
475 Fifth Avenue
New York, New York 10017
212.632.9600

CRONWELL ARCHITECTS ENGINEERS
101 South Spring Street
Little Rock, Arkansas 72201
501.372.2900

Seal

| Issue | Date |
|-----------------------------|----------|
| 100% Construction Documents | 09/27/02 |
| 90% Progress Printing | 08/30/02 |
| 100% Design Development | 03/01/02 |
| Issue | Date |

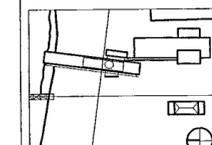

Job No 9908

Scale 1/8"=1'-0"

Date September 27, 2002

Title **SECOND LEVEL
TELECOM PLAN**

Sheet No **T302d**

FOR OFFICIAL USE ONLY