

WILLIAM J. CLINTON  
PRESIDENTIAL  
CENTER

LITTLE ROCK, ARKANSAS

Architect  
POLSHEK PARTNERSHIP LLP  
320 West 13th Street  
New York, New York 10014  
212.607.7171

Coordinating Architects  
POLK STANLEY YEARY ARCHITECTS LTD  
700 South Schiller Street  
Little Rock, Arkansas 72201  
501.378.0678

WITSELL EVANS & RASCO  
124 West Capitol Avenue, Suite 1750  
Little Rock, Arkansas 72201  
501.374.5300

WOODS CARADINE ARCHITECTS  
2200 South Main Street  
Little Rock, Arkansas 72206  
501.374.4000

Landscape Architects  
HARGREAVES ASSOCIATES  
118 Magazine Street  
Cambridge, Massachusetts 02139  
617.861.0070

LANDSCAPE ARCHITECTURE, Inc.  
400 West Capitol Avenue  
Suite 1500 Regency Center  
Little Rock, Arkansas 72201  
501.374.8810


Structural Engineer  
LESLIE E. ROBERTSON ASSOC., RLLP  
30 Broad Street, 47th Floor  
New York, New York 10004  
212.750.9000

MEP Engineers  
FLACK + KURTZ Inc.  
475 Fifth Avenue  
New York, New York 10017  
212.532.9000

CRONWELL ARCHITECTS ENGINEERS  
101 South Spring Street  
Little Rock, Arkansas 72201  
501.372.2900

Seal

Issue	Date
100% Construction Documents	09/27/02
90% Progress Printing	08/30/02
100% Design Development	03/01/02

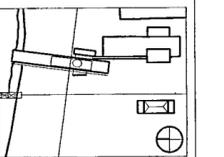

Job No. 9908

Scale 1/8"=1'-0"


Date September 27, 2002

Title

MUSEUM  
LOWER LEVEL  
TELECOM PLAN

Sheet No.

T303a

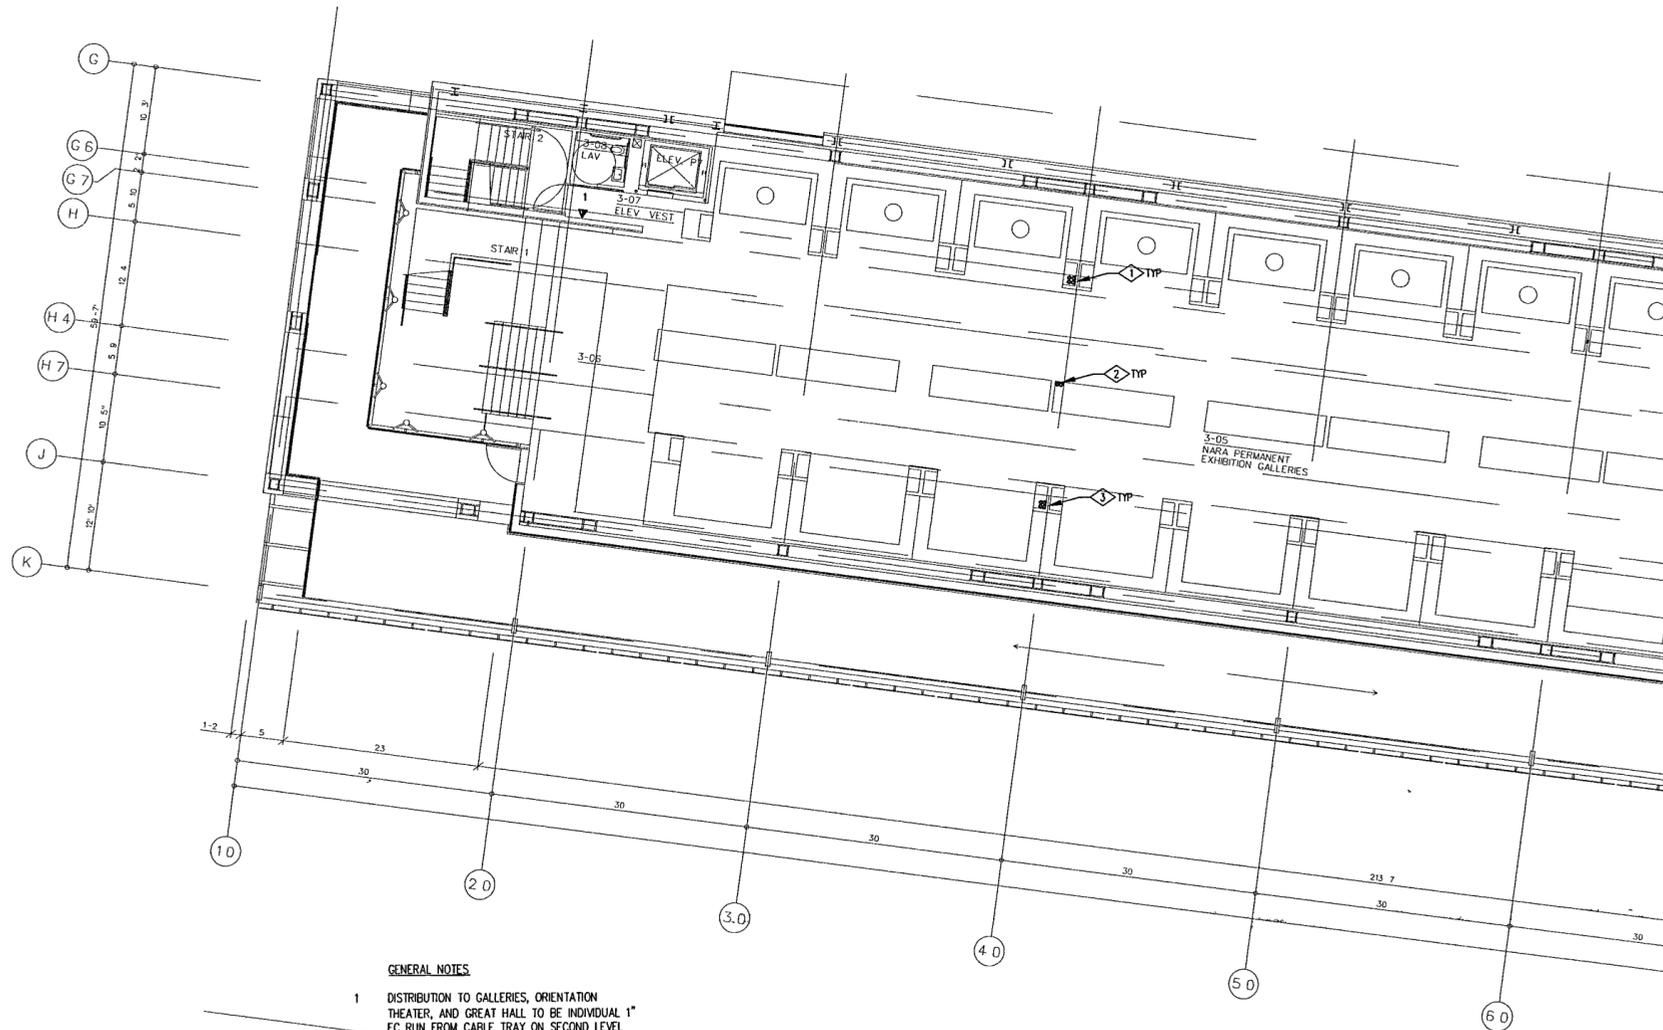

GENERAL NOTES

- 1 DISTRIBUTION TO GALLERIES, ORIENTATION THEATER, AND GREAT HALL TO BE INDIVIDUAL 1" EC RUN FROM CABLE TRAY ON SECOND LEVEL
  - 2 SEE ARCHITECTURAL DRAWINGS FOR OUTLET LOCATIONS
  - 3 SEE RAA DRAWINGS FOR EXHIBIT DISPLAY LOCATIONS
- ◇ (4) 1" EC FOR LOW VOLTAGE CABLES STUBBED UP FROM CABLE TRAY ON LOWER LEVEL TO EXHIBIT ALCOVE PIER ON MUSEUM LOWER LEVEL
  - ◇ (2) 1" EC FOR TIME LINE EXHIBIT UNITS CONDUITS TO RUN FROM CABLE TRAY WITHIN MUSEUM LOWER LEVEL FLOOR SLAB AND STUB UP UNDER DISPLAY CASE
  - ◇ (4) 1" EC FOR LOW VOLTAGE CABLES TO WEST EXHIBIT ALCOVES ON MUSEUM LEVEL CONDUITS TO RUN FROM CABLE TRAY WITHIN MUSEUM LOWER LEVEL SLAB AND STUB UP AT EXHIBIT ALCOVE PIER ON WEST SIDE