

**WILLIAM J CLINTON
PRESIDENTIAL
CENTER**

LITTLE ROCK, ARKANSAS

Architect
POLSHAK PARTNERSHIP LLP
320 West 136 Street
New York, New York 10014
212.807.7171

Coordinating Architects
POLK STANLEY YEARY ARCHITECTS Ltd
700 South Schiller Street
Little Rock, Arkansas 72201
501.378.0878

WITSELL EVANS & RASCO
124 West Capitol Avenue, Suite 1750
Little Rock, Arkansas 72201
501.374.6300

WOODS CARADINE ARCHITECTS
2200 South Main Street
Little Rock, Arkansas 72206
501.374.4060

Landscape Architects
HARGREAVES ASSOCIATES
118 Magazine Street
Cambridge, Massachusetts 02139
617.861.5070

LANDSCAPE ARCHITECTURE, Inc.
400 West Capitol Avenue
Suite 1000 Ferguson Center
Little Rock, Arkansas 72201
501.374.6610


Structural Engineer
LESLIE E. ROBERTSON ASSOC., RLLP
30 Broad Street, 47th Floor
New York, New York 10004
212.760.9000

MEP Engineers
FLACK + KURTZ Inc.
475 Fifth Avenue
New York, New York 10017
212.682.9900

CROMWELL ARCHITECTS ENGINEERS
101 South Spring Street
Little Rock, Arkansas 72201
501.372.2300

Seal


Issue	Date
100% Construction Documents	09/27/02
90% Progress Printing	08/30/02
100% Design Development	03/01/02

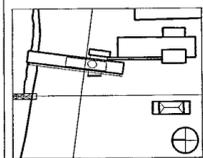

Job No. 9908
Scale 1/8"=1'-0"
Date September 27, 2002

Title
**MUSEUM
LOWER LEVEL
TELECOM PLAN**

Sheet No.
T303d

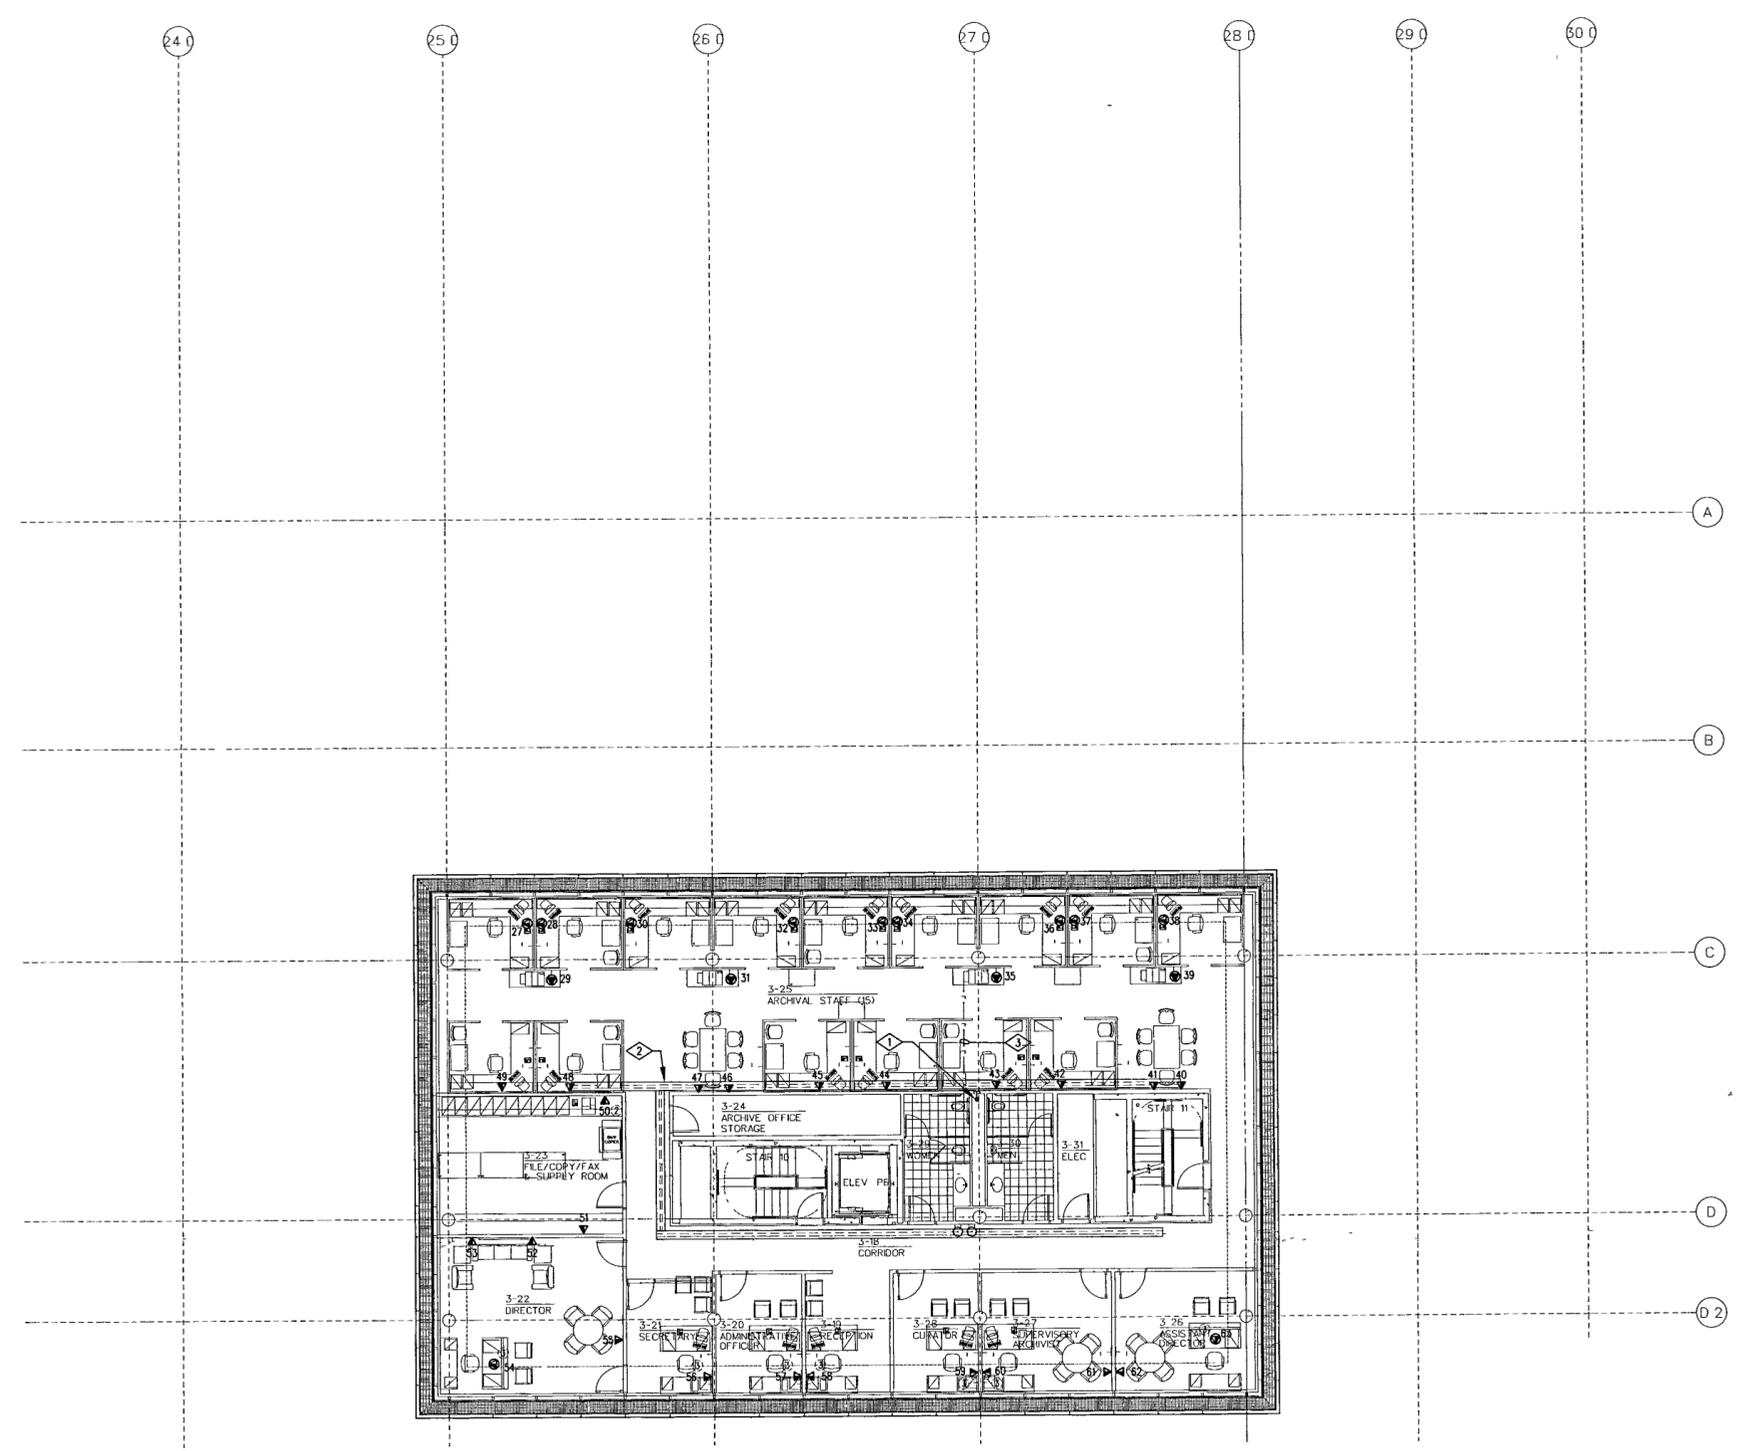

- GENERAL NOTES**
- J-HOOKS TO BE INSTALLED ABOVE ACCESSIBLE CEILINGS ONLY, EVERY 5' ON CENTER. NO MORE THAN 25 CABLES TO BE SUPPORTED BY AN INDIVIDUAL J-HOOK
 - SEE ARCHITECTURAL DRAWINGS FOR OUTLET LOCATIONS
- NOTES**
- ① (1) 4" EC FROM LEVEL BELOW
 - ② 12" WIDE X 2" DEEP FLEXIBLE STEEL MESH CABLE TRAY
 - ③ PATHWAY OF 'J' HOOKS (TYP)

96b1

FOR OFFICIAL USE ONLY