

**WILLIAM J. CLINTON  
PRESIDENTIAL  
CENTER**

LITTLE ROCK, ARKANSAS

Architect  
**POLSHKE PARTNERSHIP LLP**  
320 West 13th Street  
New York, New York 10014  
212.807.7171

Coordinating Architects  
**POLK STANLEY YEARY ARCHITECTS LTD**  
700 South Schiller Street  
Little Rock, Arkansas 72201  
501.378.0678

**WITSELL EVANS & RASCO**  
124 West Capitol Avenue, Suite 1750  
Little Rock, Arkansas 72201  
501.374.5300

**WOODS CARADINE ARCHITECTS**  
2200 South Main Street  
Little Rock, Arkansas 72208  
501.374.4000

Landscape Architects  
**HARGREAVES ASSOCIATES**  
118 Magazines Street  
Cambridge, Massachusetts 02139  
617.861.0070

**LANDSCAPE ARCHITECTURE, Inc.**  
400 West Capitol Avenue  
Suite 1000 Regions Center  
Little Rock, Arkansas 72201  
501.374.5810


Structural Engineer  
**LESLIE E. ROBERTSON ASSOC., RLLP**  
30 Broad Street, 47th Floor  
New York, New York 10004  
212.750.9000

MEP Engineers  
**FLACK + KURTZ Inc.**  
478 Fifth Avenue  
New York, New York 10017  
212.632.9800

**CROMWELL ARCHITECTS ENGINEERS**  
101 South Spring Street  
Little Rock, Arkansas 72201  
501.372.2800

Seal

100% Construction Documents	09/27/02
90% Progress Printing	08/30/02
100% Design Development	03/01/02
Issue	Date

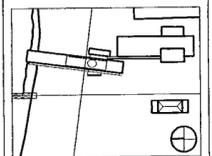

Job No. 9908

Scale 1/8"=1'-0"

Date September 27, 2002

Title  
**EXECUTIVE LEVEL  
TELECOM PLAN**


Sheet No.  
**T305b**

**GENERAL NOTES**

- 1 DISTRIBUTION TO VOICE AND DATA OUTLETS TO BE VIA 1" ID CONDUITS HOMERUN TO TELECOM CLOSET
- 2 SEE ARCHITECTURAL DRAWINGS FOR OUTLET LOCATIONS

**NOTES**

- 1 (3) 4" EC FOR SECRET SERVICE RISING FROM TELECOM SERVICE ENTRANCE ROOM
- 2 (2) 4" EC TO TELECOM EQUIPMENT IN STORAGE ROOM
- 3 30" WIDE X 60" LONG X 8" DEEP WALL MOUNTED TELECOMMUNICATIONS PULLBOX CONFIGURED ACCORDING TO GOVERNMENT STANDARDS FOR SECURE PATHWAYS
- 4 12" WIDE X 4" DEEP STEEL MESH FLEXIBLE CABLE TRAY
- 5 (2) 4" EC FROM TELECOM EQUIPMENT IN STORAGE ROOM TO CABLE TRAY

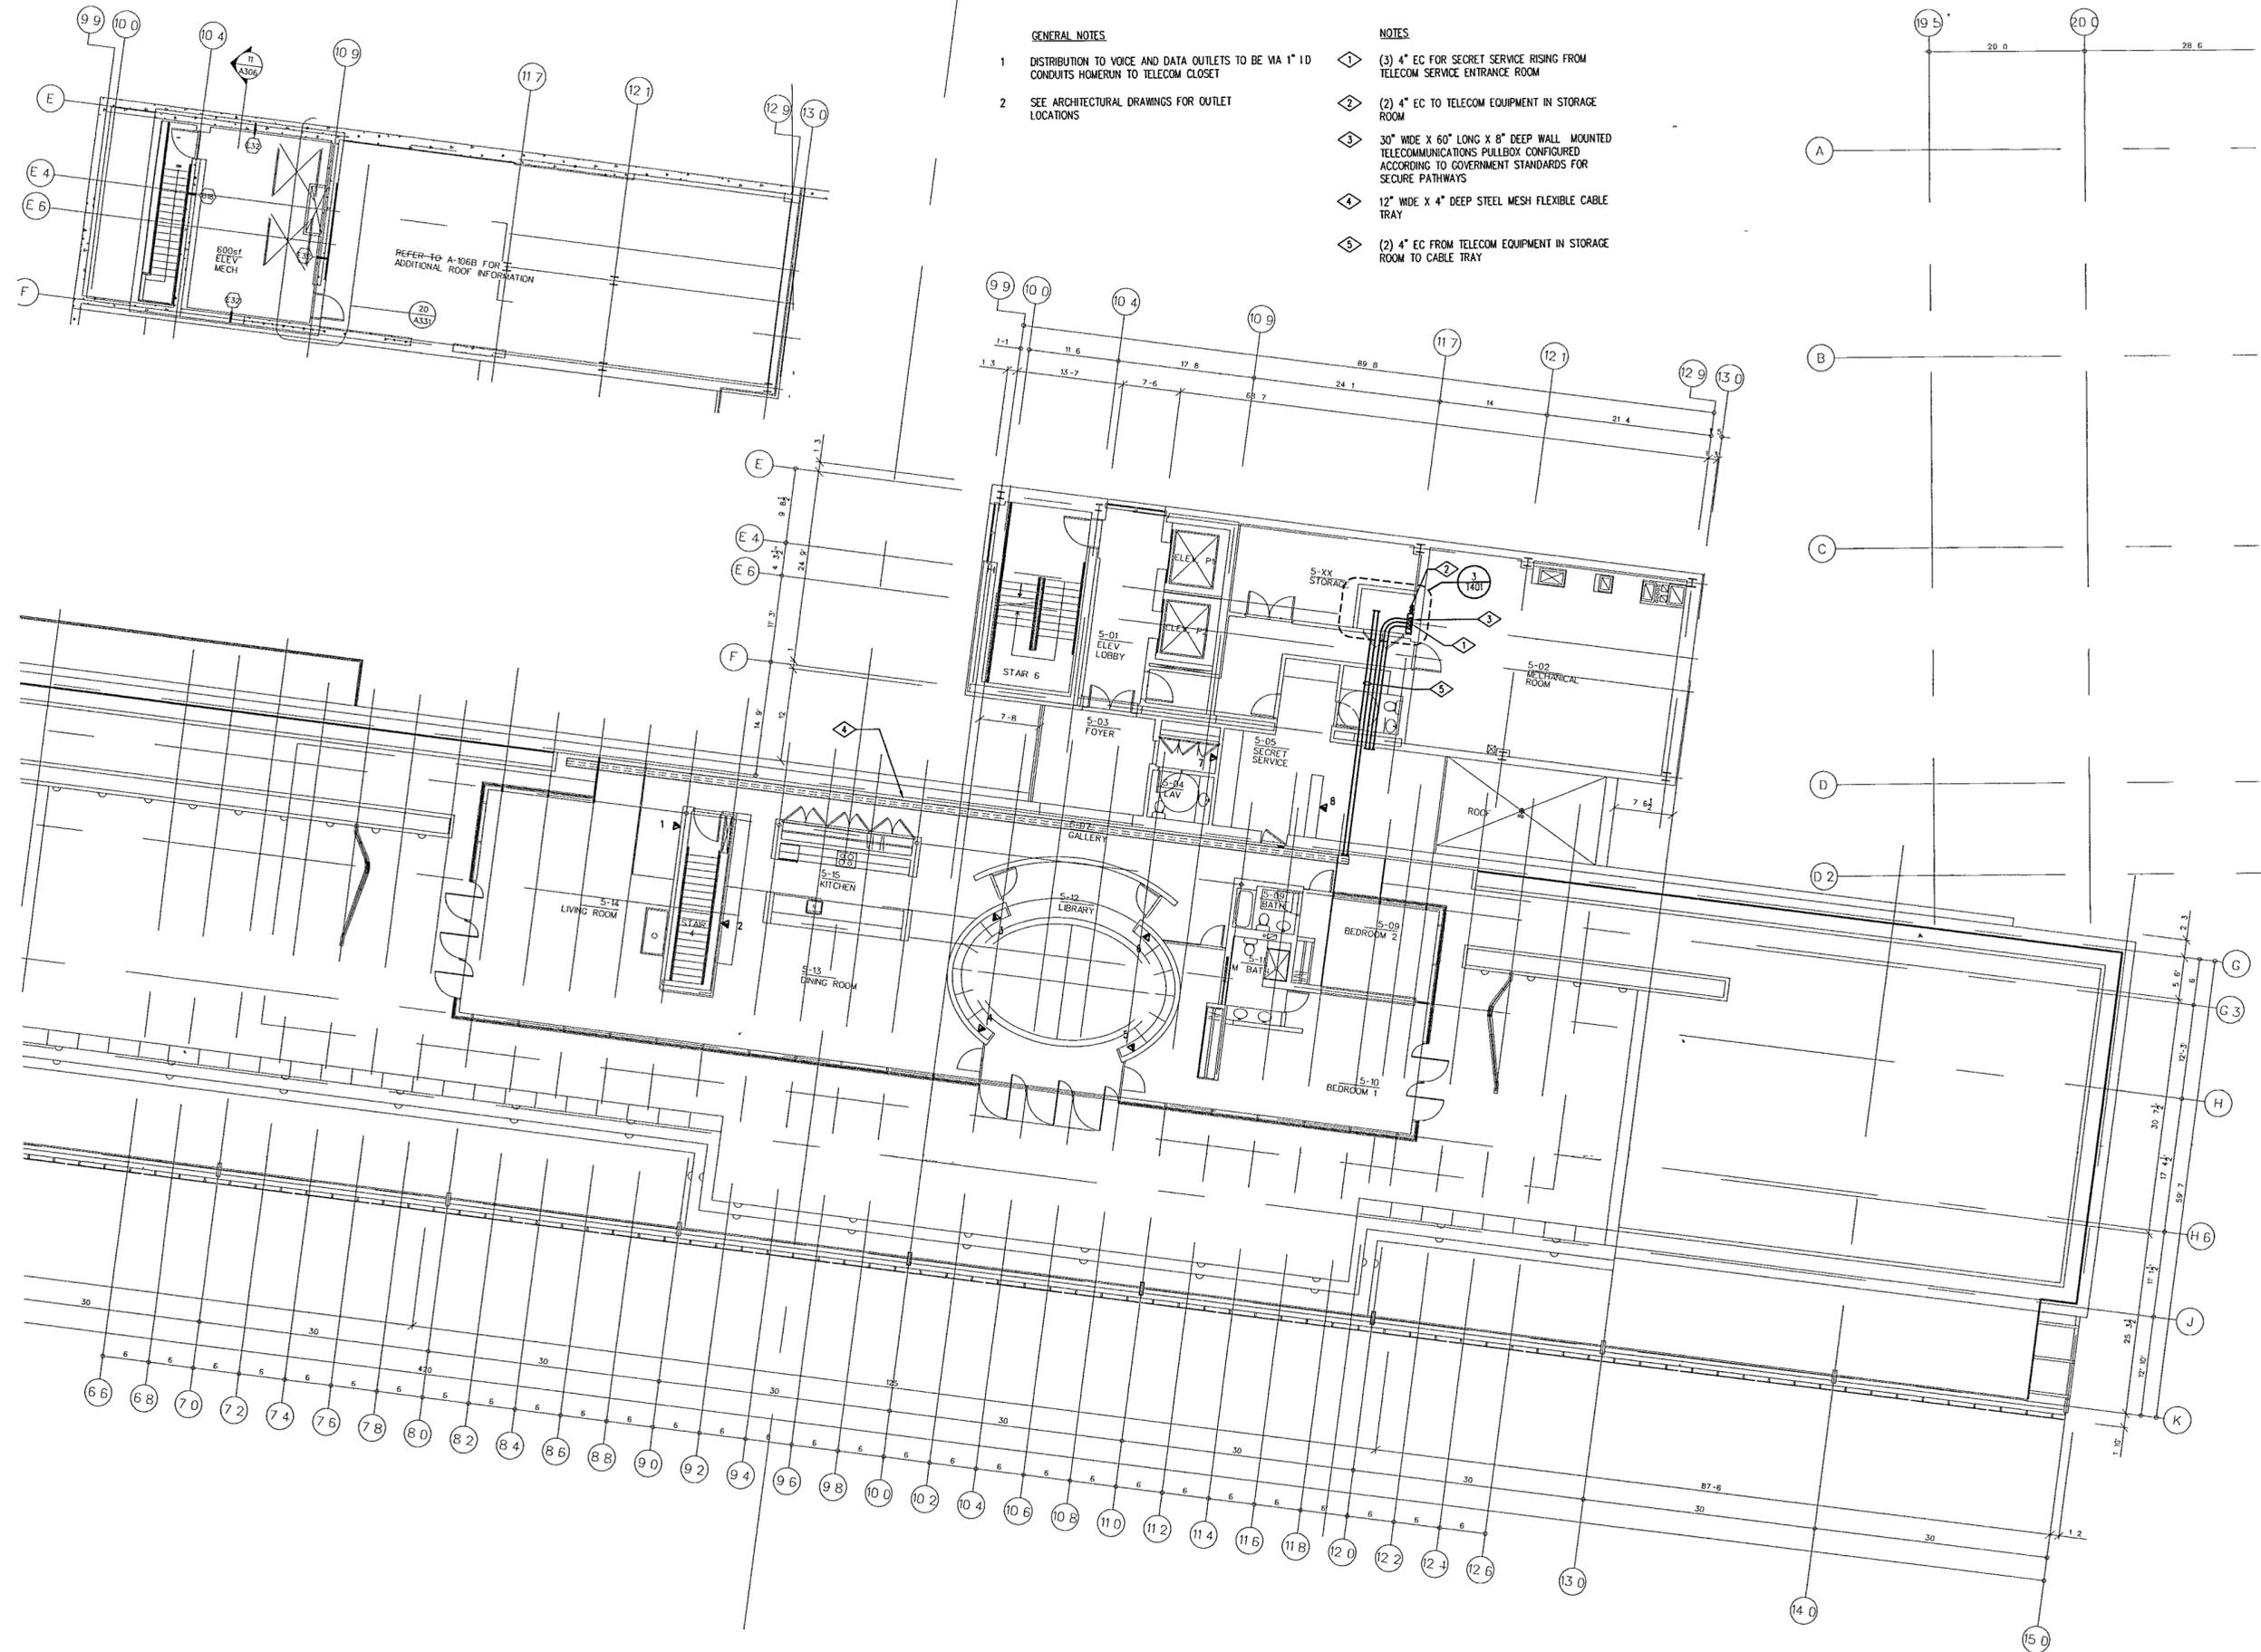

**FOR OFFICIAL USE ONLY**