

**WILLIAM J. CLINTON
PRESIDENTIAL
CENTER**

LITTLE ROCK, ARKANSAS

Architect
POLSHEK PARTNERSHIP LLP
320 West 13th Street
New York, New York 10014
212.607.7171

Coordinating Architects
POLK STANLEY YEARY ARCHITECTS LLP
700 South Schiller Street
Little Rock, Arkansas 72201
501.378.0878

WITSELL EVANS & RASCO
124 West Capital Avenue, Suite 1750
Little Rock, Arkansas 72201
501.374.6300

WOODS CARADINE ARCHITECTS
2200 South Main Street
Little Rock, Arkansas 72206
501.374.4080

Landscape Architects
HARGREAVES ASSOCIATES
118 Magazine Street
Cambridge, Massachusetts 02139
617.861.0070

LANDSCAPE ARCHITECTURE, Inc.
400 West Capitol Avenue
Suite 1000 Regions Center
Little Rock, Arkansas 72201
501.374.5610


Structural Engineer
LESLIE E. ROBERTSON ASSOC., RLP
30 Broad Street, 47th Floor
New York, New York 10004
212.763.9000

MEP Engineers
FLACK + KURTZ Inc.
475 Fifth Avenue
New York, New York 10017
212.632.9600

CROMWELL ARCHITECTS ENGINEERS
101 South Spring Street
Little Rock, Arkansas 72201
501.372.2900

Seal

Issue	Date
100% Construction Documents	09/27/02
90% Progress Printing	08/30/02
100% Design Development	03/01/02

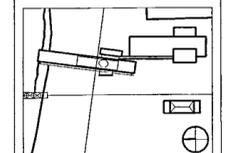

Job No. 9908

Scale NTS


Date September 27, 2002

Title

**TELECOM BACKBONE
COPPER/FIBER
RISER DIAGRAM**

Sheet No.

T501

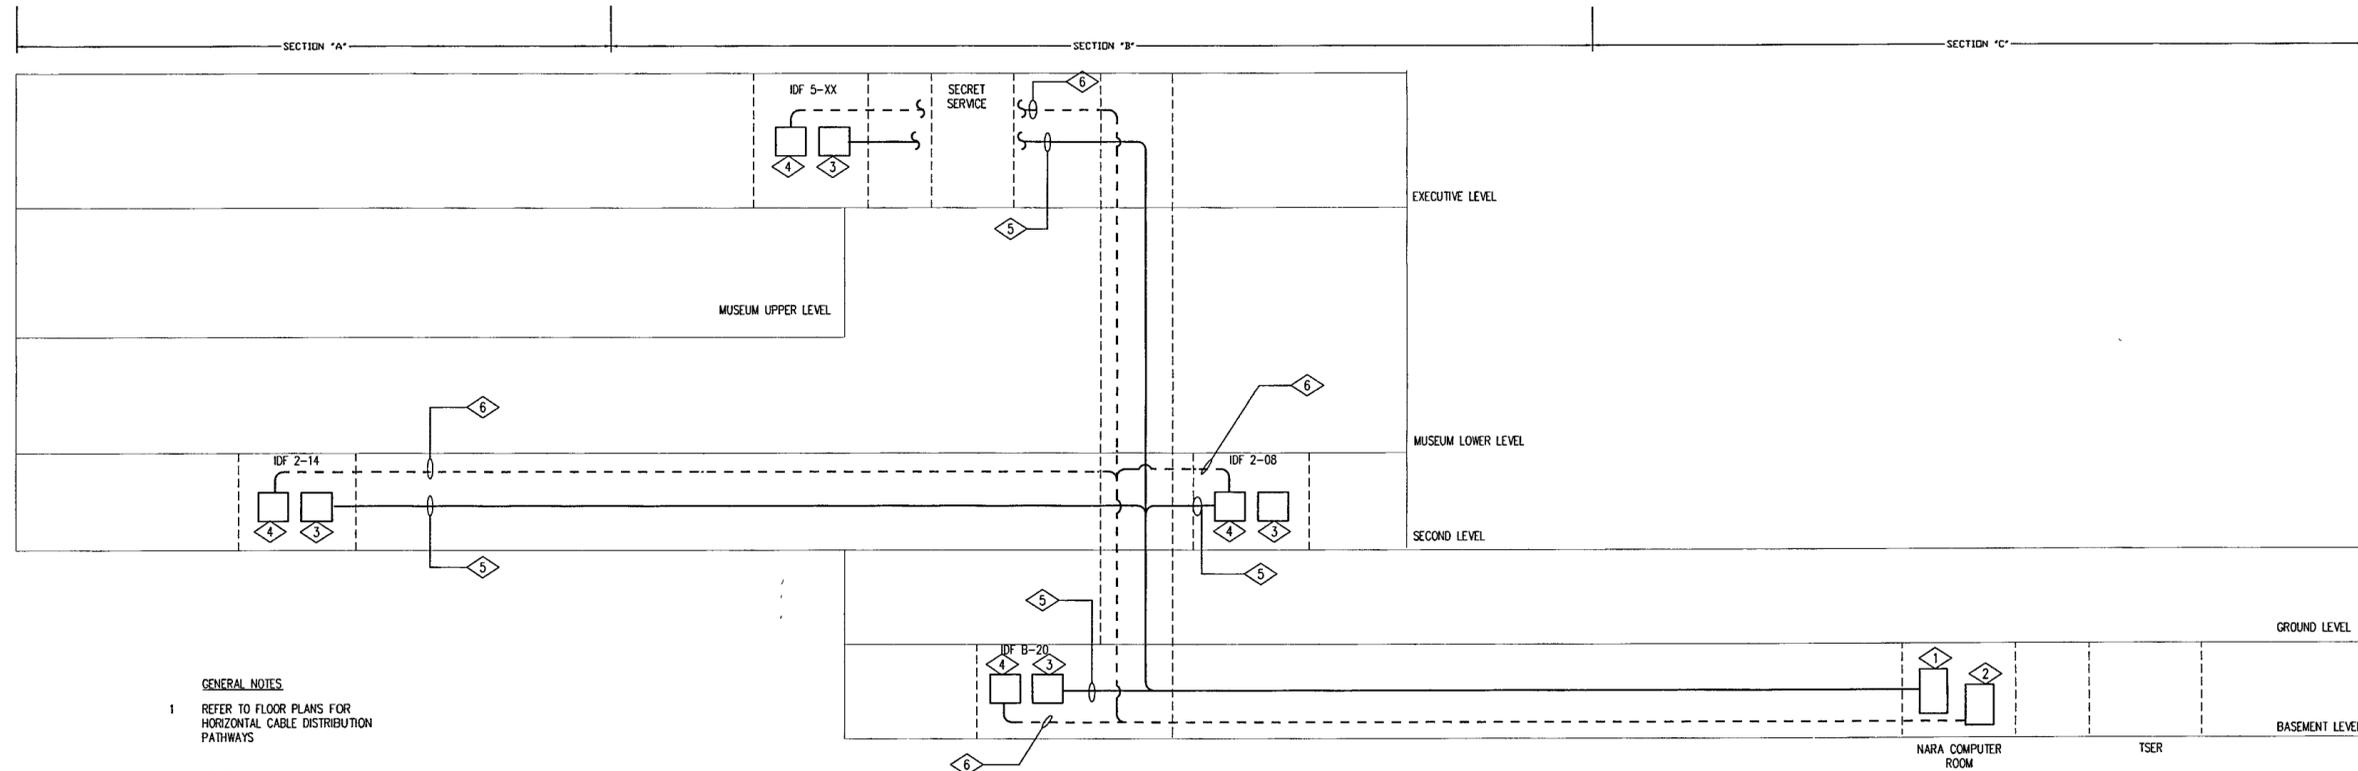

BACKBONE COPPER/FIBER RISER DIAGRAM

GENERAL NOTES

- 1 REFER TO FLOOR PLANS FOR HORIZONTAL CABLE DISTRIBUTION PATHWAYS

NOTES

- 1 MAIN DISTRIBUTION FRAME - 300pr, WALL MOUNTED 110 TYPE TERMINATION BLOCK
- 2 MAIN LIGHTGUIDE FRAME - RACK-MOUNTED 72-PORT OPTICAL FIBER PANEL
- 3 WALL MOUNTED 100pr 110 TYPE TERMINATION BLOCK
- 4 WALL MOUNTED 24-PORT OPTICAL FIBER PANEL
- 5 (2) 25pr CATEGORY 3 COPPER VOICE CABLING, PLENUM RATED
- 6 (1) 12-STRAND 62.5/125μ MULTI-MODE OPTICAL FIBER, PLENUM RATED