

**POLK
STANLEY
YEARLY
ARCHITECTS, LTD.**

700 SOUTH SCHILLER
LITTLE ROCK, AR 72201
501 378-0878
FAX 372-7629

21 W. MOUNTAIN, SUITE 227
FAYETTEVILLE, AR 72701
479-444-0473

CONSULTANTS:

OWNER'S PROJECT ADVISOR:
MOSES TUCKER REAL ESTATE, INC.

CIVIL ENGINEER:
McCLELLAND ENGINEERS

LANDSCAPE ARCHITECT:
LARSON BURNS SMITH

STRUCTURAL ENGINEER:
CROMWELL ENGINEERS INC.

MECH. ELEC. PLUMB. ENGINEER:
CROMWELL ENGINEERS INC.

SUSTAINABLE CONSULTANT:
BNIM / ELEMENTS

GLOBAL VILLAGE CONSULTANT
CAMBRIDGE SEVEN ASSOCIATES

INTERIOR DESIGNER:
POLK STANLEY YEARLY

GENERAL CONTRACTOR:
CDI

GENERAL NOTES:

- LOCATE WALLS & PARTITIONS ON CENTERLINE OF COLUMNS UNLESS NOTED OTHERWISE.
- SEE SHEET 0003 FOR COLUMN DIMENSION PLAN.
- ALL WALLS ARE SEGMENTED TO FOLLOW CURVE OF BLDG. UNLESS NOTED OTHERWISE.

NOTES:

ISSUE DATE:
100% GMP
PACKAGE #6
FEBRUARY 2, 2004

REVISIONS:

#	DATE	DESCRIPTION
1	02/04/04	PACKAGE #1


**HEIFER
INTERNATIONAL
CENTER
OFFICE BUILDING**
LITTLE ROCK, ARKANSAS

PSY PROJECT NUMBER:
431C



CONTENTS:
THIRD FLOOR PLAN - WEST END
SHEET NUMBER:

A103b

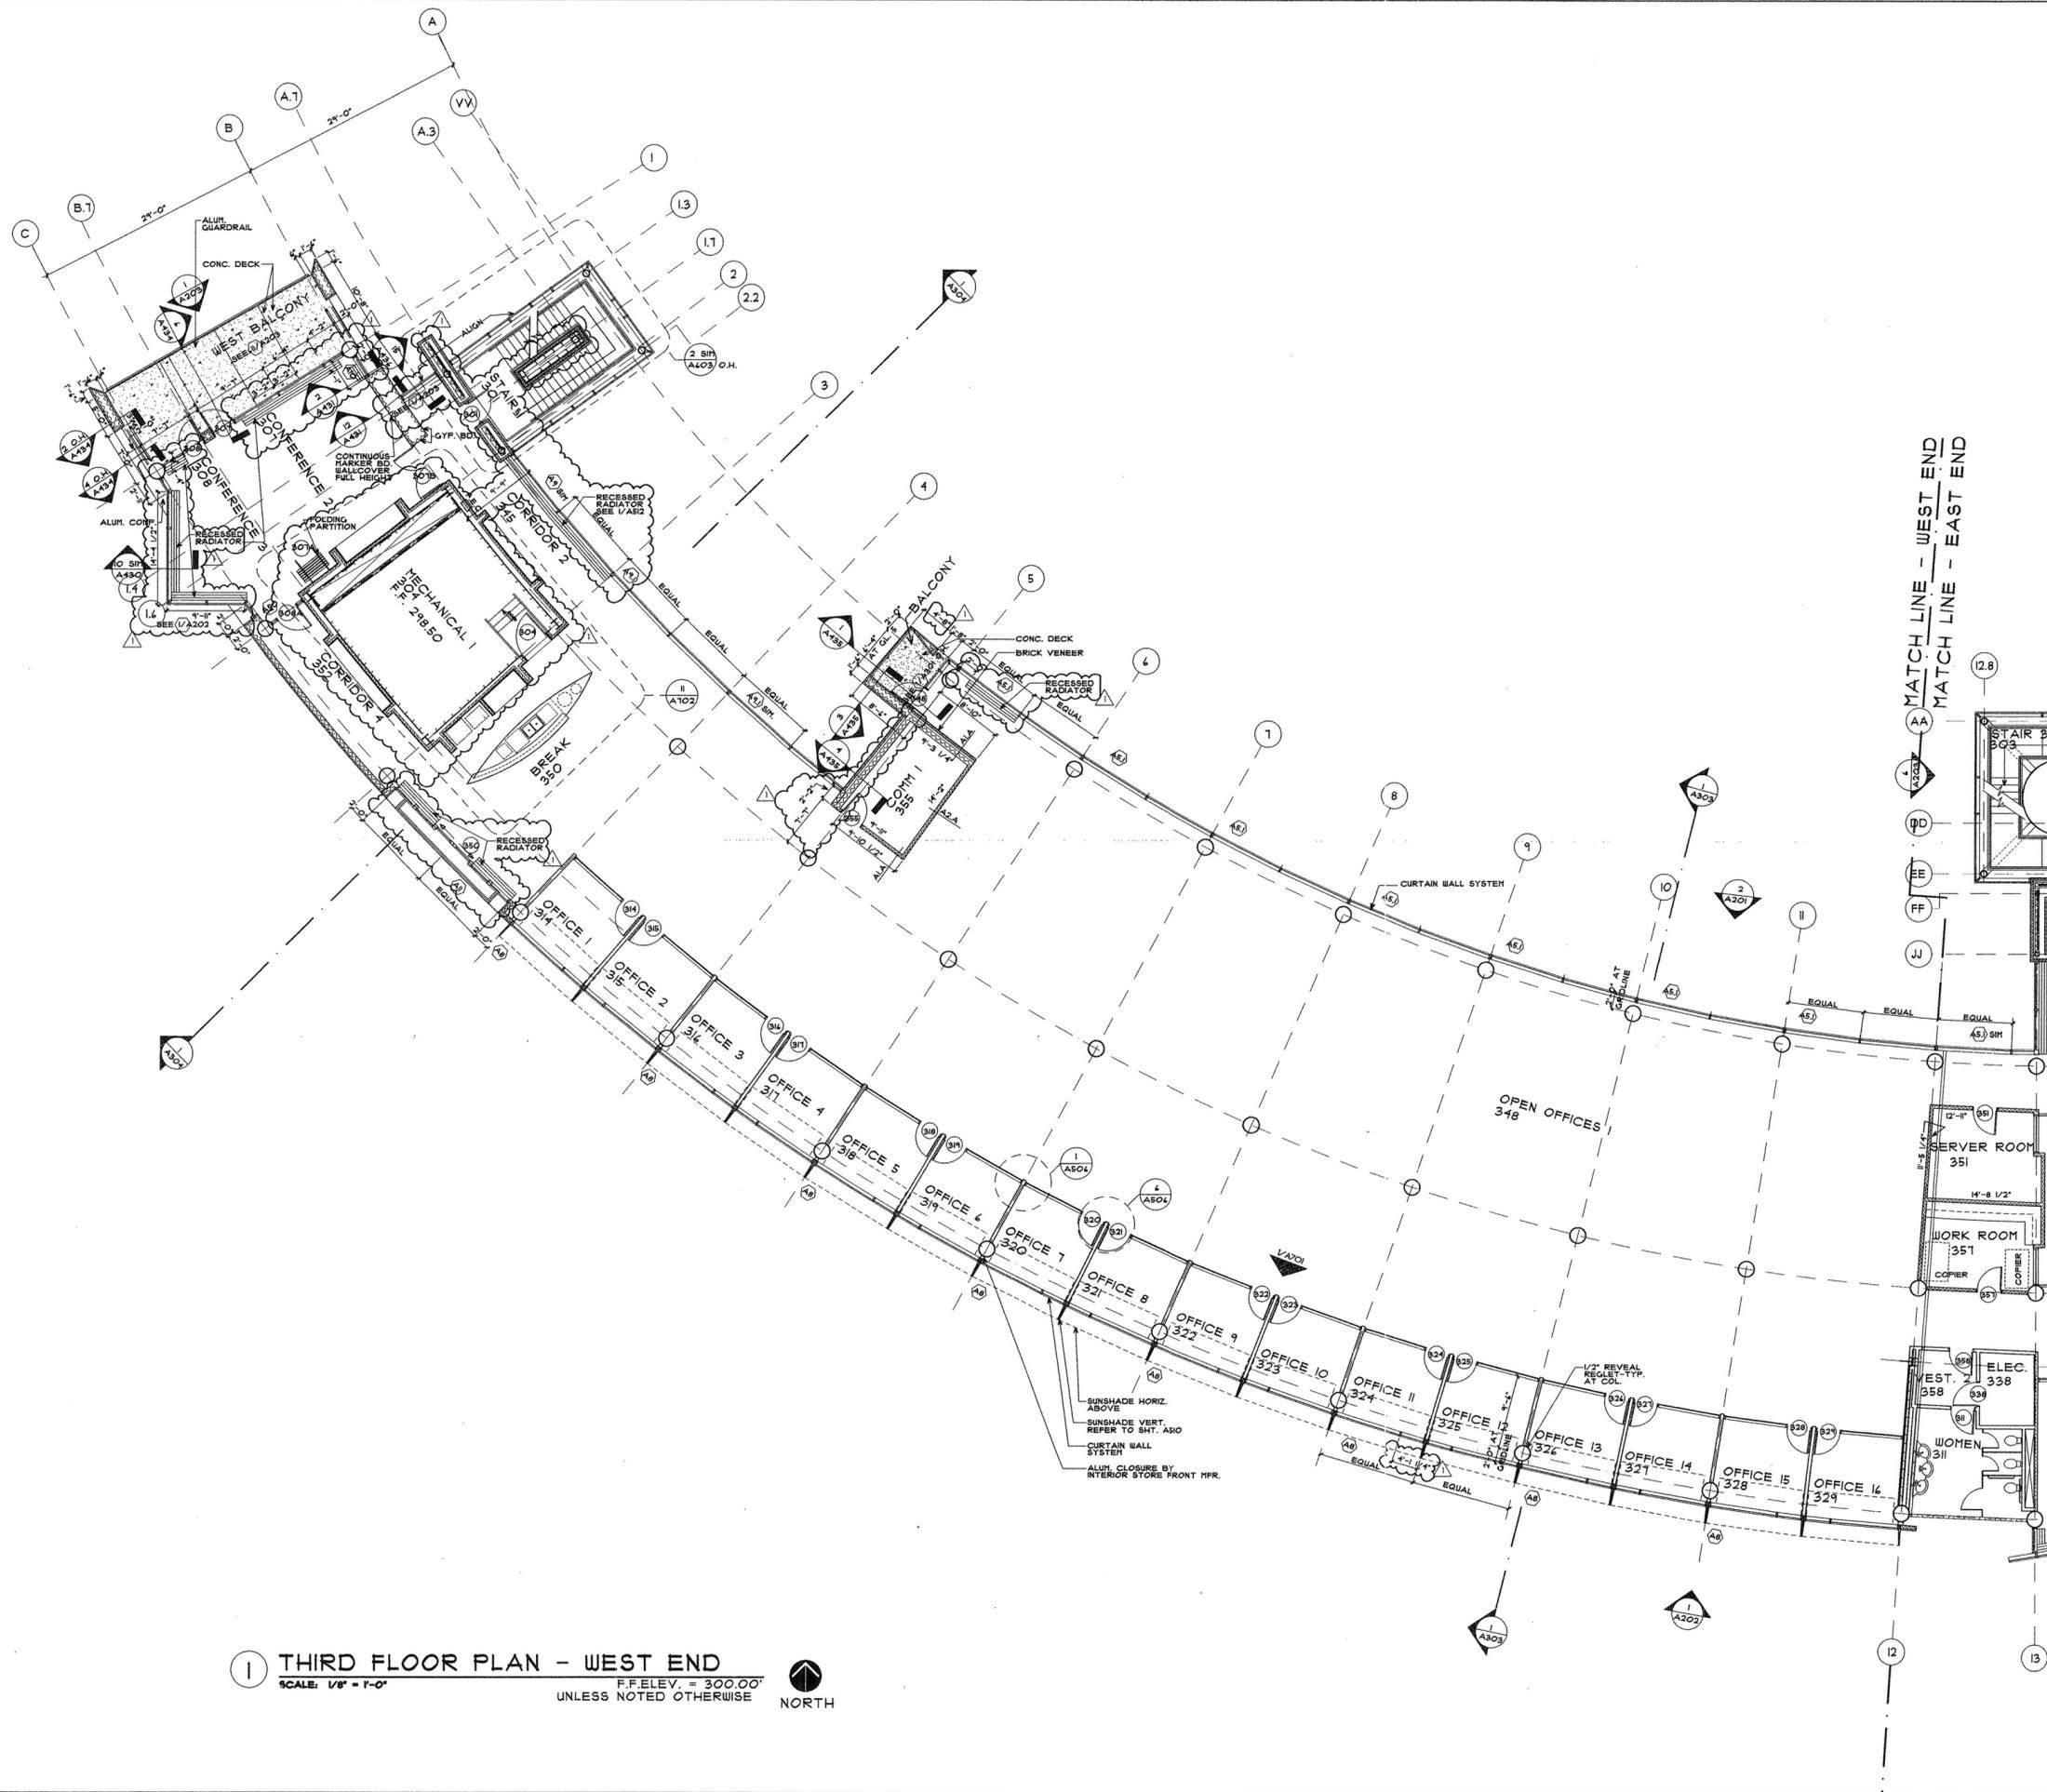

1 THIRD FLOOR PLAN - WEST END
F.F.ELEV. = 300.00'
SCALE: 1/8" = 1'-0"
UNLESS NOTED OTHERWISE



P:\0-DWG\431C\04\FloorPlan\A103b-ThirdFloorWestEnd.dwg, Plot: Tuesday, June 29, 2004, 10:58 AM