

**POLK  
STANLEY  
YEARY  
ARCHITECTS, LTD.**

700 SOUTH SCHILLER  
LITTLE ROCK, AR 72201  
501 378-0878  
FAX 372-7629

21 W. MOUNTAIN, SUITE 227  
FAYETTEVILLE, AR 72701  
479-444-0473

**CONSULTANTS:**

OWNER'S PROJECT ADVISOR:  
MOSES TUCKER REAL ESTATE, INC.

CIVIL ENGINEER:  
McCLELLAND ENGINEERS

LANDSCAPE ARCHITECT:  
LARSON BURNS SMITH

STRUCTURAL ENGINEER:  
CROMWELL ENGINEERS INC.

MECH., ELEC., PLUMB. ENGINEER:  
CROMWELL ENGINEERS INC.

SUSTAINABLE CONSULTANT:  
BNIM / ELEMENTS

GLOBAL VILLAGE CONSULTANT  
CAMBRIDGE SEVEN ASSOCIATES

INTERIOR DESIGNER:  
POLK STANLEY YEARY

GENERAL CONTRACTOR:  
CDI

**GENERAL NOTES:**

1. PAINT ALL EXPOSED STEEL DECK & STRUCTURE - SEE SPEC'S FOR SCHEDULE.
2. DO NOT PAINT EXPOSED CONC. DECK.
3. DO NOT PAINT EXPOSED DUCTS.
4. PAINT ALL OTHERS EXPOSED SYSTEMS - SEE SPEC'S FOR SCHED.
5. DO NOT PAINT ANY ALUM. MAT.
6. ELEC. CONDUIT SHALL RUN THRU FLOOR FLENNH ABOVE THEN DROP TO FUTURE AND DEVICE J-BOX, NAILER.
7. PENDANT FIXTURES: MOUNT TIGHT TO SIDES OF BEAMS INDICATED UNLESS NOTED OTHERWISE - SEE BUILDING SECTIONS FOR ADDITIONAL INFORMATION.
8. LOCATION OF ALL DEVICES, FIXTURES, ETC. SHALL BE REVIEWED WITH ARCHITECT BEFORE INSTALLATION.
9. SEE BUILDING SECTIONS FOR ADDITIONAL INFORMATION ON SPRINKLER LINE LOCATIONS.

**NOTES:**

ISSUE DATE:  
100% GMP  
PACKAGE #6  
FEBRUARY 2, 2004

**REVISIONS:**


#	DATE	DESCRIPTION
1	04/04/04	PACKAGE #1
2	05/04/04	ASI NO. 25

**HEIFER  
INTERNATIONAL  
CENTER  
OFFICE BUILDING**  
LITTLE ROCK, ARKANSAS

PSY PROJECT NUMBER:  
431C

**CONTENTS:**  
THIRD FLOOR REFLECTED  
CEILING PLAN  
- WEST END  
SHEET NUMBER:

**A103d**

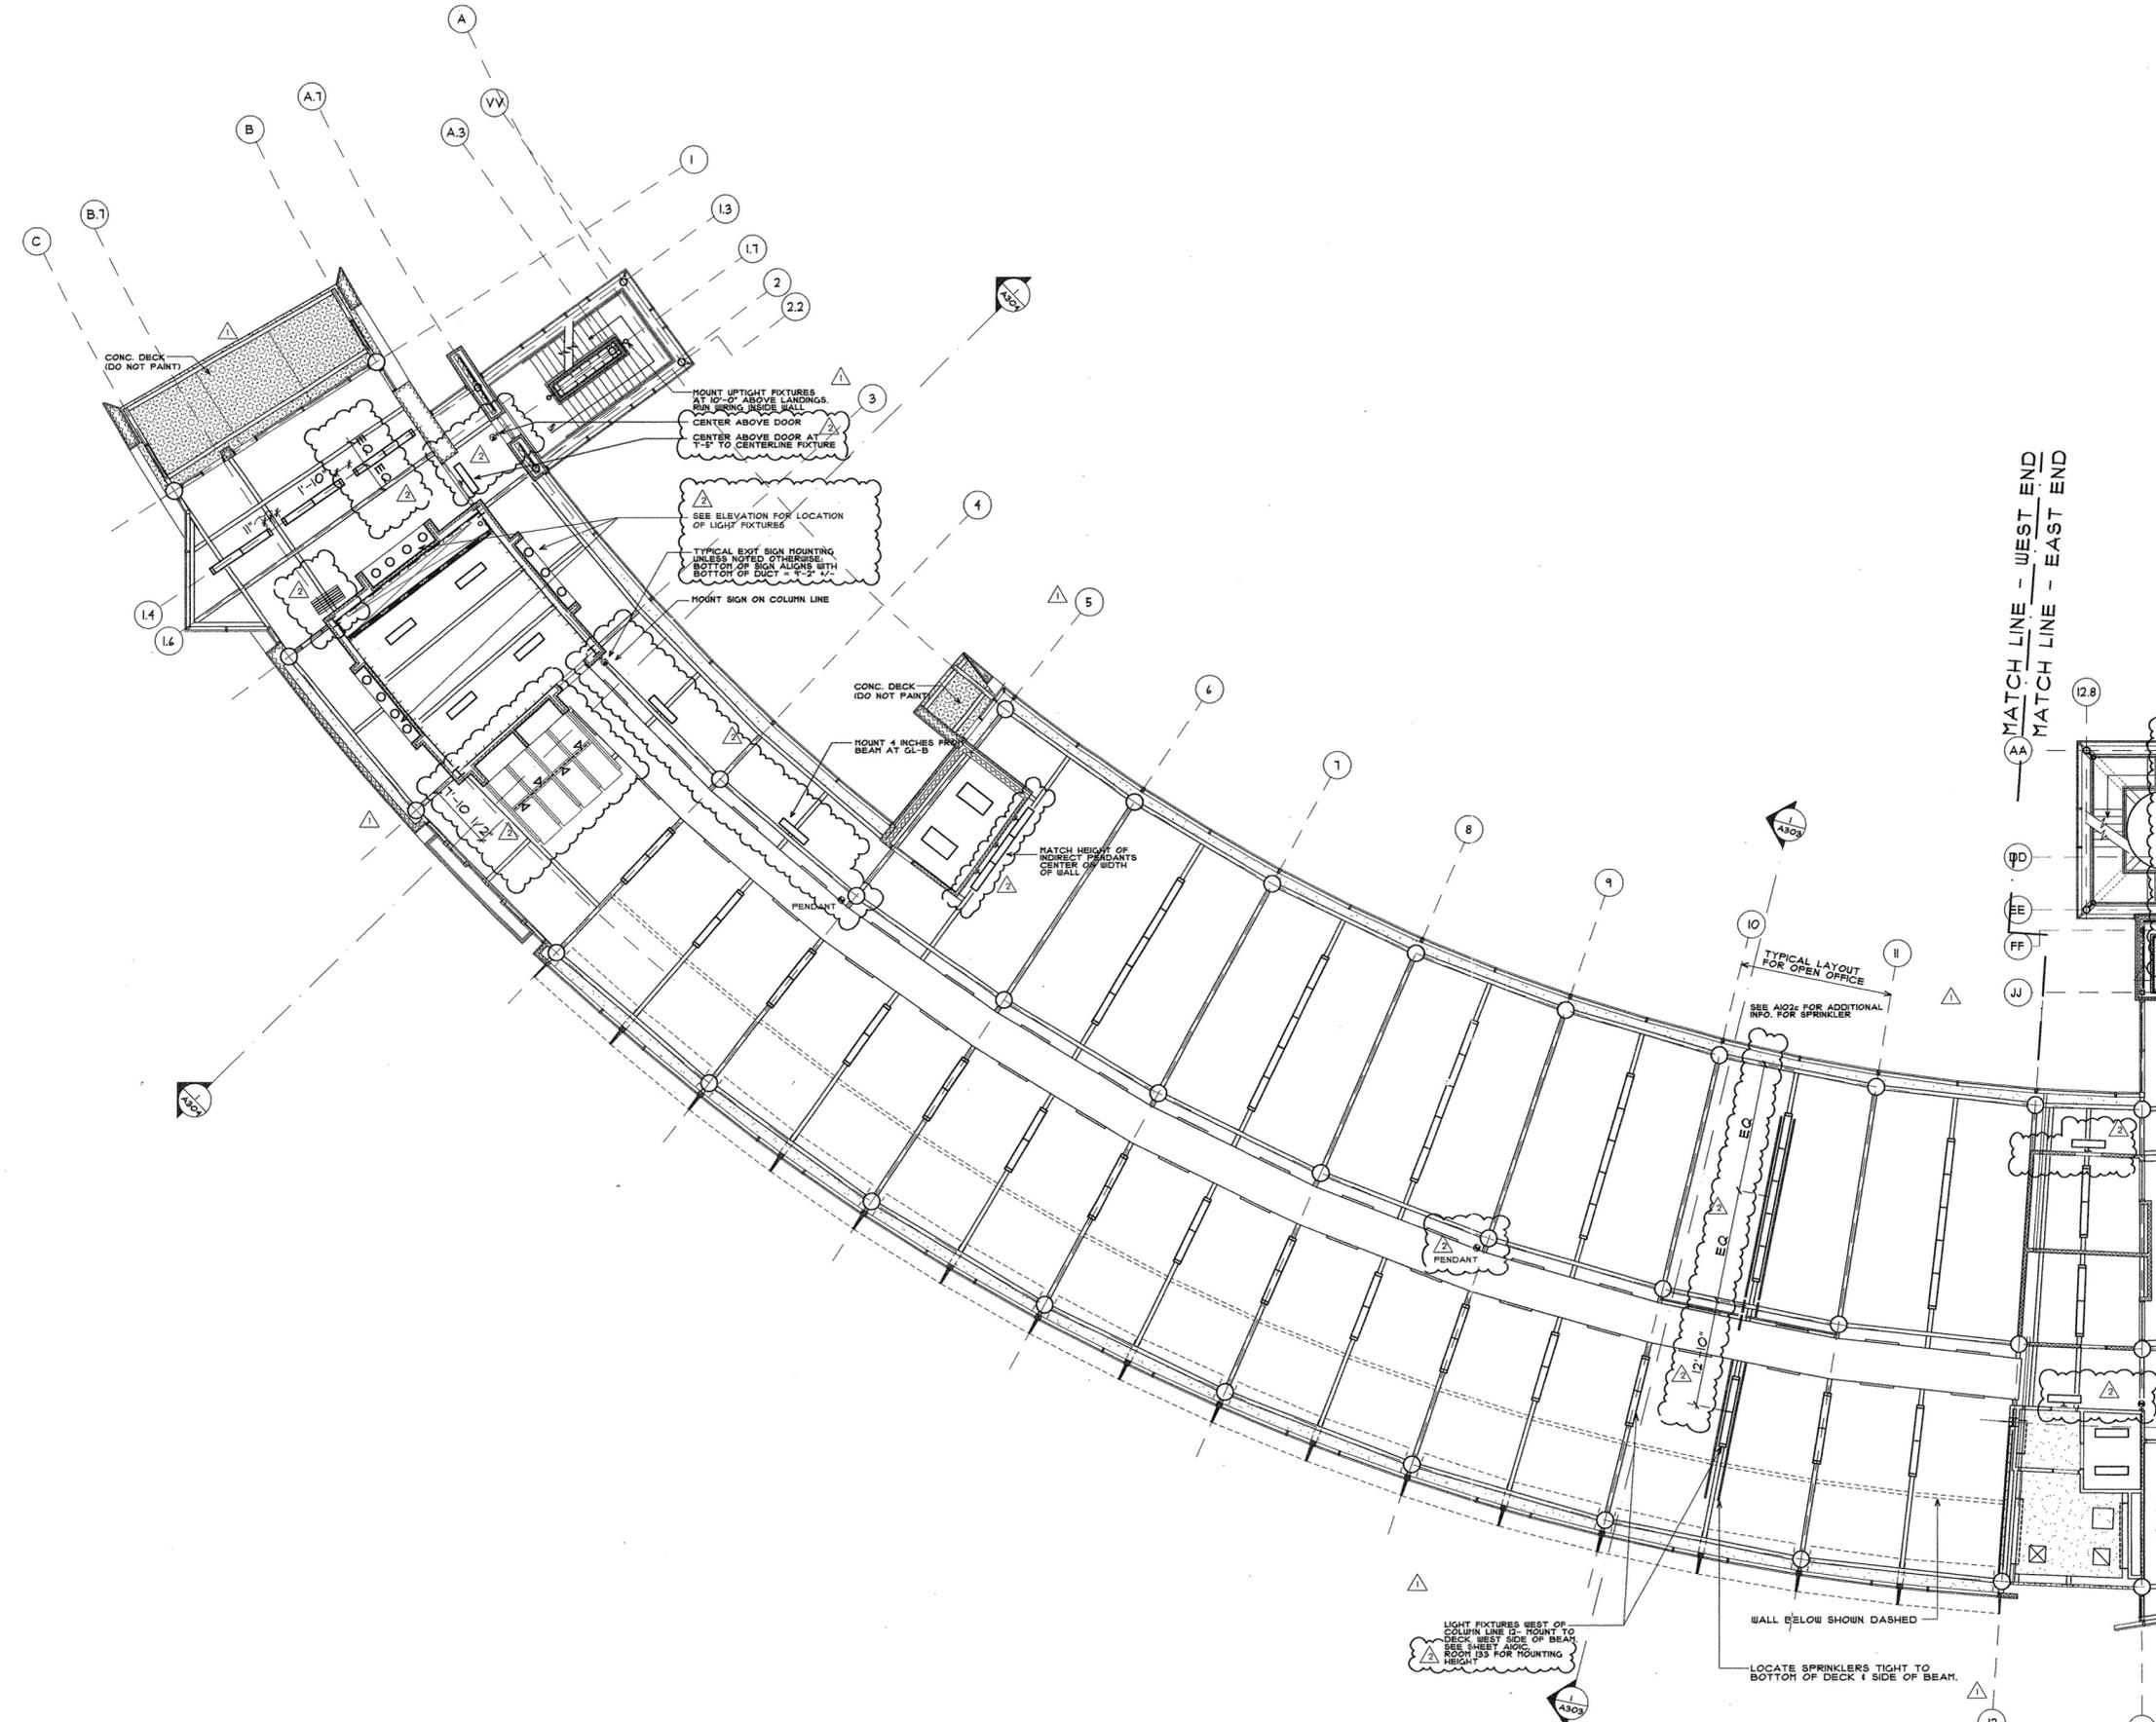

**1 THIRD FLOOR REFLECTED CEILING PLAN - WEST END**  
SCALE: 1/8" = 1'-0"  
F.F. ELEV. = 300.00'



P:\10-1000\103\103-01\Drawings\03\03-103-01-03-ThirdFloorReflectedCeilingPlanWestEnd.dwg 15, 2004 4:29 PM