

**POLK
STANLEY
YEARLY**
ARCHITECTS, LTD.

700 SOUTH SCHILLER
LITTLE ROCK, AR 72201
501 378-0878
FAX 373-7629

21 W. MOUNTAIN, SUITE 227
FAYETTEVILLE, AR 72701
479-444-0473

CONSULTANTS:

OWNER'S PROJECT ADVISOR:
MOSES TUCKER REAL ESTATE, INC.

CIVIL ENGINEER:
MCLELLAND ENGINEERS

LANDSCAPE ARCHITECT:
LARSON BURNS SMITH

STRUCTURAL ENGINEER:
CROMWELL ENGINEERS INC.

MECH., ELEC., PLUMB. ENGINEER:
CROMWELL ENGINEERS INC.

SUSTAINABLE CONSULTANT:
ENVI. ELEMENTS

GLOBAL VILLAGE CONSULTANT:
CAMBRIDGE SEVEN ASSOCIATES

INTERIOR DESIGNER:
POLK STANLEY YEARLY

GENERAL CONTRACTOR:
CDI

GENERAL NOTES:

1. PAINT ALL EXPOSED STEEL DECK & STRUCTURE - SEE SPECS FOR SCHEDULE.
2. DO NOT PAINT EXPOSED CONC. DECK.
3. DO NOT PAINT EXPOSED DUCTS.
4. PAINT ALL OTHER EXPOSED SYSTEMS - SEE SPECS FOR SCHEDULE.
5. DO NOT PAINT ANY ALUM. RAY.
6. ELEC. CONDUIT SHALL RUN THRU FLOOR FLESH ABOVE THEN DROP TO FIXTURE AND DEVICE FLOOR.
7. PENDANT FIXTURES: HOOK TIGHT UNLESS OTHERWISE INDICATED OR NOTED OTHERWISE. SEE BUILDING SECTIONS FOR ADDITIONAL INFORMATION.
8. LOCATION OF ALL DEVICES, FIXTURES, ETC. SHALL BE REVIEWED WITH ARCHITECT BEFORE INSTALLATION.
9. SEE BUILDING SECTIONS FOR ADDITIONAL INFORMATION ON SPLITTER LINK LOCATION.

NOTES:

ISSUE DATE:
10/9 GMP
PACKAGE #6
FEBRUARY 2, 2004

REVISIONS:

#	DATE	DESCRIPTION
1	10/10/04	PACKAGE #1
2	11/23/04	REV # 67


**HEIFER
INTERNATIONAL
CENTER
OFFICE BUILDING**

LITTLE ROCK, ARKANSAS
ROOF TREE TUBE
TRIMS - 2-29-04
BY EP/PSRCP
P/RC/P

PSY PROJECT NUMBER:
431C

CONTENTS:
FOURTH FLOOR REFLECTED
CEILING PLAN
- EAST END
SHEET NUMBER:

A104c

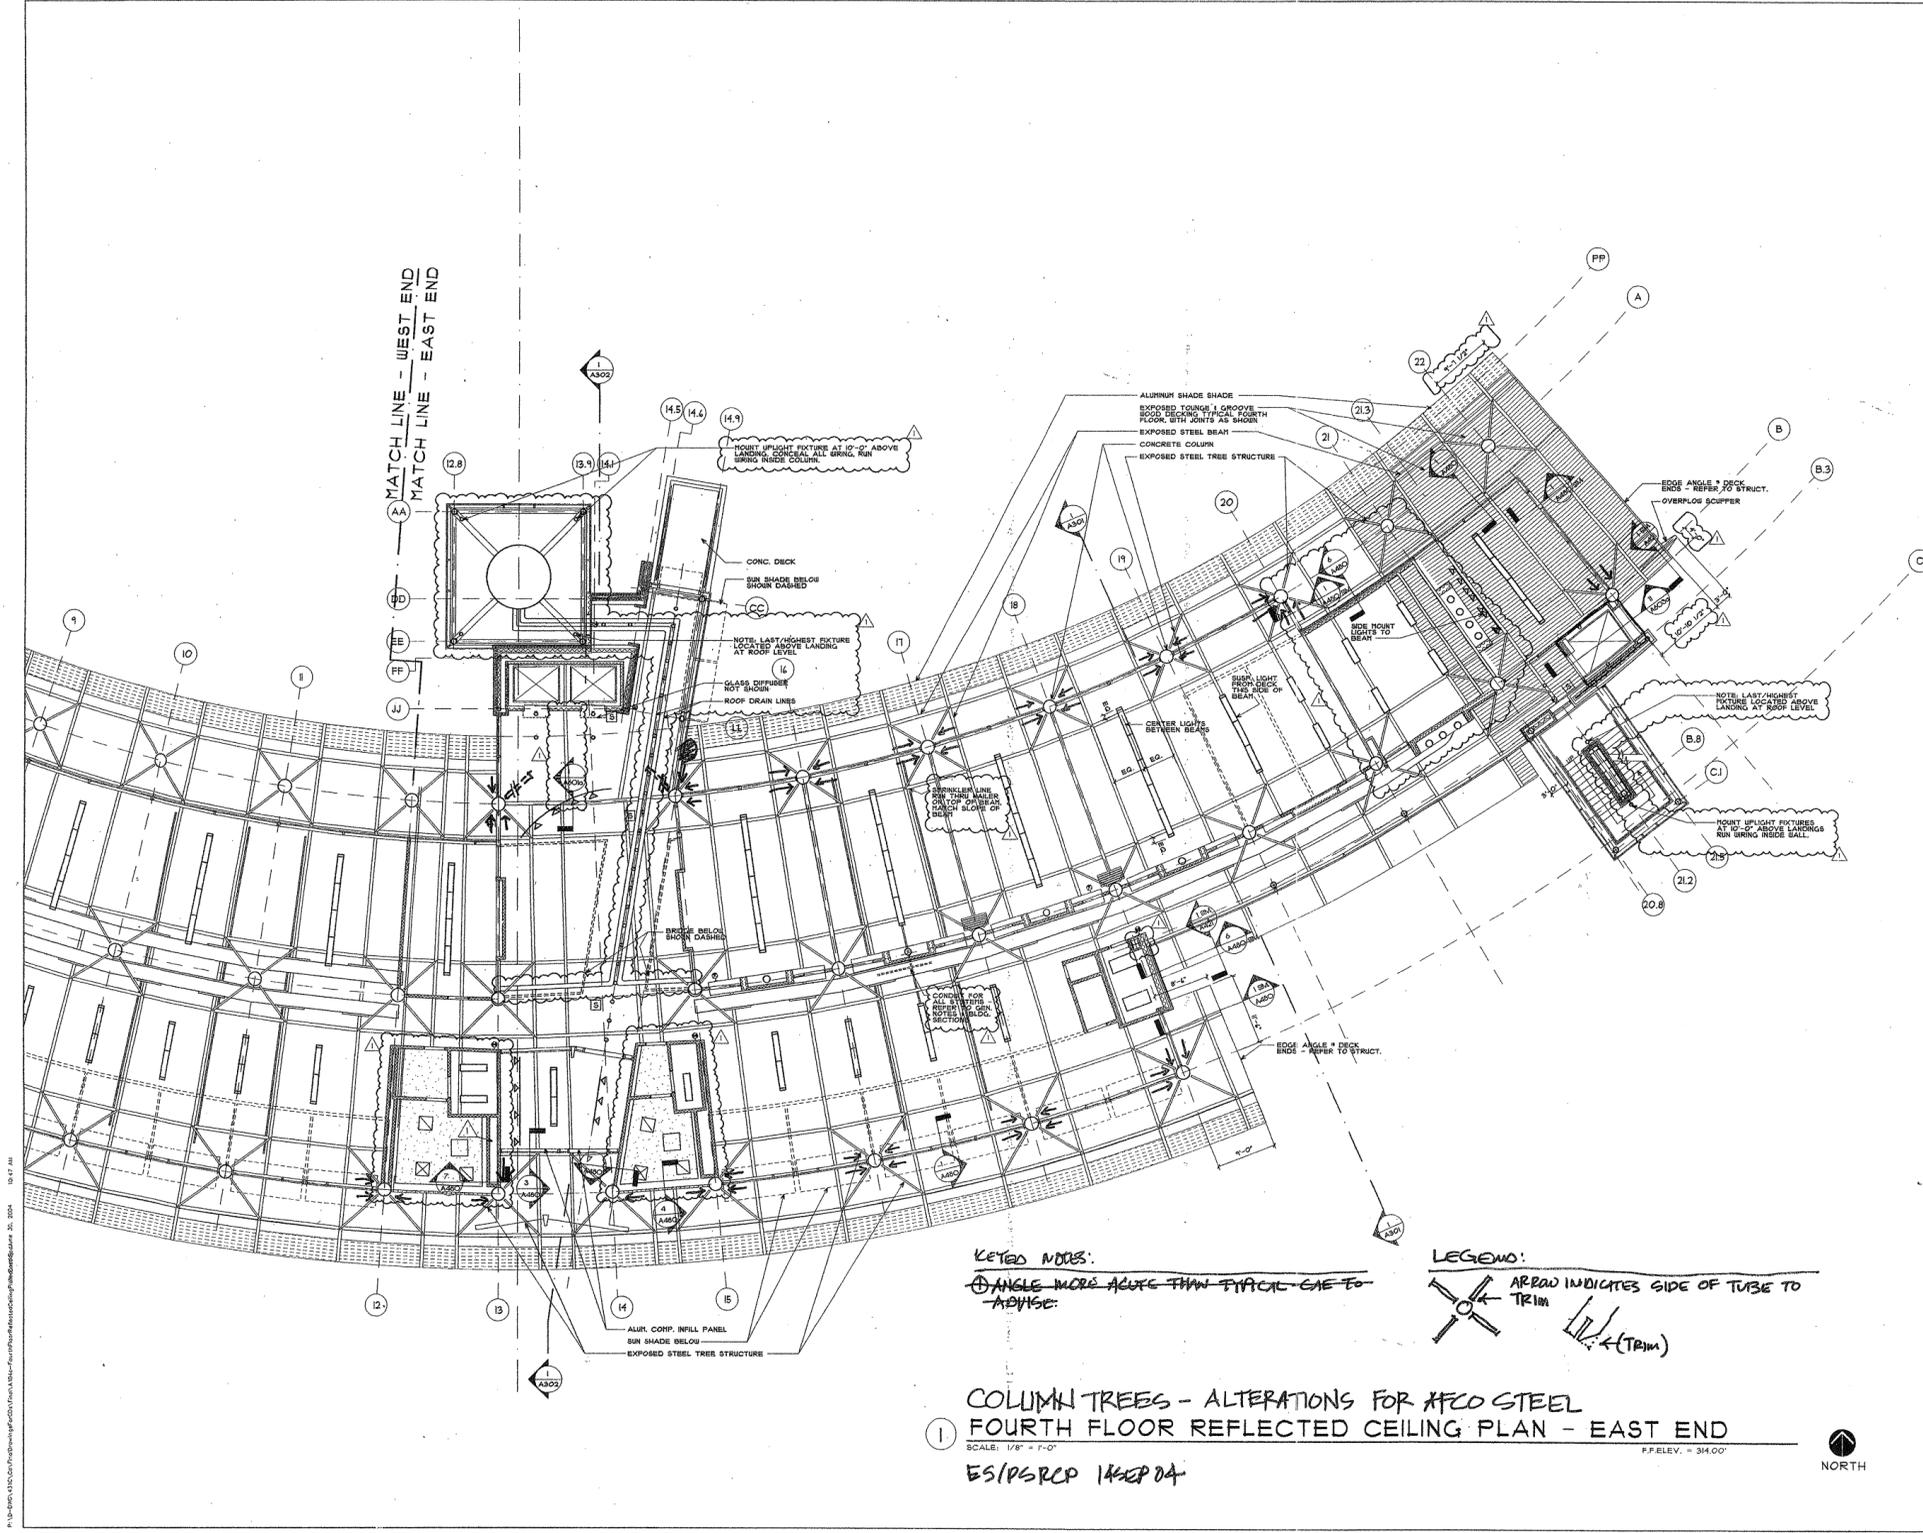

KEYED NOTES:
ANGLE MORE ACUTE THAN TYPICAL CASE TO ADVISE

LEGEND:
ARROW INDICATES SIDE OF TUBE TO TRIM

1
COLUMN TREES - ALTERATIONS FOR AFCO STEEL
FOURTH FLOOR REFLECTED CEILING PLAN - EAST END
SCALE: 1/8" = 1'-0"
P.F. ELEV. = 34'-00"

P:\02-0000\431C\04\Project\Drawings\431C-Fourth Floor Reflected Ceiling Plan - East End.dwg, 2004, 10:17 AM