

**POLK  
STANLEY  
YEARY**  
ARCHITECTS, LTD.

700 SOUTH SCHILLER  
LITTLE ROCK, AR 72201  
501 378-0878  
FAX 372-7629  
21 W. MOUNTAIN, SUITE 227  
FAYETTEVILLE, AR 72701  
479-444-0473

**CONSULTANTS:**  
OWNER'S PROJECT ADVISOR:  
MOSES TUCKER REAL ESTATE, INC.  
CIVIL ENGINEER:  
MCLELLAND ENGINEERS  
LANDSCAPE ARCHITECT:  
LARSON BURNS SMITH  
STRUCTURAL ENGINEER:  
CROMWELL ENGINEERS INC.  
MECH., ELEC., PLUMB. ENGINEER:  
CROMWELL ENGINEERS INC.  
SUSTAINABLE CONSULTANT:  
BNIM / ELEMENTS  
GLOBAL VILLAGE CONSULTANT  
CAMBRIDGE SEVEN ASSOCIATES  
INTERIOR DESIGNER:  
POLK STANLEY YEARY  
GENERAL CONTRACTOR:  
CDI

GENERAL NOTES:

NOTES:

ISSUE DATE:  
100% GMP  
PACKAGE #6  
FEBRUARY 2, 2004

REVISIONS:

#	DATE	DESCRIPTION
1	02/02/04	PACKAGE #1

**HEIFER  
INTERNATIONAL  
CENTER  
OFFICE BUILDING**  
LITTLE ROCK, ARKANSAS


PSY PROJECT NUMBER:  
431C




CONTENTS:  
ENLARGED PLANS -  
ELEVATOR CORE

SHEET NUMBER:


**A601a**

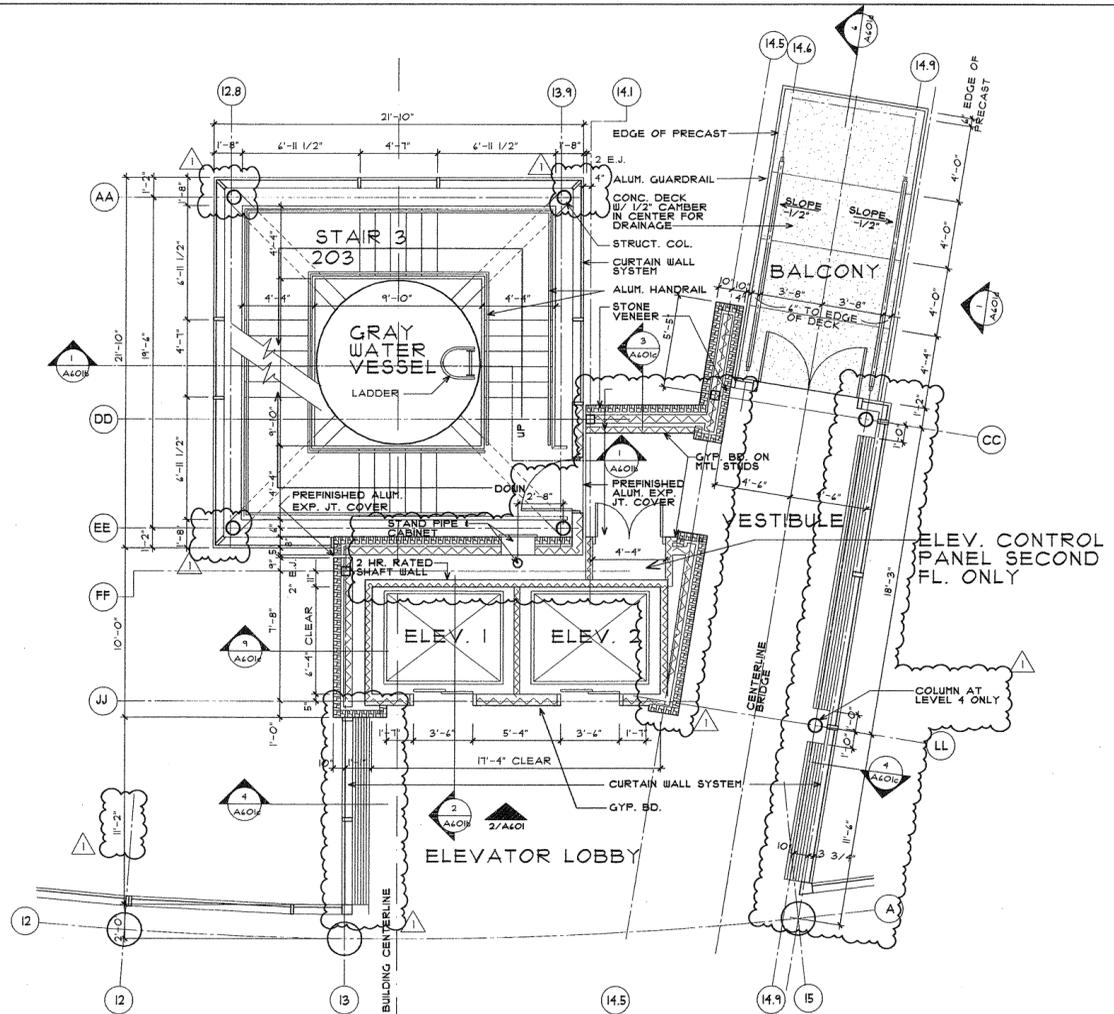

**1 LEVELS 2, 3 & 4 - CORE**  
SCALE: 1/4" = 1'-0"

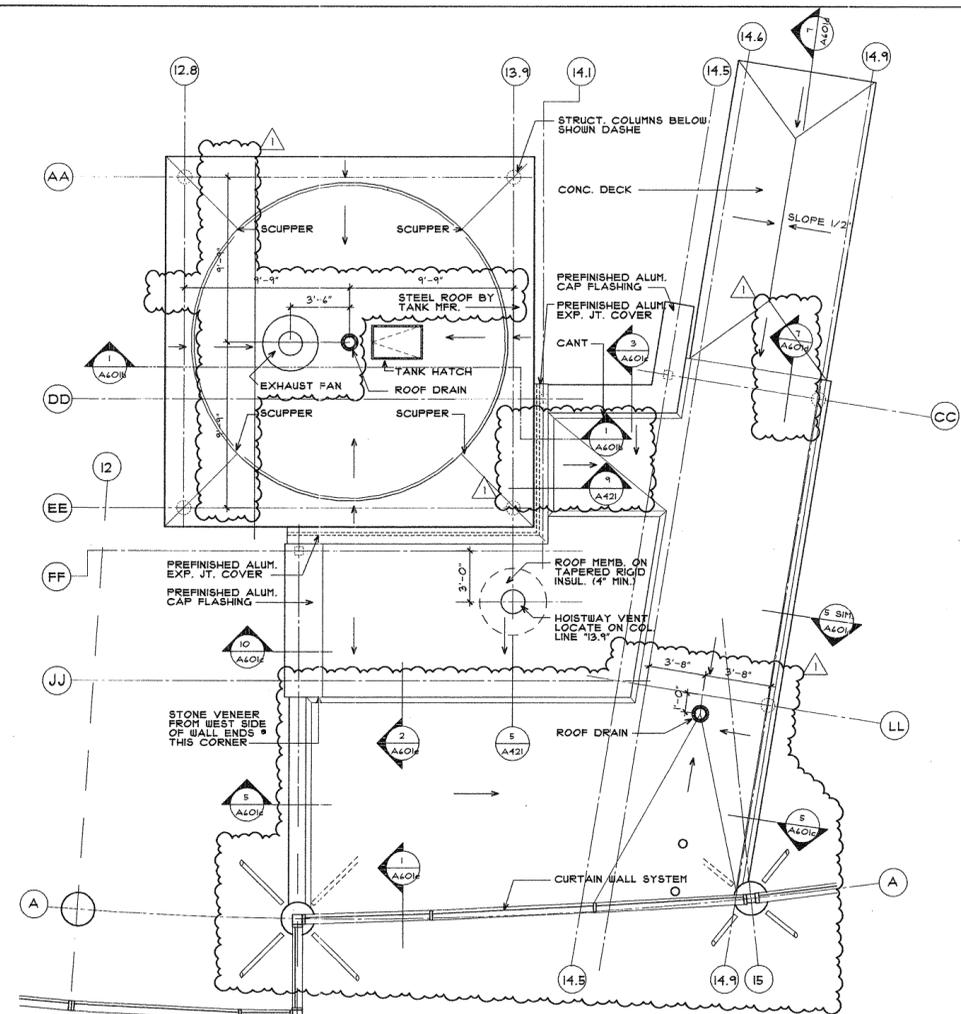

**2 ROOF PLAN - CORE**  
SCALE: 1/4" = 1'-0"

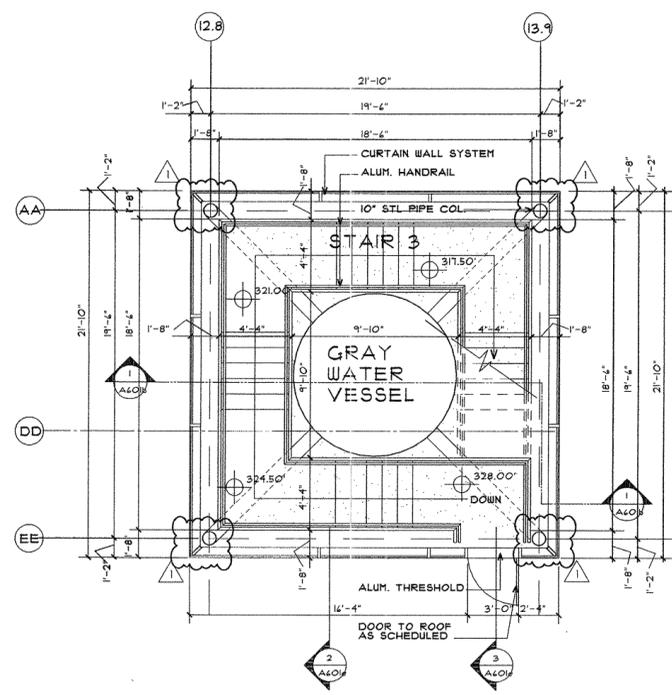

**8 ROOF LEVEL**  
SCALE: 1/4" = 1'-0"

P:\AD-DWG\MISC\A601a\Final\Drawings\Final\A601a-EnlargedCore.rvt