

**POLK
STANLEY
YEARY
ARCHITECTS, LTD.**

700 SOUTH SCHILLER
LITTLE ROCK, AR 72201
501 378-0878
FAX 372-7629

21 W. MOUNTAIN, SUITE 227
FAYETTEVILLE, AR 72701
479-444-0473

CONSULTANTS:
OWNER'S PROJECT ADVISOR:
MOSES TUCKER REAL ESTATE, INC.
CIVIL ENGINEER:
McCLELLAND CONSULTING
ENGINEERS INC.
LANDSCAPE ARCHITECT:
LARSON BURNS SMITH
STRUCTURAL ENGINEER:
CROMWELL ENGINEERS INC.
MECH., ELEC., PLUMB. ENGINEER:
CROMWELL ENGINEERS INC.
SUSTAINABLE CONSULTANT:
BNIM / ELEMENTS
GLOBAL VILLAGE CONSULTANT:
CAMBRIDGE SEVEN ASSOCIATES
INTERIOR DESIGNER:
POLK STANLEY YEARY
GENERAL CONTRACTOR:
CDI CONTRACTORS, INC.

GENERAL NOTES:

NOTES:

ISSUE DATE:
CORE / SHELL
BID PACKAGE #5
DECEMBER 15, 2003

REVISIONS:


#	DATE	DESCRIPTION
1	1-16-04	ADDENDUM #1
2	7-1-04	PKG 7 100% ROLL UP
3	11-11-04	ASI #88 1/2

**HEIFER
INTERNATIONAL
CENTER
OFFICE BUILDING**
LITTLE ROCK, ARKANSAS

PSY PROJECT NUMBER:
431C

CONTENTS:
SITE DRAINAGE PLAN

SHEET NUMBER:
C402 1 2 3

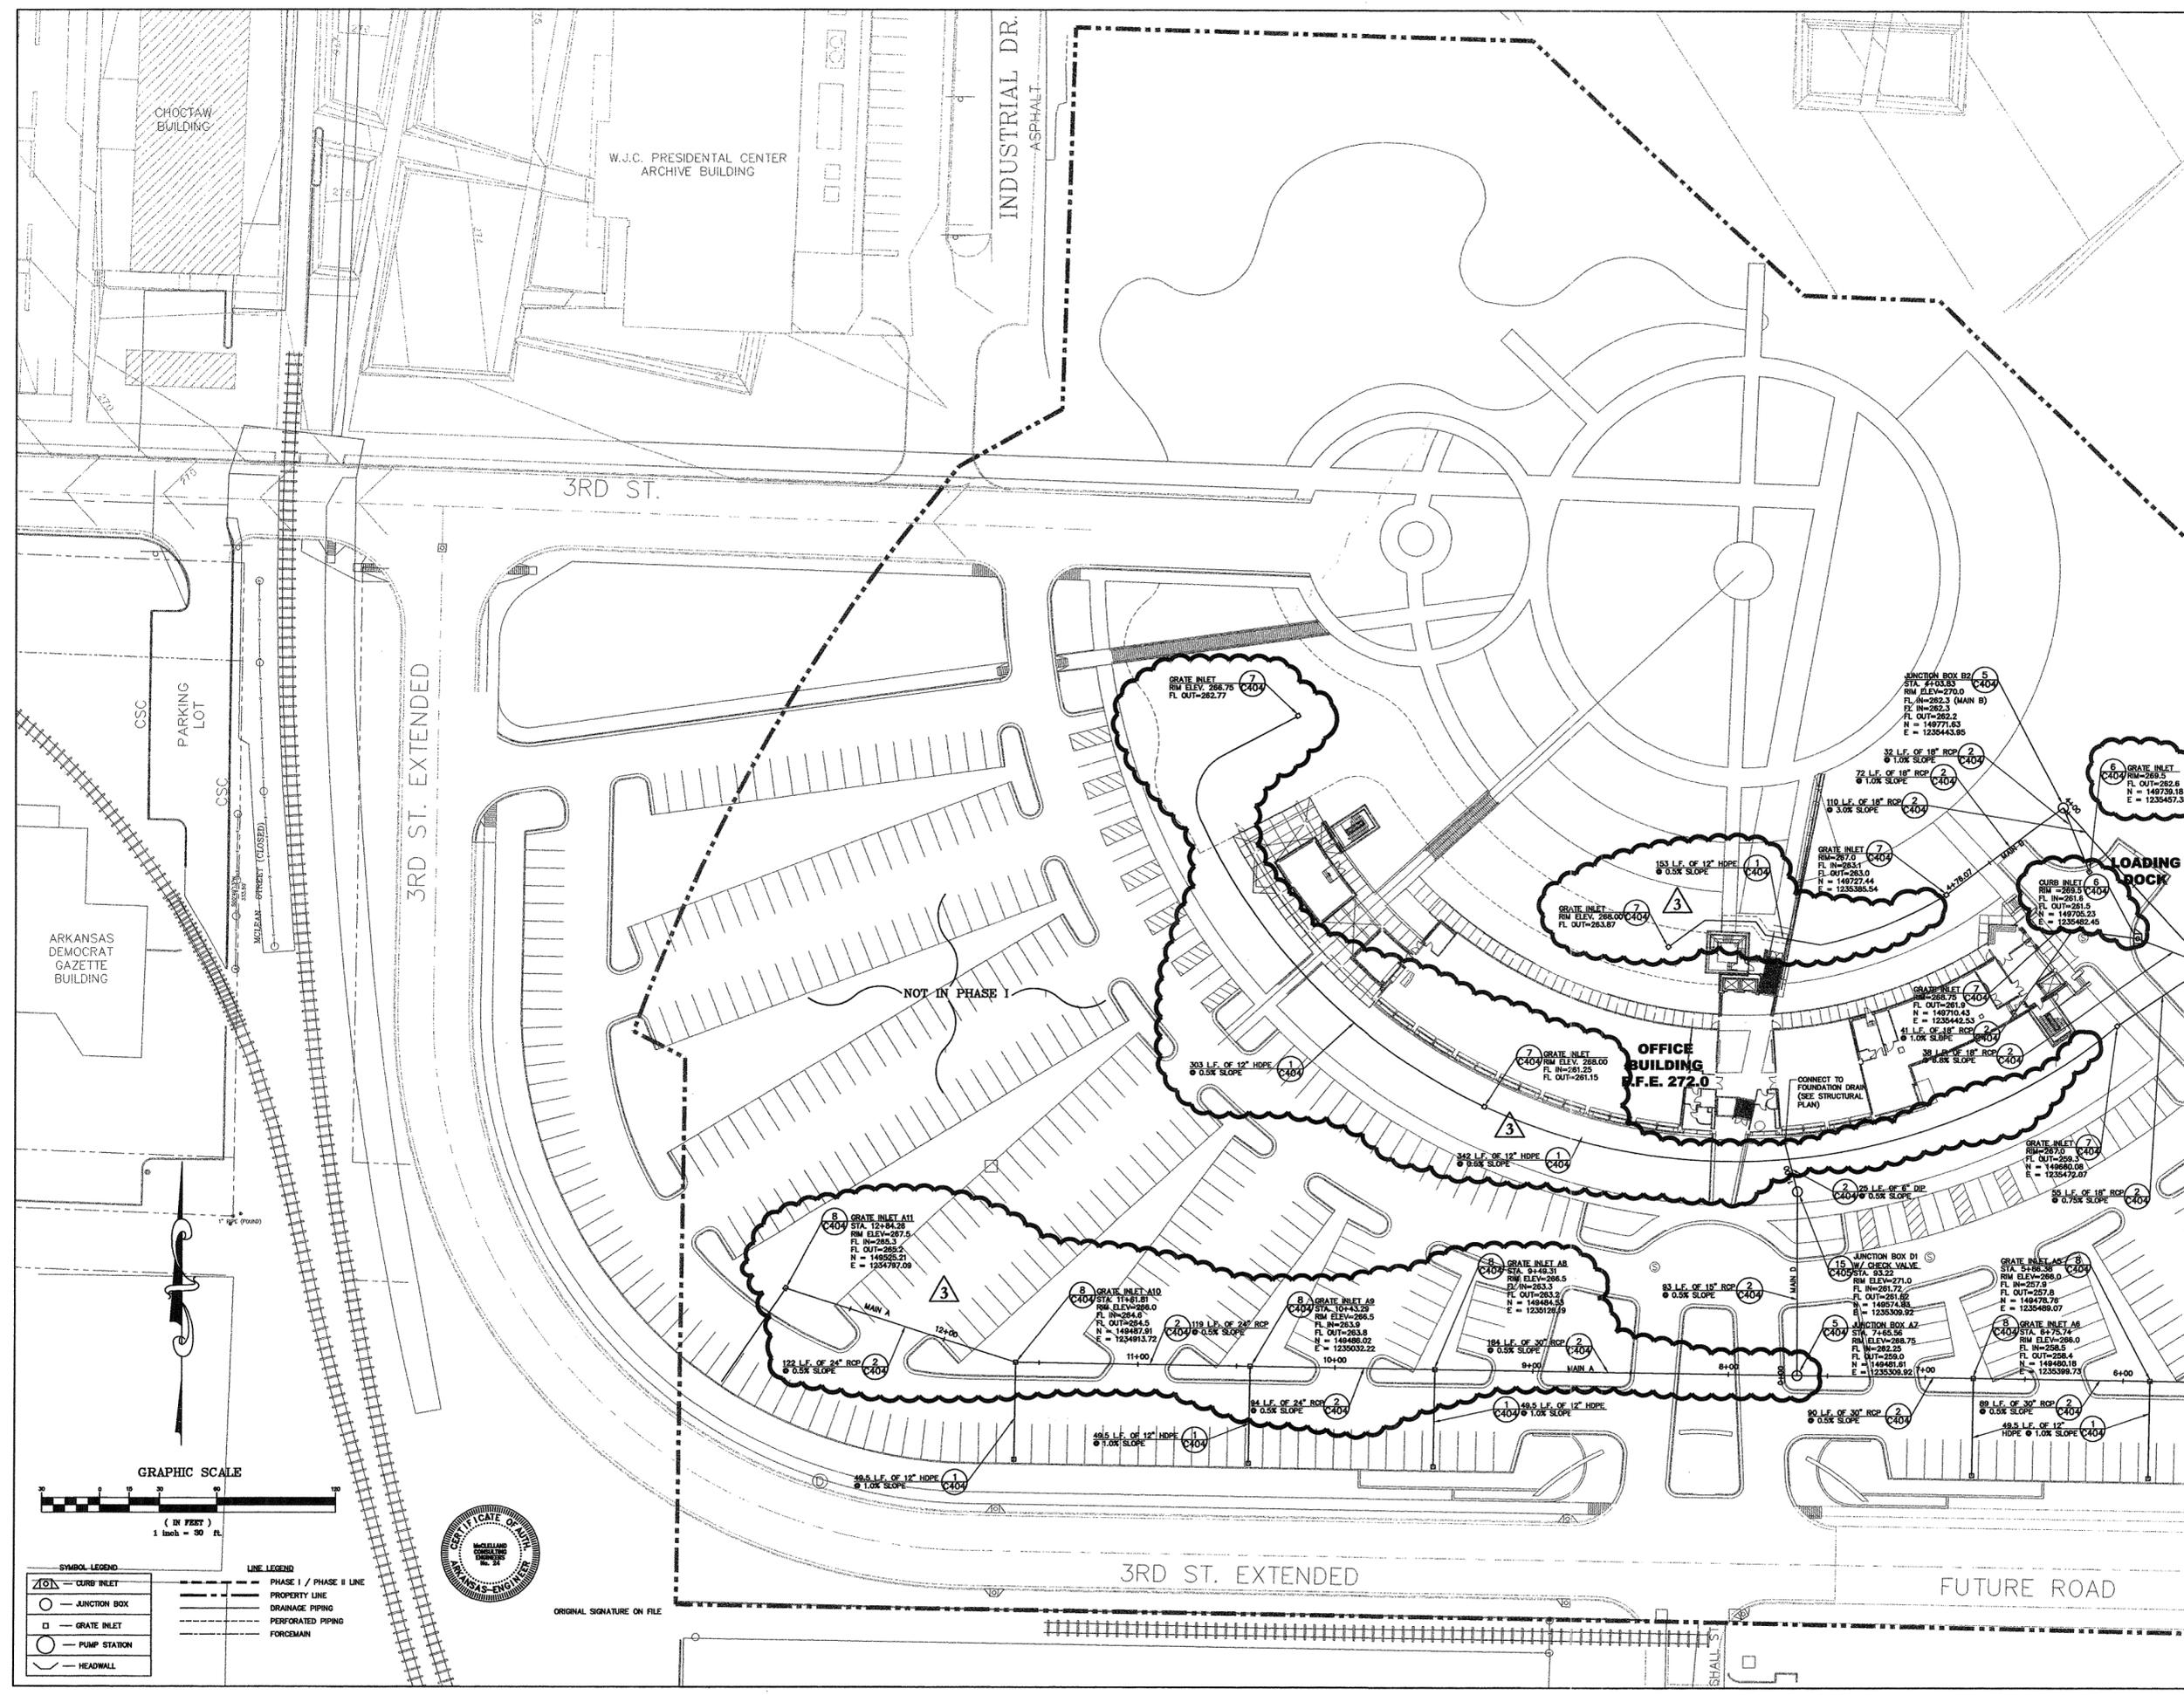

GRAPHIC SCALE
(IN FEET)
1 inch = 30 ft.

SYMBOL LEGEND

- CURB INLET
- JUNCTION BOX
- GRATE INLET
- PUMP STATION
- HEADWALL

LINE LEGEND

- PHASE I / PHASE II LINE
- PROPERTY LINE
- DRAINAGE PIPING
- PERFORATED PIPING
- FORCEMAIN



ORIGINAL SIGNATURE ON FILE