

**POLK
STANLEY
YEARY
ARCHITECTS, LTD.**

700 SOUTH SCHILLER
LITTLE ROCK, AR 72201
501 378-0878
FAX 372-7629

21 W. MOUNTAIN, SUITE 227
FAYETTEVILLE, AR 72701
479-444-0473

CONSULTANTS:
OWNER'S PROJECT ADVISOR:
MOSES TUCKER REAL ESTATE, INC.

CIVIL ENGINEER:
McCLELLAND CONSULTING
ENGINEERS INC.

LANDSCAPE ARCHITECT:
LARSON BURNS SMITH

STRUCTURAL ENGINEER:
CROMWELL ENGINEERS INC.

MECH., ELEC., PLUMB. ENGINEER:
CROMWELL ENGINEERS INC.

SUSTAINABLE CONSULTANT:
BNIM / ELEMENTS

GLOBAL VILLAGE CONSULTANT:
CAMBRIDGE SEVEN ASSOCIATES

INTERIOR DESIGNER:
POLK STANLEY YEARY

GENERAL CONTRACTOR:
CDI CONTRACTORS, INC.

GENERAL NOTES:

NOTES:

ISSUE DATE:
CORE / SHELL
BID PACKAGE #5
DECEMBER 15, 2003

REVISIONS:


#	DATE	DESCRIPTION
1	1-16-04	ADDENDUM #1
2	7-1-04	PKG 7 100% ROLL UP

**HEIFER
INTERNATIONAL
CENTER
OFFICE BUILDING**
LITTLE ROCK, ARKANSAS


PSY PROJECT NUMBER:
431C

CONTENTS:
GRAY WATER
VESSEL PLAN


SHEET NUMBER:
C701

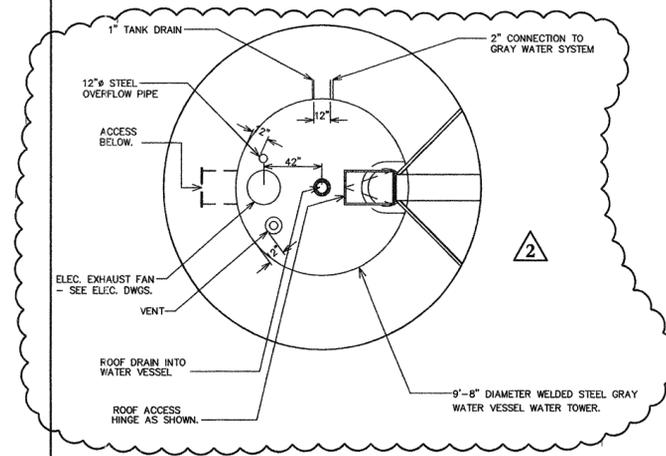

GRAY WATER VESSEL PIPING PLAN
SCALE: N.T.S.

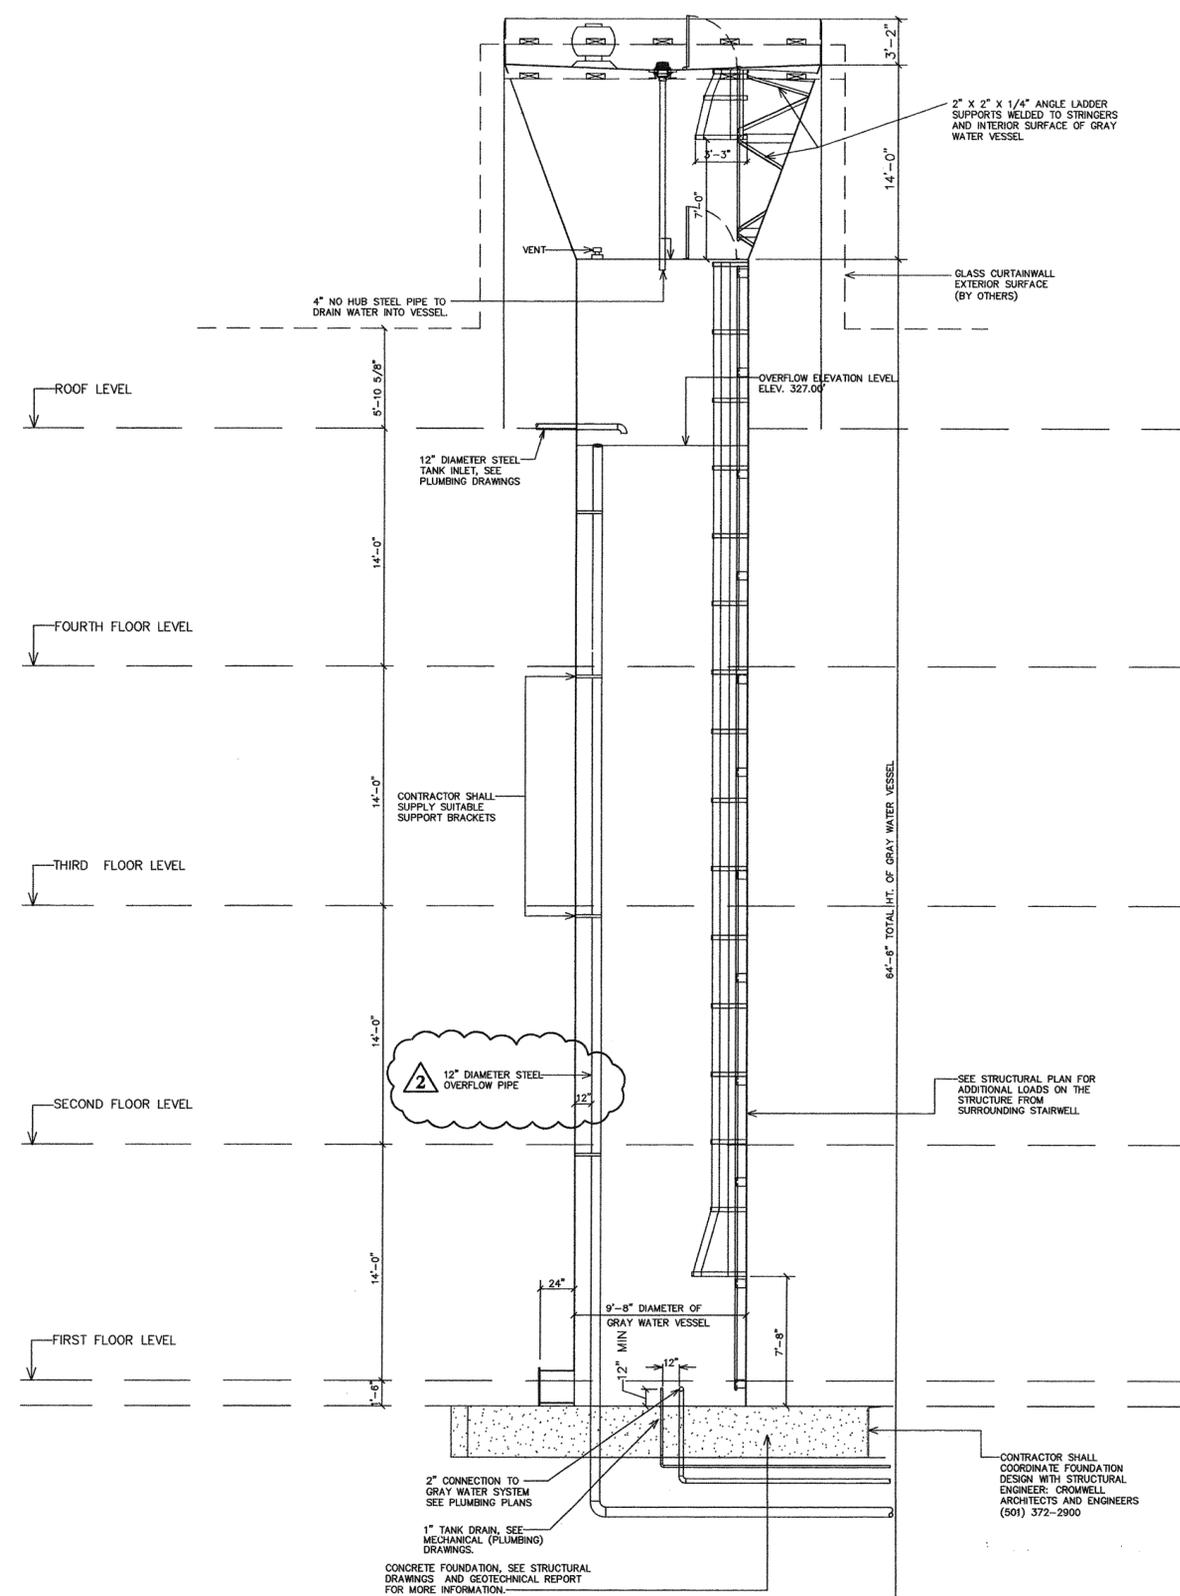

SECTION THRU GRAY VESSEL
SCALE: N.T.S.

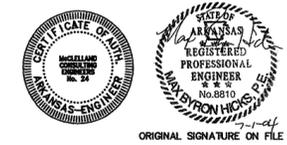

ORIGINAL SIGNATURE ON FILE