

**POLK
STANLEY
YEARY
ARCHITECTS, LTD.**
700 SOUTH SCHILLER
LITTLE ROCK, AR 72201
501.378.4875
FAX 372-7629
21 W. MOUNTAIN, SUITE 227
FAYETTEVILLE, AR 72701
479-444-0473

CONSULTANTS:
OWNER'S PROJECT ADVISOR:
MOSES TUCKER REAL ESTATE, INC.
CIVIL ENGINEER:
MCLELLAND ENGINEERS
LANDSCAPE ARCHITECT:
LARSON BURNS SMITH
STRUCTURAL ENGINEER:
CROMWELL ENGINEERS INC.
MECH. ELEC. PLUMB. ENGINEER:
CROMWELL ENGINEERS INC.
SUSTAINABLE CONSULTANT:
BNIM / ELEMENTS
GLOBAL VILLAGE CONSULTANT
CAMBRIDGE SEVEN ASSOCIATES
INTERIOR DESIGNER:
POLK STANLEY YEARY
GENERAL CONTRACTOR:
CDI


GENERAL NOTES:
1. PROVIDE POWER AND DISCONNECTS FOR TWO 5HP PUMPS. SEE C403 FOR LOCATIONS. CIRCUIT TO HCT-13,15,17 AND HCT-14,16,18 (BOTH USING #8 CONDUCTORS IN 1" CONDUIT).
2. COORDINATE ROUTE OF CONDUITS FROM MECHANICAL YARD TO BUILDING WITH OTHER TRADES.

ISSUE DATE:
DECEMBER 15, 2003
CORE/SHELL
PACKAGE #5
REVISIONS:
DATE DESCRIPTION
1 1/16/04 ADDENDUM #1
2 1/23/04 PACKAGE 5 - ADDM. 02
3 05/26/04 ASI#03
4 07/01/04 PACKAGE 7, 100% ROLLUP
5 10/12/04 ASI #20

**HEIFER
INTERNATIONAL
CENTER
OFFICE BUILDING**
LITTLE ROCK, ARKANSAS

PSY PROJECT NUMBER:
431C


CONTENTS:
ELECTRICAL SITE PLAN
SHEET NUMBER:
E001

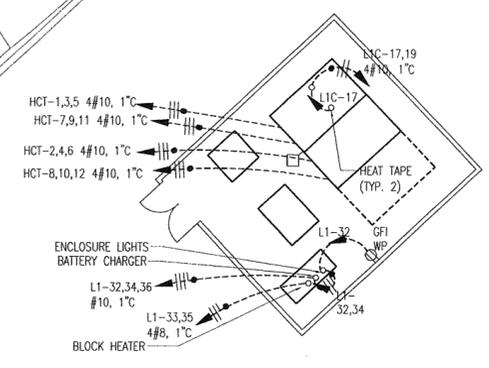


2 ENLARGED EQUIPMENT YARD




- GENERAL NOTES:**
1. PROVIDE POWER AND DISCONNECTS FOR TWO 5HP PUMPS. SEE C403 FOR LOCATIONS. CIRCUIT TO HCT-13,15,17 AND HCT-14,16,18 (BOTH USING #8 CONDUCTORS IN 1" CONDUIT).
 2. COORDINATE ROUTE OF CONDUITS FROM MECHANICAL YARD TO BUILDING WITH OTHER TRADES.

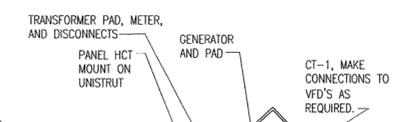

NOTES:

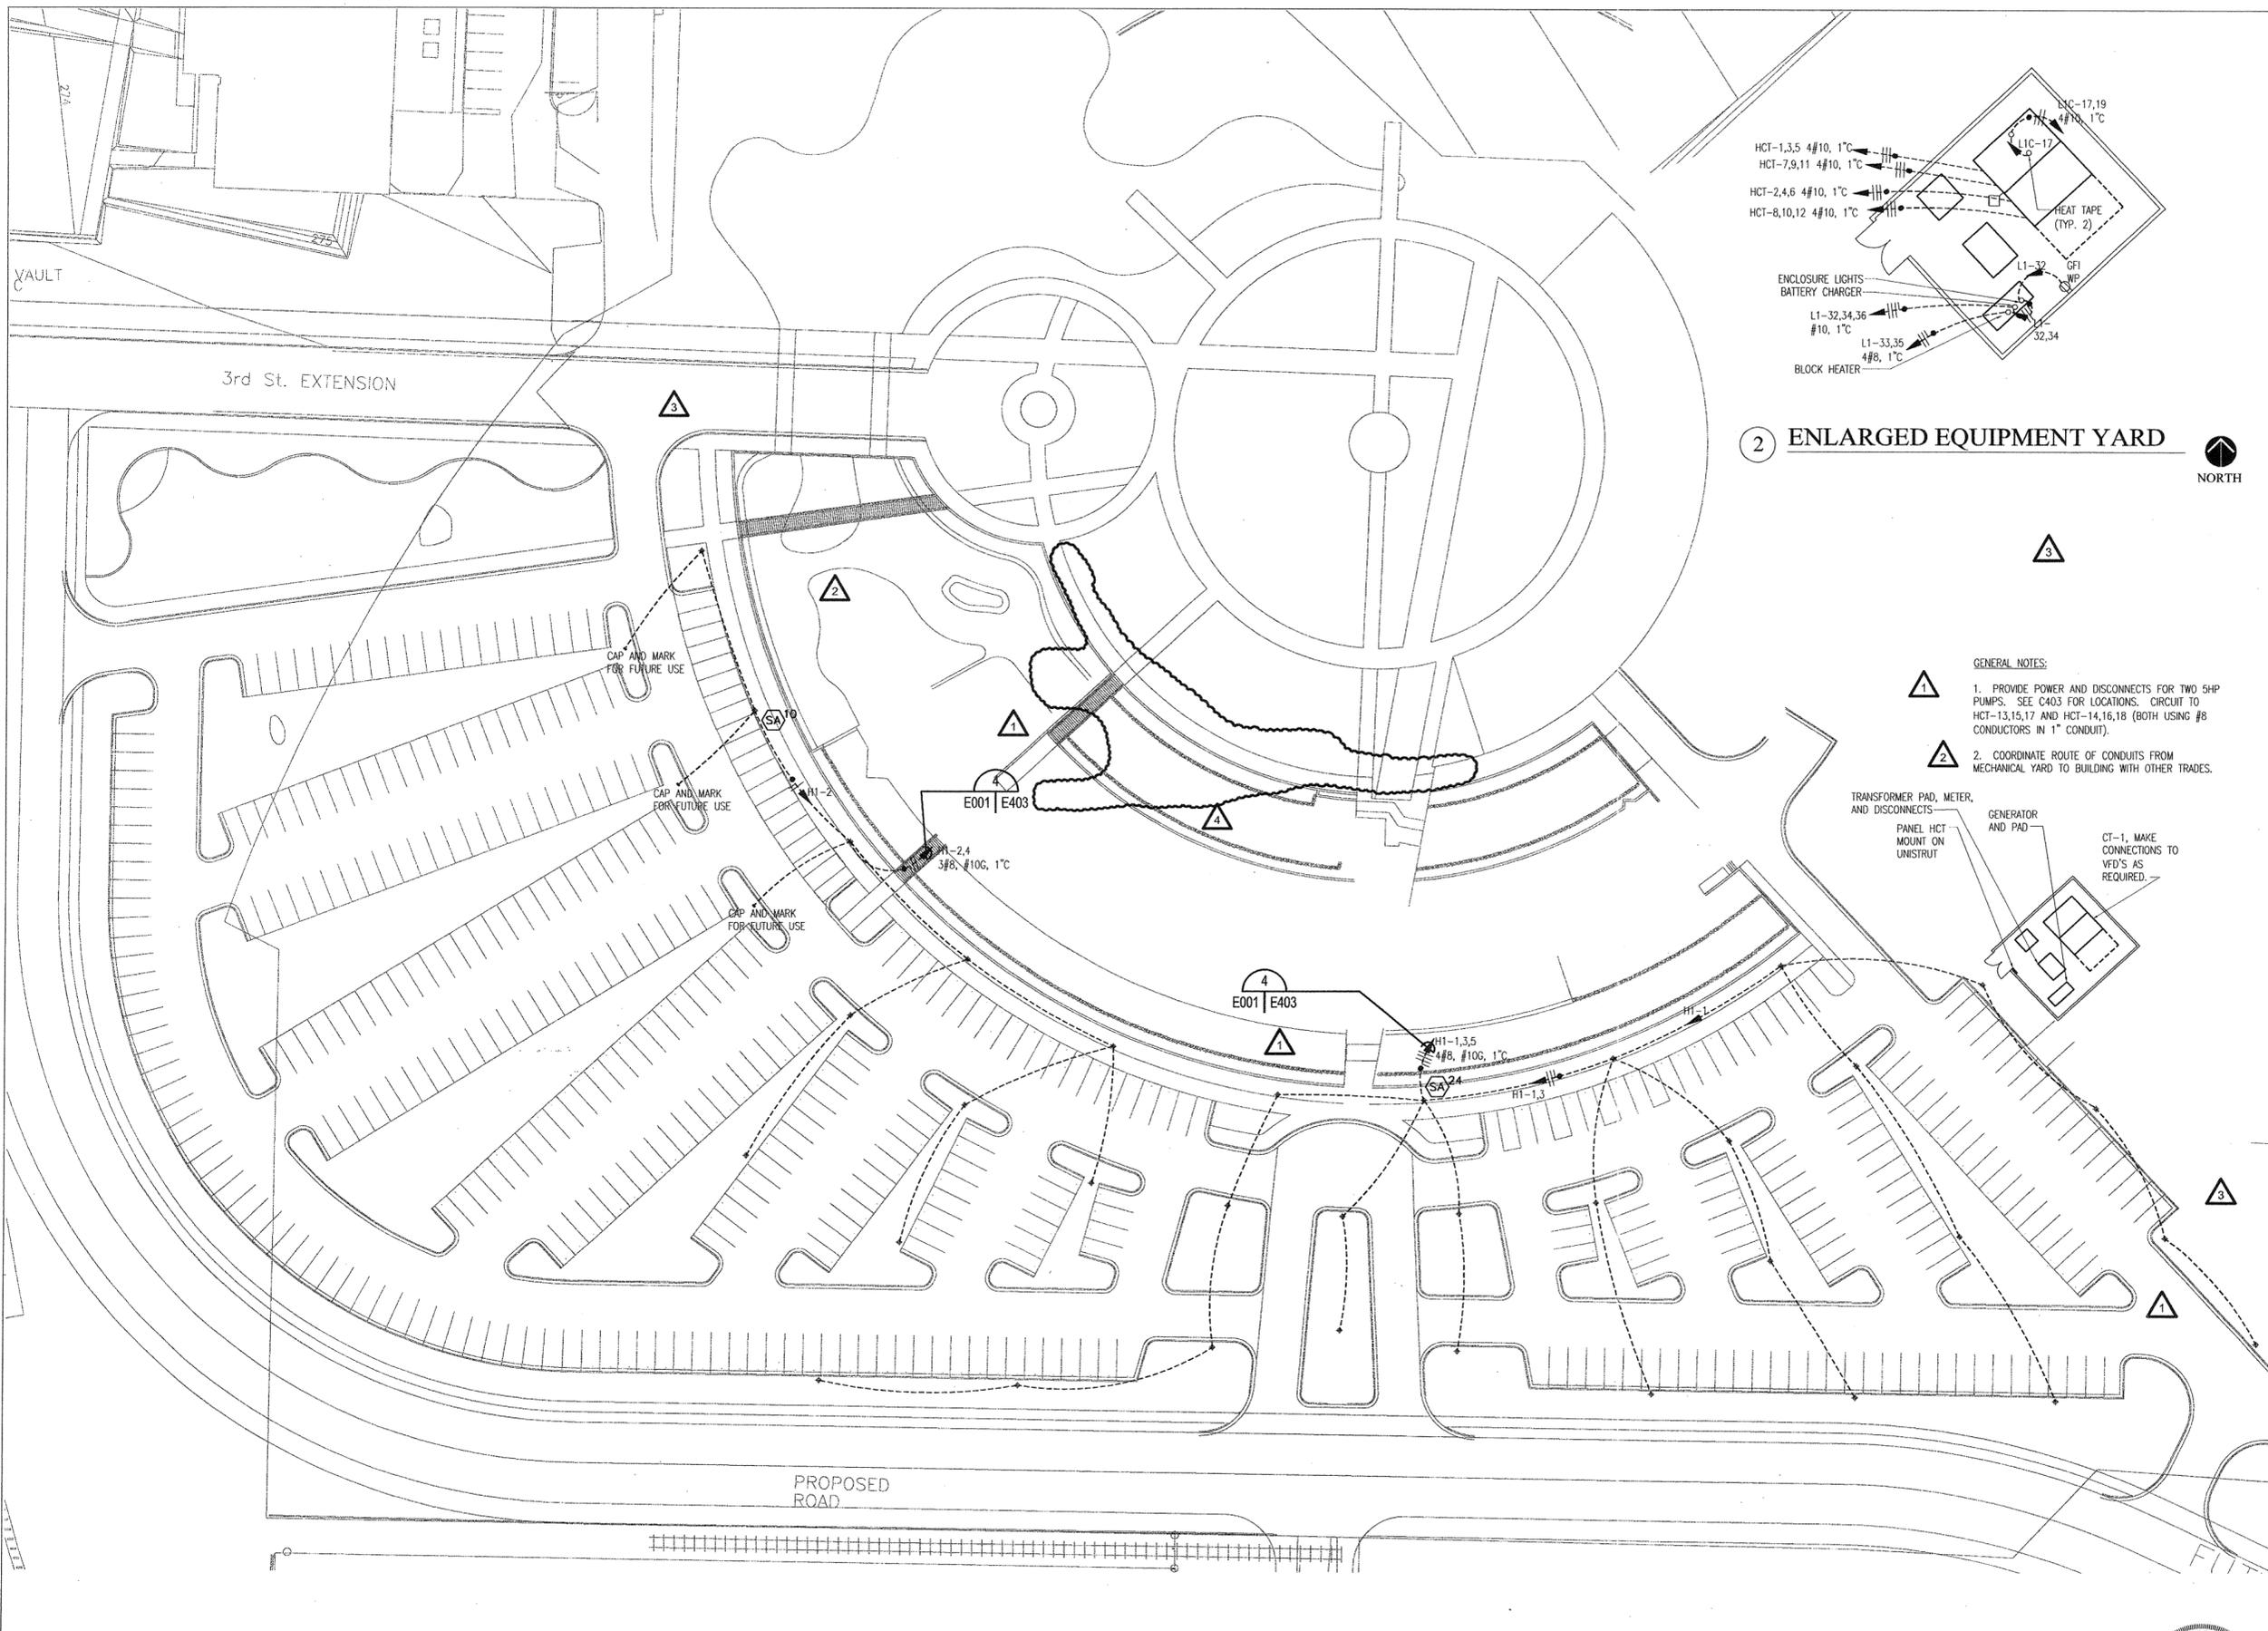

 1 ELECTRICAL SITE PLAN
SCALE: 1" = 30'-0"



12/15/03