

**POLK  
STANLEY  
YEARY  
ARCHITECTS, LTD.**

780 SOUTH SCHILLER  
LITTLE ROCK, AR 72201  
501.378.0878  
FAX 372-7629

21 W. MOUNTAIN, SUITE 227  
FAYETTEVILLE, AR 72701  
479-444-0473

**CONSULTANTS:**

OWNER'S PROJECT ADVISOR:  
MOSES TUCKER REAL ESTATE, INC.

CIVIL ENGINEER:  
McCLELLAND ENGINEERS

LANDSCAPE ARCHITECT:  
LARSON BURNS SMITH

STRUCTURAL ENGINEER:  
CROMWELL ENGINEERS INC.

MECH., ELEC., PLUMB. ENGINEER:  
CROMWELL ENGINEERS INC.

SUSTAINABLE CONSULTANT:  
BNIM / ELEMENTS

GLOBAL VILLAGE CONSULTANT  
CAMBRIDGE SEVEN ASSOCIATES

INTERIOR DESIGNER:  
POLK STANLEY YEARY

GENERAL CONTRACTOR:  
CDI

**GENERAL NOTES:**

**NOTES:**

---



---



---



---



---



---



---



---

ISSUE DATE:  
DECEMBER 15, 2003  
CORE/SHELL  
PACKAGE #5

REVISIONS:


#	DATE	DESCRIPTION
1	1/16/04	ADDENDUM #1
2	4/07/04	PACKAGE 5 - ADDM. 05
3	7/01/04	PACKAGE 7, 100% ROLLUP
4	10/12/04	ASI #20
5	11/29/04	ASI #27

**HEIFER  
INTERNATIONAL  
CENTER  
OFFICE BUILDING**

LITTLE ROCK, ARKANSAS

PSY PROJECT NUMBER:  
431C

CONTENTS:  
THIRD FLOOR LIGHTING  
PLAN - EAST END  
SHEET NUMBER:  
**E103a**

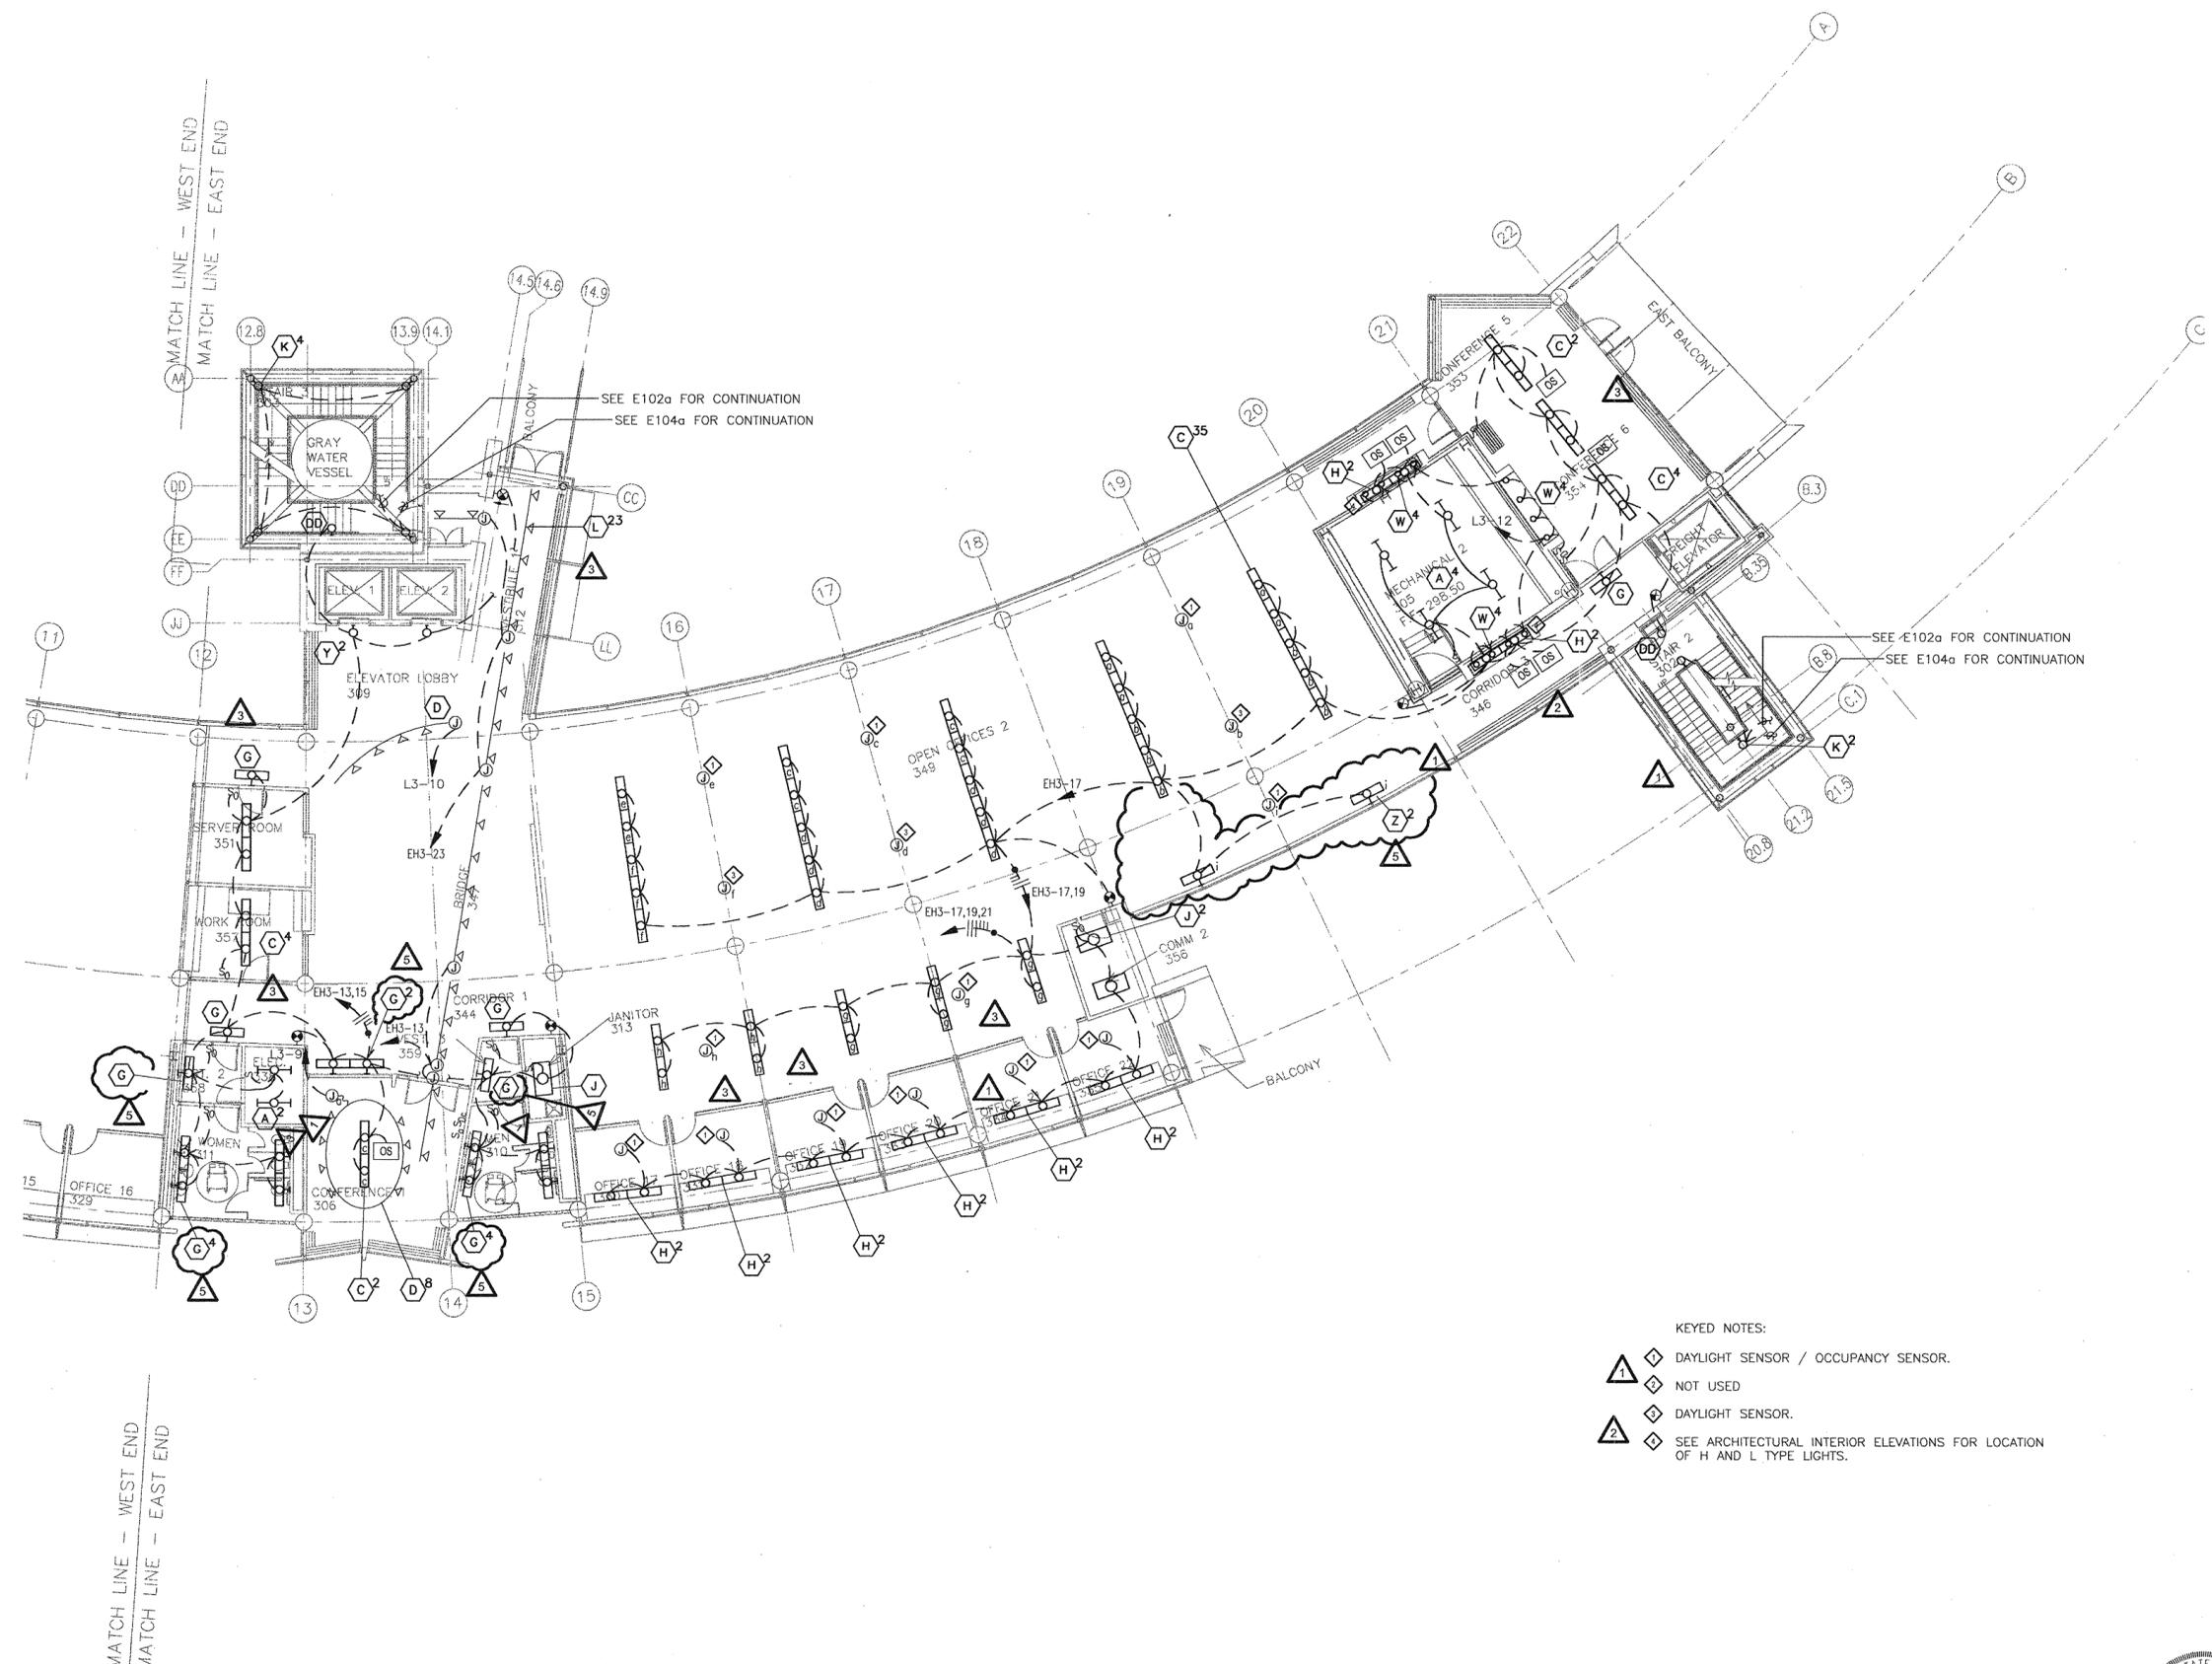


**KEYED NOTES:**

▲ DAYLIGHT SENSOR / OCCUPANCY SENSOR.  
◆ NOT USED  
▲ DAYLIGHT SENSOR.  
◆ SEE ARCHITECTURAL INTERIOR ELEVATIONS FOR LOCATION OF H AND L TYPE LIGHTS.

MATCH LINE - WEST END  
MATCH LINE - EAST END

**1 THIRD FLOOR LIGHTING PLAN - EAST END**  
SCALE: 1/8" = 1'-0"

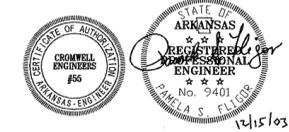

▲