

CONSULTANTS:

OWNER'S PROJECT ADVISOR:
MOSES TUCKER REAL ESTATE, INC.

CIVIL ENGINEER:
McCLELLAND ENGINEERS

LANDSCAPE ARCHITECT:
LARSON BURNS SMITH

STRUCTURAL ENGINEER:
CROMWELL ENGINEERS INC.

MECH., ELEC., PLUMB. ENGINEER:
CROMWELL ENGINEERS INC.

SUSTAINABLE CONSULTANT:
BNIM / ELEMENTS

GLOBAL VILLAGE CONSULTANT
CAMBRIDGE SEVEN ASSOCIATES

INTERIOR DESIGNER:
POLK STANLEY YEARY

GENERAL CONTRACTOR:
CDI

GENERAL NOTES:

NOTES:

ISSUE DATE:
DECEMBER 15, 2003
CORE/SHELL
PACKAGE #5

REVISIONS:


#	DATE	DESCRIPTION
3	4/07/04	PACKAGE 5 - ADDM. 05
4	7/01/04	PACKAGE 7, 100% ROLLUP
5	10/12/04	ASI #20
6	11/29/04	ASI #27
7	12/27/04	ASI #29

**HEIFER
INTERNATIONAL
CENTER
OFFICE BUILDING**

LITTLE ROCK, ARKANSAS

PSY PROJECT NUMBER:
431C

CONTENTS:
FIRST FLOOR POWER
PLAN - EAST END
SHEET NUMBER:
E201a

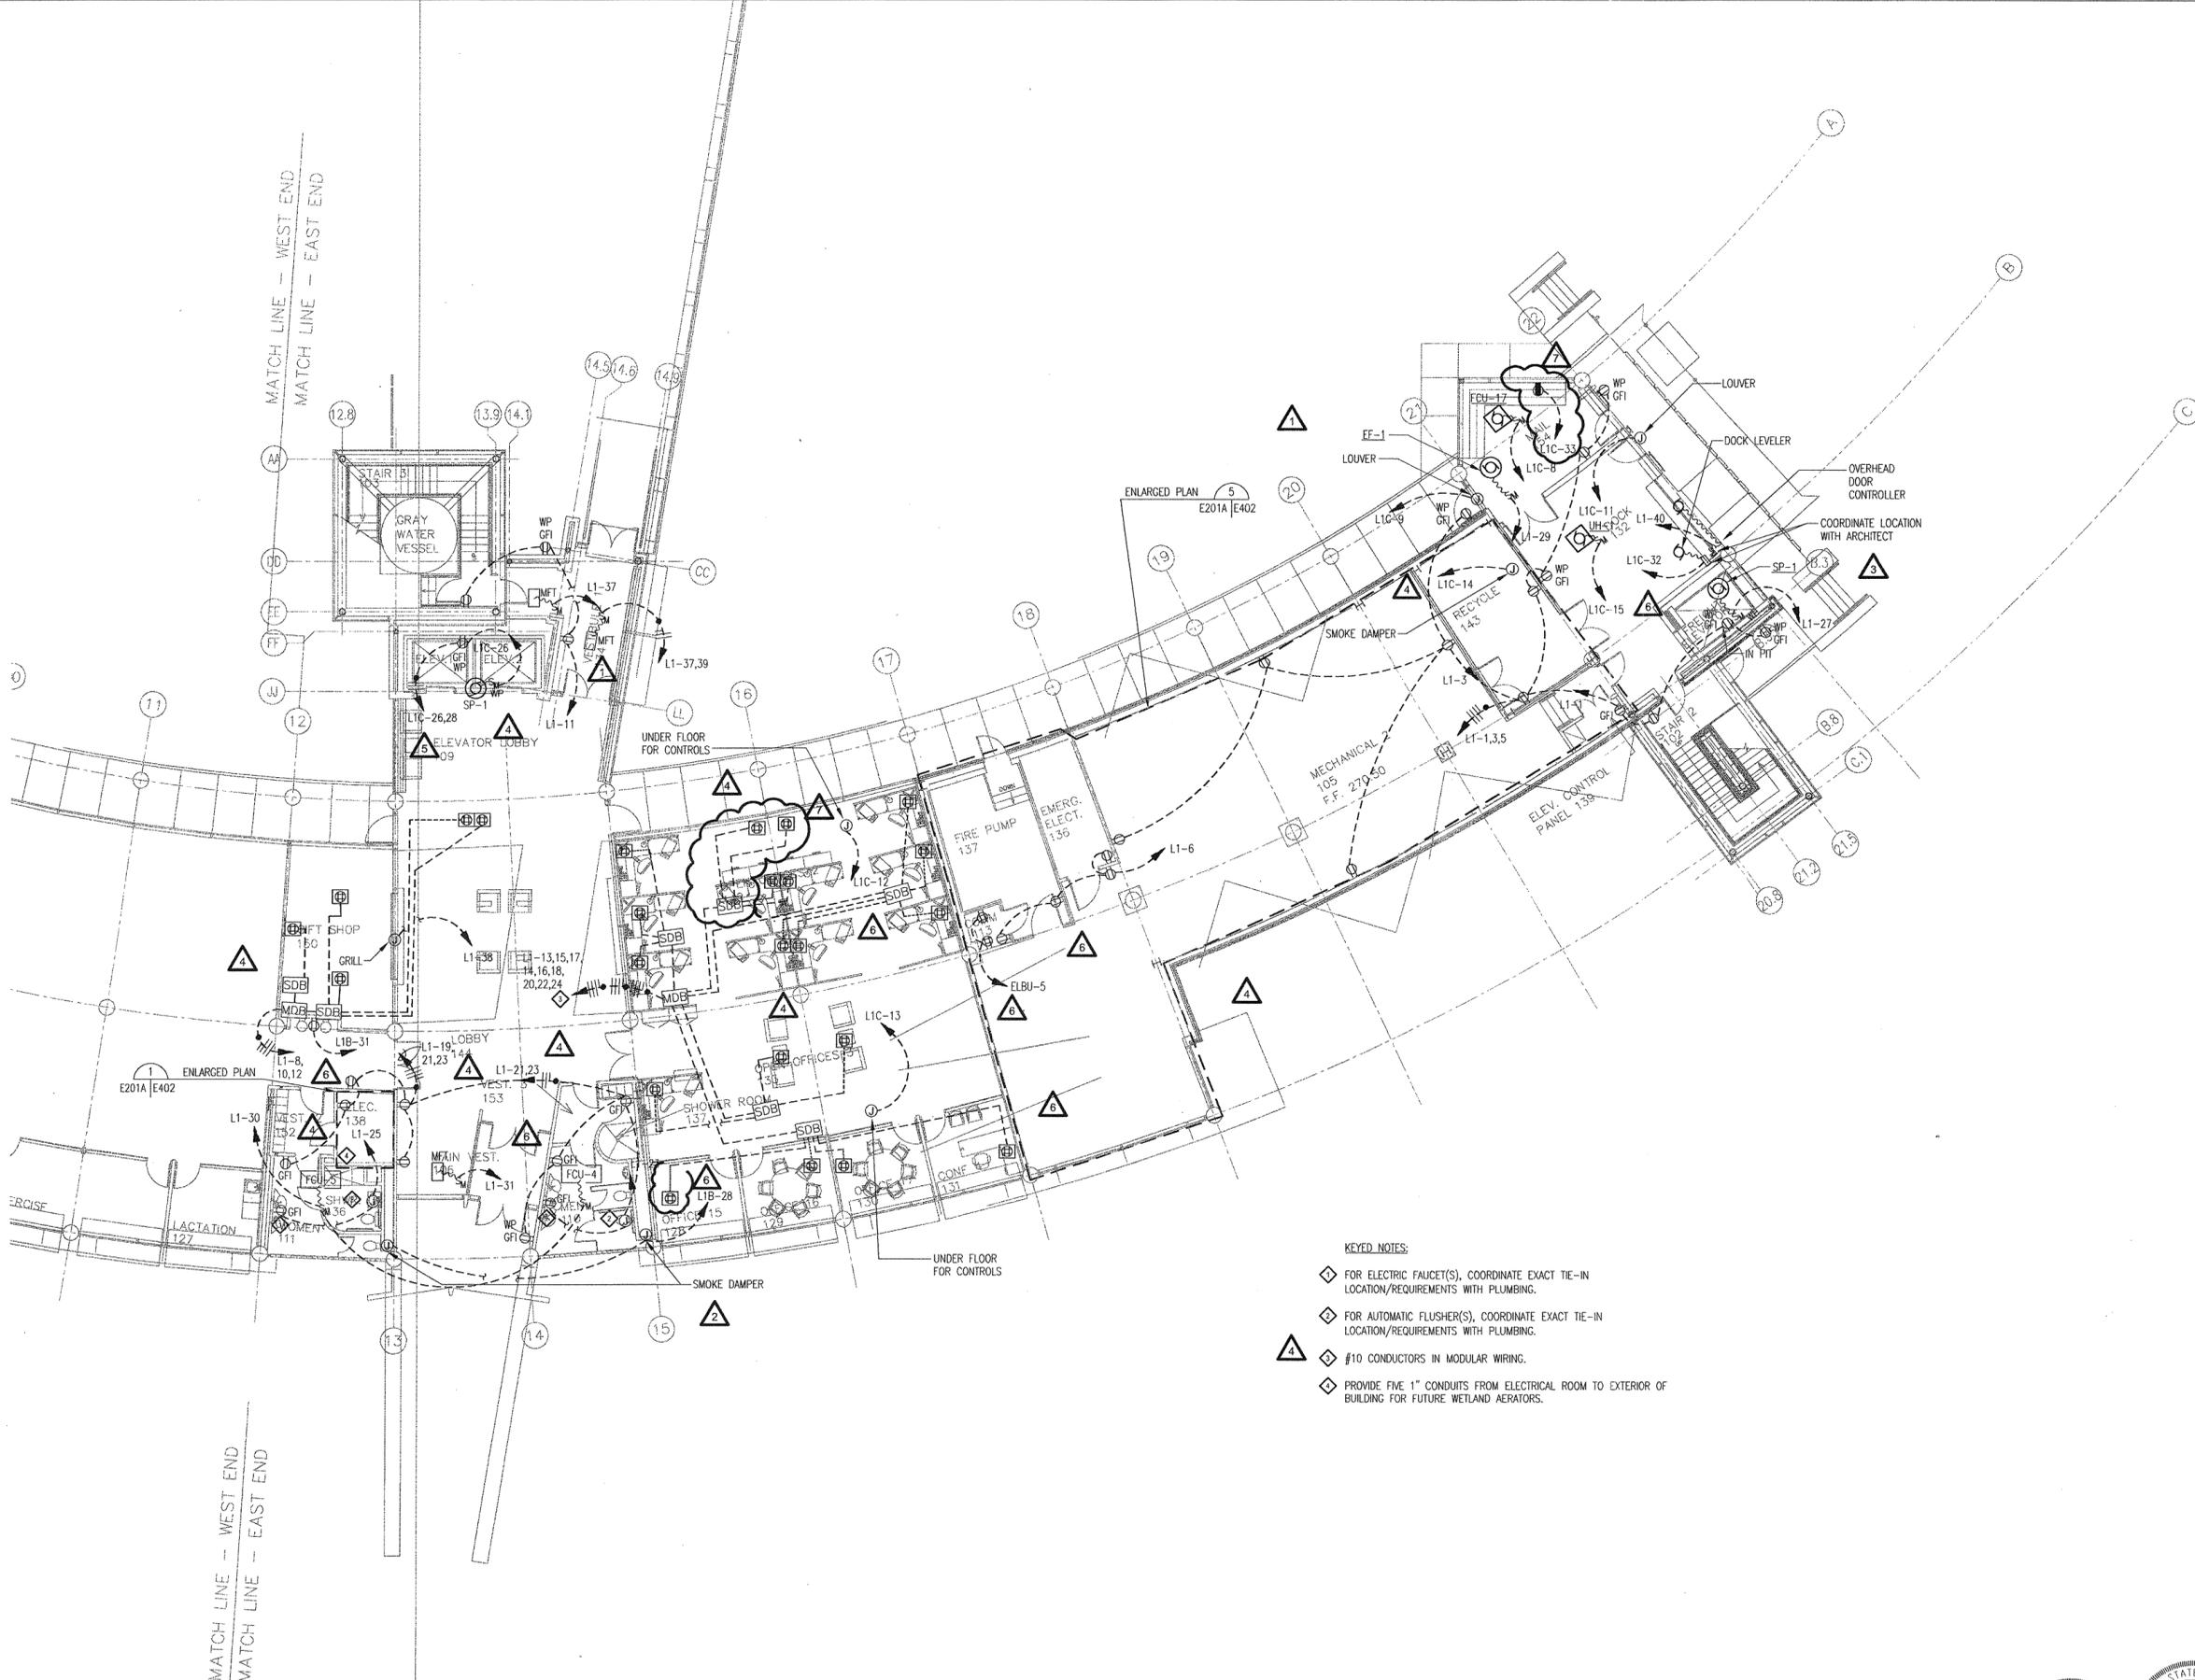

- KEYED NOTES:**
- ◆ FOR ELECTRIC FAUCET(S), COORDINATE EXACT TIE-IN LOCATION/REQUIREMENTS WITH PLUMBING.
 - ◆ FOR AUTOMATIC FLUSHER(S), COORDINATE EXACT TIE-IN LOCATION/REQUIREMENTS WITH PLUMBING.
 - ▲ #10 CONDUCTORS IN MODULAR WIRING.
 - ◆ PROVIDE FIVE 1" CONDUITS FROM ELECTRICAL ROOM TO EXTERIOR OF BUILDING FOR FUTURE WETLAND AERATORS.

1 FIRST FLOOR POWER PLAN - EAST END
SCALE: 1/8" = 1'-0"



COPYRIGHT © 2003 POLK STANLEY YEARY ARCHITECTS, LTD.