

**POLK
STANLEY
YEARY
ARCHITECTS, LTD.**

700 SOUTH SCHILLER
LITTLE ROCK, AR 72201
501.378-4878
FAX 372-7629

21 W. MOUNTAIN, SUITE 227
FAYETTEVILLE, AR 72701
479-444-0473

CONSULTANTS:

OWNER'S PROJECT ADVISOR:
MOSES TUCKER REAL ESTATE, INC.

CIVIL ENGINEER:
MCLELLAND ENGINEERS

LANDSCAPE ARCHITECT:
LARSON BURNS SMITH

STRUCTURAL ENGINEER:
CROMWELL ENGINEERS INC.

MECH., ELEC., PLUMB. ENGINEER:
CROMWELL ENGINEERS INC.

SUSTAINABLE CONSULTANT:
BNIM / ELEMENTS

GLOBAL VILLAGE CONSULTANT
CAMBRIDGE SEVEN ASSOCIATES

INTERIOR DESIGNER:
POLK STANLEY YEARY

GENERAL CONTRACTOR:
CDI

GENERAL NOTES:

NOTES:

ISSUE DATE:
DECEMBER 15, 2003
CORE/SHELL
PACKAGE #5

REVISIONS:

#	DATE	DESCRIPTION
1	1/16/04	ADDENDUM #1
2	1/28/04	PACKAGE 5 - ADDM. 03
3	7/01/04	PACKAGE 7, 100% ROLLUP
4	11/29/04	ASI #27


**HEIFER
INTERNATIONAL
CENTER
OFFICE BUILDING**

LITTLE ROCK, ARKANSAS

PSY PROJECT NUMBER:
431C

CONTENTS:
ELECTRICAL ROOF PLAN
- EAST END
SHEET NUMBER:

E205a

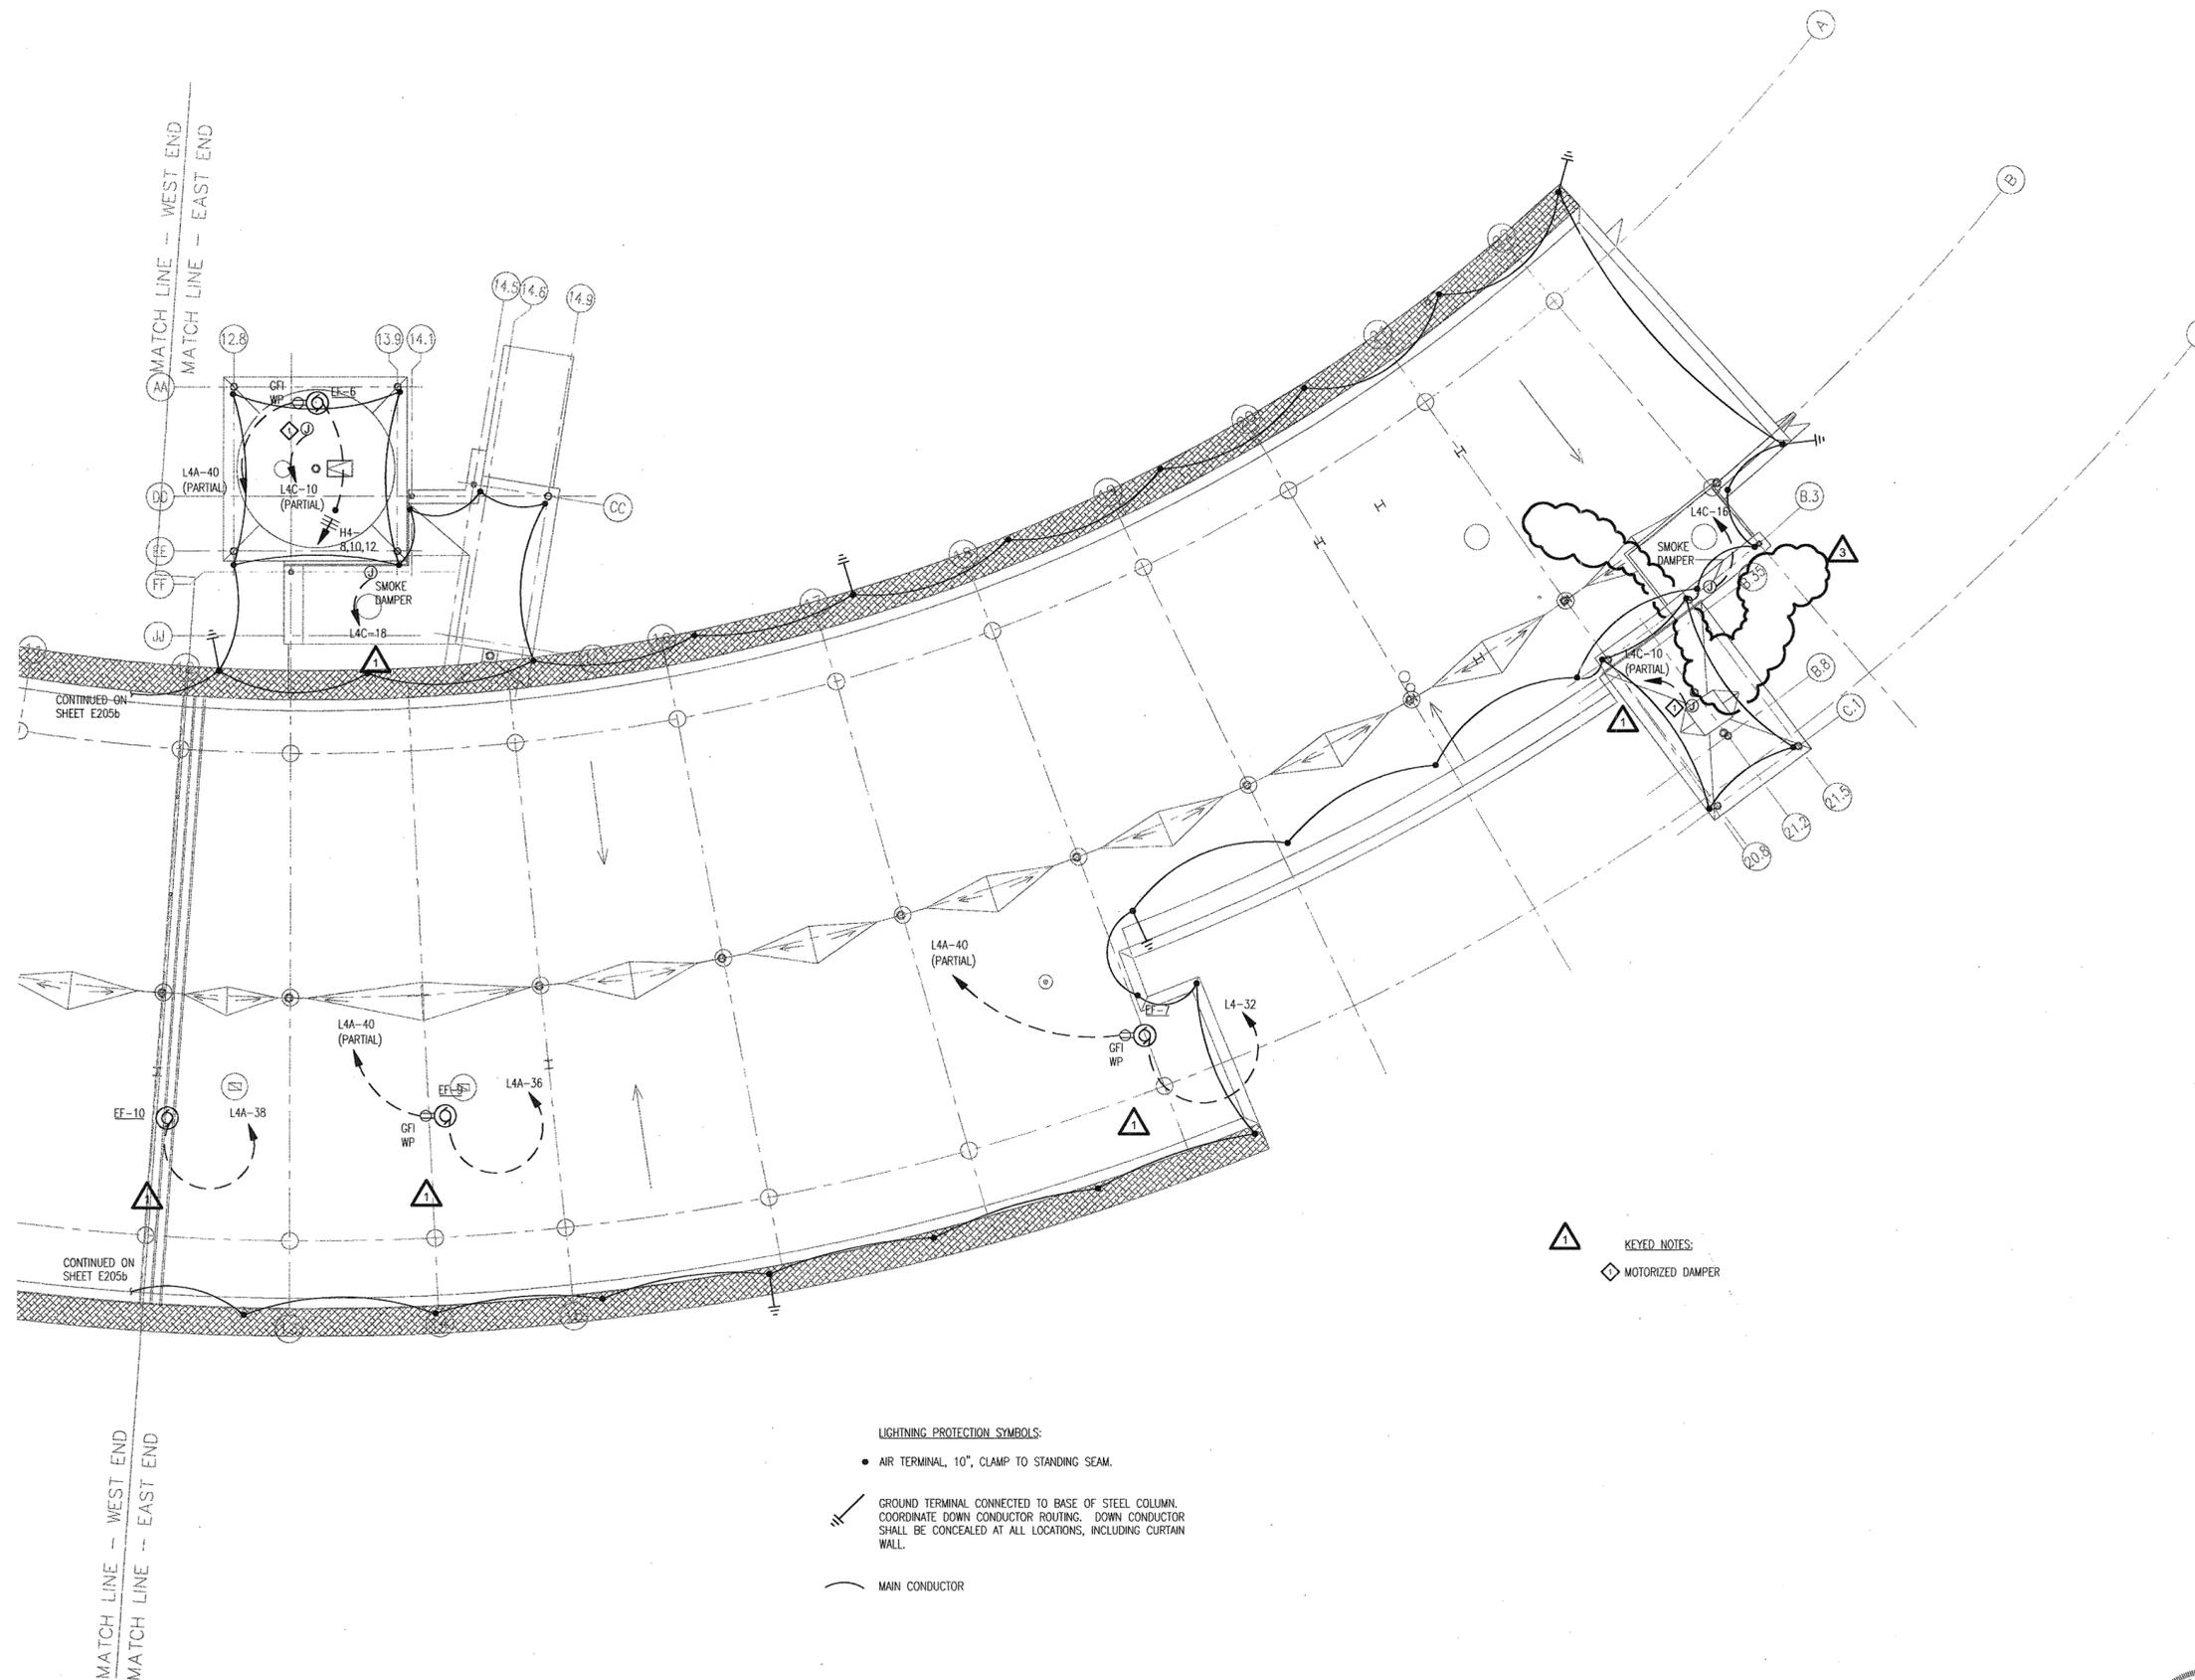

LIGHTNING PROTECTION SYMBOLS:

● AIR TERMINAL, 10", CLAMP TO STANDING SEAM.

⚡ GROUND TERMINAL CONNECTED TO BASE OF STEEL COLUMN.
COORDINATE DOWN CONDUCTOR ROUTING. DOWN CONDUCTOR
SHALL BE CONCEALED AT ALL LOCATIONS, INCLUDING CURTAIN
WALL.

— MAIN CONDUCTOR

⚠ KEYED NOTES:
◇ MOTORIZED DAMPER

1 ELECTRICAL ROOF PLAN - EAST END

SCALE: 1/8" = 1'-0"



2/15/03