

CONSULTANTS:

OWNERS PROJECT ADVISOR:
MOSES TUCKER REAL ESTATE, INC.

CIVIL ENGINEER:
McCLELLAND ENGINEERS

LANDSCAPE ARCHITECT:
LARSON BURNS SMITH

STRUCTURAL ENGINEER:
CROMWELL ENGINEERS INC.

MECH., ELEC., PLUMB. ENGINEER:
CROMWELL ENGINEERS INC.

SUSTAINABLE CONSULTANT:
BNIM / ELEMENTS

GLOBAL VILLAGE CONSULTANT
CAMBRIDGE SEVEN ASSOCIATES

INTERIOR DESIGNER:
POLK STANLEY YEARY

GENERAL CONTRACTOR:
CDI

GENERAL NOTES:

NOTES:

ISSUE DATE:
DECEMBER 15, 2003
CORE/SHELL
PACKAGE #5

REVISIONS:


#	DATE	DESCRIPTION
1	1/16/04	ADDENDUM #1
2	1/23/04	PACKAGE 5 - ADDM. 02
3	7/01/04	PACKAGE 7, 100% ROLLUP
4	11/29/04	ASI #27

**HEIFER
INTERNATIONAL
CENTER
OFFICE BUILDING**

LITTLE ROCK, ARKANSAS

PSY PROJECT NUMBER:
431C

CONTENTS:
SECOND FLOOR POWER
PLAN - EAST END
SHEET NUMBER:
E202a

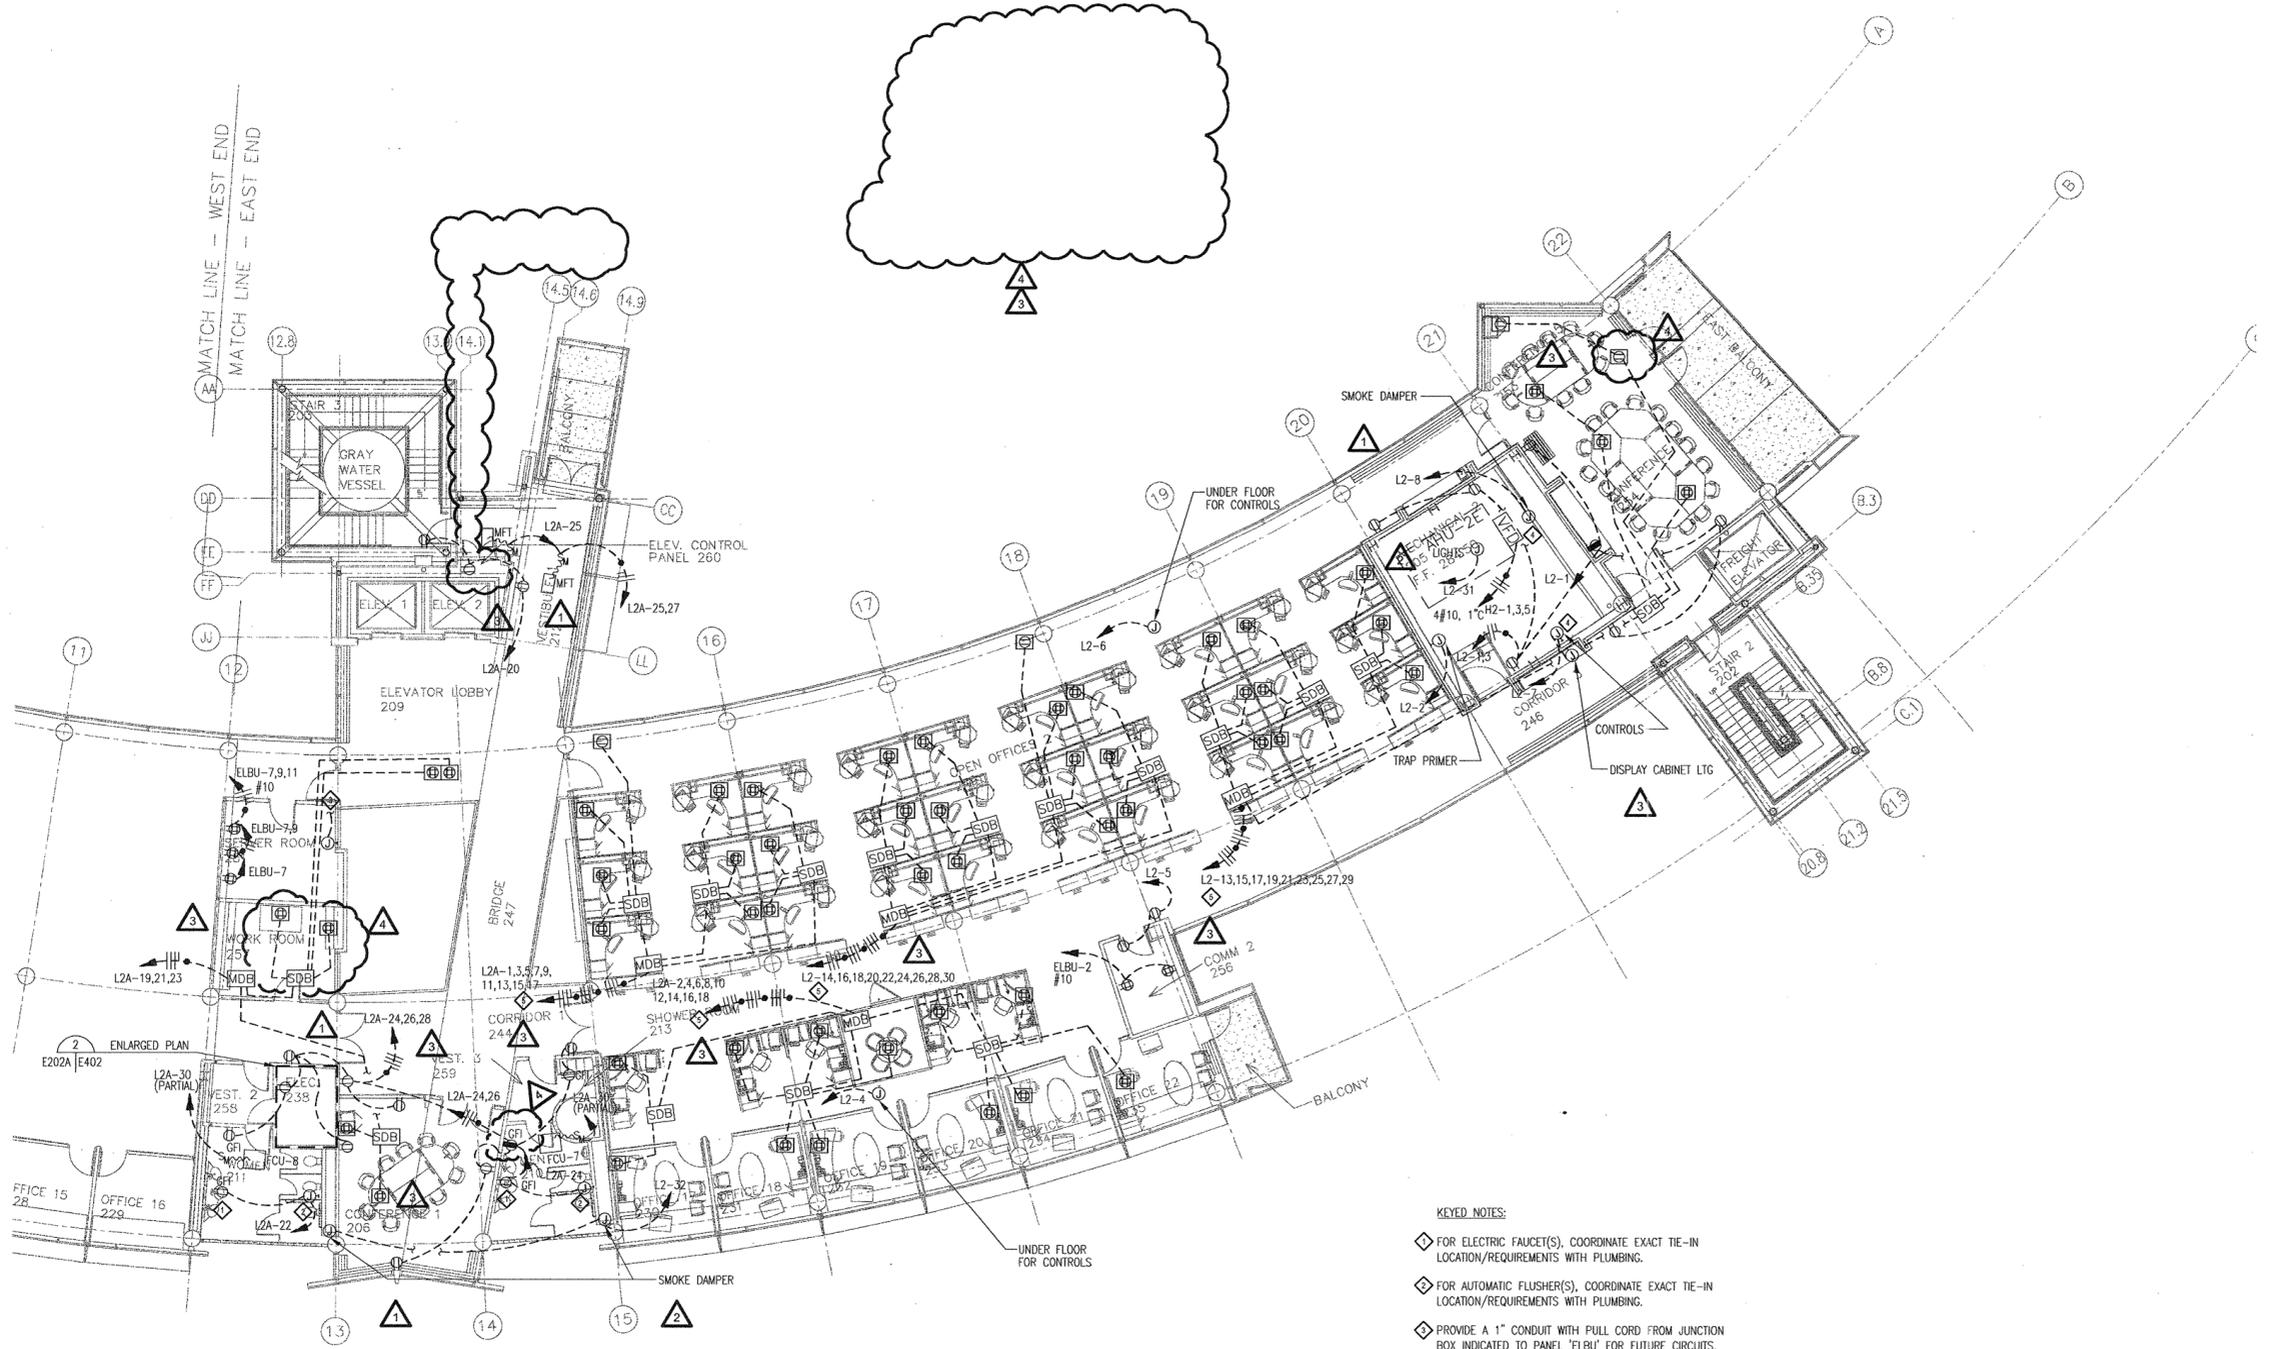

- KEYED NOTES:**
- ◆ FOR ELECTRIC FAUCET(S), COORDINATE EXACT TIE-IN LOCATION/REQUIREMENTS WITH PLUMBING.
 - ◆ FOR AUTOMATIC FLUSHER(S), COORDINATE EXACT TIE-IN LOCATION/REQUIREMENTS WITH PLUMBING.
 - ◆ PROVIDE A 1" CONDUIT WITH FULL CORD FROM JUNCTION BOX INDICATED TO PANEL 'ELBU' FOR FUTURE CIRCUITS.
 - ◆ COORDINATE EXACT LOCATION WITH MECHANICAL.
 - ◆ #10 CONDUCTORS IN MODULAR WIRING.
 - ◆ SEE E501 FOR CIRCUIT INFORMATION.
 - ◆ PUSH BUTTON WITH PROTECTIVE COVER. ACTIVATION OF PUSH BUTTON SHALL CAUSE BOTH PASSENGER ELEVATOR CIRCUIT BREAKERS TO SHUNT TRIP. BUTTON SHALL BE LABELED "EMERGENCY POWER OFF - ELEVATOR MOTORS".
 - ◆ COORDINATE ALL DEVICE LOCATIONS AND REQUIREMENTS WITH ELEVATOR SUPPLIER AND STATE ELEVATOR INSPECTOR, SO THAT ELEVATOR INSTALLATION MEETS ALL CODES AND REQUIREMENTS. COORDINATE WITH FIRE ALARM SYSTEM PROVIDER FOR CONNECTIONS AND REQUIREMENTS.

1 SECOND FLOOR POWER PLAN - EAST END
SCALE: 1/8" = 1'-0"

