

**POLK  
STANLEY  
YEARY  
ARCHITECTS, LTD.**

700 SOUTH SCHILLER  
LITTLE ROCK, AR 72201  
501 378-6878  
FAX 372-7629

21 W. MOUNTAIN, SUITE 227  
FAYETTEVILLE, AR 72701  
479-444-0473

**CONSULTANTS:**

OWNER'S PROJECT ADVISOR:  
MOSES TUCKER REAL ESTATE, INC.

CIVIL ENGINEER:  
MCLELLAND ENGINEERS

LANDSCAPE ARCHITECT:  
LARSON BURNS SMITH

STRUCTURAL ENGINEER:  
CROMWELL ENGINEERS INC.

MECH., ELEC., PLUMB. ENGINEER:  
CROMWELL ENGINEERS INC.

SUSTAINABLE CONSULTANT:  
BNIM / ELEMENTS

GLOBAL VILLAGE CONSULTANT  
CAMBRIDGE SEVEN ASSOCIATES

INTERIOR DESIGNER:  
POLK STANLEY YEARY

GENERAL CONTRACTOR:  
CDI

**GENERAL NOTES:**

**NOTES:**

ISSUE DATE:  
DECEMBER 15, 2003  
CORE/SHELL  
PACKAGE #5

**REVISIONS:**

#	DATE	DESCRIPTION
Δ	1-16-04	ADDENDUM #1
Δ	1-23-04	PACKAGE 5-ADDM. 02
Δ	7-1-04	PACKAGE 7, 100% ROLL-UP


**HEIFER  
INTERNATIONAL  
CENTER  
OFFICE BUILDING**

LITTLE ROCK, ARKANSAS


PSY PROJECT NUMBER:  
431C

CONTENTS:  
THIRD FLOOR FIRE ALARM  
PLAN - EAST END  
SHEET NUMBER:

**FA103a**

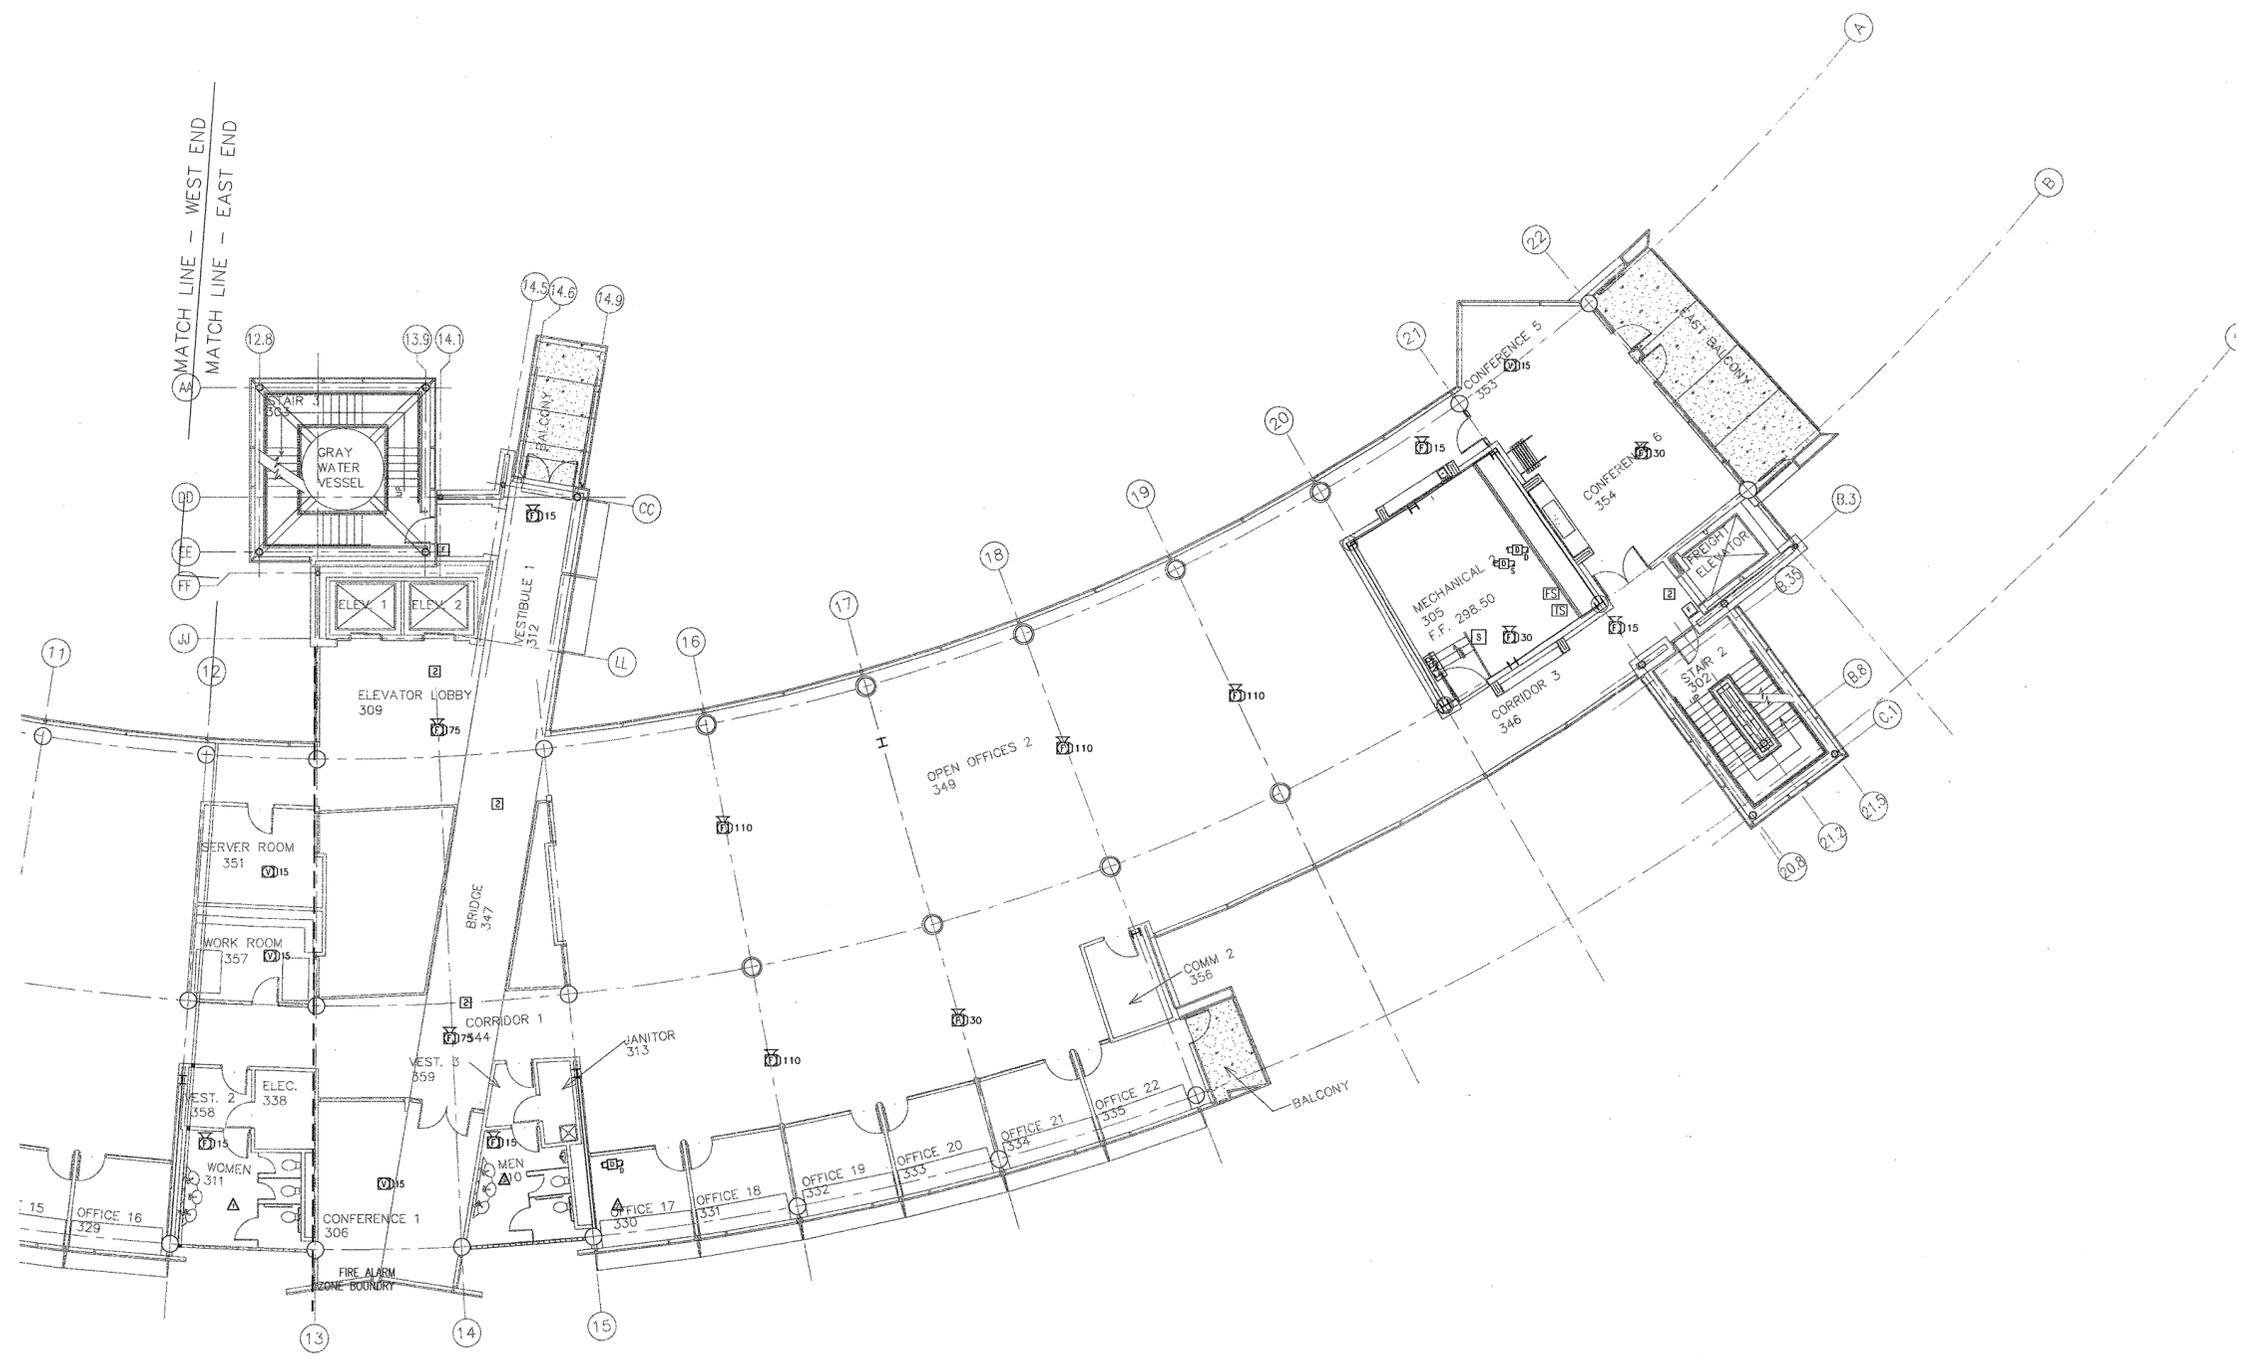

① THIRD FLOOR FIRE ALARM PLAN - EAST END  
SCALE: 1/8" = 1'-0"  
NORTH

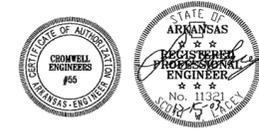

DATE PLOTTED: 12/15/03 10:58 AM