

CONSULTANTS:

OWNER'S PROJECT ADVISOR:
MOSES TUCKER REAL ESTATE, INC.

CIVIL ENGINEER:
MCCLELLAND ENGINEERS

LANDSCAPE ARCHITECT:
LARSON BURNS SMITH

STRUCTURAL ENGINEER:
CROMWELL ENGINEERS INC.

MECH., ELEC., PLUMB. ENGINEER:
CROMWELL ENGINEERS INC.

SUSTAINABLE CONSULTANT:
BNIM/ ELEMENTS

GLOBAL VILLAGE CONSULTANT
CAMBRIDGE SEVEN ASSOCIATES

INTERIOR DESIGNER:
POLK STANLEY YEARY

GENERAL CONTRACTOR:
CDI

GENERAL NOTES:

NOTES:

ISSUE DATE:
DECEMBER 15, 2003
CORE/SHELL
PACKAGE #5

REVISIONS:


#	DATE	DESCRIPTION
1	1-22-04	PACKAGE 5-ADDM. 02
2	7-1-04	PACKAGE 7, 100% ROLL-UP

**HEIFER
INTERNATIONAL
CENTER
OFFICE BUILDING**


LITTLE ROCK, ARKANSAS

PSY PROJECT NUMBER:
431C


CONTENTS:
FIRST FLOOR FIRE SPRK
PLAN - WEST END
SHEET NUMBER:
FP101b

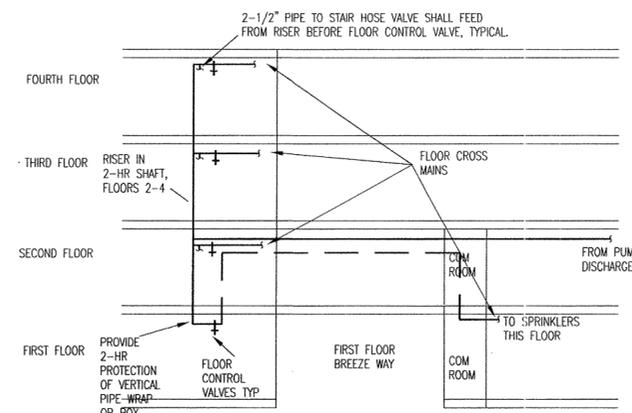

② ELEVATION VIEW - PIPE ROUTE

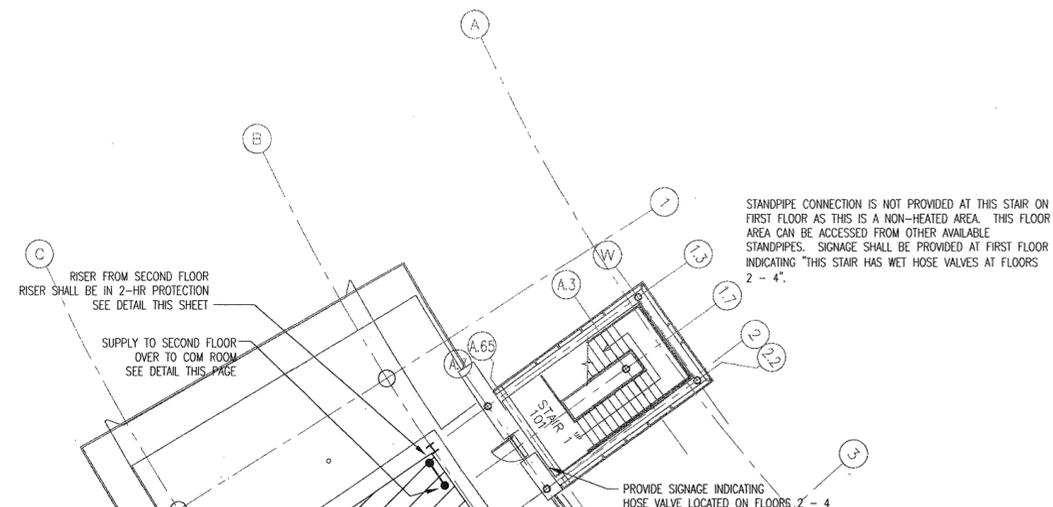

③ STAIRWAY STANDPIPE CONNECTION
SCALE: NTS

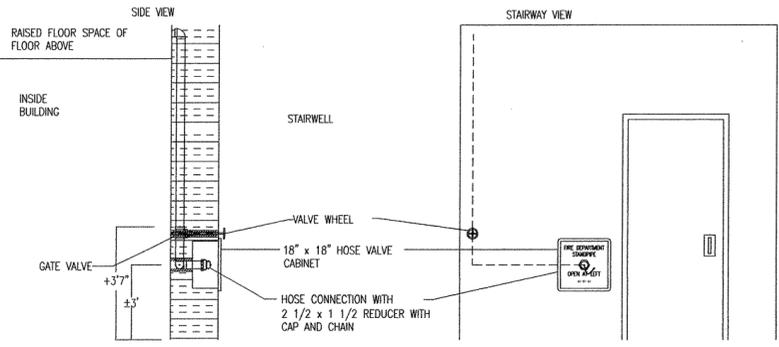

① FIRST FLOOR FIRE SPRINKLER PLAN - WEST END
SCALE: 1/8" = 1'-0"



DATE PLOTTED: 11/15/03 10:51 AM