

**CONSULTANTS:**

OWNER'S PROJECT ADVISOR:  
MOSES TUCKER REAL ESTATE, INC.

CIVIL ENGINEER:  
McCLELLAND ENGINEERS

LANDSCAPE ARCHITECT:  
LARSON BURNS SMITH

STRUCTURAL ENGINEER:  
CROMWELL ENGINEERS INC.

MECH., ELEC., PLUMB. ENGINEER:  
CROMWELL ENGINEERS INC.

SUSTAINABLE CONSULTANT:  
BNIM / ELEMENTS

GLOBAL VILLAGE CONSULTANT  
CAMBRIDGE SEVEN ASSOCIATES

INTERIOR DESIGNER:  
POLK STANLEY YEARY

GENERAL CONTRACTOR:  
CDI

**GENERAL NOTES:**

**NOTES:**

ISSUE DATE:  
DECEMBER 15, 2003  
CORE/SHELL  
PACKAGE #5

**REVISIONS:**

| # | DATE    | DESCRIPTION             |
|---|---------|-------------------------|
| 1 | 1-22-04 | PACKAGE 5-ADDM. 02      |
| 2 | 7-1-04  | PACKAGE 7, 100% ROLL-UP |


**HEIFER  
INTERNATIONAL  
CENTER  
OFFICE BUILDING**

LITTLE ROCK, ARKANSAS


PSY PROJECT NUMBER:  
431C

CONTENTS:  
THIRD FLOOR FIRE SPRK  
PLAN - EAST END

SHEET NUMBER:  
**FP103a**

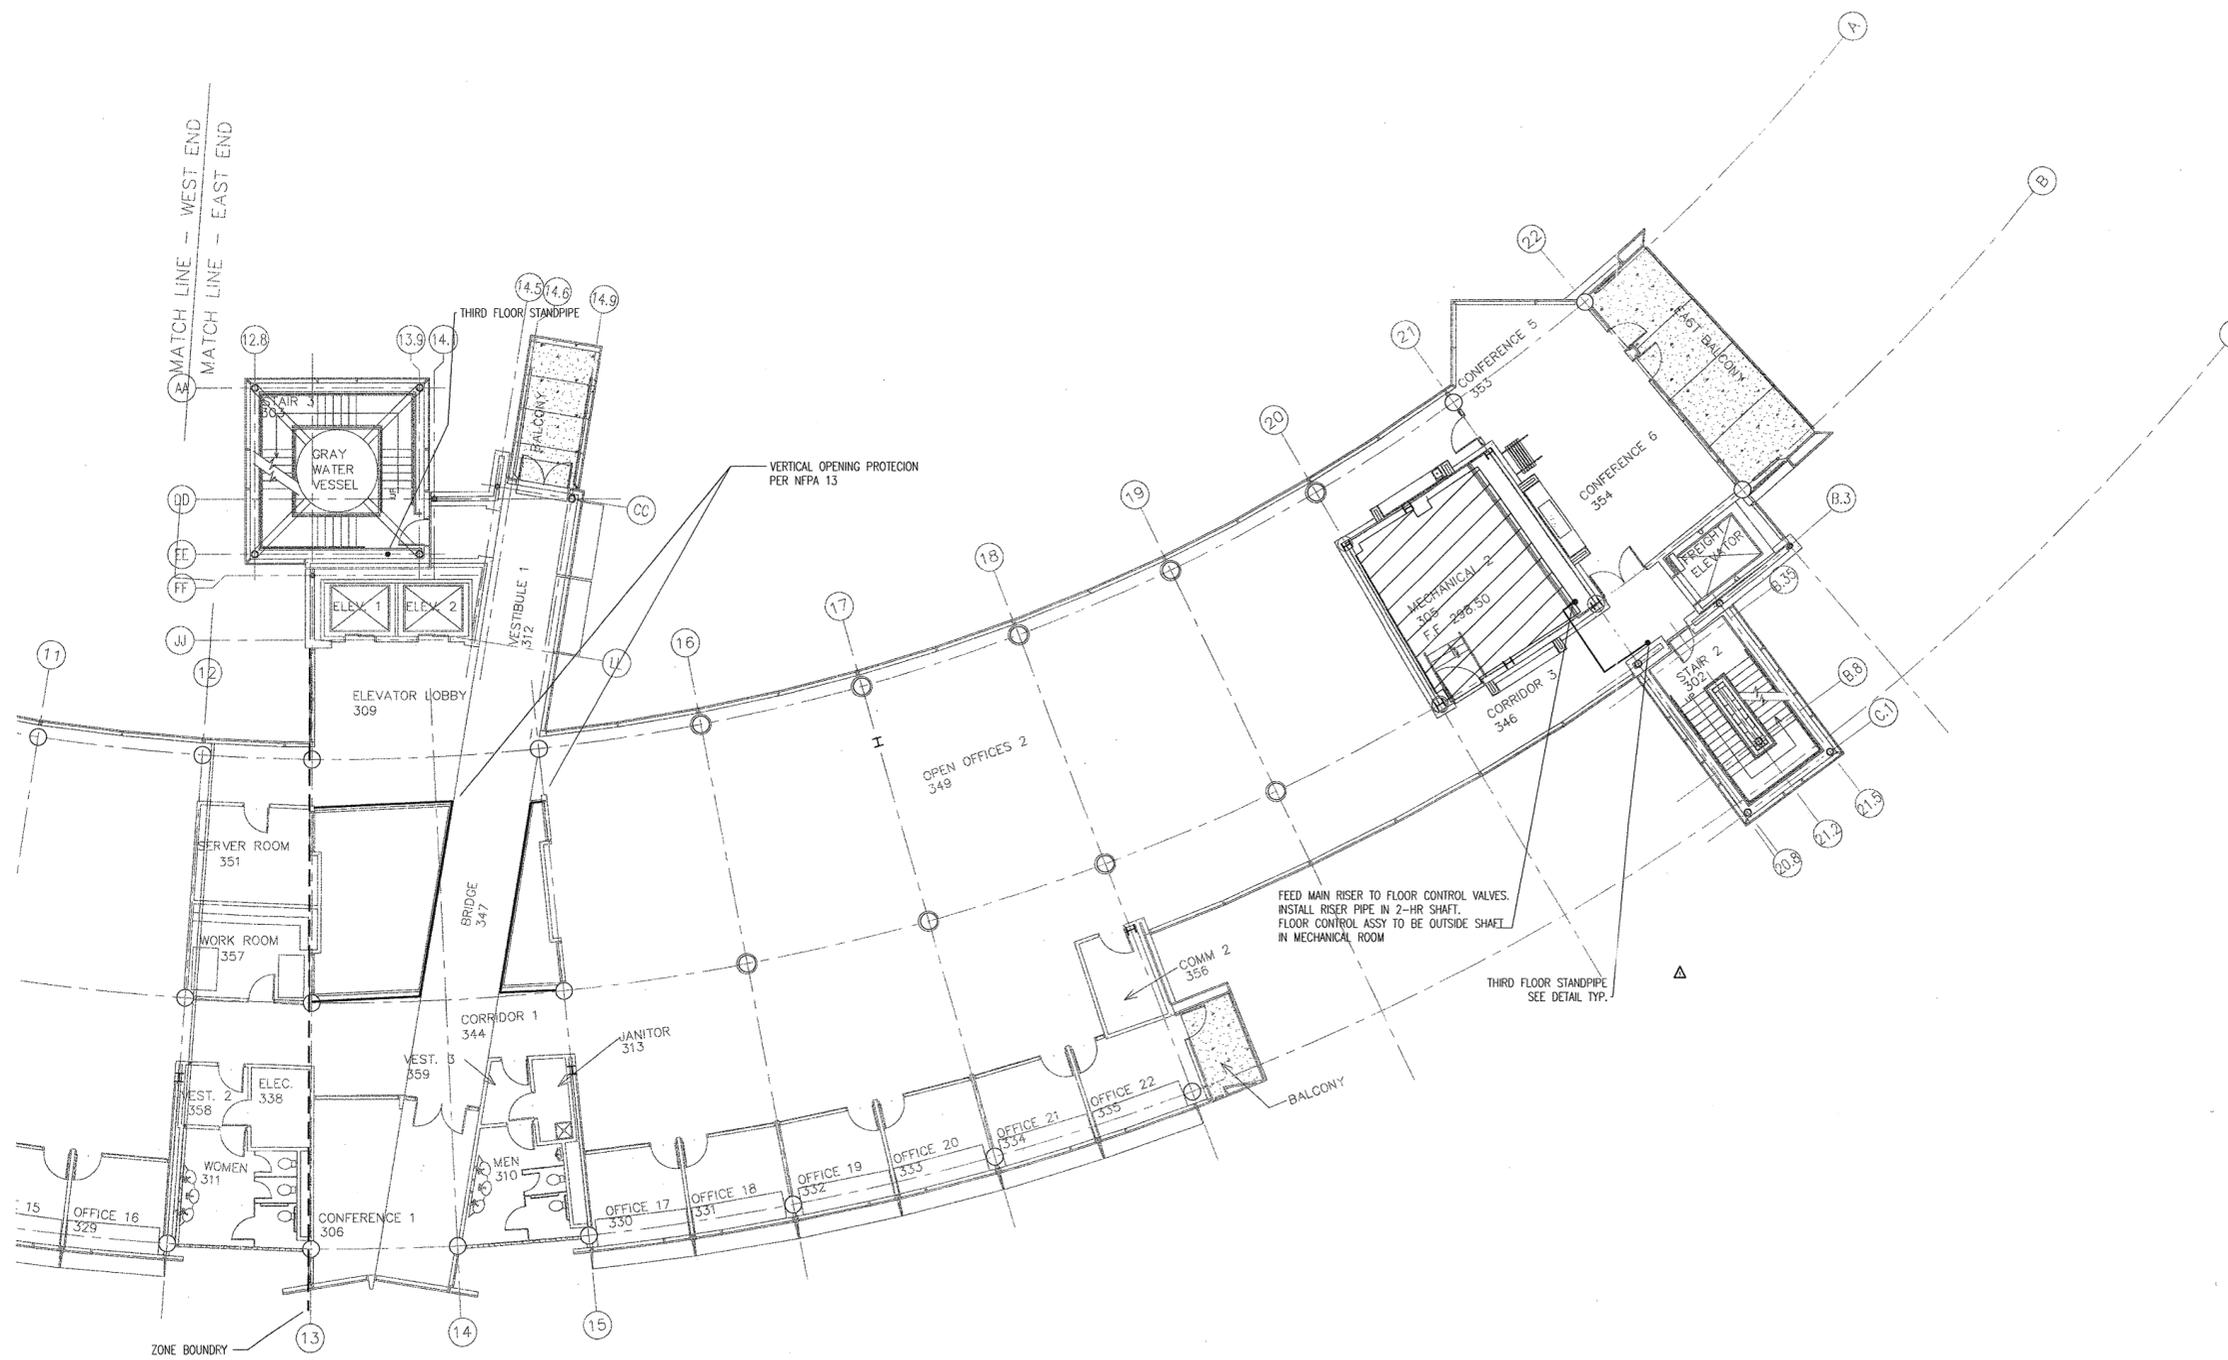

**1** THIRD FLOOR FIRE SPRINKLER PLAN - EAST END  
SCALE: 1/8" = 1'-0"

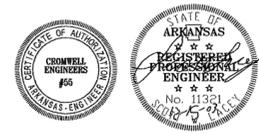

DATE PLOTTED: 12/15/03 10:00 AM