

**POLK  
STANLEY  
YEARY  
ARCHITECTS, LTD.**

700 SOUTH SCHILLER  
LITTLE ROCK, AR 72201  
501 378-0878  
FAX 372-7629

21 W. MOUNTAIN, SUITE 227  
FAYETTEVILLE, AR 72701  
479-444-0473

**CONSULTANTS:**

OWNER'S PROJECT ADVISOR:  
MOSES TUCKER REAL ESTATE, INC.

CIVIL ENGINEER:  
McCLELLAND ENGINEERS

LANDSCAPE ARCHITECT:  
LARSON BURNS SMITH

STRUCTURAL ENGINEER:  
CROMWELL ENGINEERS INC.

MECH., ELEC., PLUMB. ENGINEER:  
CROMWELL ENGINEERS INC.

SUSTAINABLE CONSULTANT:  
BNIM / ELEMENTS

GLOBAL VILLAGE CONSULTANT  
CAMBRIDGE SEVEN ASSOCIATES

INTERIOR DESIGNER:  
POLK STANLEY YEARY

GENERAL CONTRACTOR:  
CDI

**GENERAL NOTES:**

**NOTES:**

ISSUE DATE:  
DECEMBER 15, 2003  
CORE/SHELL  
PACKAGE #5

**REVISIONS:**

#	DATE	DESCRIPTION
1	1-16-04	ADDENDUM #1
2	1-23-04	PACKAGE 5-ADDM. 02
3	7-1-04	PACKAGE 7, 100% ROLL UP
4	11-29-04	ASI #27

**HEIFER  
INTERNATIONAL  
CENTER  
OFFICE BUILDING**


LITTLE ROCK, ARKANSAS

PSY PROJECT NUMBER:  
431C

CONTENTS:  
SECOND FLOOR HVAC  
PLAN - WEST END

SHEET NUMBER:

**M102b**

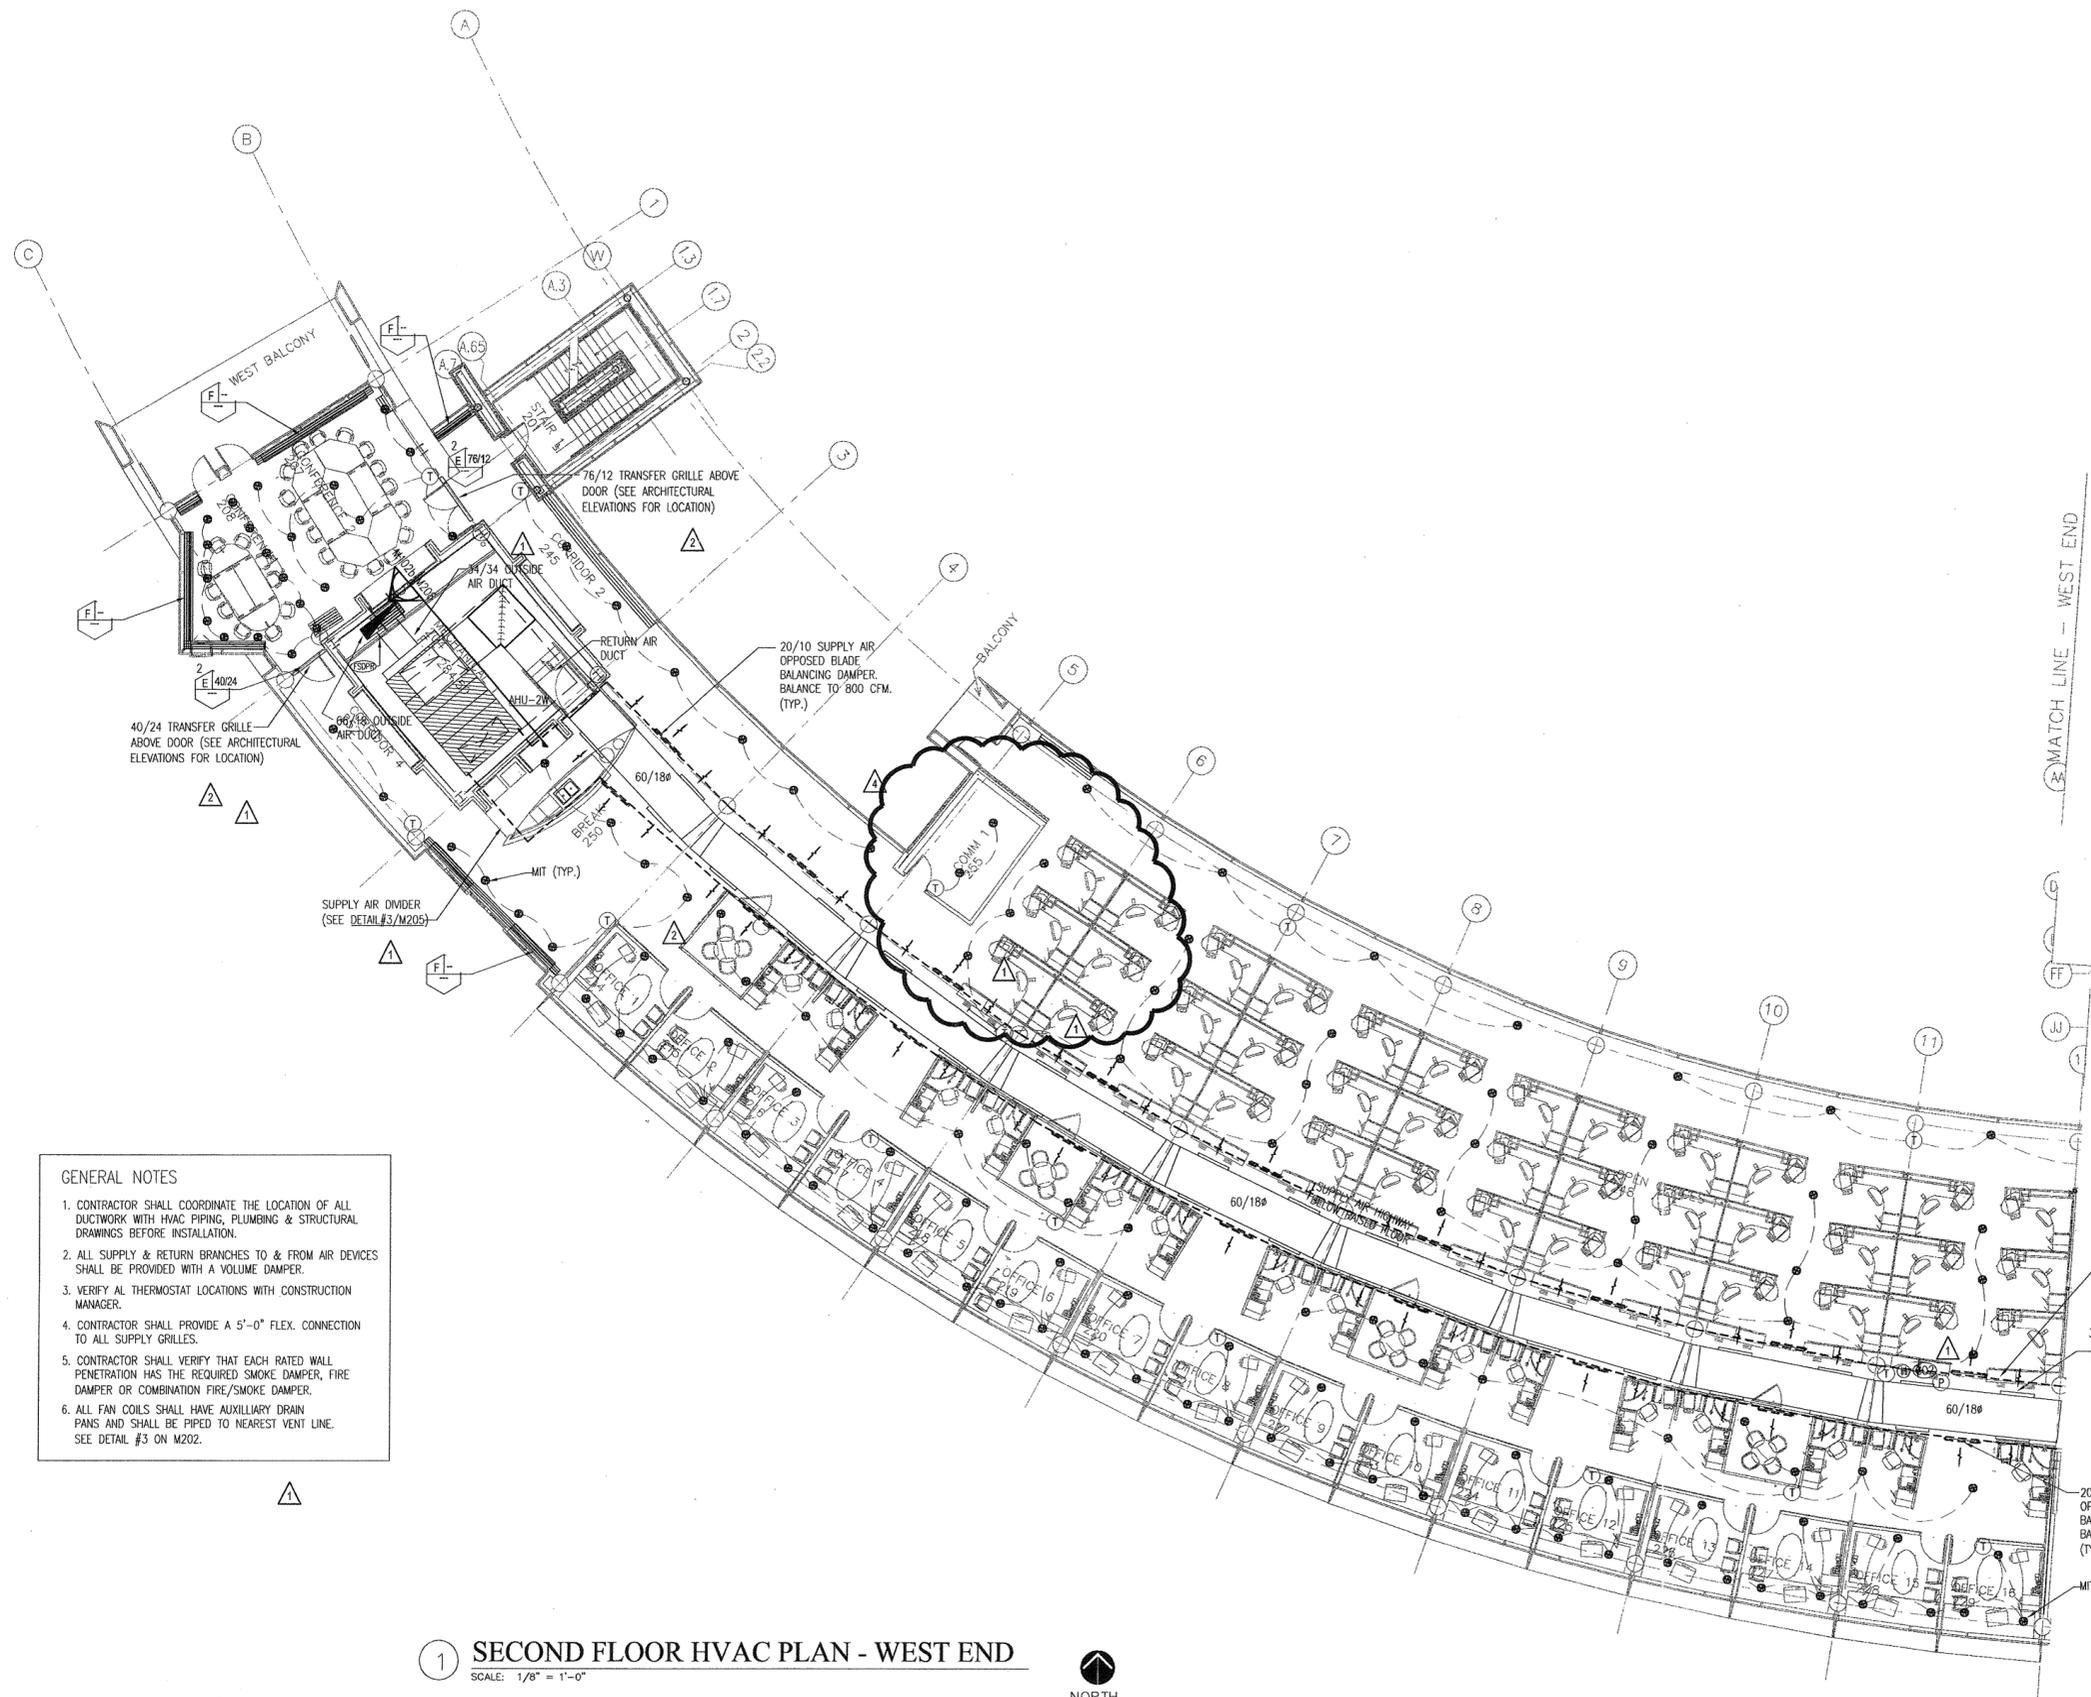

**GENERAL NOTES**

1. CONTRACTOR SHALL COORDINATE THE LOCATION OF ALL DUCTWORK WITH HVAC PIPING, PLUMBING & STRUCTURAL DRAWINGS BEFORE INSTALLATION.
2. ALL SUPPLY & RETURN BRANCHES TO & FROM AIR DEVICES SHALL BE PROVIDED WITH A VOLUME DAMPER.
3. VERIFY ALL THERMOSTAT LOCATIONS WITH CONSTRUCTION MANAGER.
4. CONTRACTOR SHALL PROVIDE A 5'-0" FLEX. CONNECTION TO ALL SUPPLY GRILLES.
5. CONTRACTOR SHALL VERIFY THAT EACH RATED WALL PENETRATION HAS THE REQUIRED SMOKE DAMPER, FIRE DAMPER OR COMBINATION FIRE/SMOKE DAMPER.
6. ALL FAN COILS SHALL HAVE AUXILIARY DRAIN PANS AND SHALL BE PIPED TO NEAREST VENT LINE. SEE DETAIL #3 ON M202.

**1 SECOND FLOOR HVAC PLAN - WEST END**  
SCALE: 1/8" = 1'-0"

