

**CONSULTANTS:**

OWNER'S PROJECT ADVISOR:  
MOSES TUCKER REAL ESTATE, INC.

CIVIL ENGINEER:  
MCLELLAND ENGINEERS

LANDSCAPE ARCHITECT:  
LARSON BURNS SMITH

STRUCTURAL ENGINEER:  
CROMWELL ENGINEERS INC.

MECH., ELEC., PLUMB. ENGINEER:  
CROMWELL ENGINEERS INC.

SUSTAINABLE CONSULTANT:  
BNIM / ELEMENTS

GLOBAL VILLAGE CONSULTANT  
CAMBRIDGE SEVEN ASSOCIATES

INTERIOR DESIGNER:  
POLK STANLEY YEARY

GENERAL CONTRACTOR:  
CDI

**GENERAL NOTES:**

NOTES:

---



---



ISSUE DATE:  
~~NOVEMBER 15, 2005~~  
NOVEMBER 15, 2005

SCHEMATIC/FOUNDATION  
PACKAGE #

REVISIONS:

#	DATE	DESCRIPTION
Δ	1-16-04	ADDENDUM #1
Δ	1-23-04	PACKAGE 5-ADDM. 02
Δ	7-1-04	PACKAGE 7, 100% ROLL UP


**HEIFER  
INTERNATIONAL  
CENTER  
OFFICE BUILDING**

LITTLE ROCK, ARKANSAS

PSY PROJECT NUMBER:  
431C

CONTENTS:  
THIRD FLOOR HVAC  
PLAN - EAST END

SHHEET NUMBER:  
**M103a**

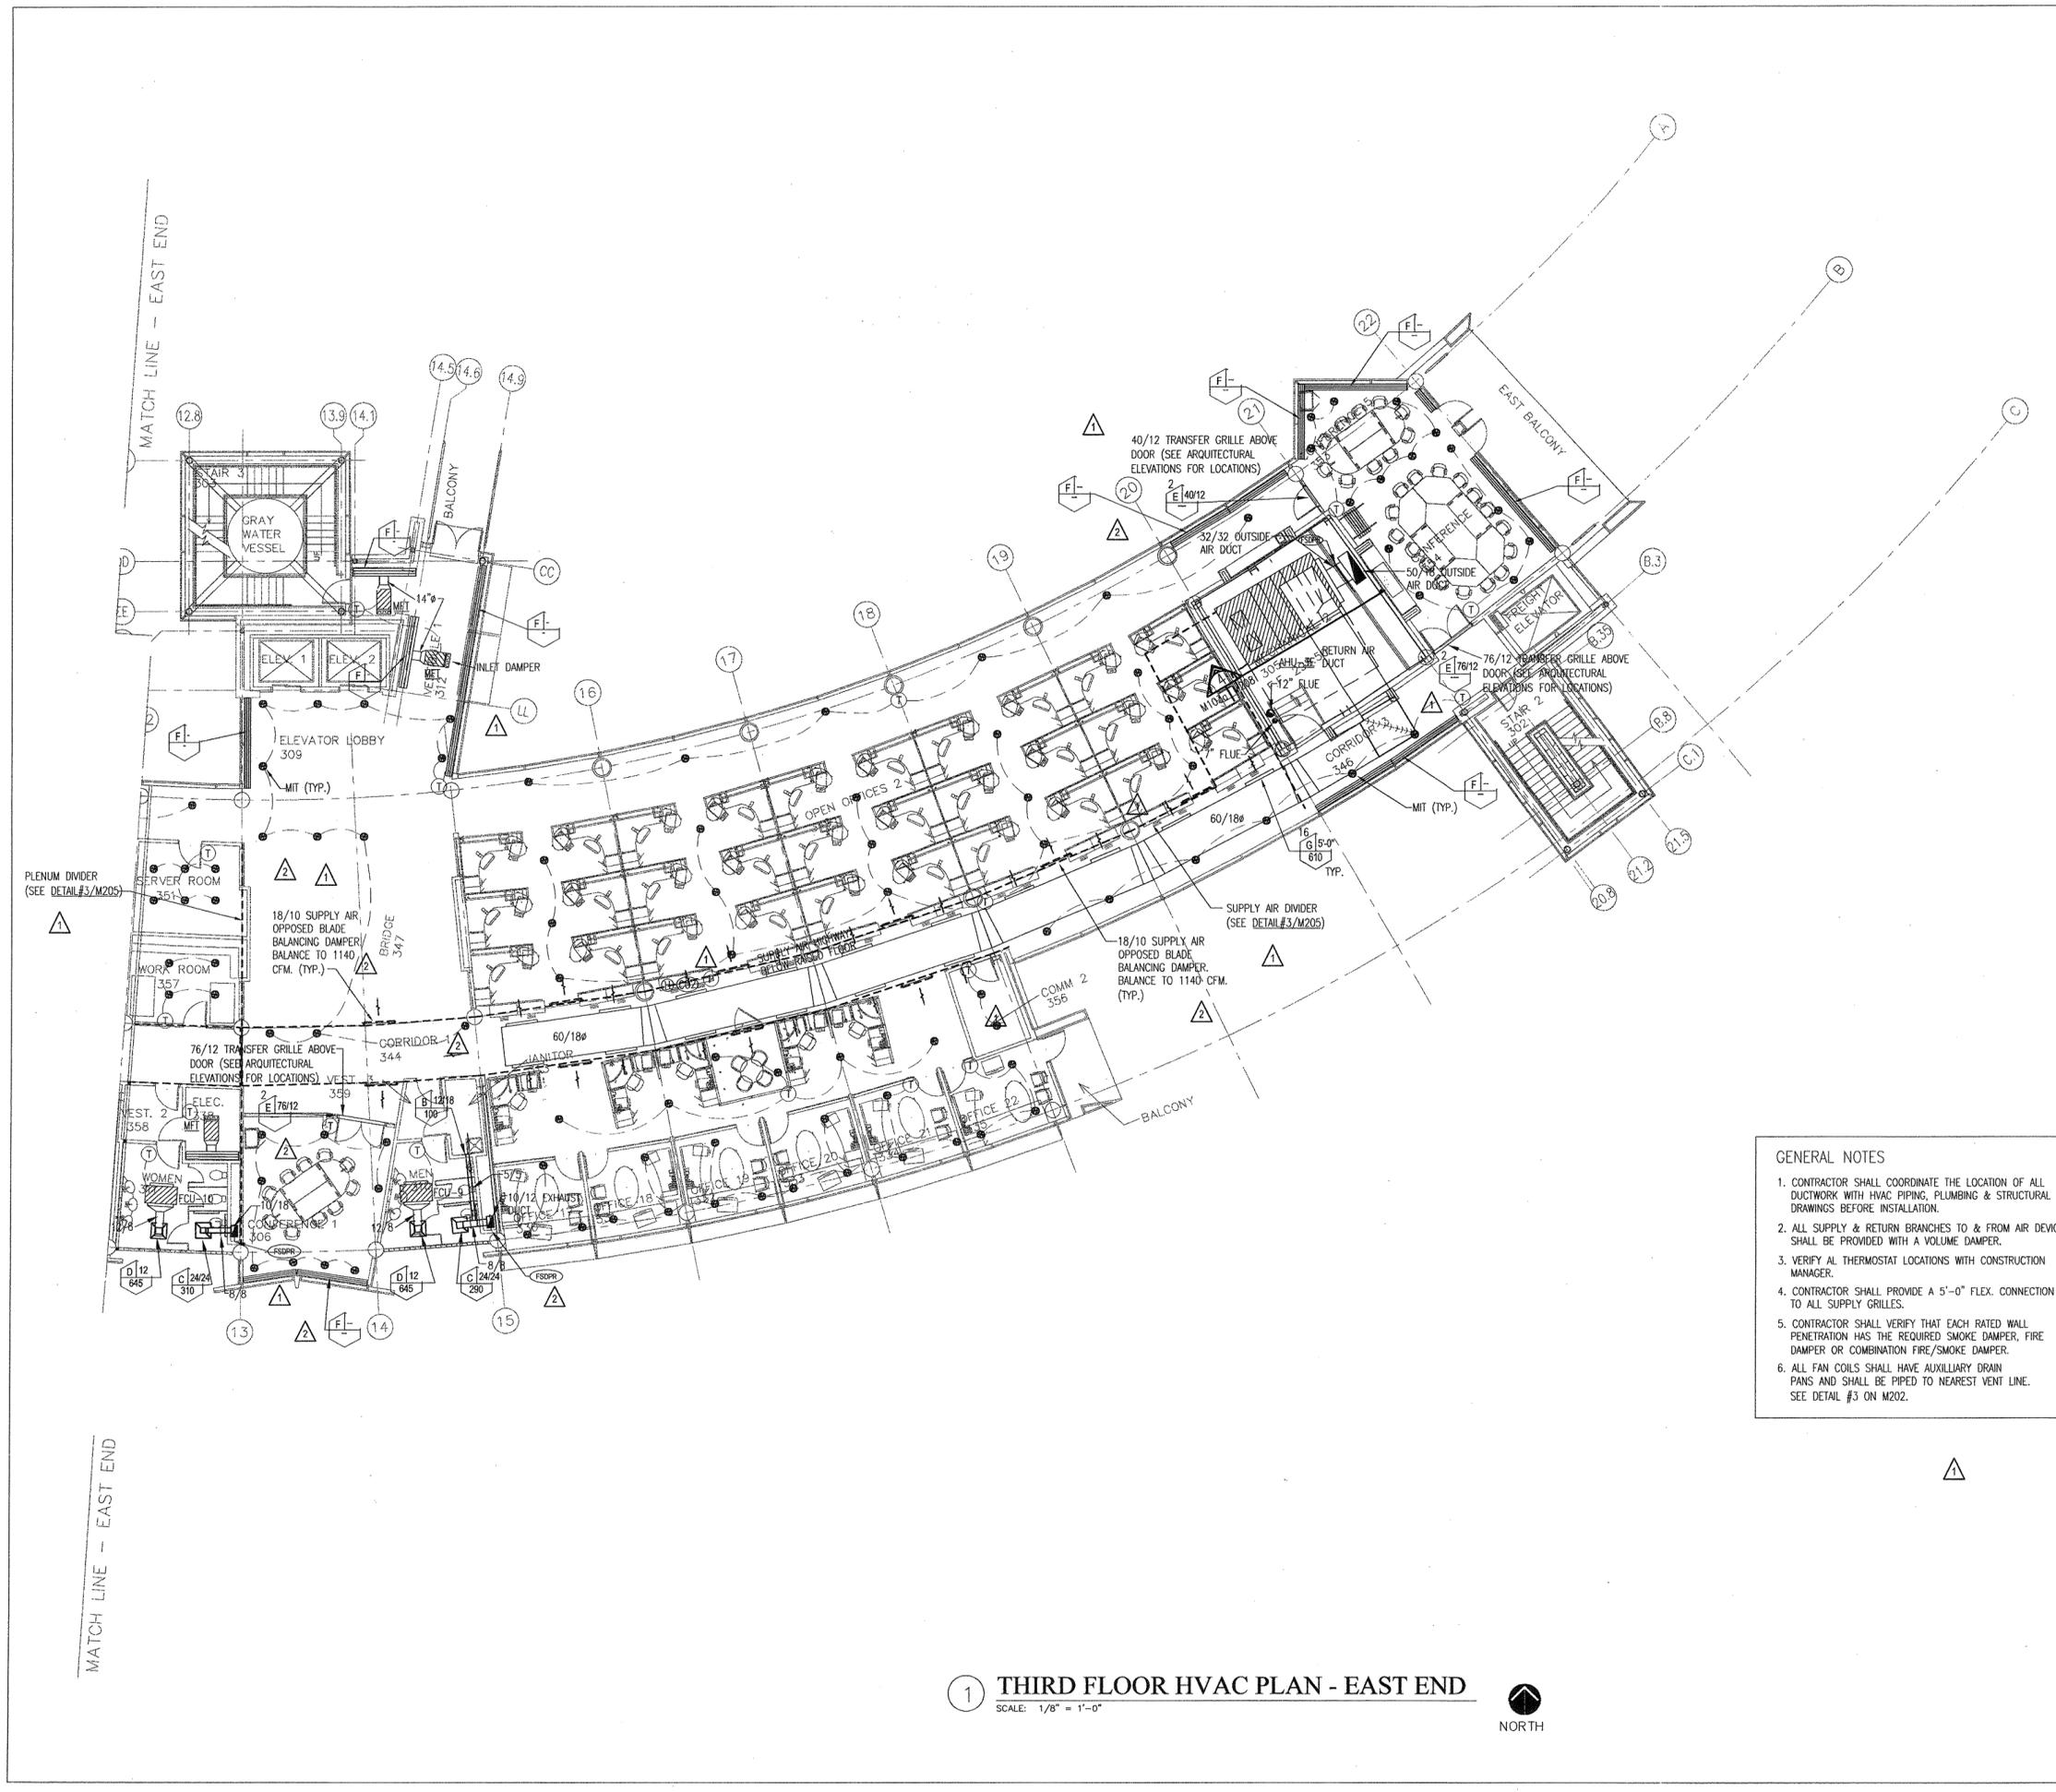

- GENERAL NOTES**
- CONTRACTOR SHALL COORDINATE THE LOCATION OF ALL DUCTWORK WITH HVAC PIPING, PLUMBING & STRUCTURAL DRAWINGS BEFORE INSTALLATION.
  - ALL SUPPLY & RETURN BRANCHES TO & FROM AIR DEVICES SHALL BE PROVIDED WITH A VOLUME DAMPER.
  - VERIFY ALL THERMOSTAT LOCATIONS WITH CONSTRUCTION MANAGER.
  - CONTRACTOR SHALL PROVIDE A 5'-0" FLEX. CONNECTION TO ALL SUPPLY GRILLES.
  - CONTRACTOR SHALL VERIFY THAT EACH RATED WALL PENETRATION HAS THE REQUIRED SMOKE DAMPER, FIRE DAMPER OR COMBINATION FIRE/SMOKE DAMPER.
  - ALL FAN COILS SHALL HAVE AUXILIARY DRAIN PANS AND SHALL BE PIPED TO NEAREST VENT LINE. SEE DETAIL #3 ON M202.

**1 THIRD FLOOR HVAC PLAN - EAST END**  
SCALE: 1/8" = 1'-0"

