

CONSULTANTS:

OWNER'S PROJECT ADVISOR:
MOSES TUCKER REAL ESTATE, INC.

CIVIL ENGINEER:
MCCLERLAND ENGINEERS

LANDSCAPE ARCHITECT:
LARSON BURNS SMITH

STRUCTURAL ENGINEER:
CROMWELL ENGINEERS INC.

MECH., ELEC., PLUMB. ENGINEER:
CROMWELL ENGINEERS INC.

SUSTAINABLE CONSULTANT:
BNIM / ELEMENTS

GLOBAL VILLAGE CONSULTANT
CAMBRIDGE SEVEN ASSOCIATES

INTERIOR DESIGNER:
POLK STANLEY YEARY

GENERAL CONTRACTOR:
CDI

GENERAL NOTES:

NOTES:

ISSUE DATE:
DECEMBER 15, 2003
CORE/SHELL
PACKAGE #5

REVISIONS:

#	DATE	DESCRIPTION
1	1-16-04	ADDENDUM #1
2	1-23-04	PACKAGE 5-ADDM. 02
3	7-1-04	PACKAGE 7, 100% ROLL UP
4	11-29-04	ASI #27

**HEIFER
INTERNATIONAL
CENTER
OFFICE BUILDING**


LITTLE ROCK, ARKANSAS

PSY PROJECT NUMBER:
431C

CONTENTS:
THIRD FLOOR HVAC
PLAN - WEST END

SHEET NUMBER:

M103b

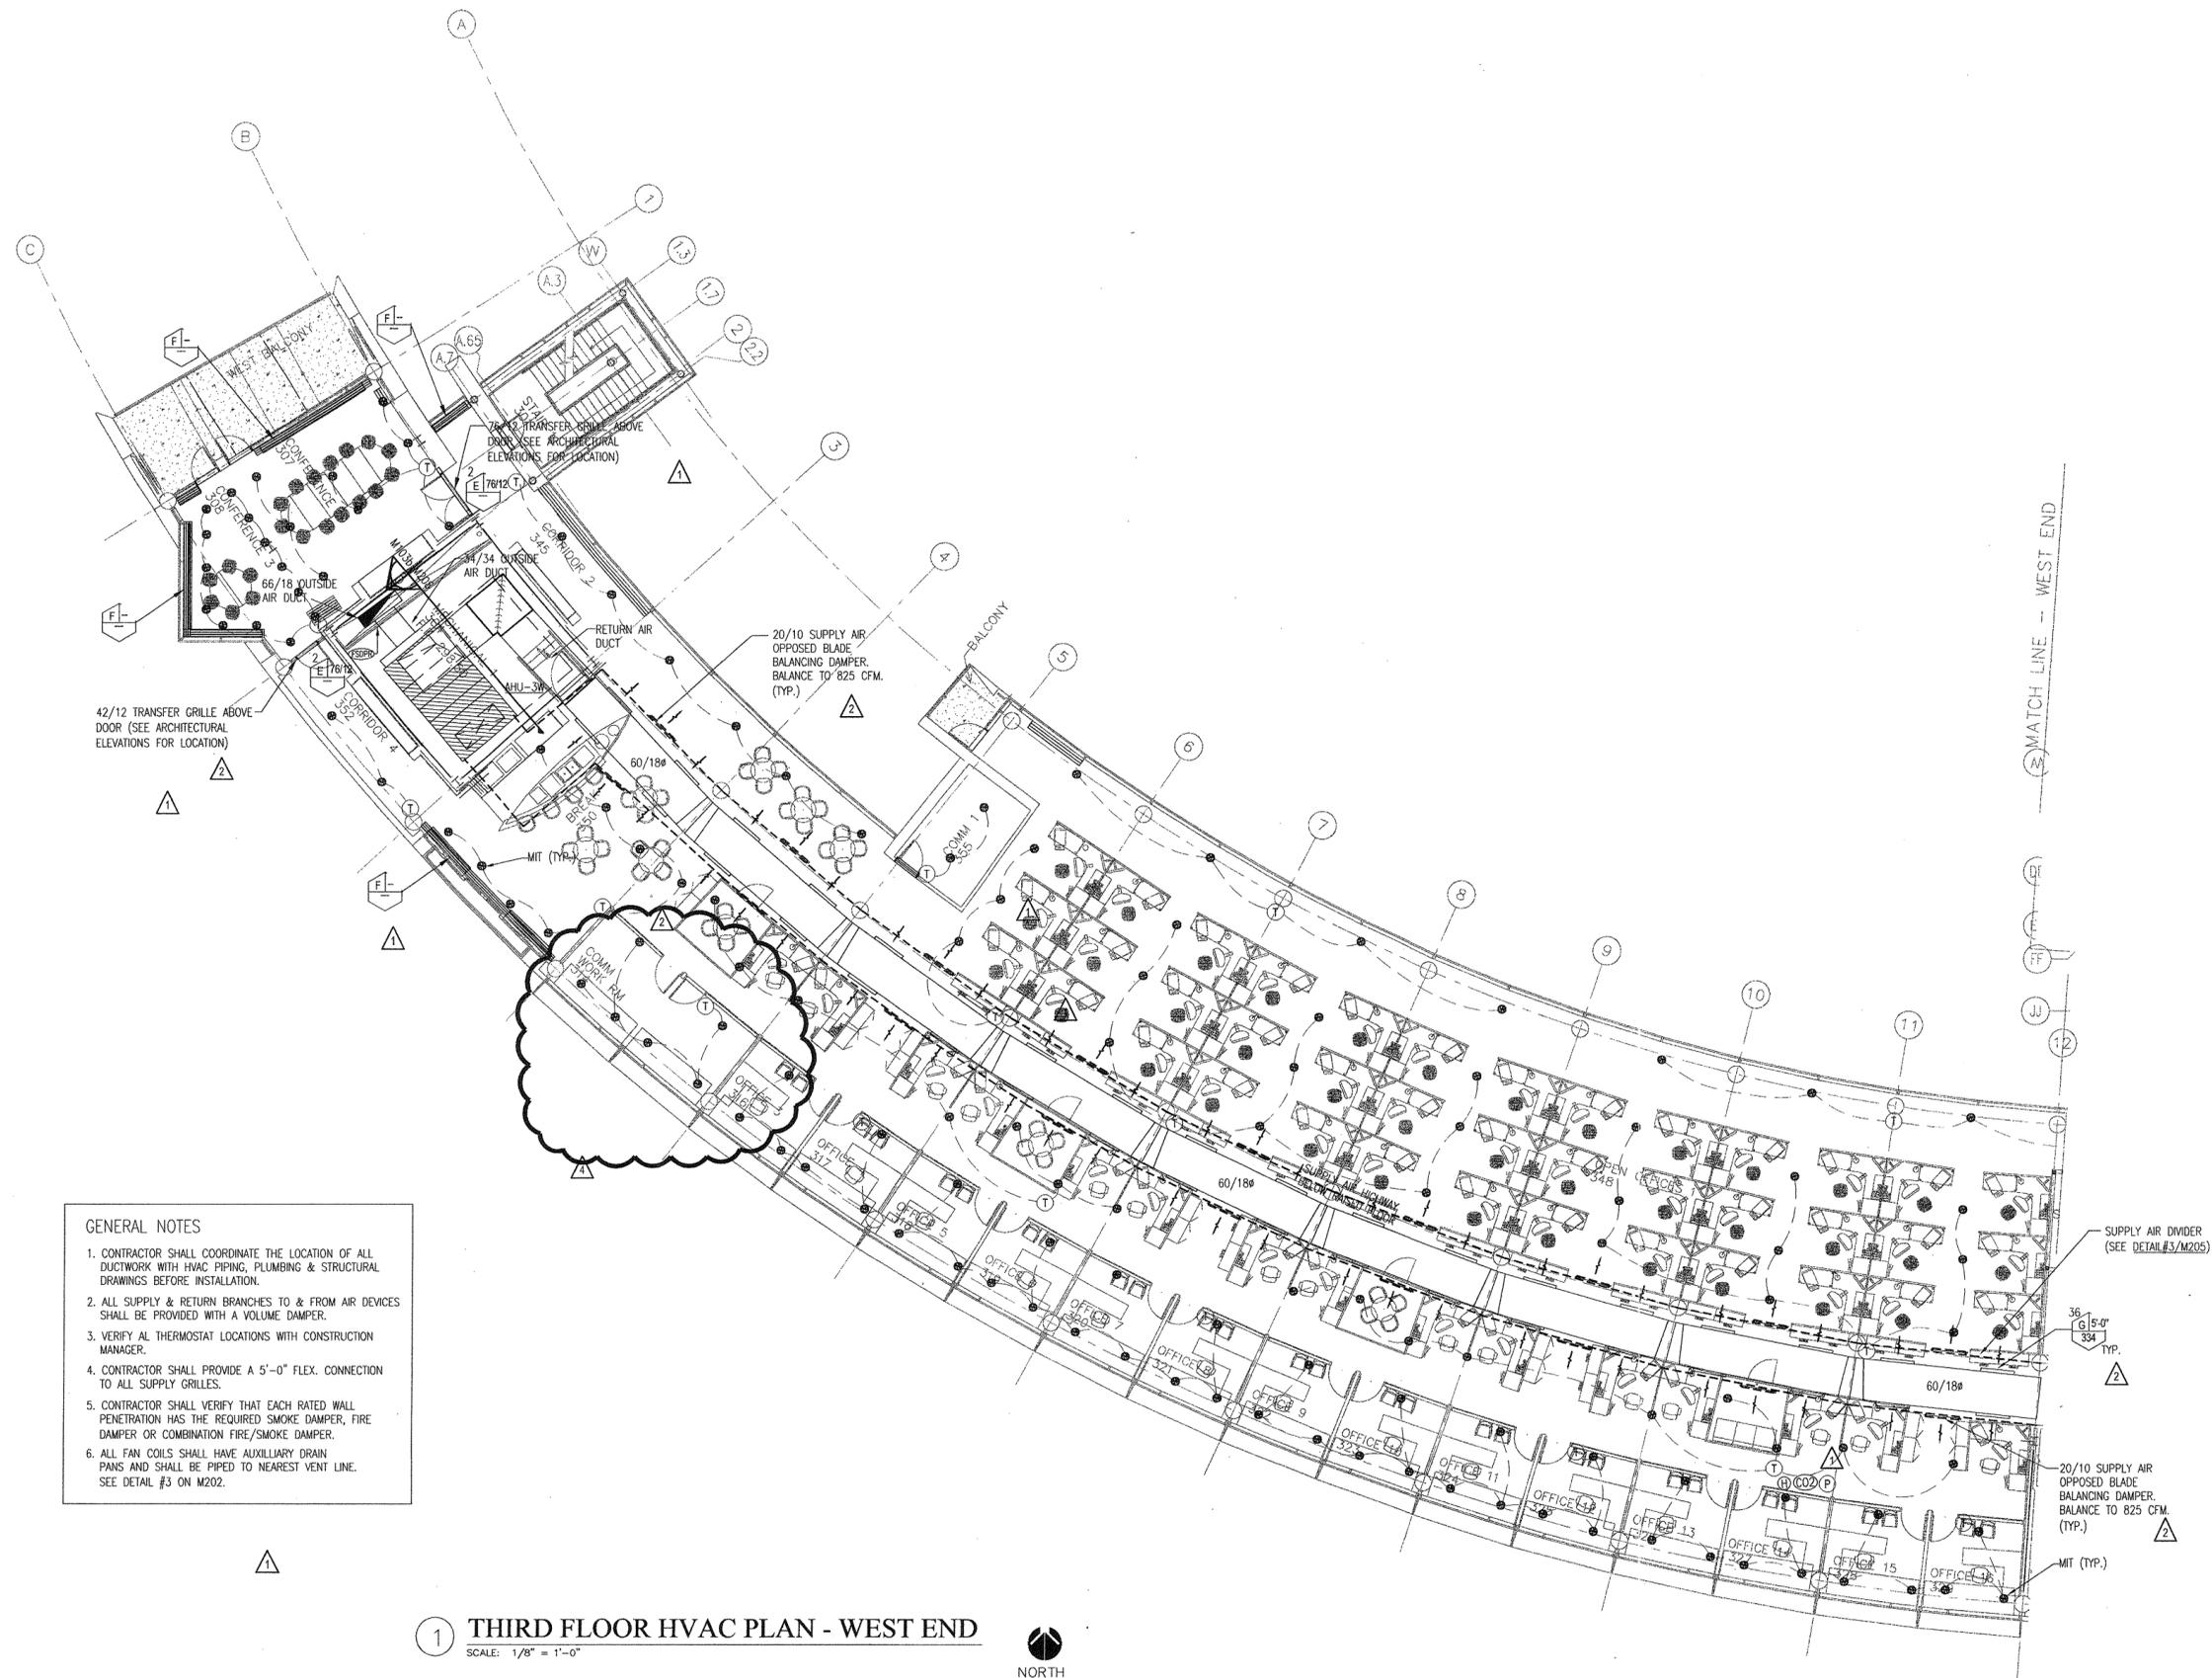

GENERAL NOTES

1. CONTRACTOR SHALL COORDINATE THE LOCATION OF ALL DUCTWORK WITH HVAC PIPING, PLUMBING & STRUCTURAL DRAWINGS BEFORE INSTALLATION.
2. ALL SUPPLY & RETURN BRANCHES TO & FROM AIR DEVICES SHALL BE PROVIDED WITH A VOLUME DAMPER.
3. VERIFY ALL THERMOSTAT LOCATIONS WITH CONSTRUCTION MANAGER.
4. CONTRACTOR SHALL PROVIDE A 5'-0" FLEX. CONNECTION TO ALL SUPPLY GRILLES.
5. CONTRACTOR SHALL VERIFY THAT EACH RATED WALL PENETRATION HAS THE REQUIRED SMOKE DAMPER, FIRE DAMPER OR COMBINATION FIRE/SMOKE DAMPER.
6. ALL FAN COILS SHALL HAVE AUXILIARY DRAIN PANS AND SHALL BE PIPED TO NEAREST VENT LINE. SEE DETAIL #3 ON M202.

1 THIRD FLOOR HVAC PLAN - WEST END
SCALE: 1/8" = 1'-0"

