

**POLK
STANLEY
YEARY
ARCHITECTS, LTD.**

700 SOUTH SCHILLER
LITTLE ROCK, AR 72201
501 378-0878
FAX 372-7629

21 W. MOUNTAIN, SUITE 227
FAYETTEVILLE, AR 72701
479-444-0473

CONSULTANTS:

OWNER'S PROJECT ADVISOR:
MOSES TUCKER REAL ESTATE, INC.

CIVIL ENGINEER:
McCLELLAND ENGINEERS

LANDSCAPE ARCHITECT:
LARSON BURNS SMITH

STRUCTURAL ENGINEER:
CROMWELL ENGINEERS INC.

MECH., ELEC., PLUMB. ENGINEER:
CROMWELL ENGINEERS INC.

SUSTAINABLE CONSULTANT:
BNIM / ELEMENTS

GLOBAL VILLAGE CONSULTANT
CAMBRIDGE SEVEN ASSOCIATES

INTERIOR DESIGNER:
POLK STANLEY YEARY

GENERAL CONTRACTOR:
CDI

GENERAL NOTES:

NOTES:

ISSUE DATE:
DECEMBER 15, 2003
CORE/SHELL
PACKAGE #5
REVISIONS:

#	DATE	DESCRIPTION
1	1-16-04	ADDENDUM #1
2	1-23-04	PACKAGE 5-ADDUM. 02
3	7-1-04	PACKAGE 7, 100% ROLL UP
4	11-29-04	ASI #27

**HEIFER
INTERNATIONAL
CENTER
OFFICE BUILDING**


LITTLE ROCK, ARKANSAS

PSY PROJECT NUMBER:
431C

CONTENTS:
FIRST FLOOR HVAC PIPING
PLAN - WEST END

SHEET NUMBER:

M105b

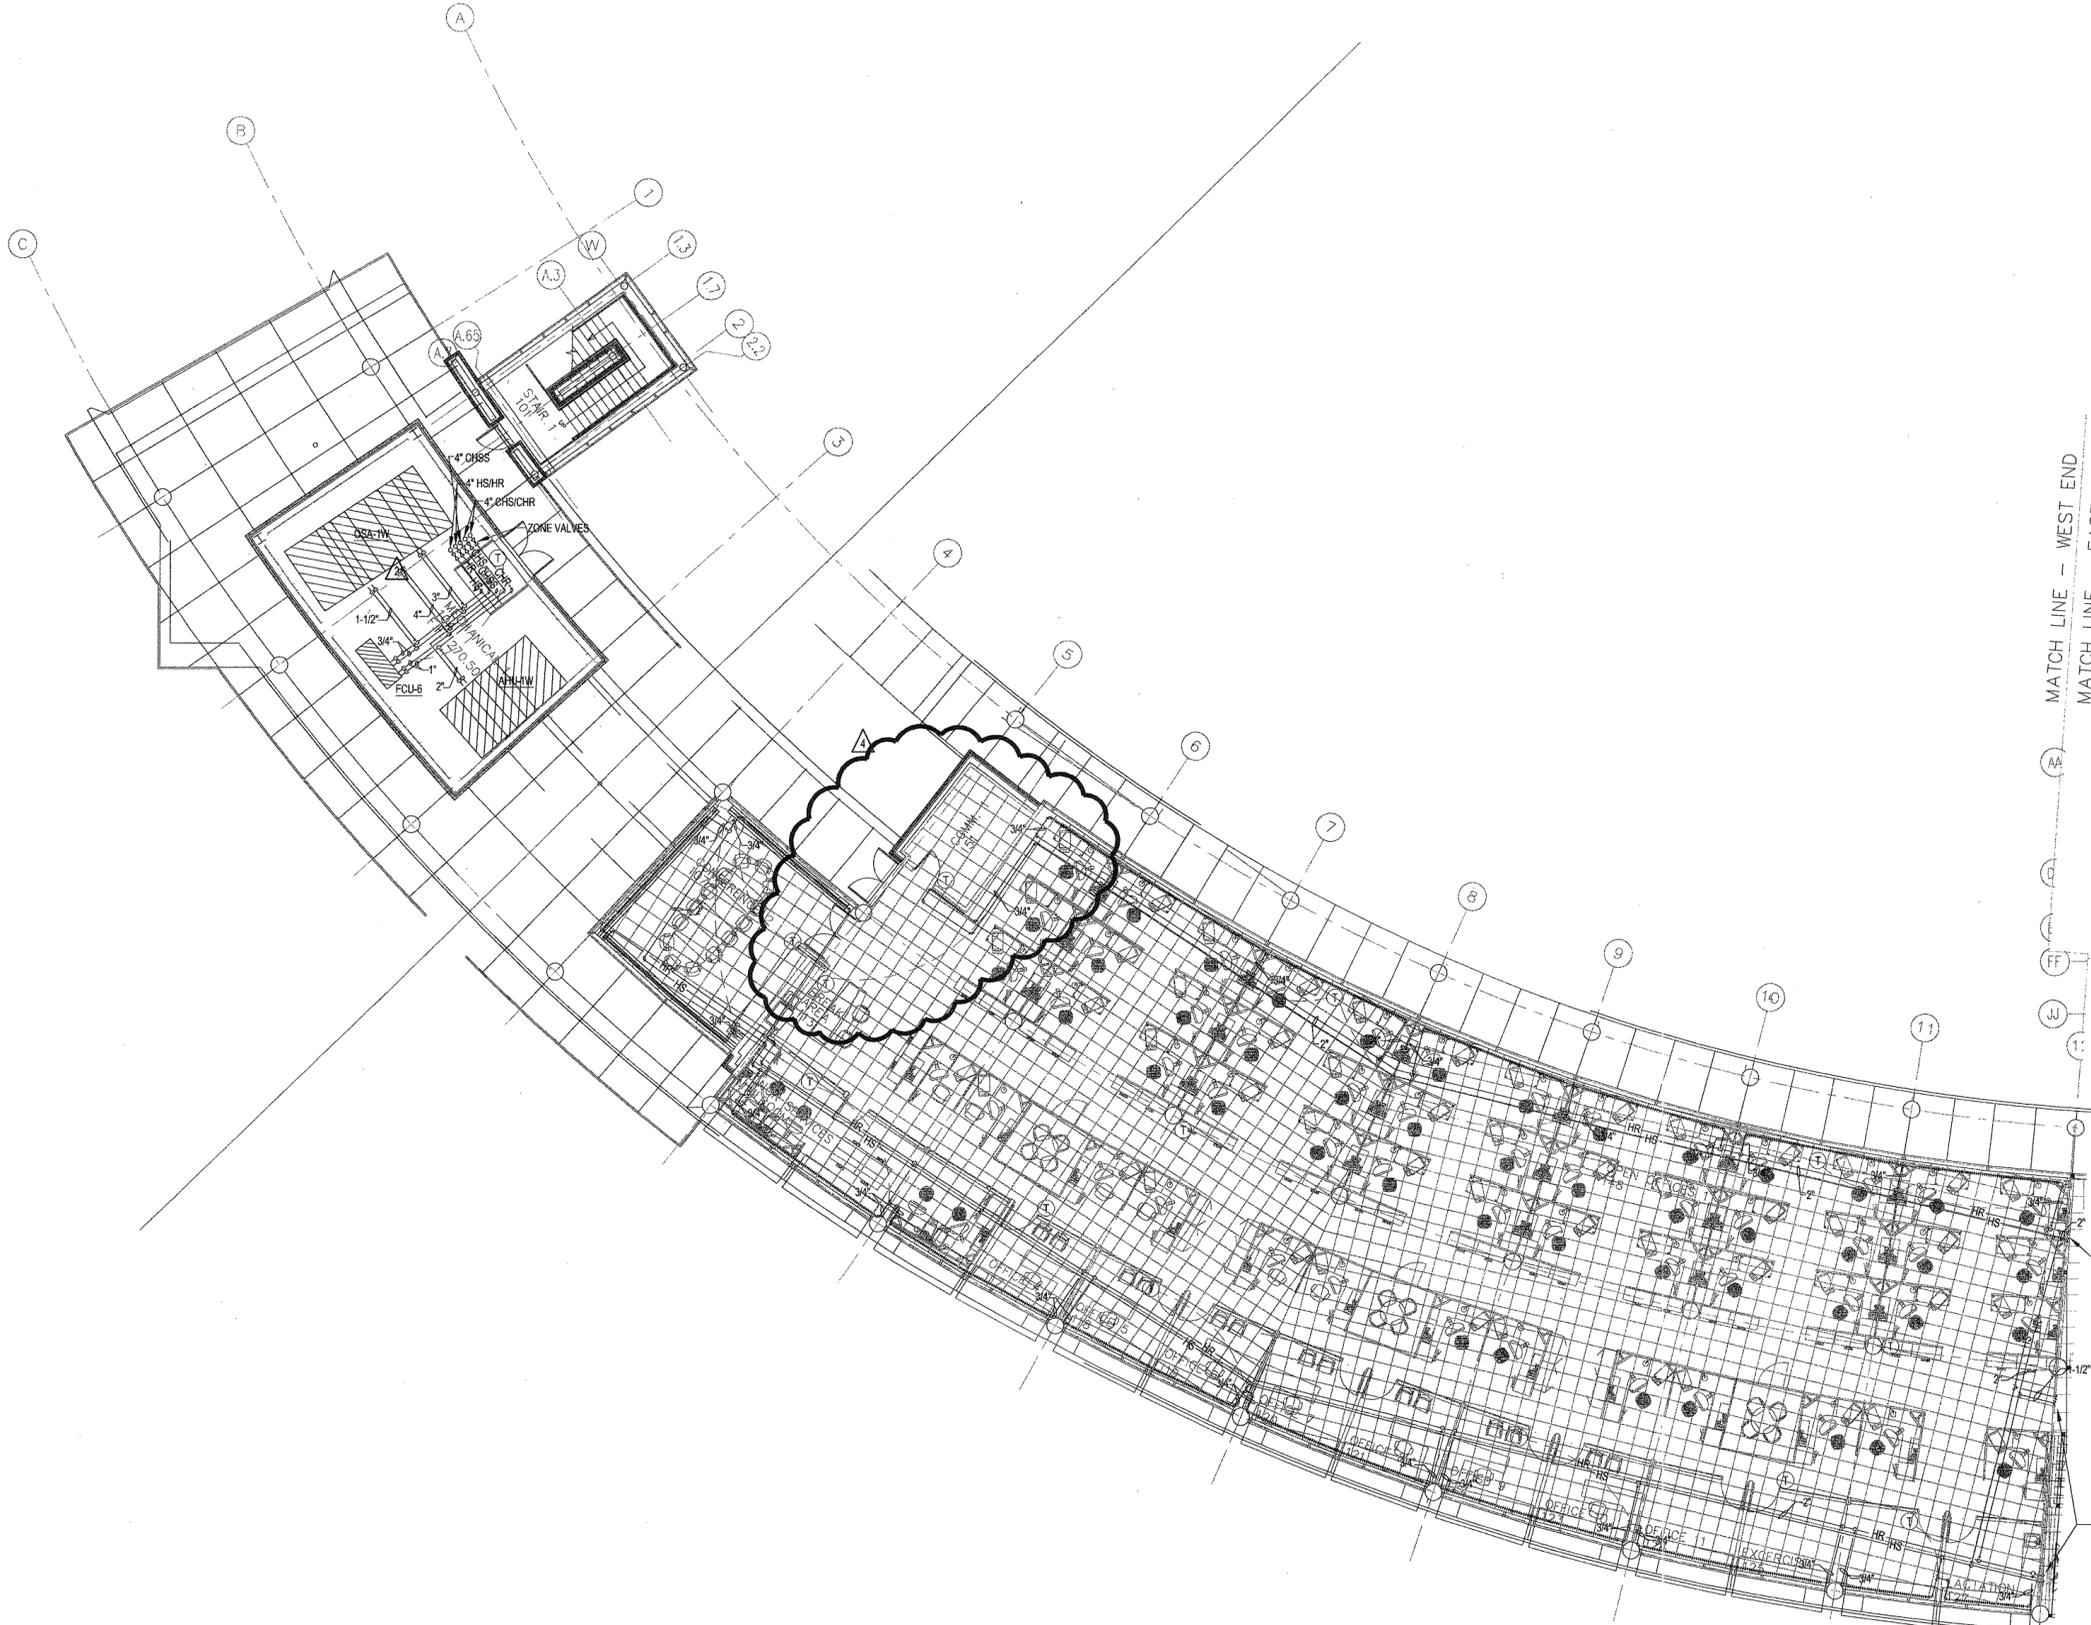

1 FIRST FLOOR HVAC PIPING PLAN - WEST END
SCALE: 1/8" = 1'-0"



MATCH LINE - WEST END
MATCH LINE - EAST END

WEST END
EAST END



REGISTERED PROFESSIONAL ENGINEER
TODD A. KUAN
NO. 9408
STATE OF ARKANSAS