

**POLK  
STANLEY  
YEARY  
ARCHITECTS, LTD.**

700 SOUTH SCHILLER  
LITTLE ROCK, AR 72201  
501.378.4678  
FAX 372-7629

21 W. MOUNTAIN, SUITE 227  
FAYETTEVILLE, AR 72701  
479-444-0473

**CONSULTANTS:**

OWNER'S PROJECT ADVISOR:  
MOSES TUCKER REAL ESTATE, INC.

CIVIL ENGINEER:  
McCLELLAND ENGINEERS

LANDSCAPE ARCHITECT:  
LARSON BURNS SMITH

STRUCTURAL ENGINEER:  
CROMWELL ENGINEERS INC.

MECH., ELEC., PLUMB. ENGINEER:  
CROMWELL ENGINEERS INC.

SUSTAINABLE CONSULTANT:  
BNIM / ELEMENTS

GLOBAL VILLAGE CONSULTANT  
CAMBRIDGE SEVEN ASSOCIATES

INTERIOR DESIGNER:  
POLK STANLEY YEARY

GENERAL CONTRACTOR:  
CDI

**GENERAL NOTES:**

**NOTES:**

ISSUE DATE:  
DECEMBER 15, 2003  
CORE/SHELL  
PACKAGE #5  
REVISIONS:

#	DATE	DESCRIPTION
▲	1-16-04	ADDENDUM #1
▲	1-23-04	PACKAGE 5-ADDM. 02
▲	7-1-04	PACKAGE 7, 100% ROLL UP
▲	11-29-04	ASI #27


**HEIFER  
INTERNATIONAL  
CENTER  
OFFICE BUILDING**  
LITTLE ROCK, ARKANSAS

PSY PROJECT NUMBER:  
431C

CONTENTS:  
SECOND FLOOR HVAC  
PIPING PLAN - EAST END

SHEET NUMBER:

**M106a**

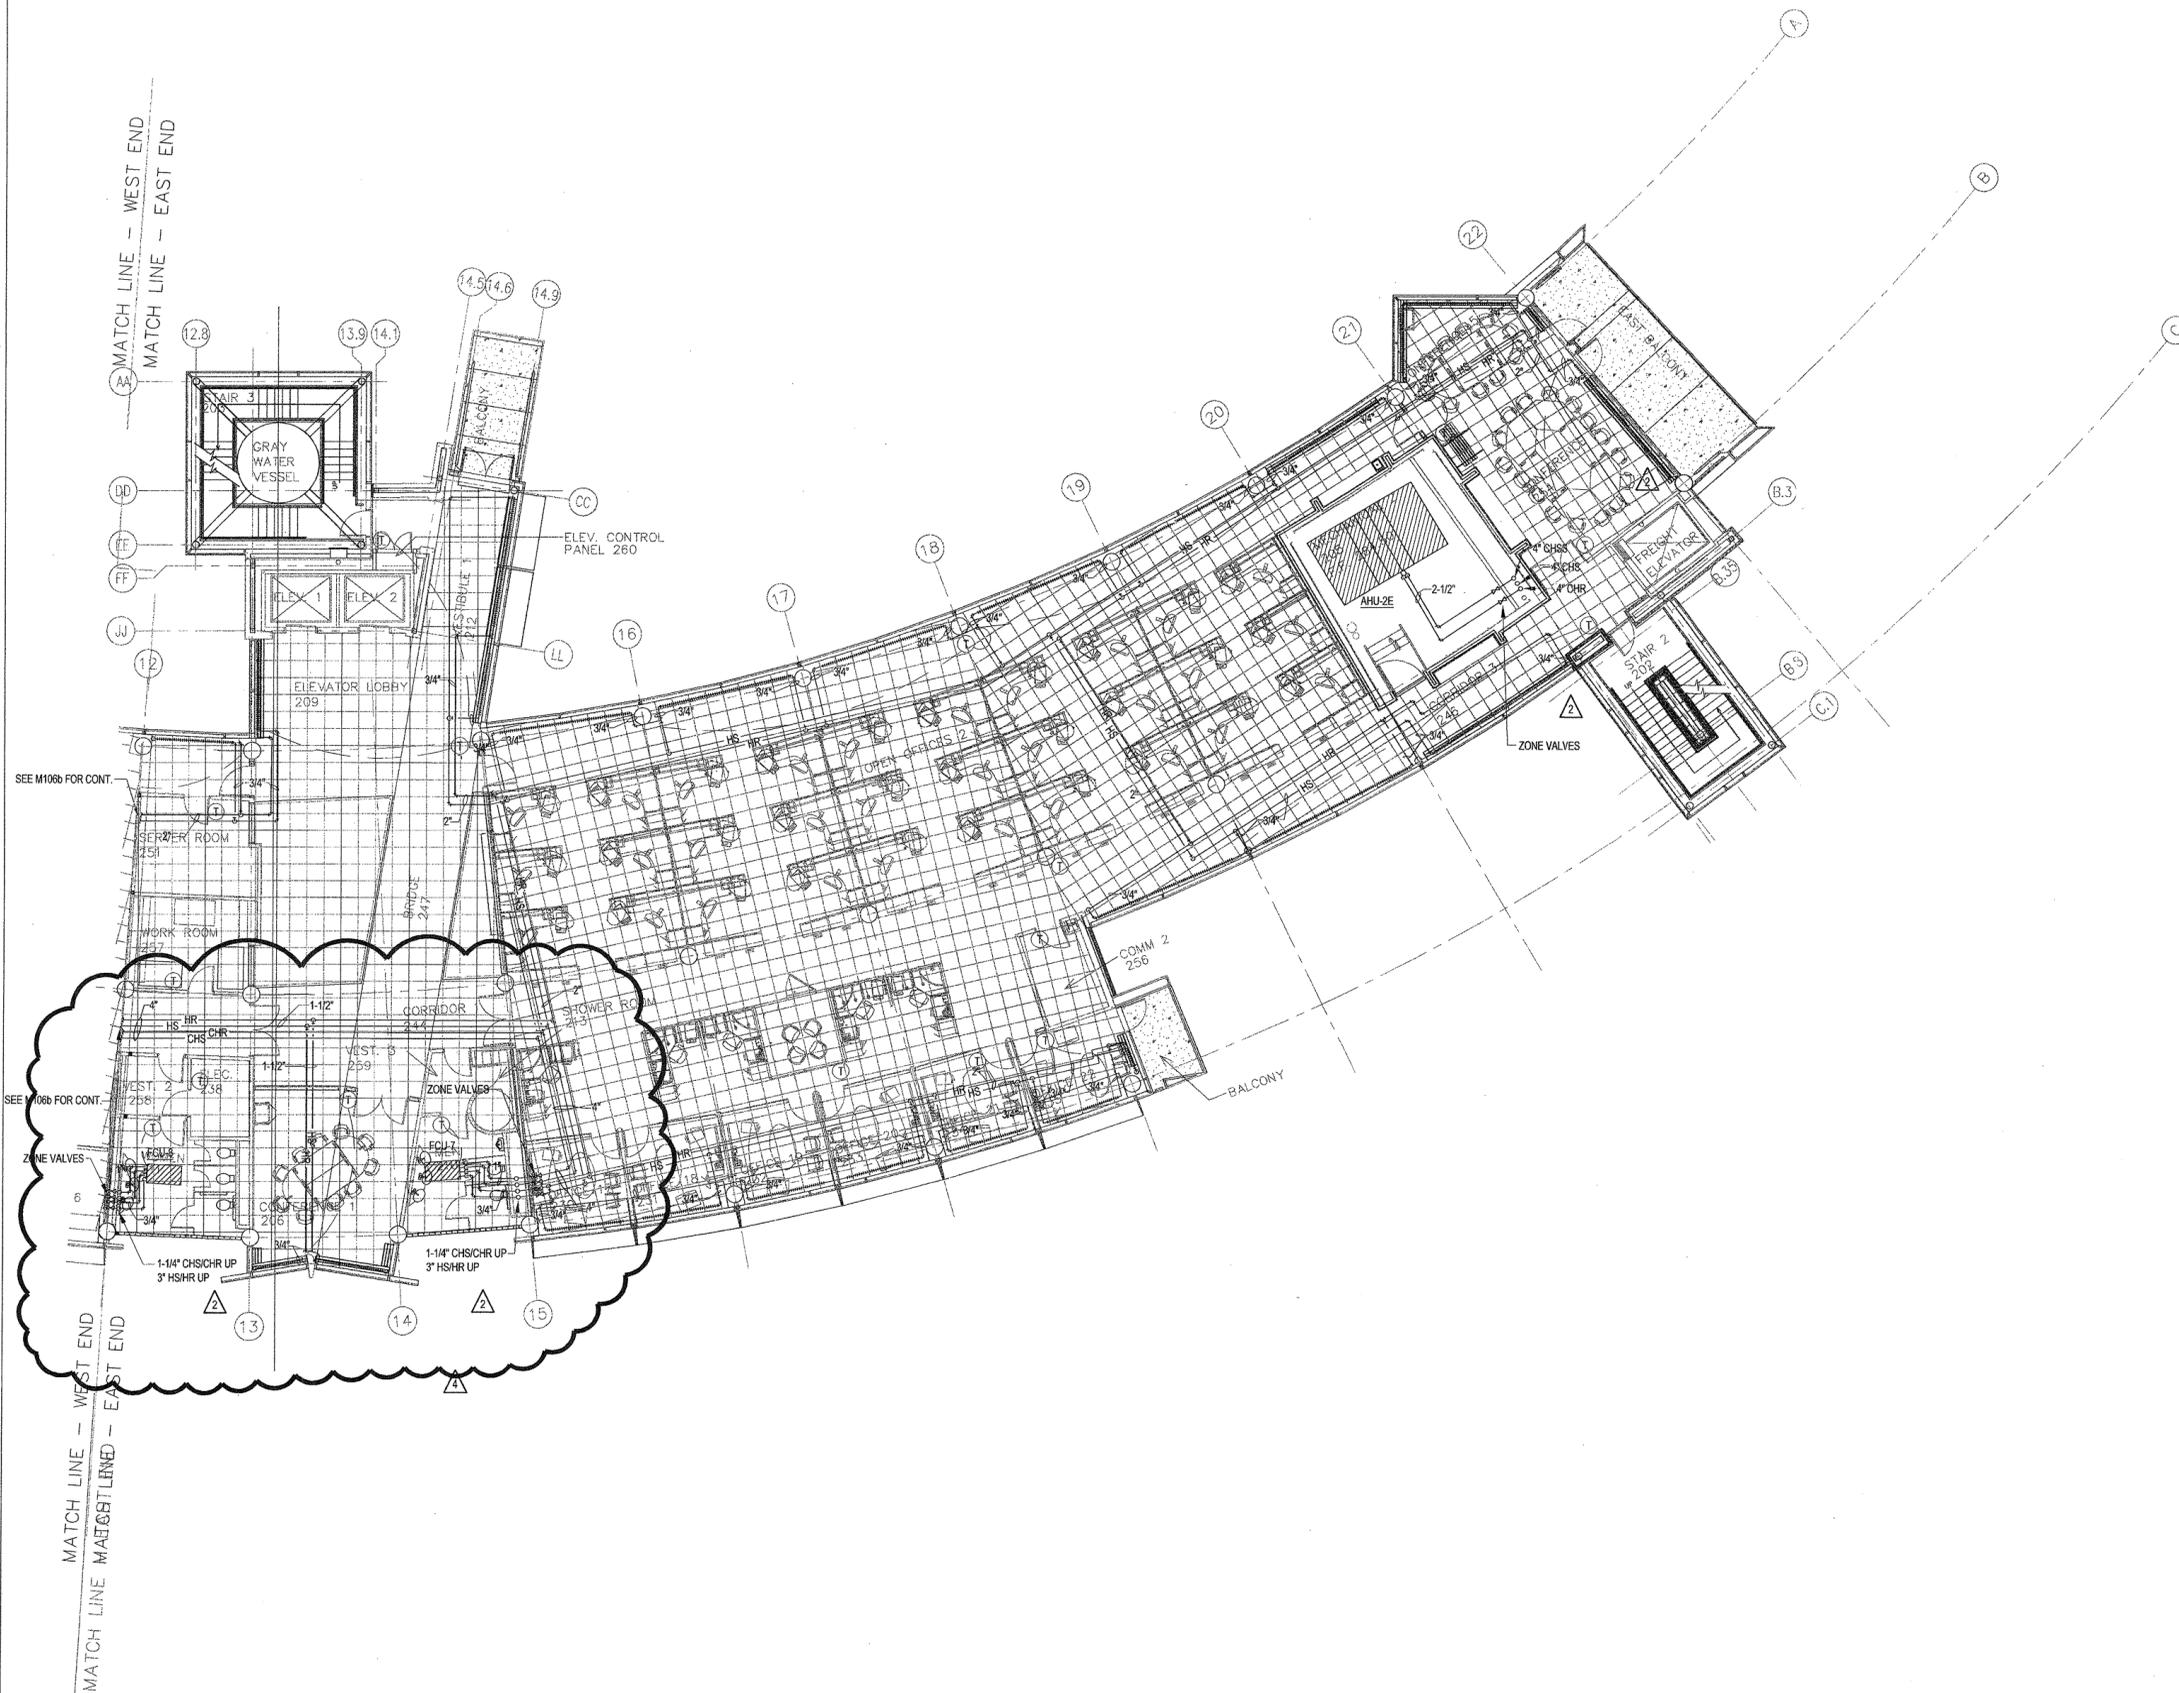

**1 SECOND FLOOR HVAC PIPING PLAN - EAST END**  
SCALE: 1/8" = 1'-0"



DATE PLOTTED: 12/15/03 10:00 AM