

**CONSULTANTS:**

OWNER'S PROJECT ADVISOR:  
MOSES TUCKER REAL ESTATE, INC.

CIVIL ENGINEER:  
McCLELLAND ENGINEERS

LANDSCAPE ARCHITECT:  
LARSON BURNS SMITH

STRUCTURAL ENGINEER:  
CROMWELL ENGINEERS INC.

MECH., ELEC., PLUMB. ENGINEER:  
CROMWELL ENGINEERS INC.

SUSTAINABLE CONSULTANT:  
BNIM/ELEMENTS

GLOBAL VILLAGE CONSULTANT  
CAMBRIDGE SEVEN ASSOCIATES

INTERIOR DESIGNER:  
POLK STANLEY YEARY

GENERAL CONTRACTOR:  
CDI

**GENERAL NOTES:**

NOTES:  
\_\_\_\_\_  
\_\_\_\_\_  
\_\_\_\_\_  
\_\_\_\_\_  
\_\_\_\_\_  
\_\_\_\_\_

ISSUE DATE:  
DECEMBER 15, 2003  
CORE/SHELL  
PACKAGE #5

REVISIONS:


#	DATE	DESCRIPTION
1	1-16-04	ADDENDUM #1
2	7-1-04	PACKAGE 7, 100% ROLL UP
3	11-29-04	ASI #27

**HEIFER  
INTERNATIONAL  
CENTER  
OFFICE BUILDING**  
LITTLE ROCK, ARKANSAS

PSY PROJECT NUMBER:  
431C

CONTENTS:  
HVAC ROOF PLAN

SHEET NUMBER:  
**M109**

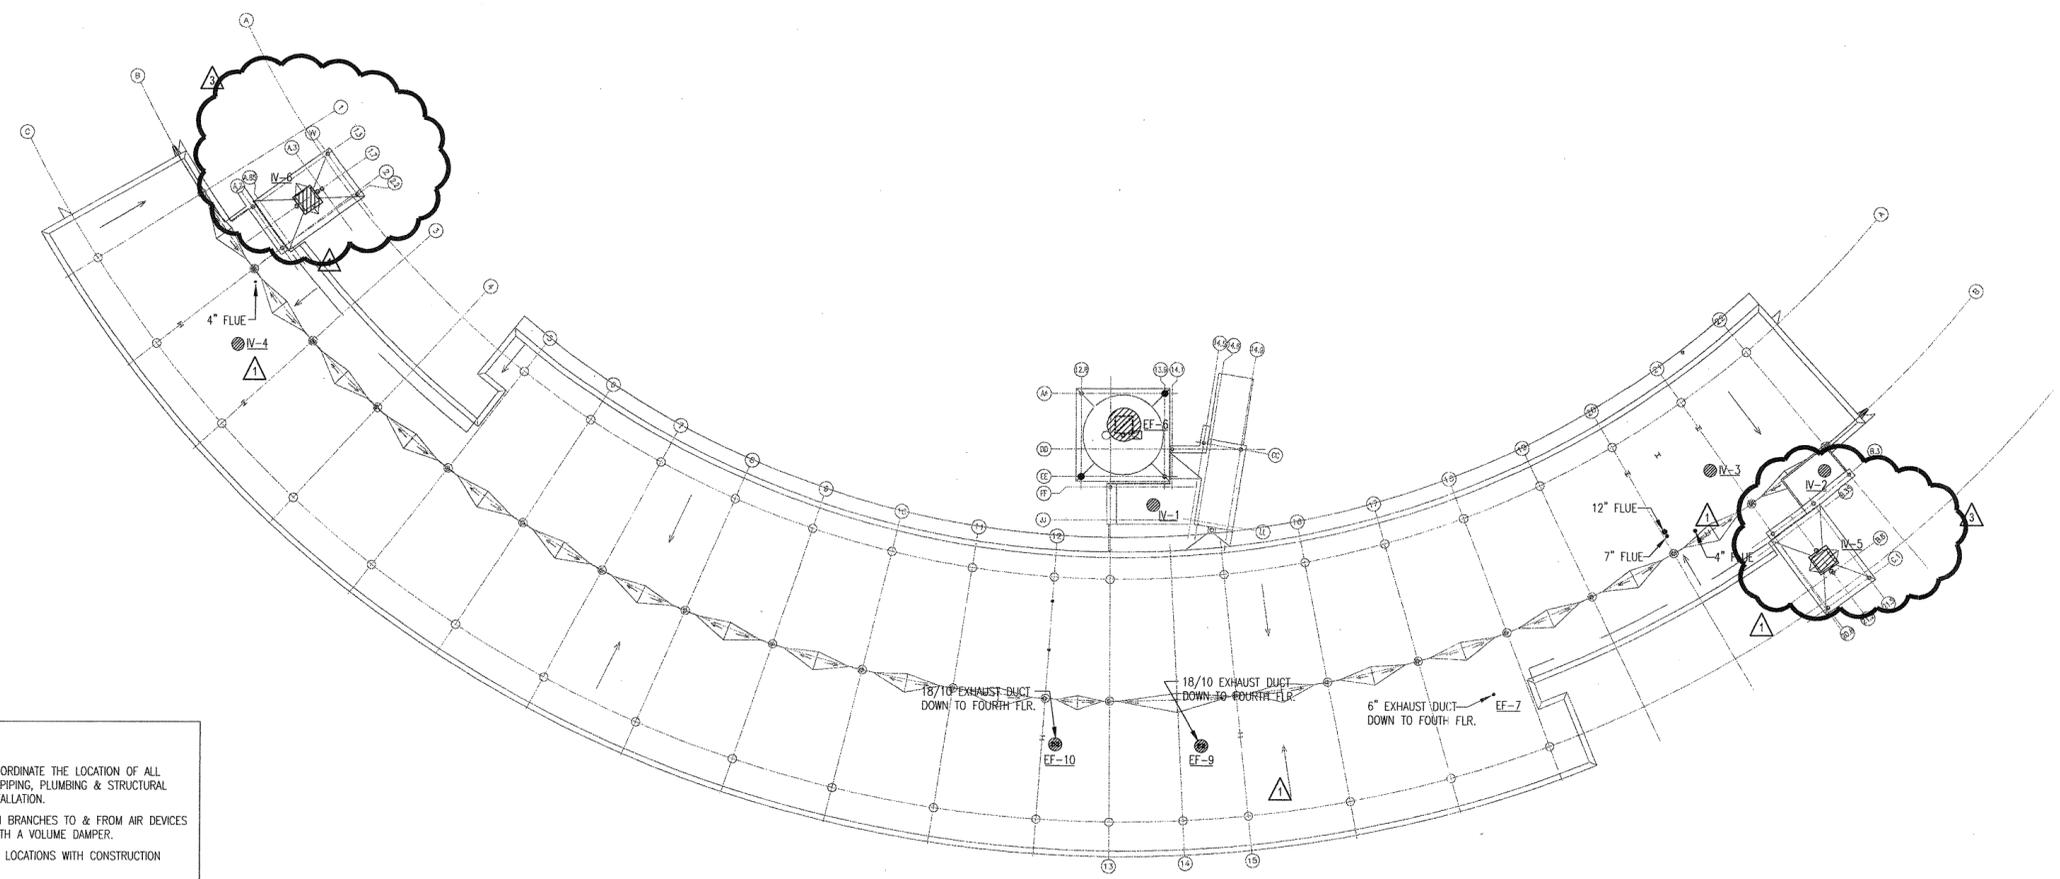

- GENERAL NOTES**
1. CONTRACTOR SHALL COORDINATE THE LOCATION OF ALL DUCTWORK WITH HVAC PIPING, PLUMBING & STRUCTURAL DRAWINGS BEFORE INSTALLATION.
  2. ALL SUPPLY & RETURN BRANCHES TO & FROM AIR DEVICES SHALL BE PROVIDED WITH A VOLUME DAMPER.
  3. VERIFY ALL THERMOSTAT LOCATIONS WITH CONSTRUCTION MANAGER.
  4. CONTRACTOR SHALL PROVIDE A 5'-0" FLEX. CONNECTION TO ALL SUPPLY GRILLES.
  5. CONTRACTOR SHALL VERIFY THAT EACH RATED WALL PENETRATION HAS THE REQUIRED SMOKE DAMPER, FIRE DAMPER OR COMBINATION FIRE/SMOKE DAMPER.
  6. ALL FAN COILS SHALL HAVE AUXILIARY DRAIN PANS AND SHALL BE PIPED TO NEAREST VENT LINE. SEE DETAIL #4 ON M202.

**1 HVAC ROOF PLAN**  
SCALE: 1/16" = 1'-0"  
NORTH

