

**POLK  
STANLEY  
YEARY  
ARCHITECTS, LTD.**

700 SOUTH SCHILLER  
LITTLE ROCK, AR 72201  
501 378-0878  
FAX 372-7629

21 W. MOUNTAIN, SUITE 227  
FAYETTEVILLE, AR 72701  
479-444-0473

**CONSULTANTS:**

- OWNER'S PROJECT ADVISOR:  
MOSES TUCKER REAL ESTATE, INC.
- CIVIL ENGINEER:  
McCLELLAND ENGINEERS
- LANDSCAPE ARCHITECT:  
LARSON BURNS SMITH
- STRUCTURAL ENGINEER:  
CROMWELL ENGINEERS INC.
- MECH., ELEC., PLUMB. ENGINEER:  
CROMWELL ENGINEERS INC.
- SUSTAINABLE CONSULTANT:  
BNIM / ELEMENTS
- GLOBAL VILLAGE CONSULTANT  
CAMBRIDGE SEVEN ASSOCIATES
- INTERIOR DESIGNER:  
POLK STANLEY YEARY
- GENERAL CONTRACTOR:  
CDI

**GENERAL NOTES:**

NOTES:

---



---



---



---



---



---



---



---

ISSUE DATE:  
DECEMBER 15, 2003  
CORE/SHELL  
PACKAGE #5  
REVISIONS:

#	DATE	DESCRIPTION
Δ	1-16-04	ADDENDUM #1
Δ	7-1-04	PACKAGE 7, 100% ROLL UP
Δ	11-29-04	ASI #27


**HEIFER  
INTERNATIONAL  
CENTER  
OFFICE BUILDING**  
LITTLE ROCK, ARKANSAS

PSY PROJECT NUMBER:  
431C

**CONTENTS:**

HVAC DETAILS  
SHEET NUMBER:

**M207**

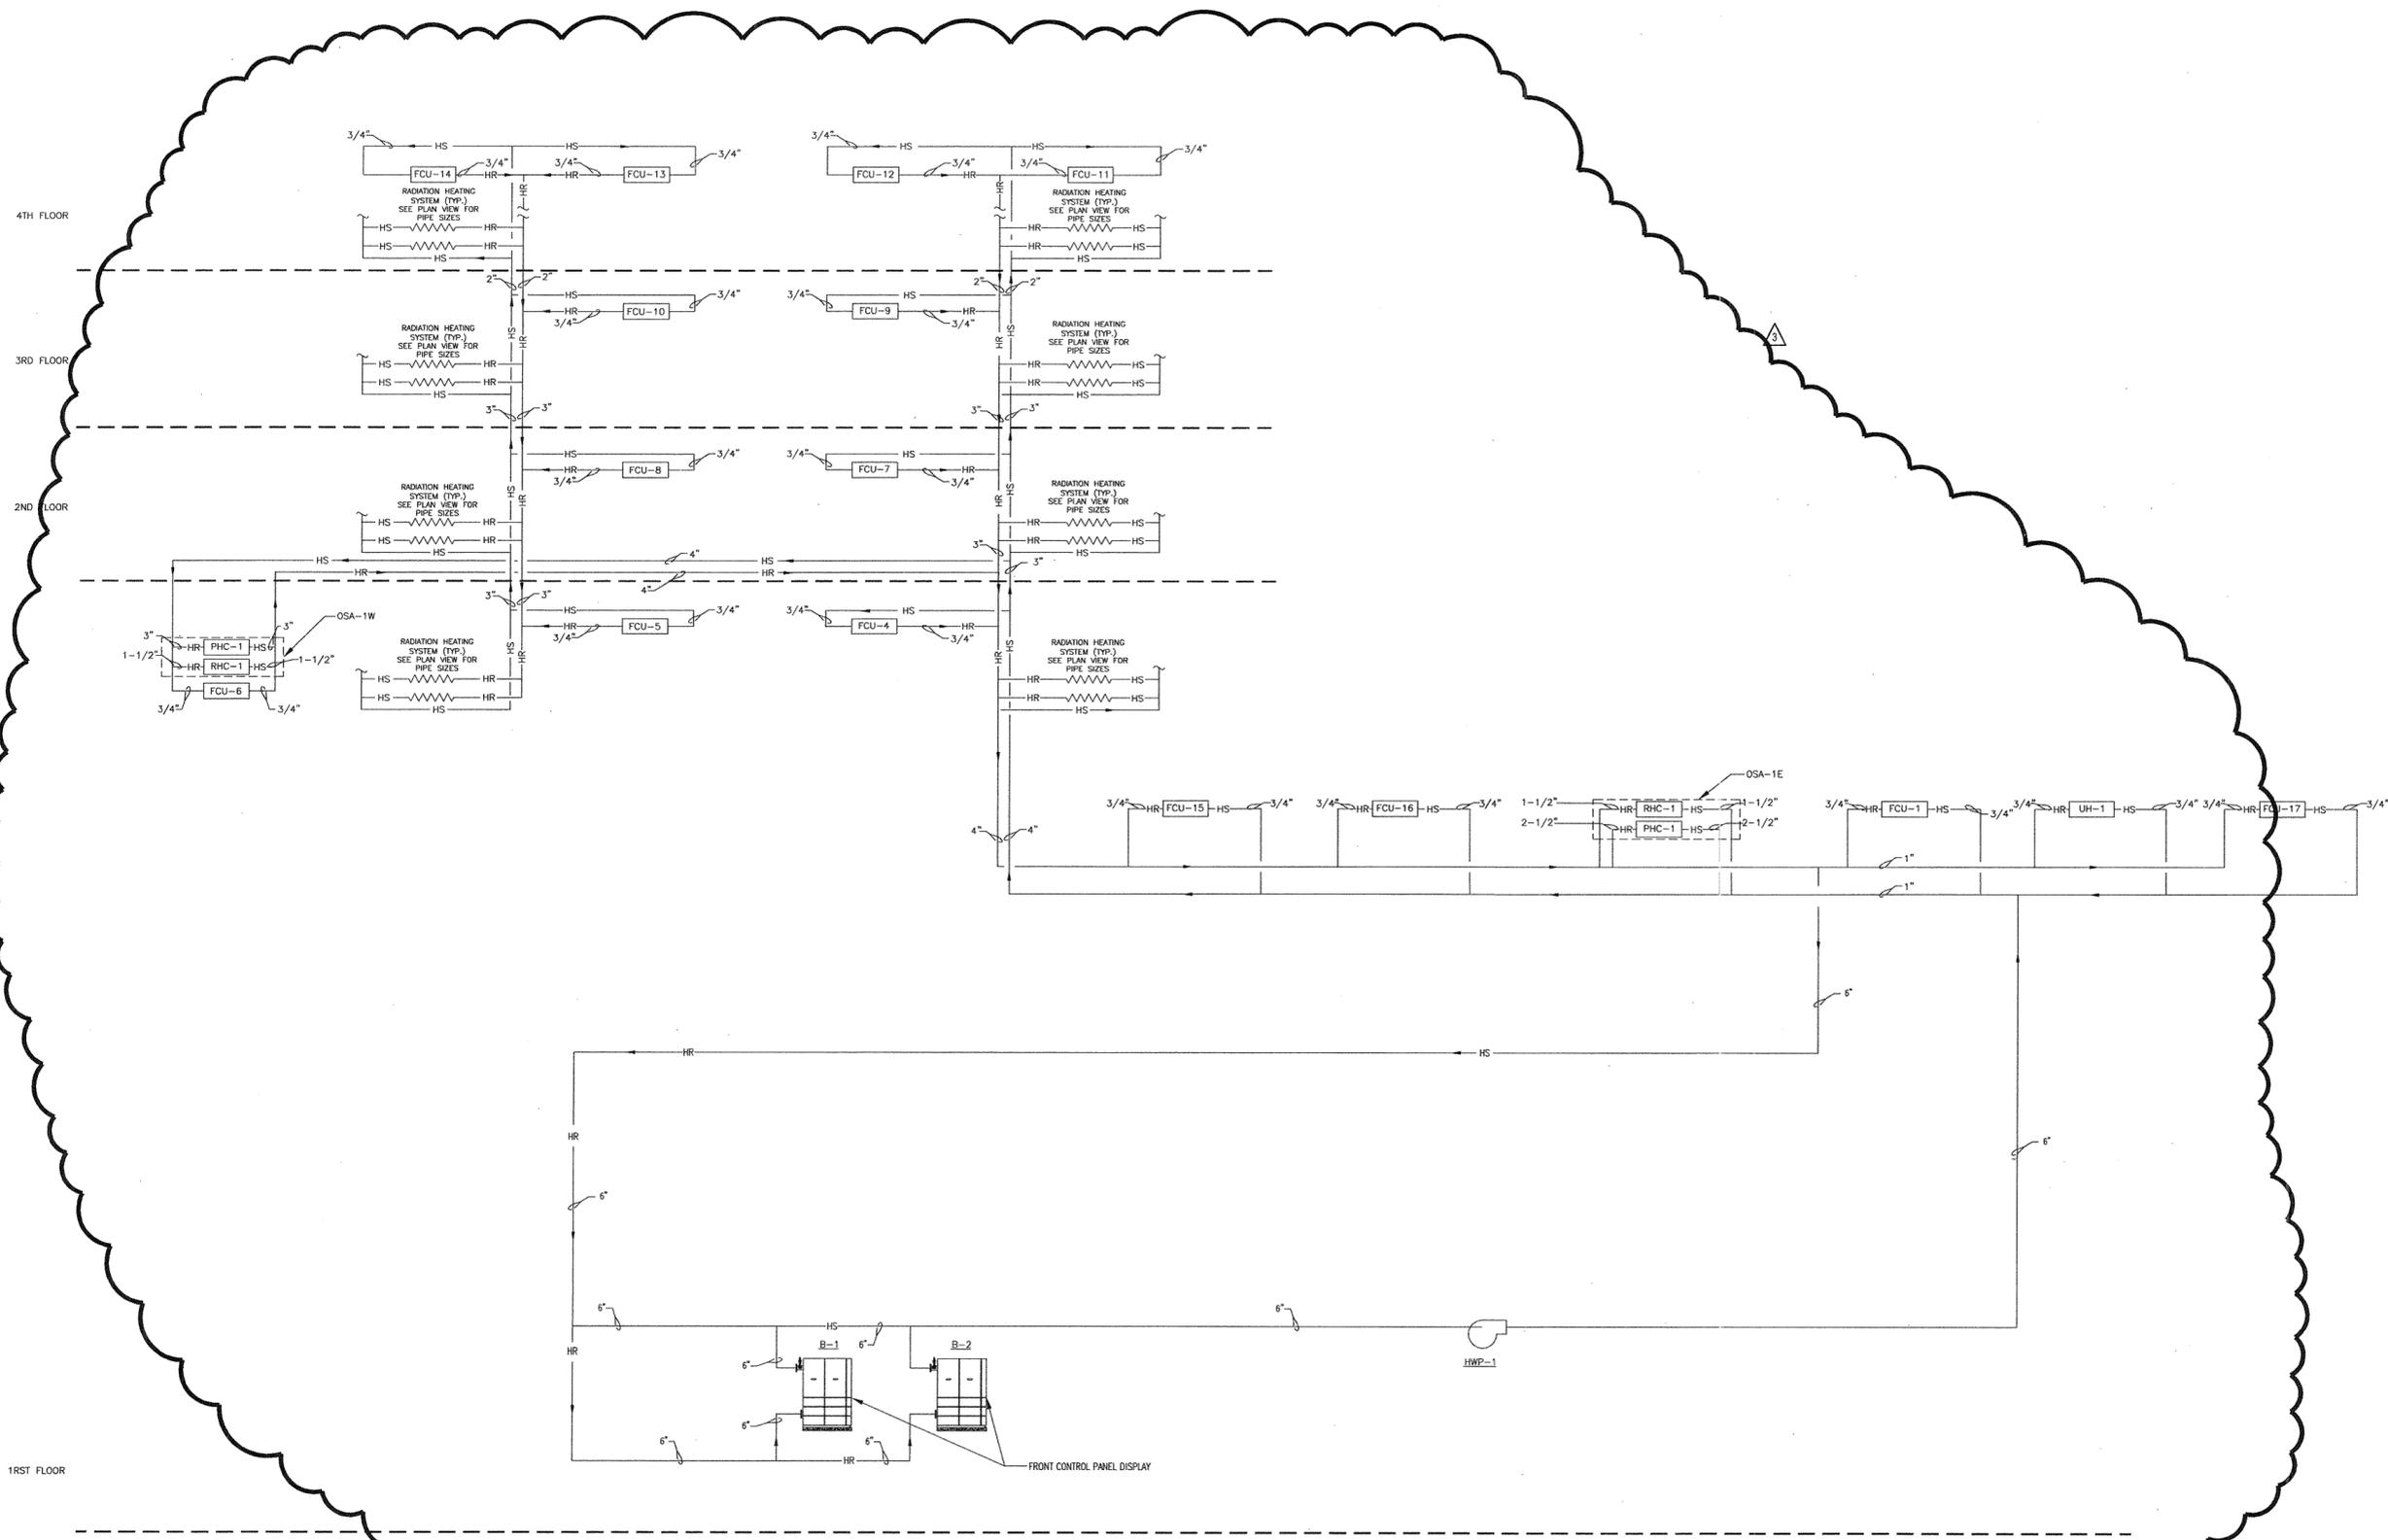

**1 HOT WATER FLOW DIAGRAMS**  
M403 | M403 NO SCALE



DATE PLOTTED: 11/15/04 10:58 AM