

CONSULTANTS:

OWNER'S PROJECT ADVISOR:
MOSES TUCKER REAL ESTATE, INC.

CIVIL ENGINEER:
McCLELLAND ENGINEERS

LANDSCAPE ARCHITECT:
LARSON BURNS SMITH

STRUCTURAL ENGINEER:
CROMWELL ENGINEERS INC.

MECH., ELEC., PLUMB. ENGINEER:
CROMWELL ENGINEERS INC.

SUSTAINABLE CONSULTANT:
BNIM / ELEMENTS

GLOBAL VILLAGE CONSULTANT
CAMBRIDGE SEVEN ASSOCIATES

INTERIOR DESIGNER:
POLK STANLEY YEARY

GENERAL CONTRACTOR:
CDI

GENERAL NOTES:

NOTES:

ISSUE DATE:
DECEMBER 15, 2003
CORE/SHELL
PACKAGE #5

REVISIONS:

#	DATE	DESCRIPTION
1	1-16-04	ADDENDUM #1
2	1-23-04	PACKAGE 5-ADDM. 02
3	7-1-04	PACKAGE 7, 100% ROLL UP
4	11-29-04	ASI #27

**HEIFER
INTERNATIONAL
CENTER
OFFICE BUILDING**

LITTLE ROCK, ARKANSAS


PSY PROJECT NUMBER:
431C

CONTENTS:


HVAC DETAILS

SHEET NUMBER:


M208

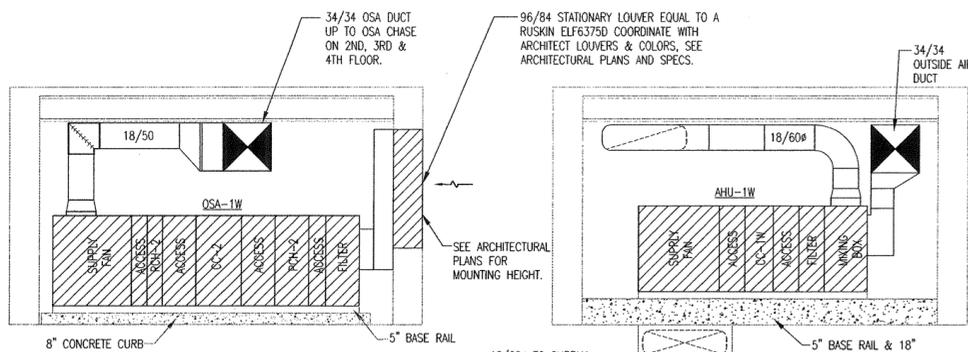


1 ELEVATION @ OSA-1W
M-208 | M101b | 1/4"=1'-0"

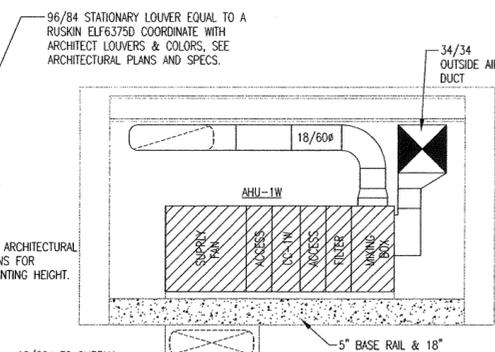


2 ELEVATION @ AHU-1W
M-208 | M101c | 1/4"=1'-0"

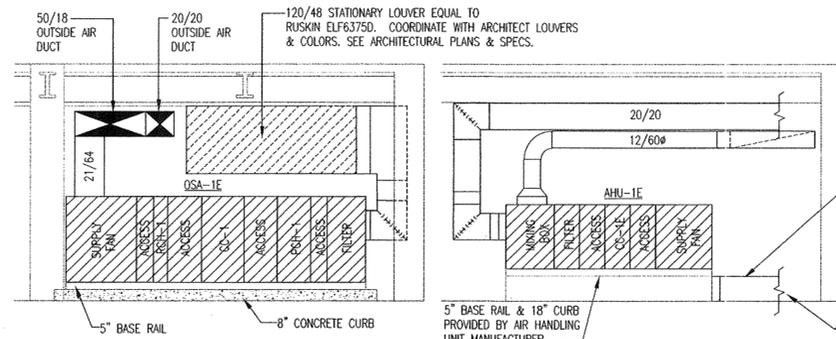


3 ELEVATION @ AHU-1E & OSA-1E
M-208 | M101a | 1/4"=1'-0"

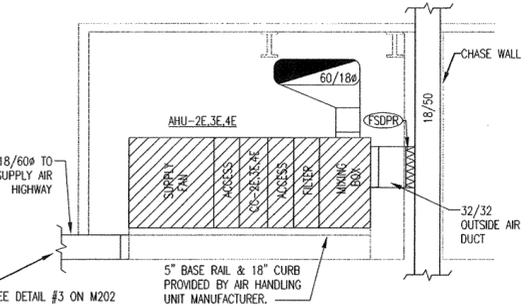


4 ELEVATION @ AHU-2E, 3E & 4E
M-208 | M102a | 1/4"=1'-0"

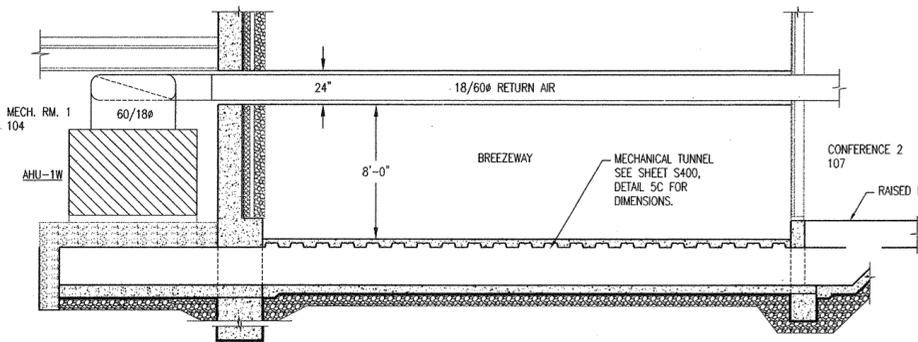


10 ELEVATION @ MECHANICAL TUNNEL
M-208 | M101b | 1/4"=1'-0"

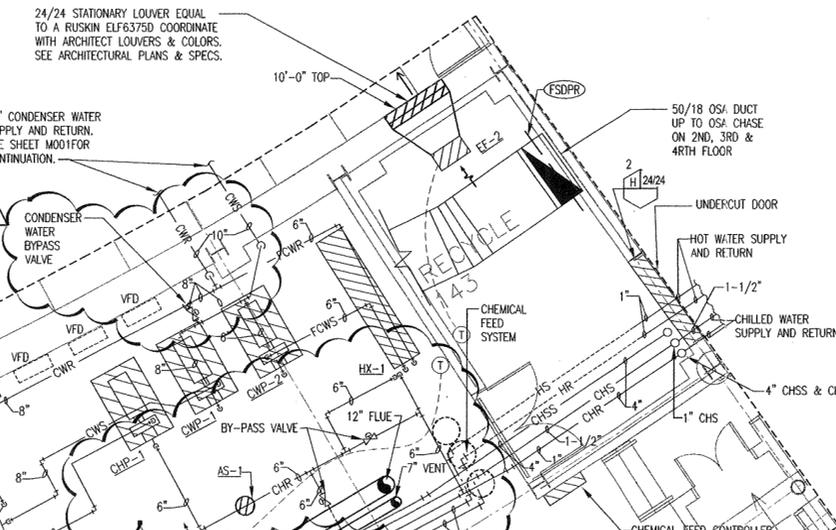

5 ELEVATION @ AHU-2W, 3W & 4W
M-208 | M102b | 1/4"=1'-0"

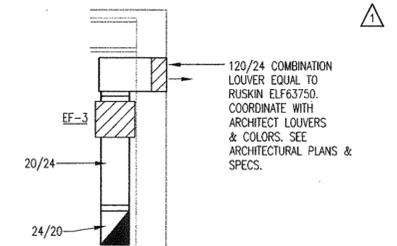

7 ELEVATION @ MECH. 105
M-208 | M208 | 1/4"=1'-0"

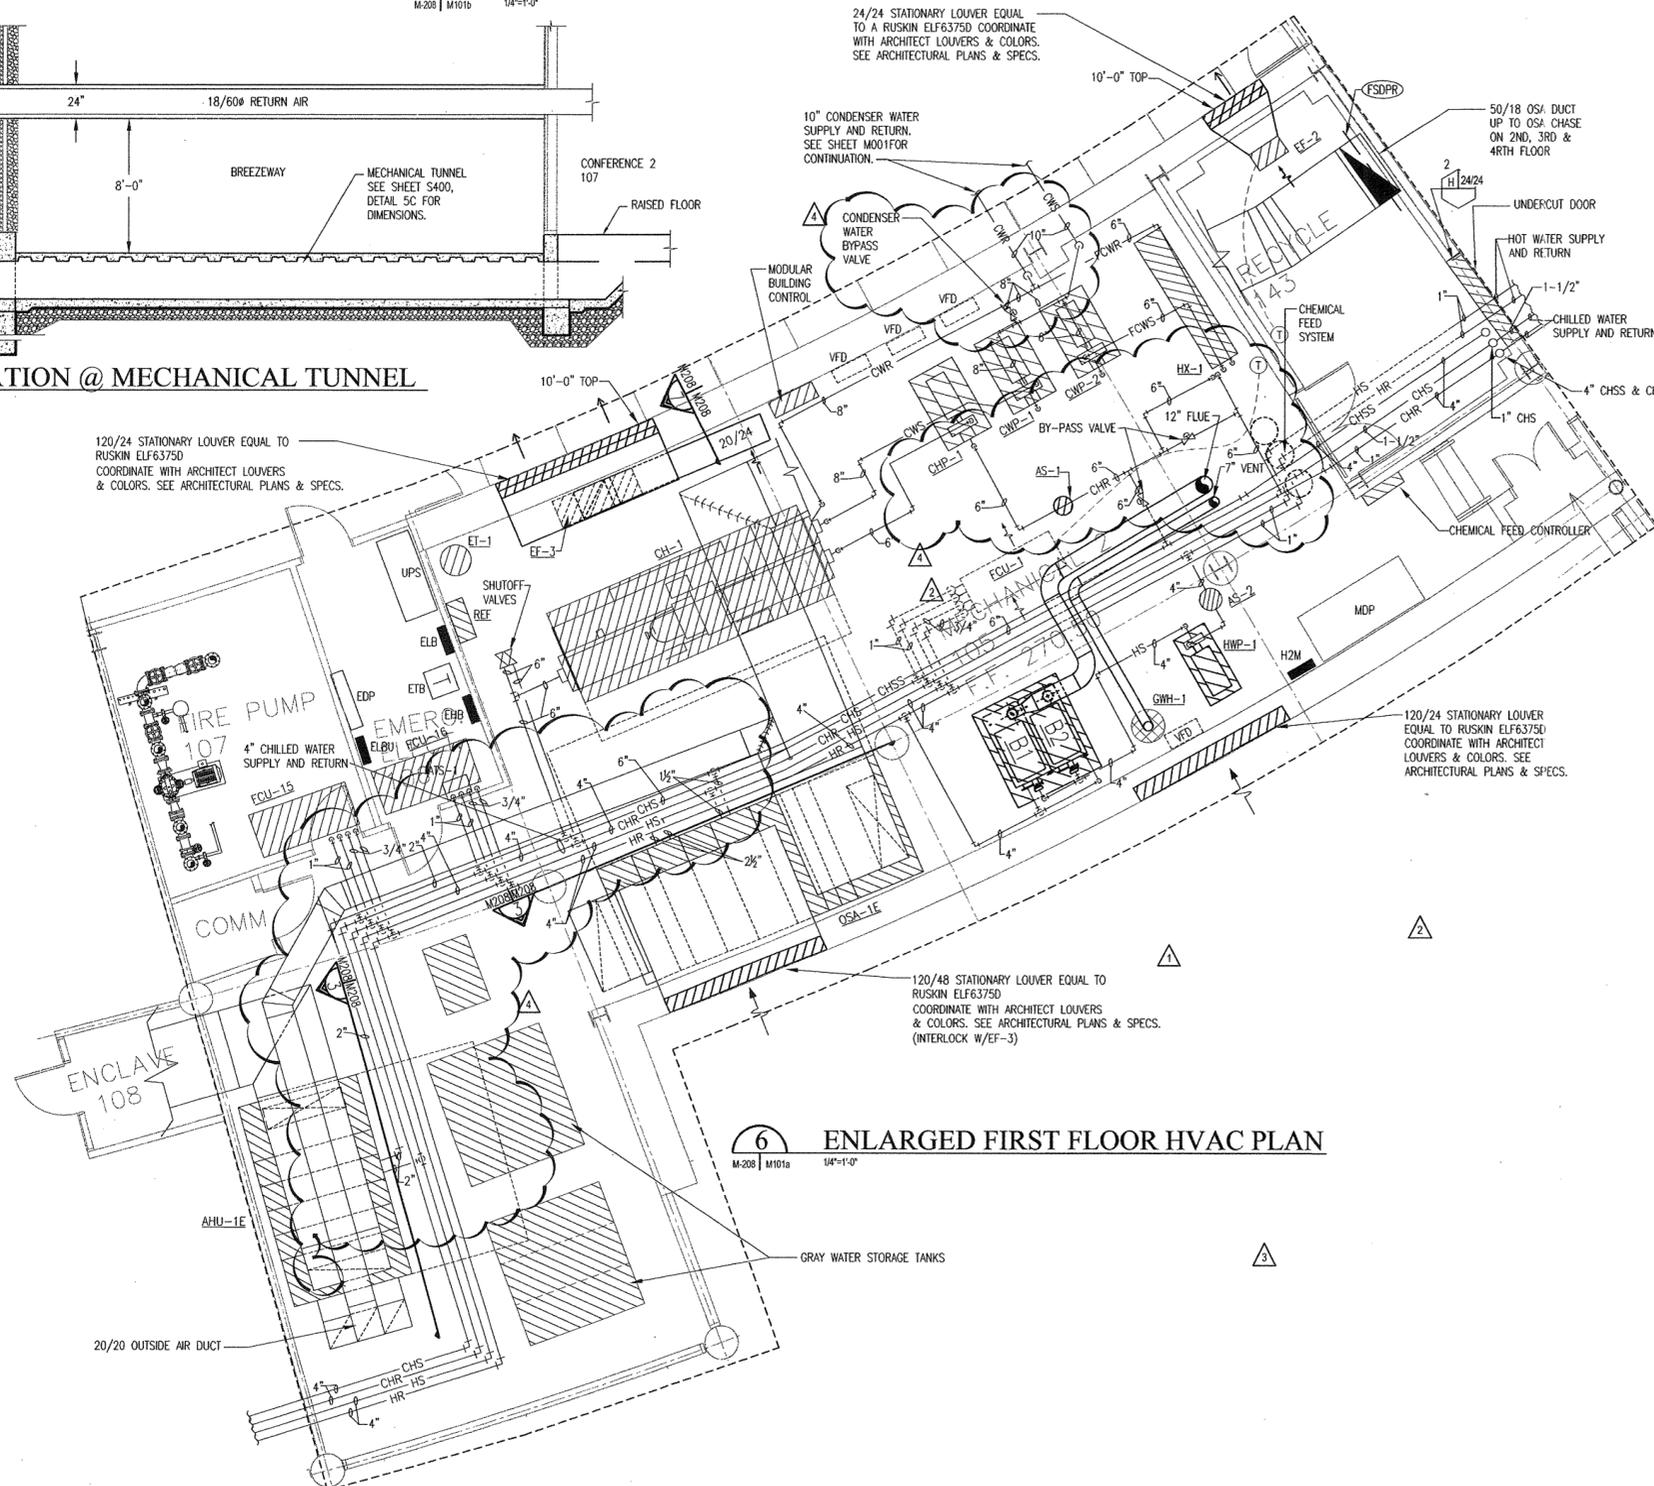

6 ENLARGED FIRST FLOOR HVAC PLAN
M-208 | M101a | 1/4"=1'-0"

