

CONSULTANTS:

OWNER'S PROJECT ADVISOR:
MOSES TUCKER REAL ESTATE, INC.

CIVIL ENGINEER:
McCLELLAND ENGINEERS

LANDSCAPE ARCHITECT:
LARSON BURNS SMITH

STRUCTURAL ENGINEER:
CROMWELL ENGINEERS INC.

MECH. ELEC. PLUMB. ENGINEER:
CROMWELL ENGINEERS INC.

SUSTAINABLE CONSULTANT:
BNIM / ELEMENTS

GLOBAL VILLAGE CONSULTANT
CAMBRIDGE SEVEN ASSOCIATES

INTERIOR DESIGNER:
POLK STANLEY YEARY

GENERAL CONTRACTOR:
CDI

GENERAL NOTES:

NOTES:

ISSUE DATE:
DECEMBER 15, 2003
CORE/SHELL
PACKAGE #5

REVISIONS:

#	DATE	DESCRIPTION
1	01/16/04	PKG. 5 / ADD. #1
2	01/23/04	PACKAGE 5-ADDUM 02
3	05/24/04	ASI #03
4	07/01/04	Package 7, 100% Roll-up


**HEIFER
INTERNATIONAL
CENTER
OFFICE BUILDING**

LITTLE ROCK, ARKANSAS

PSY PROJECT NUMBER:
431C

CONTENTS:
FIRST FLOOR PLUMBING PLAN
WEST END
SHEET NUMBER:

P101b

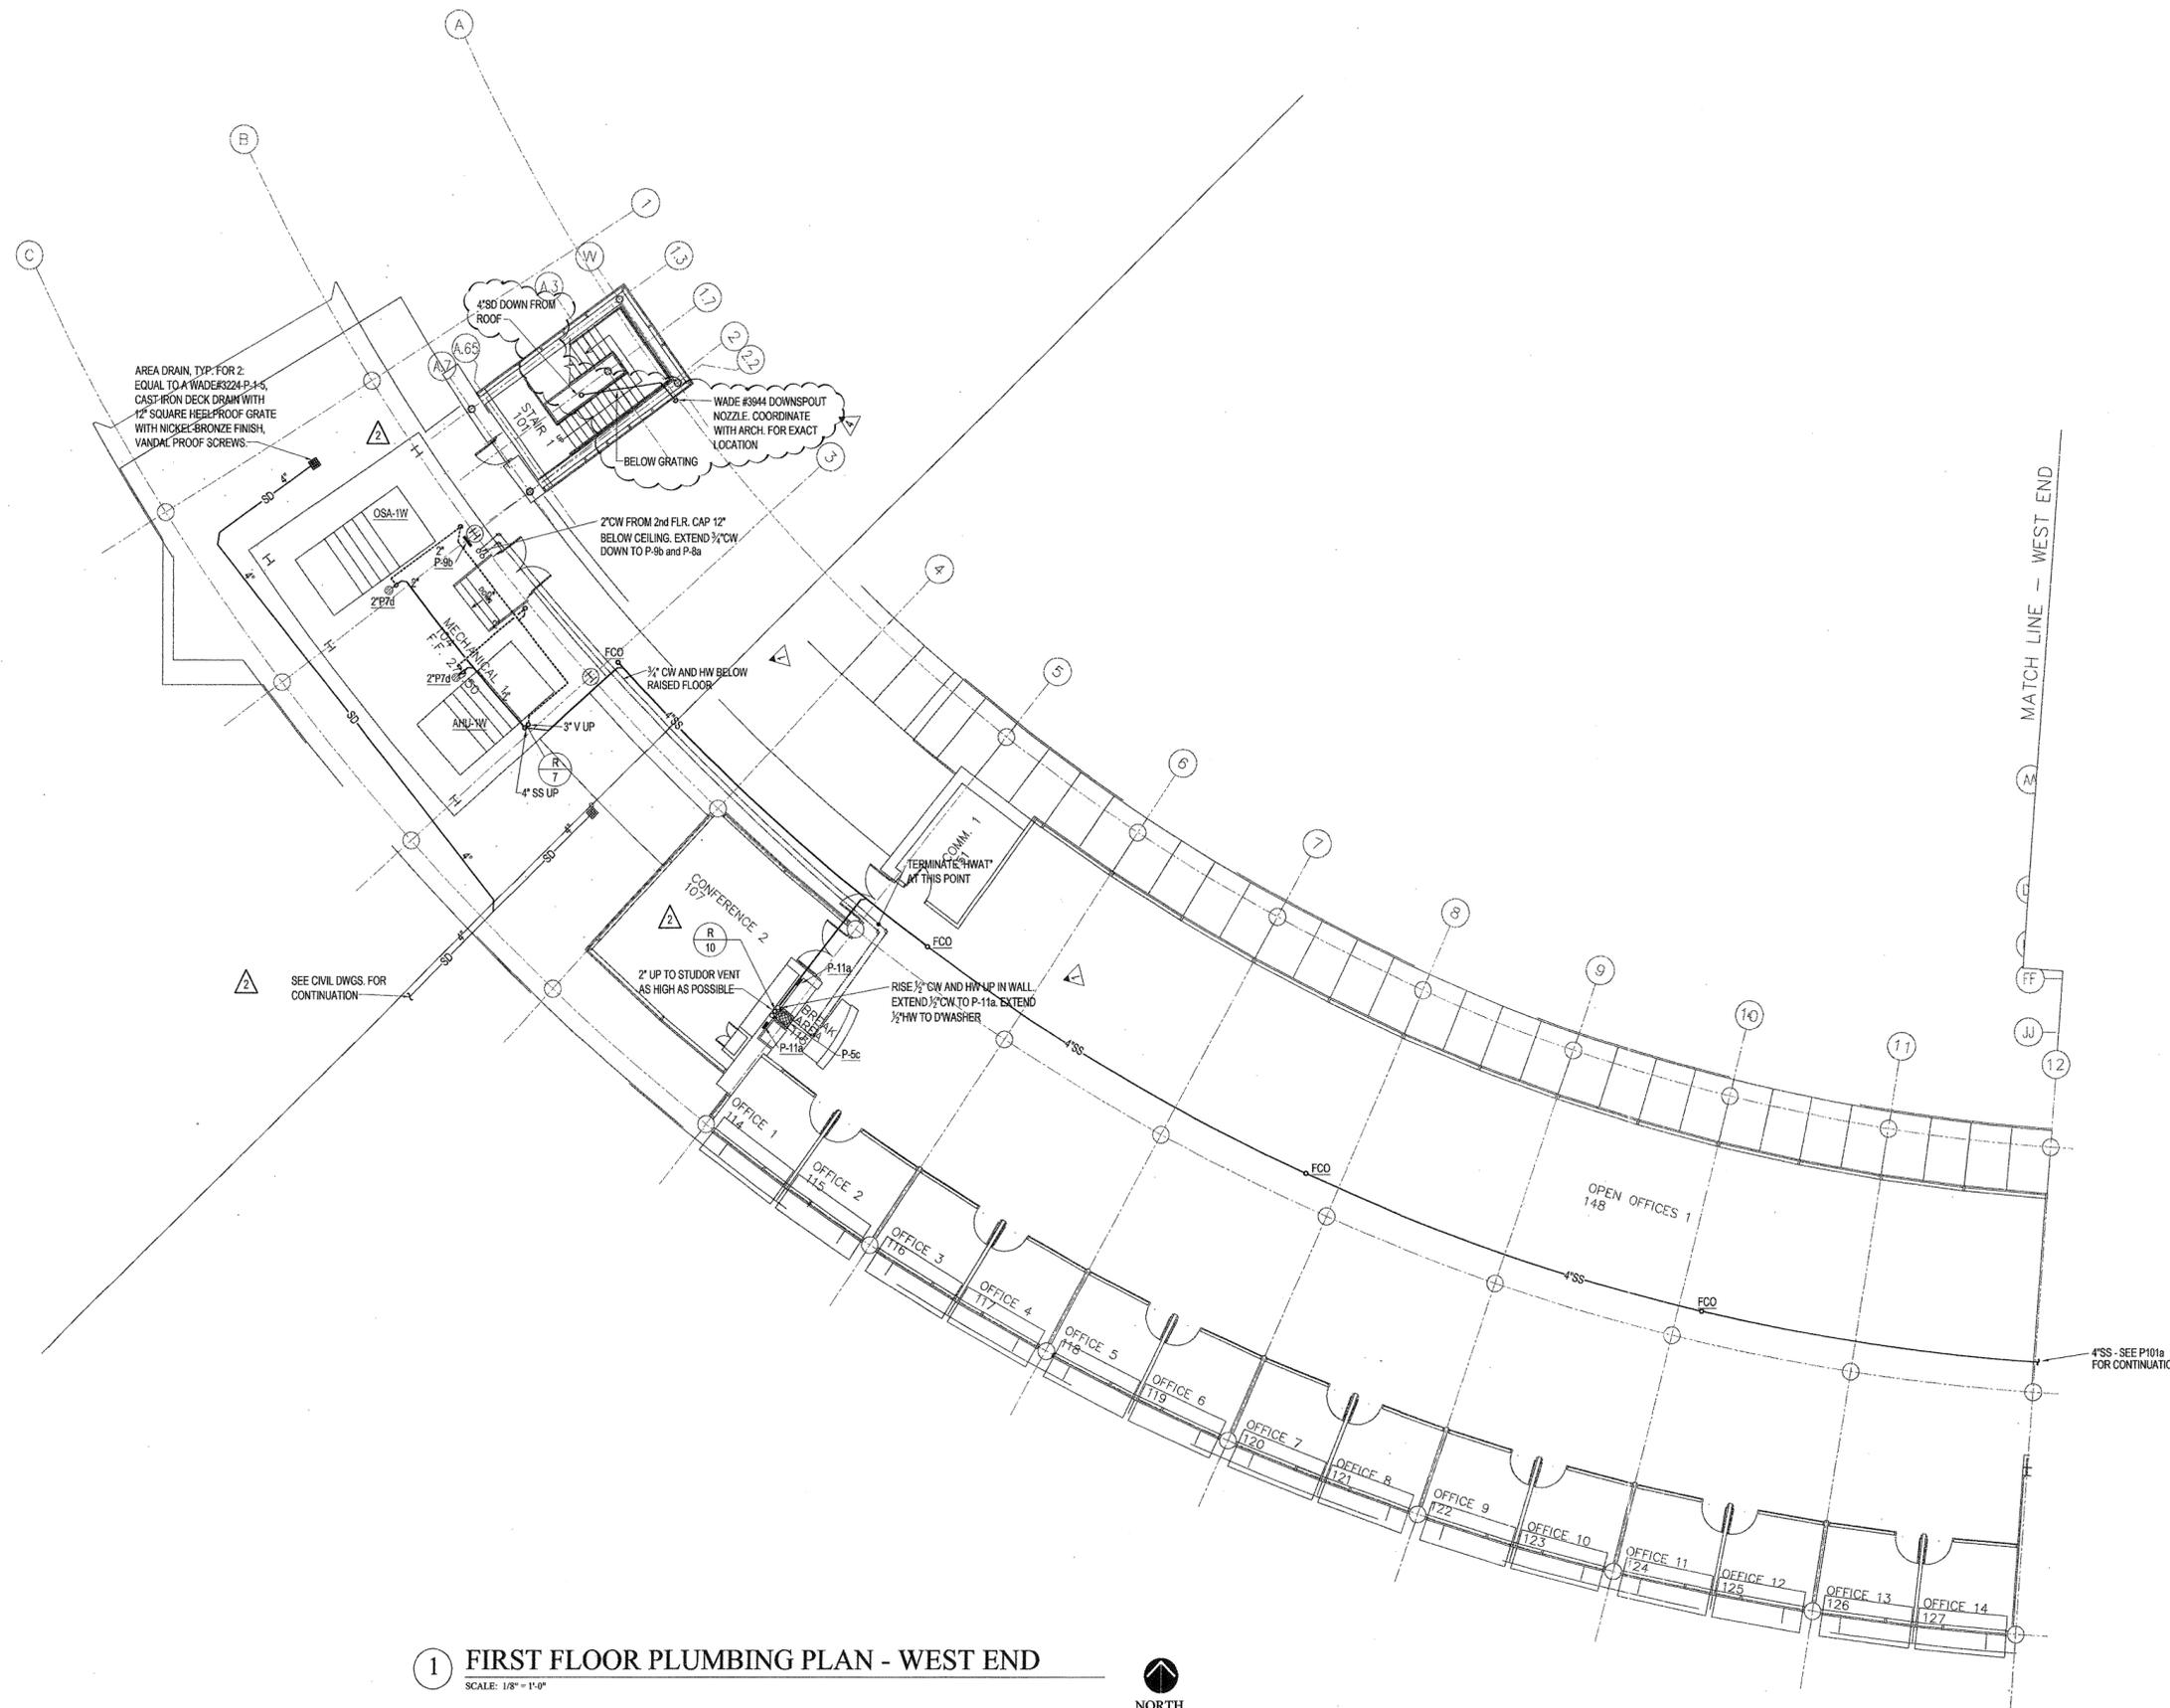

1 FIRST FLOOR PLUMBING PLAN - WEST END

SCALE: 1/8" = 1'-0"



NORTH



DATE PLOTTED: 01/15/04 10:58 AM