

**POLK
STANLEY
YEARY
ARCHITECTS, LTD.**

700 SOUTH SCHILLER
LITTLE ROCK, AR 72201
501.378.0878
FAX 372-7629

21 W. MOUNTAIN, SUITE 227
FAYETTEVILLE, AR 72701
479-444-0473

CONSULTANTS:

OWNER'S PROJECT ADVISOR:
MOSES TUCKER REAL ESTATE, INC.

CIVIL ENGINEER:
McCLELLAND ENGINEERS

LANDSCAPE ARCHITECT:
LARSON BURNS SMITH

STRUCTURAL ENGINEER:
CROMWELL ENGINEERS INC.

MECH., ELEC., PLUMB. ENGINEER:
CROMWELL ENGINEERS INC.

SUSTAINABLE CONSULTANT:
BNIM / ELEMENTS

GLOBAL VILLAGE CONSULTANT
CAMBRIDGE SEVEN ASSOCIATES

INTERIOR DESIGNER:
POLK STANLEY YEARY

GENERAL CONTRACTOR:
CDI

GENERAL NOTES:

NOTES:

ISSUE DATE:
DECEMBER 15, 2003
CORE/SHELL
PACKAGE #5

REVISIONS:

| # | DATE | DESCRIPTION |
|---|----------|-------------------------|
| 1 | 01/16/04 | PKG. 5/ ADD #1 |
| 2 | 01/23/04 | PACKAGE 5-ADDM. 02 |
| 3 | 07/01/04 | Package 7, 100% Roll-up |


**HEIFER
INTERNATIONAL
CENTER
OFFICE BUILDING**

LITTLE ROCK, ARKANSAS

PSY PROJECT NUMBER:
431C

CONTENTS:
THIRD FLOOR PLUMBING PLAN
EAST END
SHEET NUMBER:

P103a

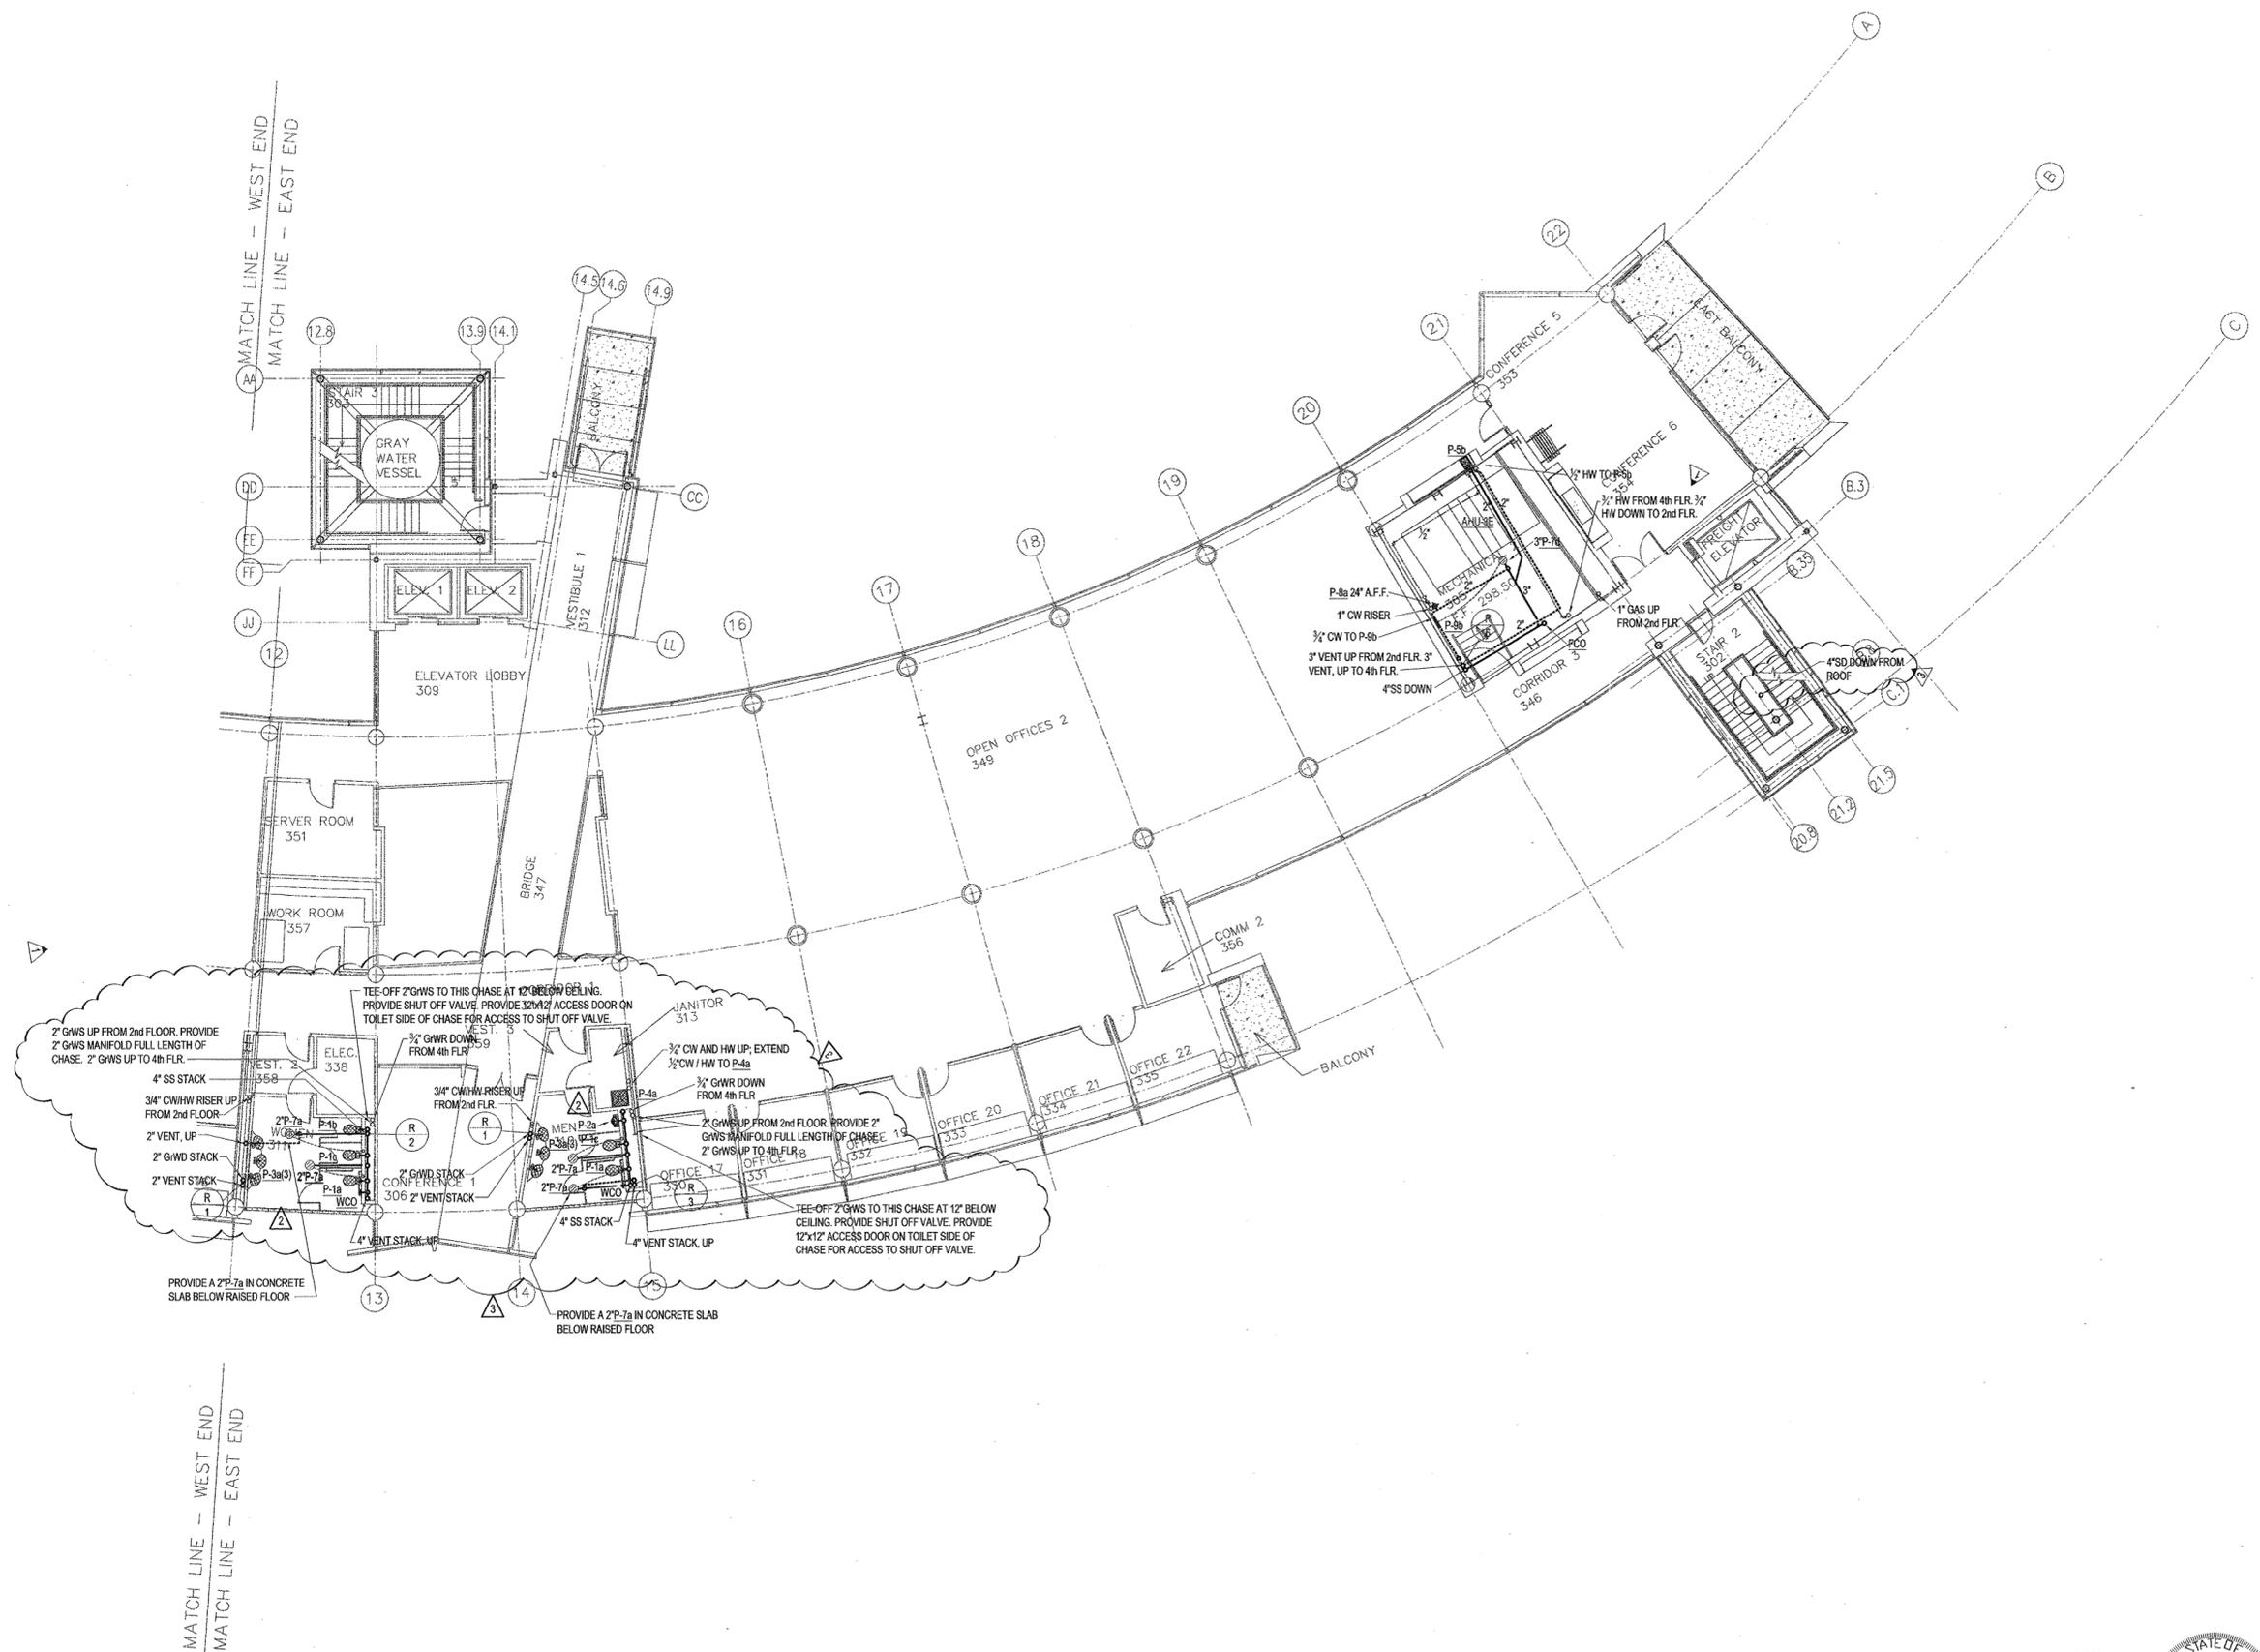

1 THIRD FLOOR PLUMBING PLAN - EAST END
SCALE: 1/8" = 1'-0"



© 2003 POLK STANLEY YEARY ARCHITECTS, LTD.