

**CONSULTANTS:**

OWNER'S PROJECT ADVISOR:  
MOSES TUCKER REAL ESTATE, INC.

CIVIL ENGINEER:  
MCLELLAND ENGINEERS

LANDSCAPE ARCHITECT:  
LARSON BURNS SMITH

STRUCTURAL ENGINEER:  
CROMWELL ENGINEERS INC.

MECH., ELEC., PLUMB. ENGINEER:  
CROMWELL ENGINEERS INC.

SUSTAINABLE CONSULTANT:  
BNIM / ELEMENTS

GLOBAL VILLAGE CONSULTANT  
CAMBRIDGE SEVEN ASSOCIATES

INTERIOR DESIGNER:  
POLK STANLEY YEARY

GENERAL CONTRACTOR:  
CDI

**GENERAL NOTES:**

**NOTES:**

ISSUE DATE:  
DECEMBER 15, 2003  
CORE/SHELL  
PACKAGE #5

**REVISIONS:**

#	DATE	DESCRIPTION
1	01/16/04	PKG. 5/ADD. #1
2	01/23/04	PACKAGE 5-ADDM. 02
3	07/01/04	Package 7, 100% Roll-up
4	11/29/04	ASI #27

**HEIFER  
INTERNATIONAL  
CENTER  
OFFICE BUILDING**


LITTLE ROCK, ARKANSAS

PSY PROJECT NUMBER:  
431C

CONTENTS:  
FOURTH FLOOR PLUMBING PLAN  
EAST END

SHEET NUMBER:

**P104a**

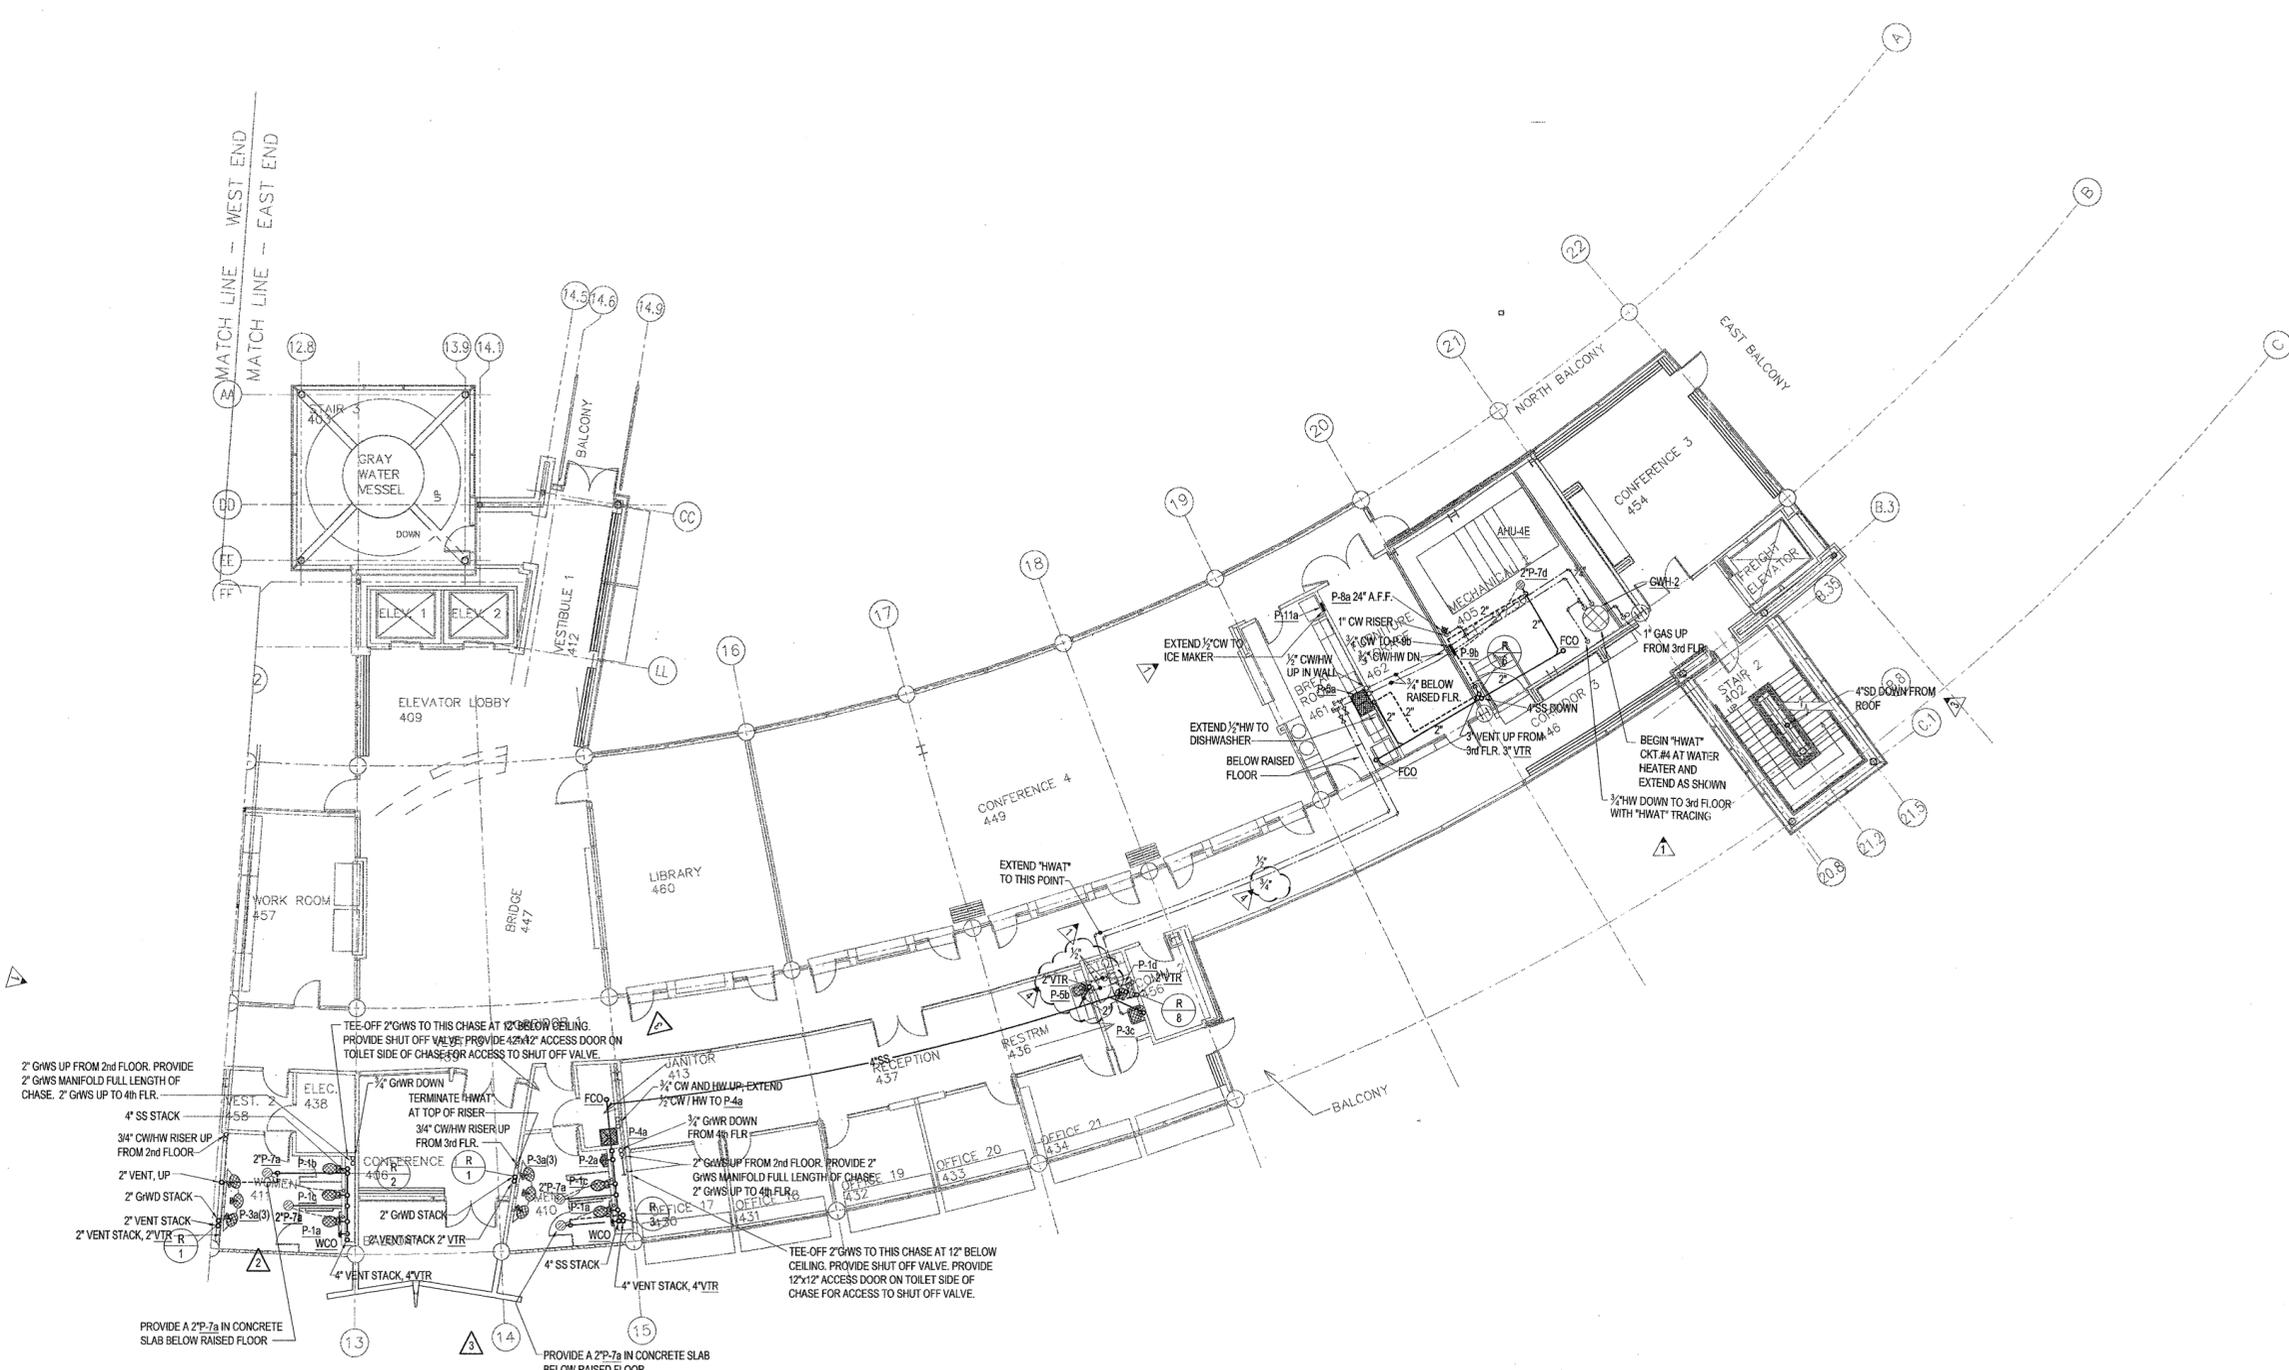

**1 FOURTH FLOOR PLUMBING PLAN - EAST END**  
SCALE: 1/8" = 1'-0"



© 2003 POLK STANLEY YEARY ARCHITECTS, L.T.D.