

CONSULTANTS:
OWNER'S PROJECT ADVISOR:
MOSES TUCKER REAL ESTATE, INC.
CIVIL ENGINEER:
McCLELLAND ENGINEERS
LANDSCAPE ARCHITECT:
LARSON BURNS SMITH
STRUCTURAL ENGINEER:
CROMWELL ENGINEERS INC.
MECH., ELEC., PLUMB. ENGINEER:
CROMWELL ENGINEERS INC.
SUSTAINABLE CONSULTANT:
BNM / ELEMENTS
GLOBAL VILLAGE CONSULTANT
CAMBRIDGE SEVEN ASSOCIATES
INTERIOR DESIGNER:
POLK STANLEY YEARY
GENERAL CONTRACTOR:
CDI

GENERAL NOTES:

NOTES:

ISSUE DATE:
NOVEMBER 17, 2003
**STRUCTURAL FOUNDATION
PACKAGE #4**


REVISIONS:

#	DATE	DESCRIPTION
1	12/11/2003	ADDENDUM 2
2	01/19/2004	PACKAGE 4 - ADDM. 04
3	02/26/2004	PACKAGE 4 - ADDM. 05
4	03/17/2004	PACKAGE 4 - ADDM. 06
5	03/23/2004	PACKAGE 4 - ADDM. 07


**HEIFER
INTERNATIONAL
CENTER
OFFICE BUILDING**
LITTLE ROCK, ARKANSAS

PSY PROJECT NUMBER:
431C


CONTENTS:
FOUNDATION PLAN -
WEST END
SHEET NUMBER:
S101b

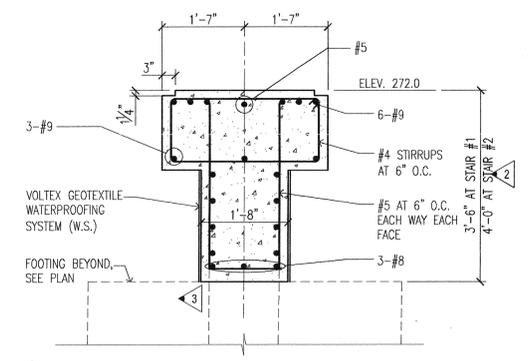

3 GRADE BEAM SECTION AT STAIR
SCALE: 3/8"=1'-0" (REF. 12/A602a)

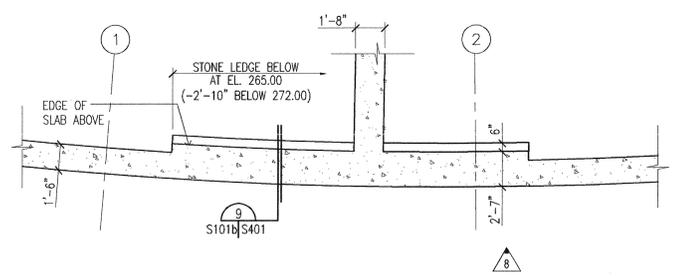

2 ENLARGED PLAN
SCALE: 1/2"=1'-0"

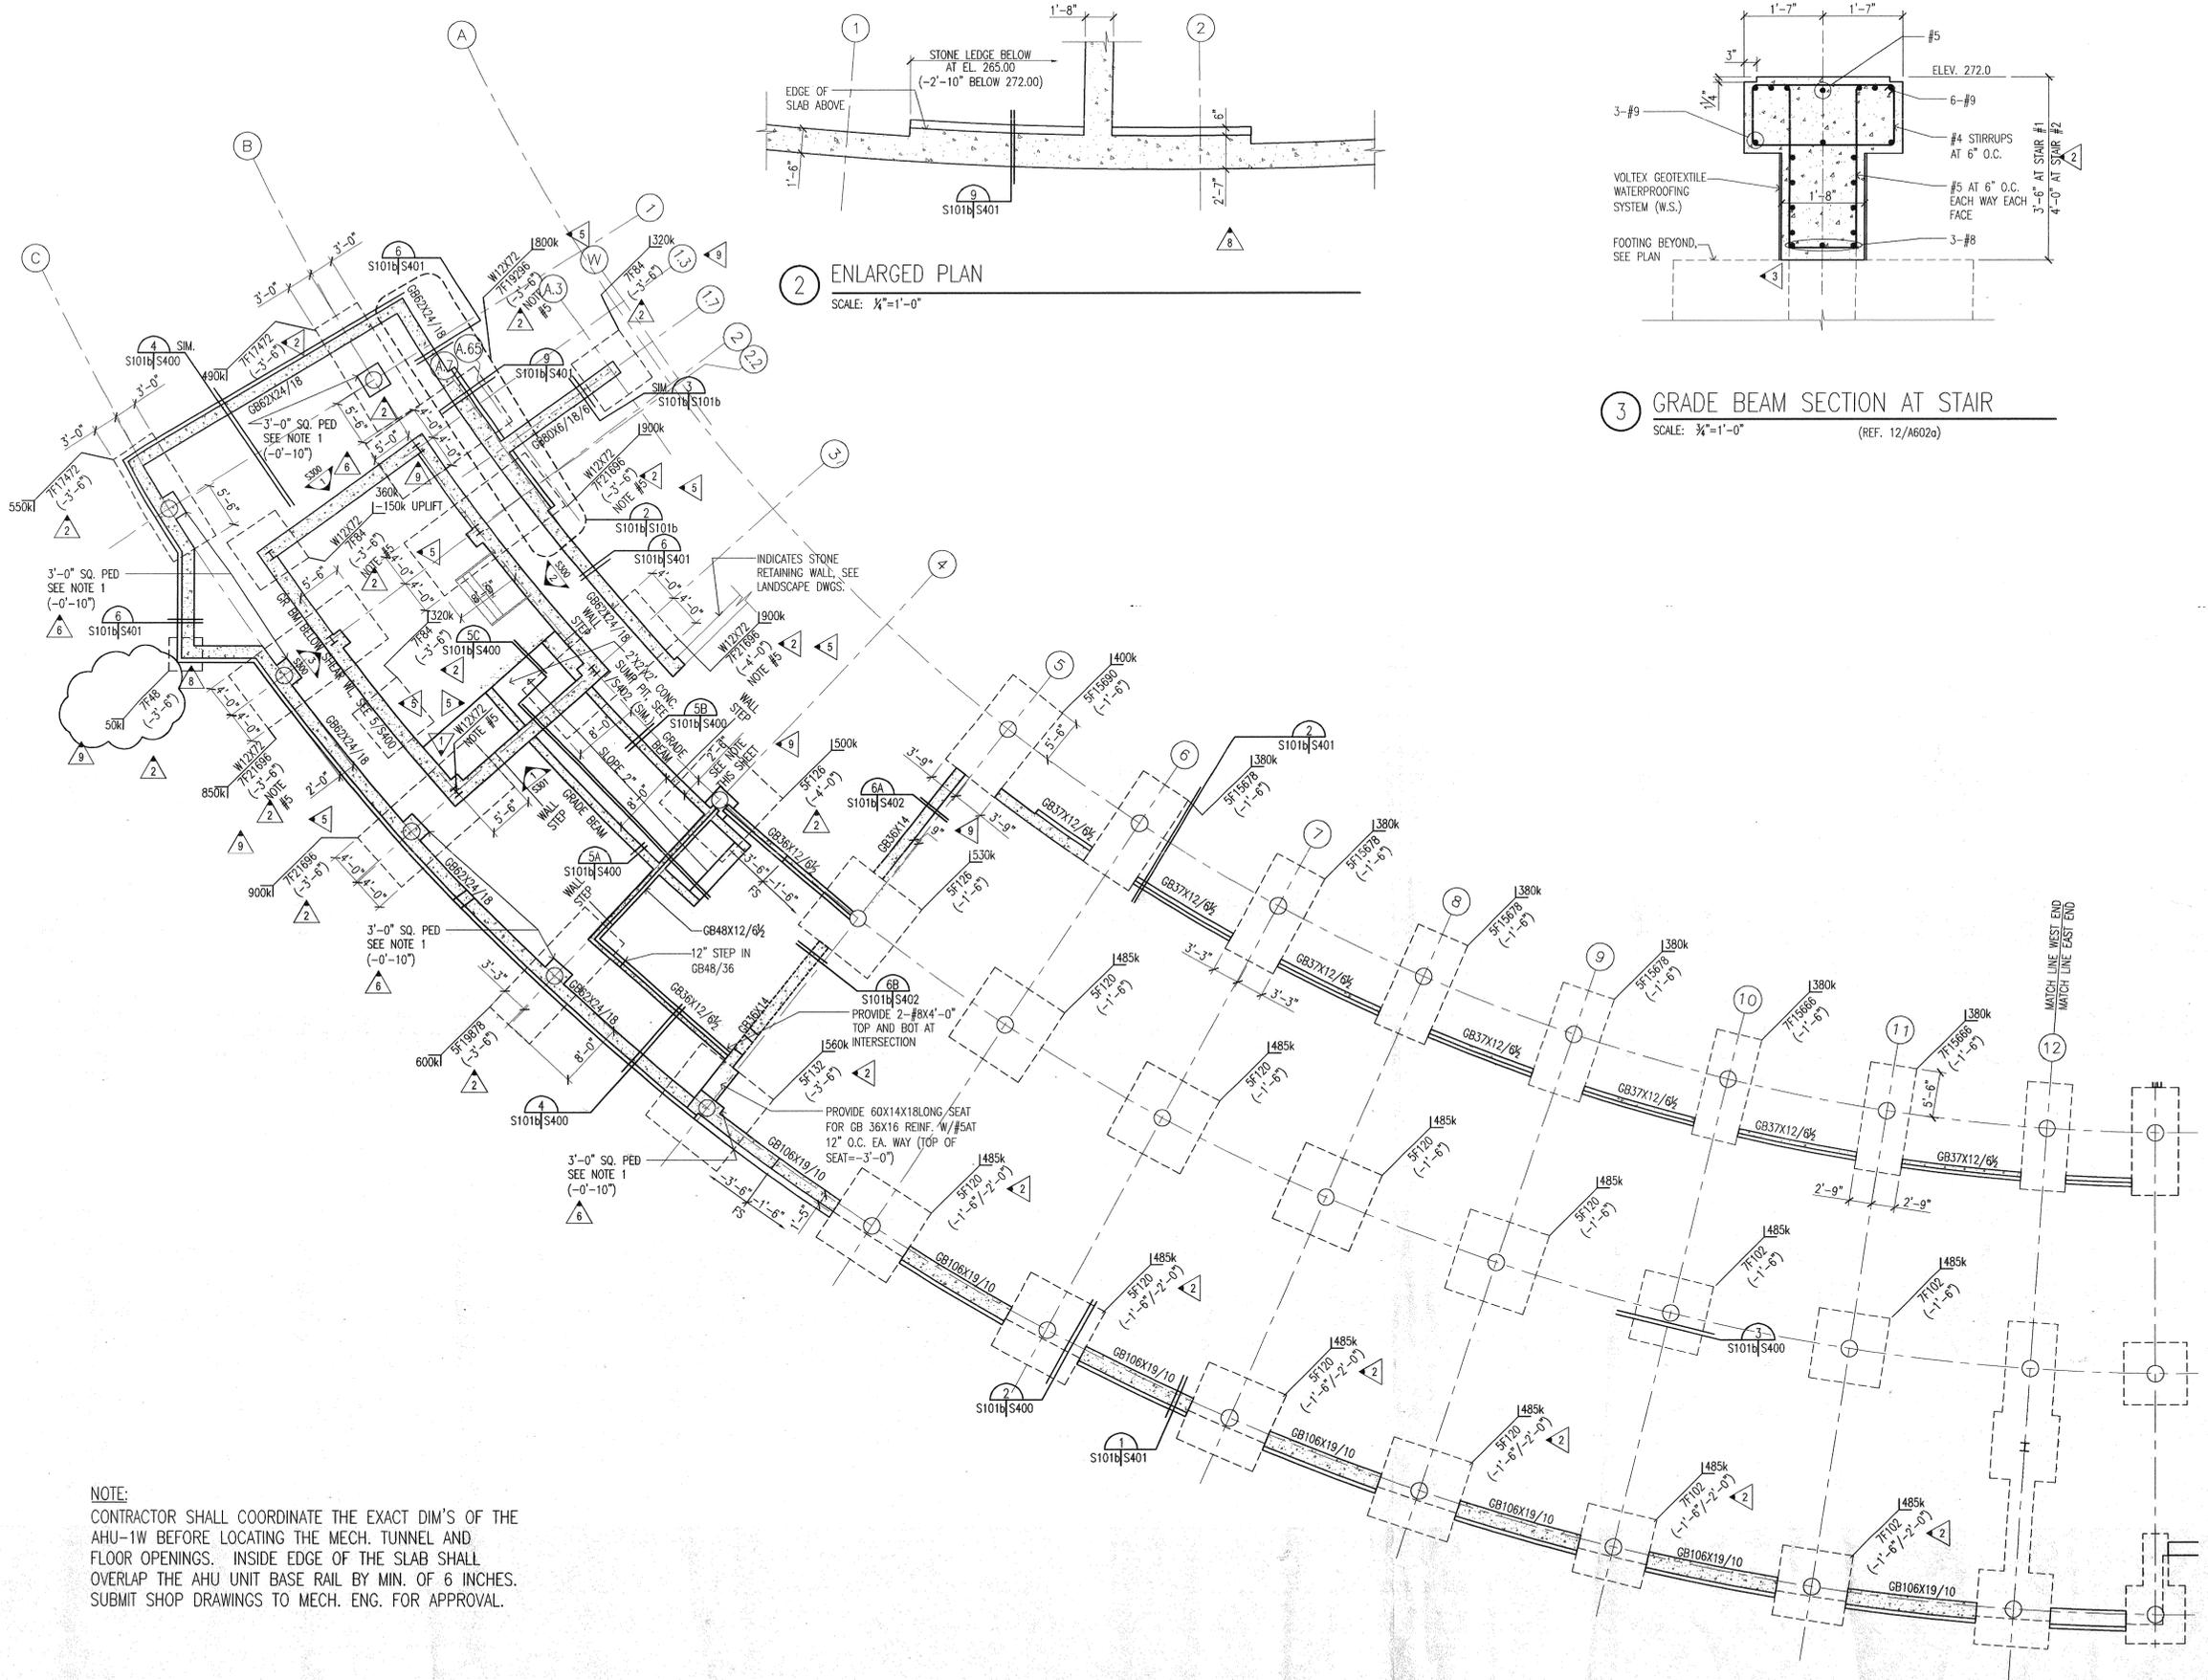

1 FOUNDATION PLAN - WEST END
SCALE: 1/8"=1'-0" SEE SHEET G003 AND ARCH PLANS FOR DIMENSIONS NOT GIVEN. SEE S101a FOR NOTES AND INFO NOT GIVEN.

NOTE:
CONTRACTOR SHALL COORDINATE THE EXACT DIM'S OF THE AHU-1W BEFORE LOCATING THE MECH. TUNNEL AND FLOOR OPENINGS. INSIDE EDGE OF THE SLAB SHALL OVERLAP THE AHU UNIT BASE RAIL BY MIN. OF 6 INCHES. SUBMIT SHOP DRAWINGS TO MECH. ENG. FOR APPROVAL.

