

400 SOUTH SCHIFFER
LITTLE ROCK, AR 72601
501.373.4878
501.373.7629 fax

509 W. SPRING STREET, SUITE 100
FAYETTEVILLE, AR 72701
479.444.0299 office
473.251.7166 fax

www.polkstanley.com



- CONSULTANTS:**
- CIVIL ENGINEER: MCCLELLAND ENGINEERS
 - LANDSCAPE ARCHITECT: LARSON BURNS SMITH
 - STRUCTURAL ENGINEER: CROMWELL ENGINEERS INC.
 - MECH., ELEC., PLUMB. ENGINEER: CROMWELL ENGINEERS INC.
 - GLOBAL VILLAGE CONSULTANT: CAMBRIDGE SEVEN ASSOCIATES
 - INTERIOR DESIGNER: POLK STANLEY ROWLAND CURZON PORTER ARCHITECTS
 - GENERAL CONTRACTOR: CDI CONTRACTORS, INC.

NOTES:

ISSUE DATE:
17 SEPTEMBER 07

#	DATE	DESCRIPTION


**MURPHY KELLER
EDUCATION CENTER**

**HEIFER
INTERNATIONAL
CENTER**
LITTLE ROCK, ARKANSAS

PSRCP JOB NUMBER:
431E

CONTENTS:
SITE PLAN

SHEET NUMBER:
A100

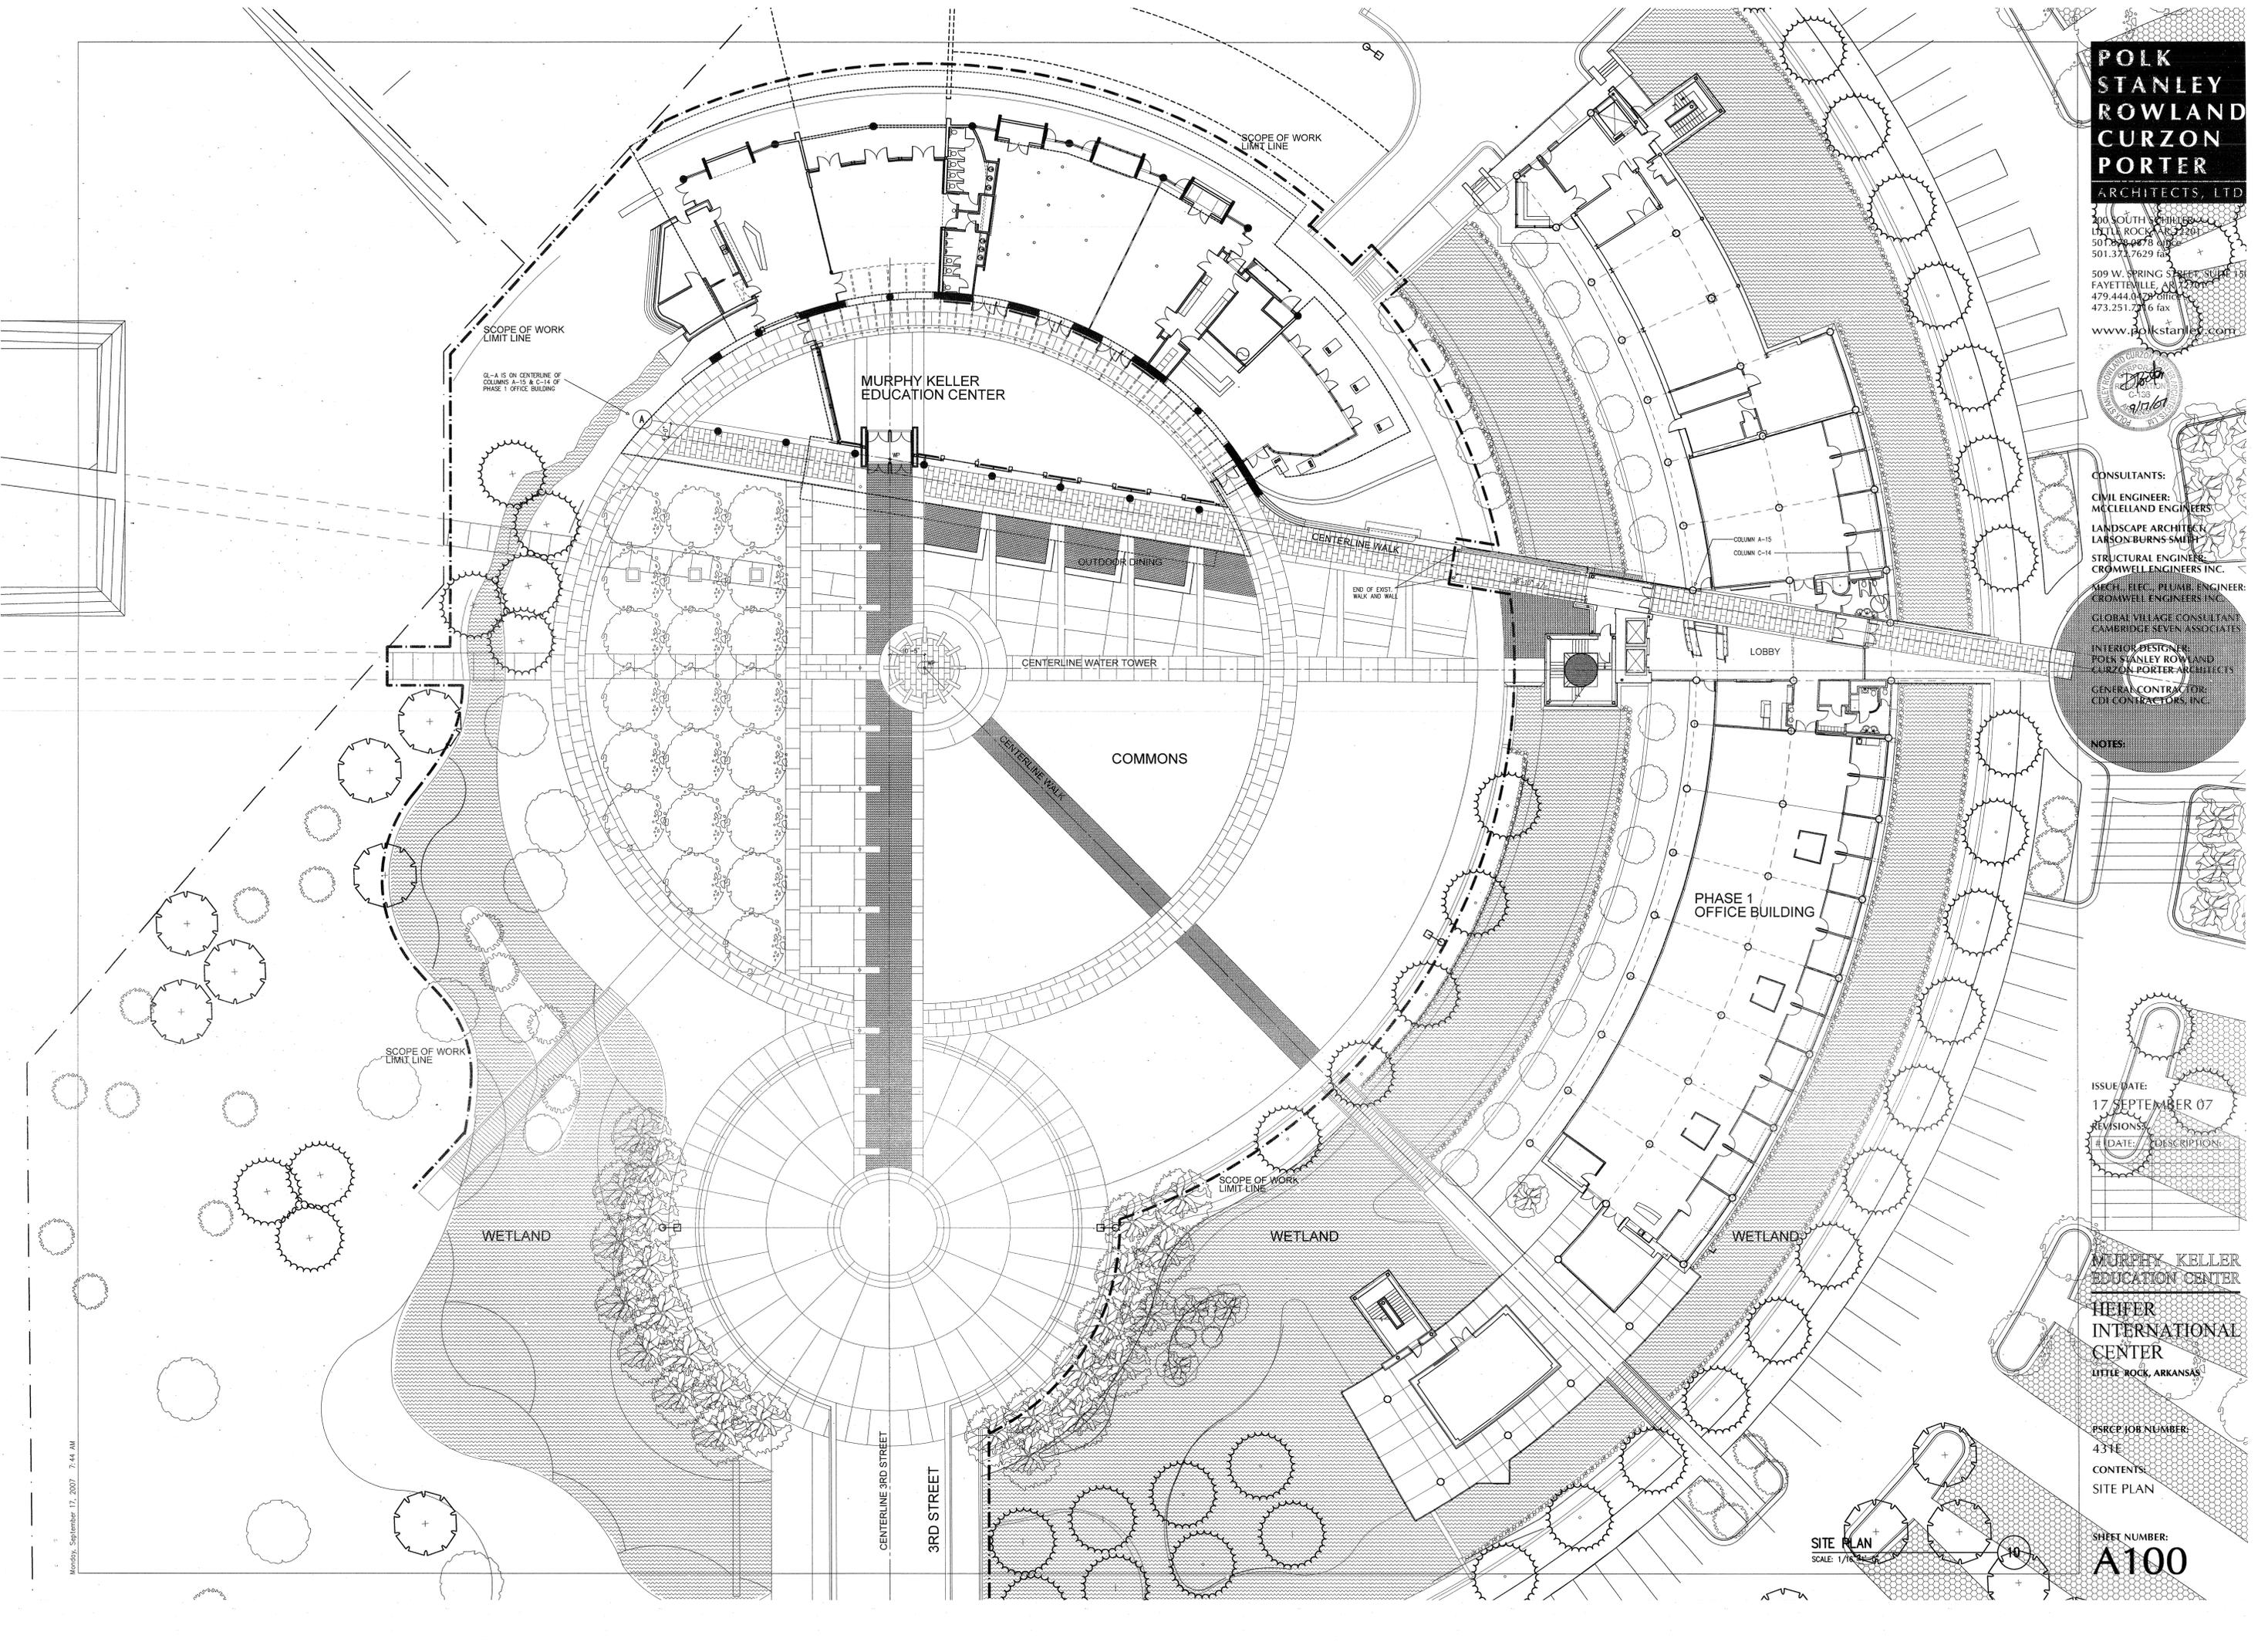

Monday, September 17, 2007 7:44 AM

700 SOUTH SCHILLER
LITTLE ROCK, AR 72201
501.378.0878 office
501.372.7629 fax

509 W. SPRING STREET, SUITE 150
FAYETTEVILLE, AR 72701
479.444.0473 office
473.251.7216 fax

www.polkstanley.com

CONSULTANTS:

CIVIL ENGINEER:
MCCLELLAND ENGINEERS

LANDSCAPE ARCHITECT:
LARSON BURNS SMITH

STRUCTURAL ENGINEER:
CROMWELL ENGINEERS INC.

MECH., ELEC., PLUMB. ENGINEER:
CROMWELL ENGINEERS INC.

GLOBAL VILLAGE CONSULTANT:
CAMBRIDGE SEVEN ASSOCIATES

INTERIOR DESIGNER:
POLK STANLEY ROWLAND
CURZON PORTER ARCHITECTS

GENERAL CONTRACTOR:
CDI CONTRACTORS, INC.

NOTES:

Blank lines for notes.

ISSUE DATE:
17 SEPTEMBER 07

REVISIONS:

#	DATE	DESCRIPTION
1	07 JAN 07	ASH NO. 01
2	14 FEB 08	ASH NO. 2
3	24 MAR 08	ASH NO. 4
4	30 JULY 08	ASH NO. 17
5	28 AUG 08	ASH NO. 20

**MURPHY KELLER
EDUCATION CENTER**

**HEIFER
INTERNATIONAL
CENTER**
LITTLE ROCK, ARKANSAS

PSRCP JOB NUMBER:


431E

CONTENTS:

FLOOR PLAN 5'-8 5/8"

SHEET NUMBER:

A101

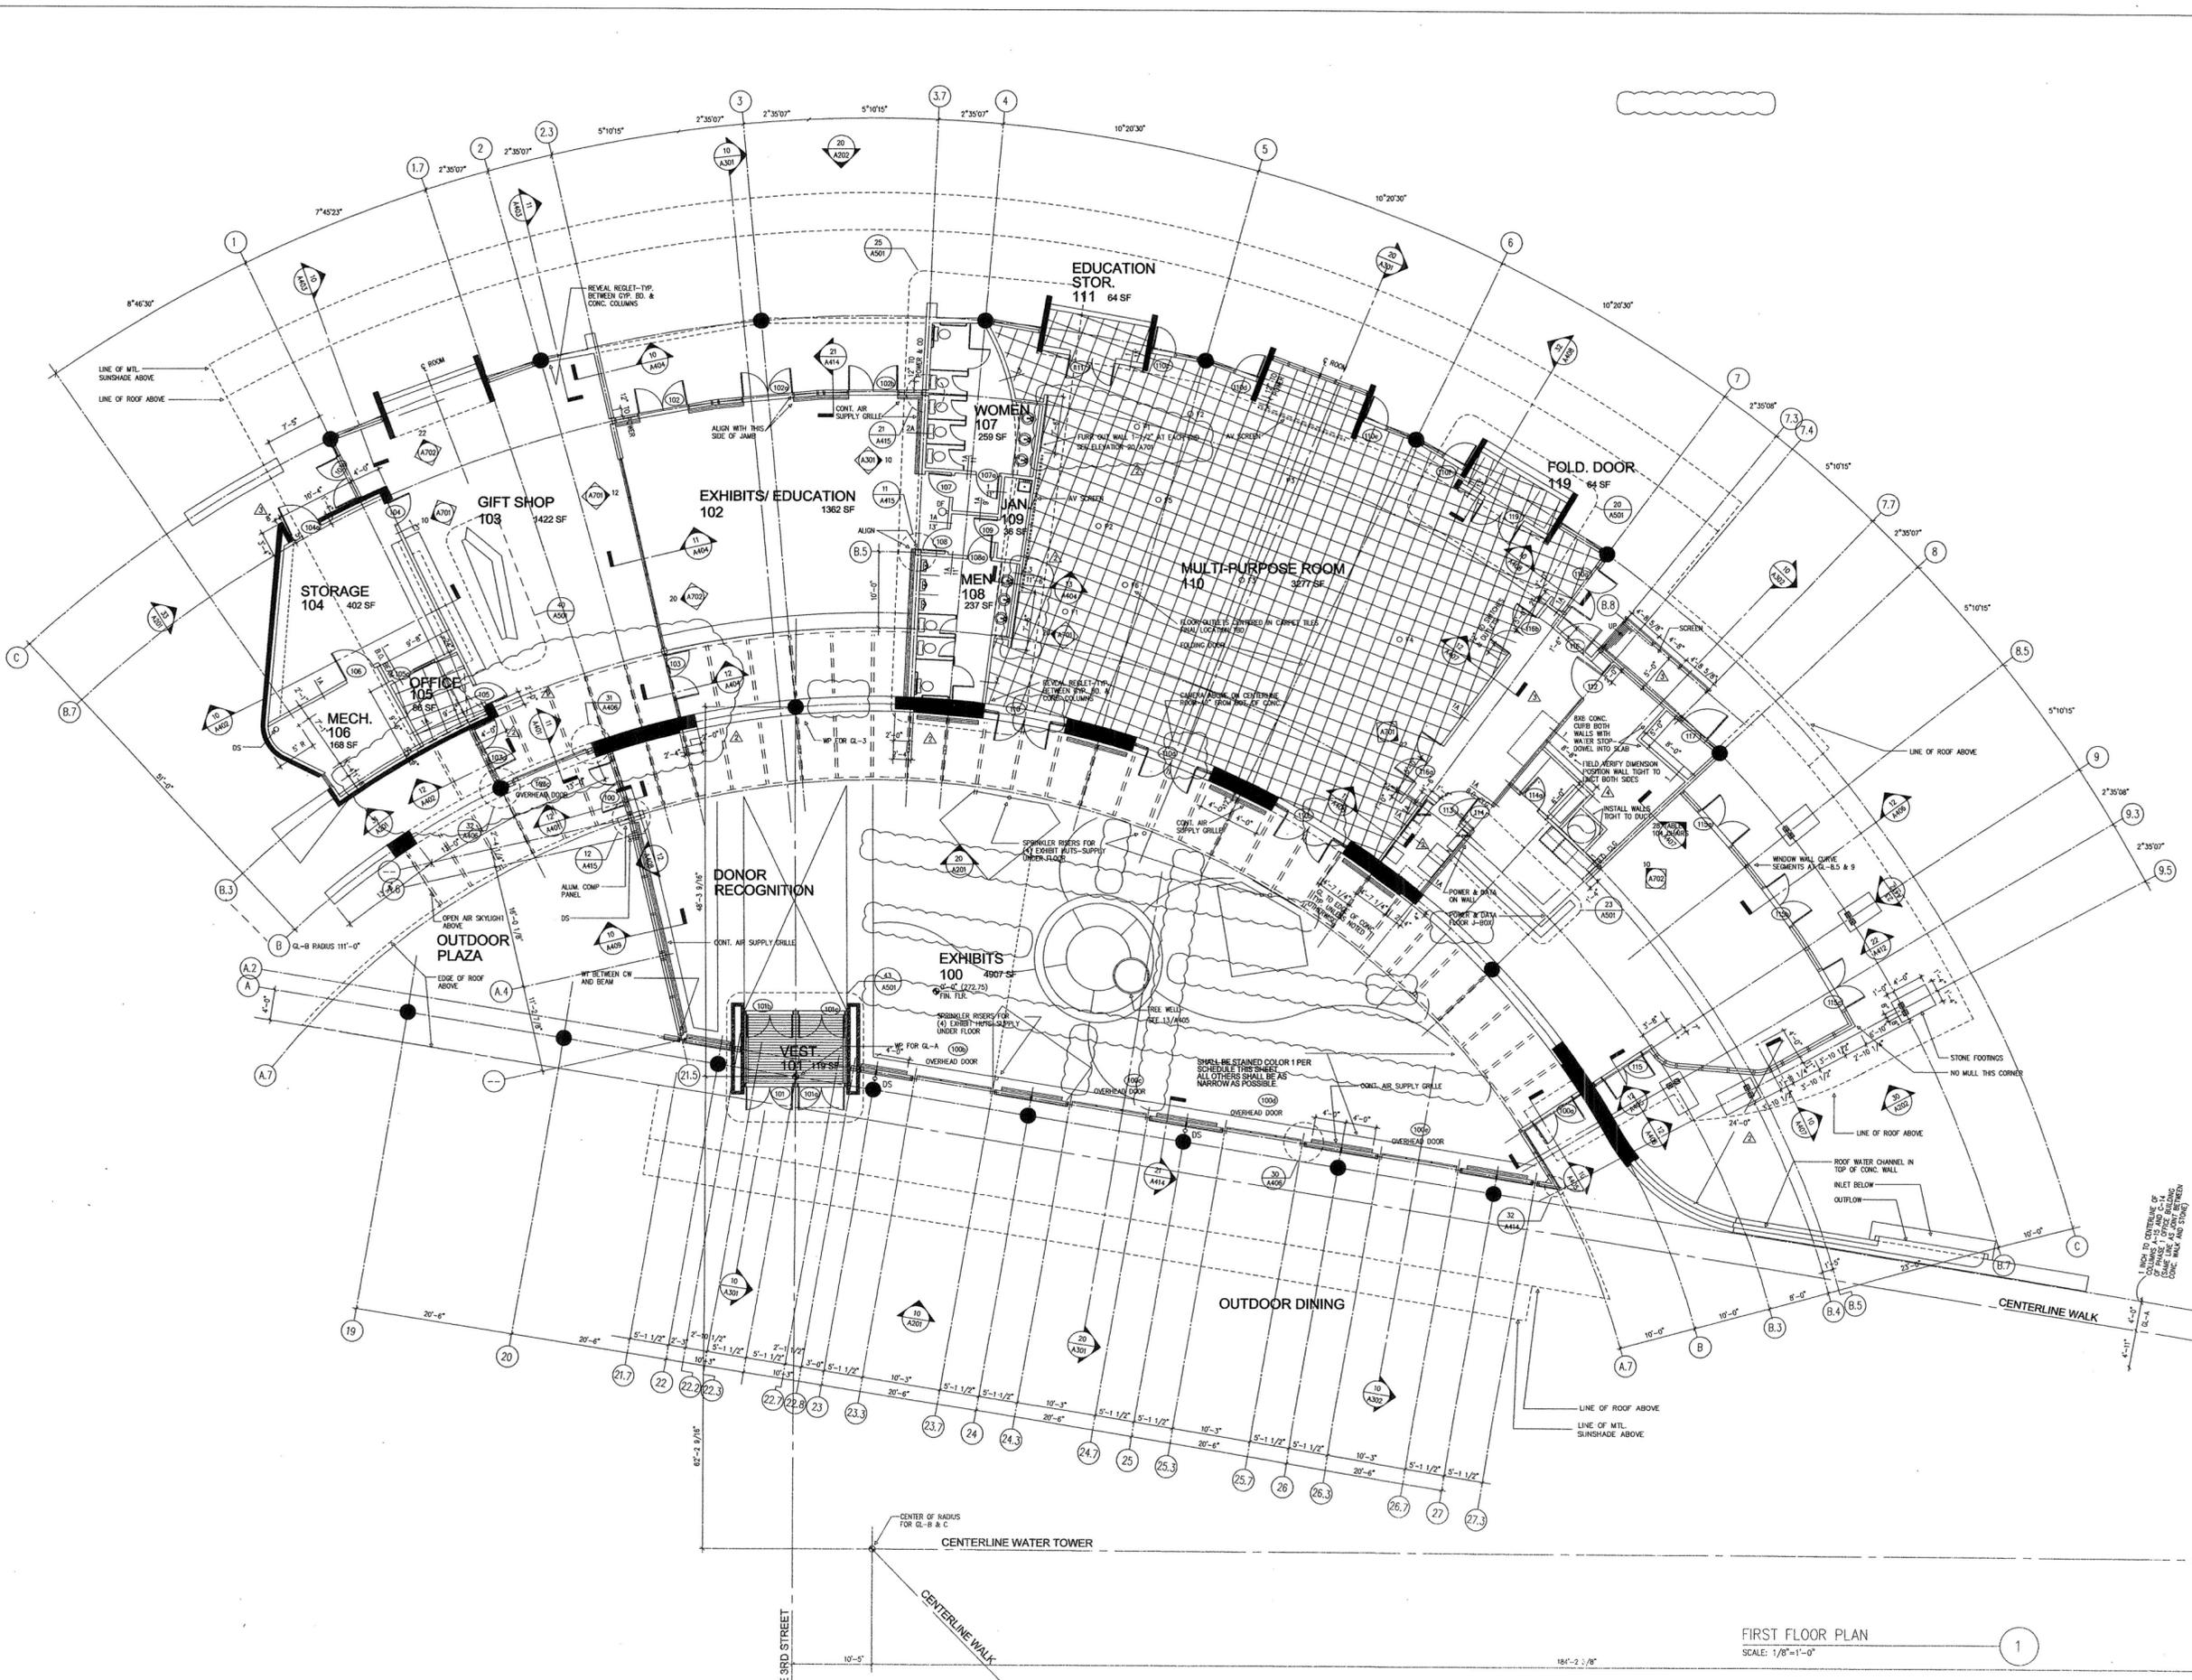

FIRST FLOOR PLAN
SCALE: 1/8"=1'-0"

1



CONSULTANTS:

- CIVIL ENGINEER:**
MCLELLAND ENGINEERS
- LANDSCAPE ARCHITECT:**
LARSON BURNS SMITH
- STRUCTURAL ENGINEER:**
CROMWELL ENGINEERS INC.
- MECH., ELEC., PLUMB. ENGINEER:**
CROMWELL ENGINEERS INC.
- GLOBAL VILLAGE CONSULTANT:**
CAMBRIDGE SEVEN ASSOCIATES
- INTERIOR DESIGNER:**
POLK STANLEY ROWLAND
CURZON PORTER ARCHITECTS
- GENERAL CONTRACTOR:**
CDI CONTRACTORS, INC.

NOTES:

ISSUE DATE:
17 SEPTEMBER 07

REVISIONS:

#	DATE:	DESCRIPTION:

**MURPHY KELLER
EDUCATION CENTER**

**HEIFER
INTERNATIONAL
CENTER**
LITTLE ROCK, ARKANSAS

PSRCP JOB NUMBER:


431E

CONTENTS:

MECHANICAL
MEZZANINE
FLOOR PLAN

SHEET NUMBER:

A101a

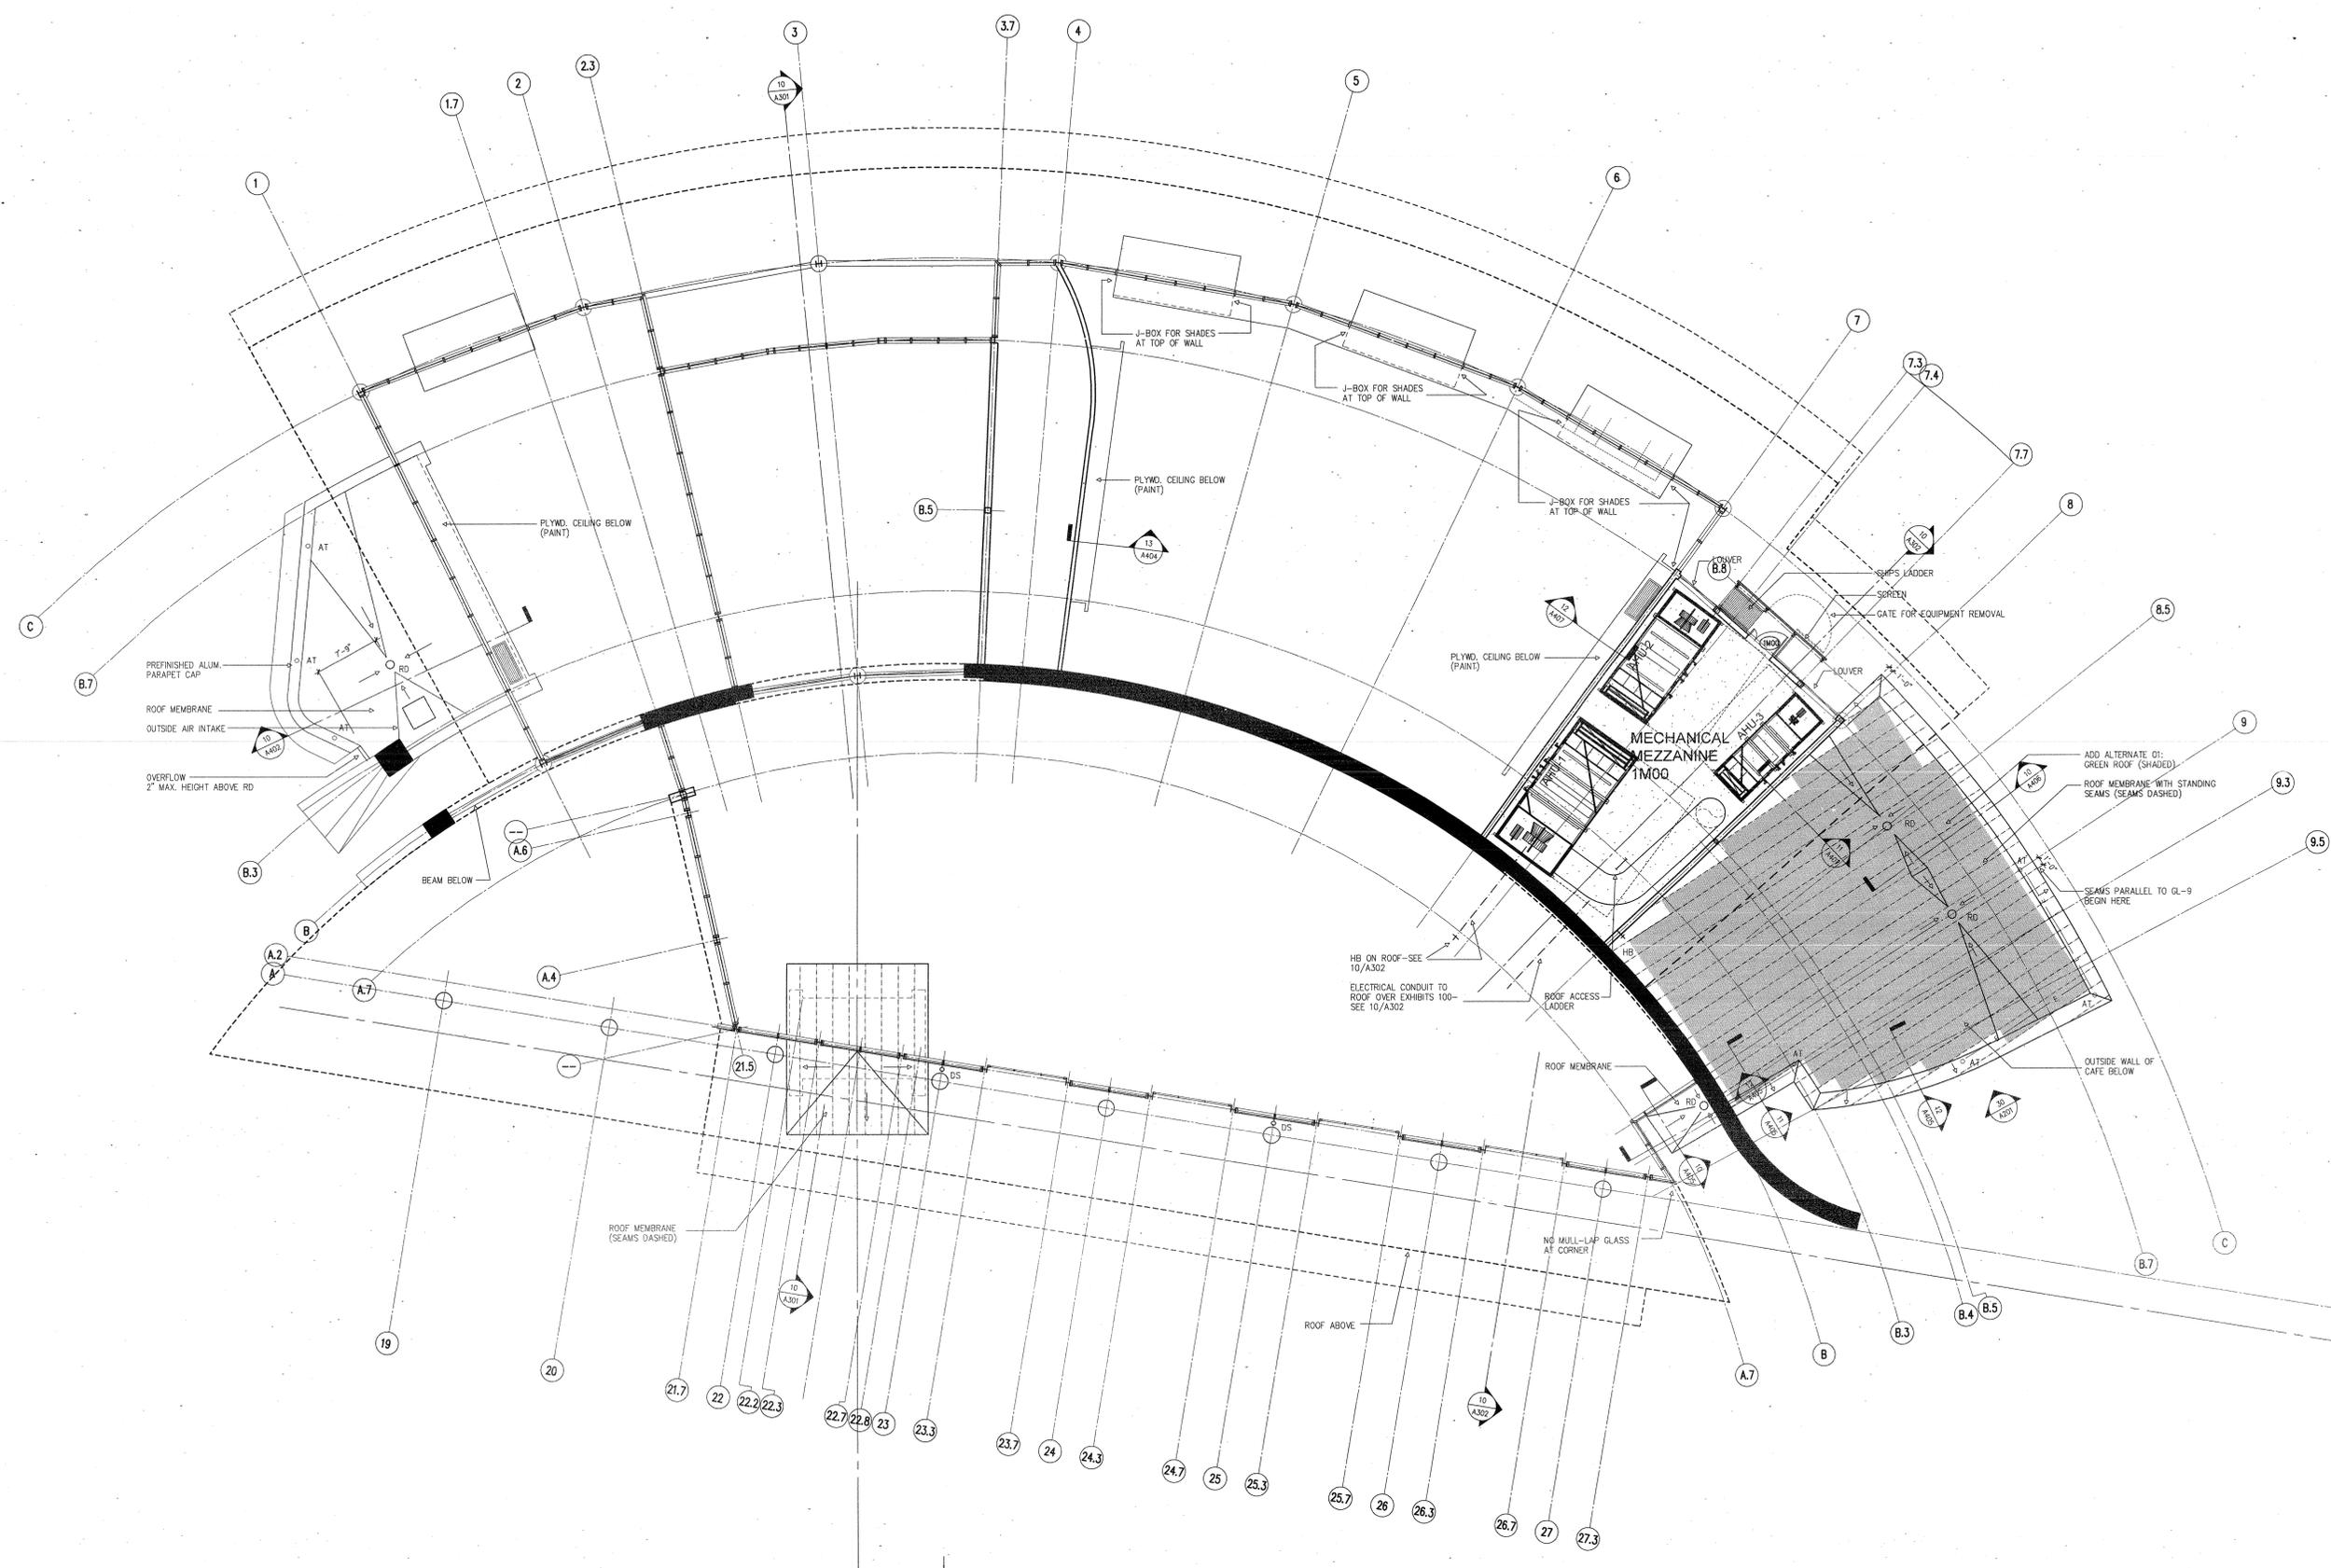

NOTE: ROOF IS VISIBLE FROM EXISTING 4 STORY OFFICE BUILDING AND MUST BE ORGANIZED AS SHOWN DUE TO ITS HIGH VISIBILITY. REVIEW LOCATION OF ALL DEVICES VISIBLE TO VIEW WITH ARCHITECT BEFORE INSTALLATION.
MECHANICAL MEZZANINE FLOOR PLAN 1
SCALE: 1/8"=1'-0"

700 SOUTH SCHILLER
LITTLE ROCK, AR 72201
501.378.0878 office
501.372.7629 fax

509 W. SPRING STREET, SUITE 150
FAYETTEVILLE, AR 72701
479.444.0473 office
473.251.7216 fax

www.polkstanley.com



CONSULTANTS:

CIVIL ENGINEER:
MCLELLAND ENGINEERS

LANDSCAPE ARCHITECT:
LARSON BURNS SMITH

STRUCTURAL ENGINEER:
CROMWELL ENGINEERS INC.

MECH., ELEC., PLUMB. ENGINEER:
CROMWELL ENGINEERS INC.

GLOBAL VILLAGE CONSULTANT
CAMBRIDGE SEVEN ASSOCIATES

INTERIOR DESIGNER:
POLK STANLEY ROWLAND
CURZON PORTER ARCHITECTS

GENERAL CONTRACTOR:
CDI CONTRACTORS, INC.

NOTES:

ISSUE DATE:
17 SEPTEMBER 07

REVISIONS:

#	DATE	DESCRIPTION
1	07 JAN 07	ASH NO. 01
2	07 MAY 08	ASH NO. 13

MURPHY KELLER
EDUCATION CENTER


HEIFER
INTERNATIONAL
CENTER

LITTLE ROCK, ARKANSAS

PSRCP JOB NUMBER:
431E

CONTENTS:
ROOF PLAN

SHEET NUMBER:
A102

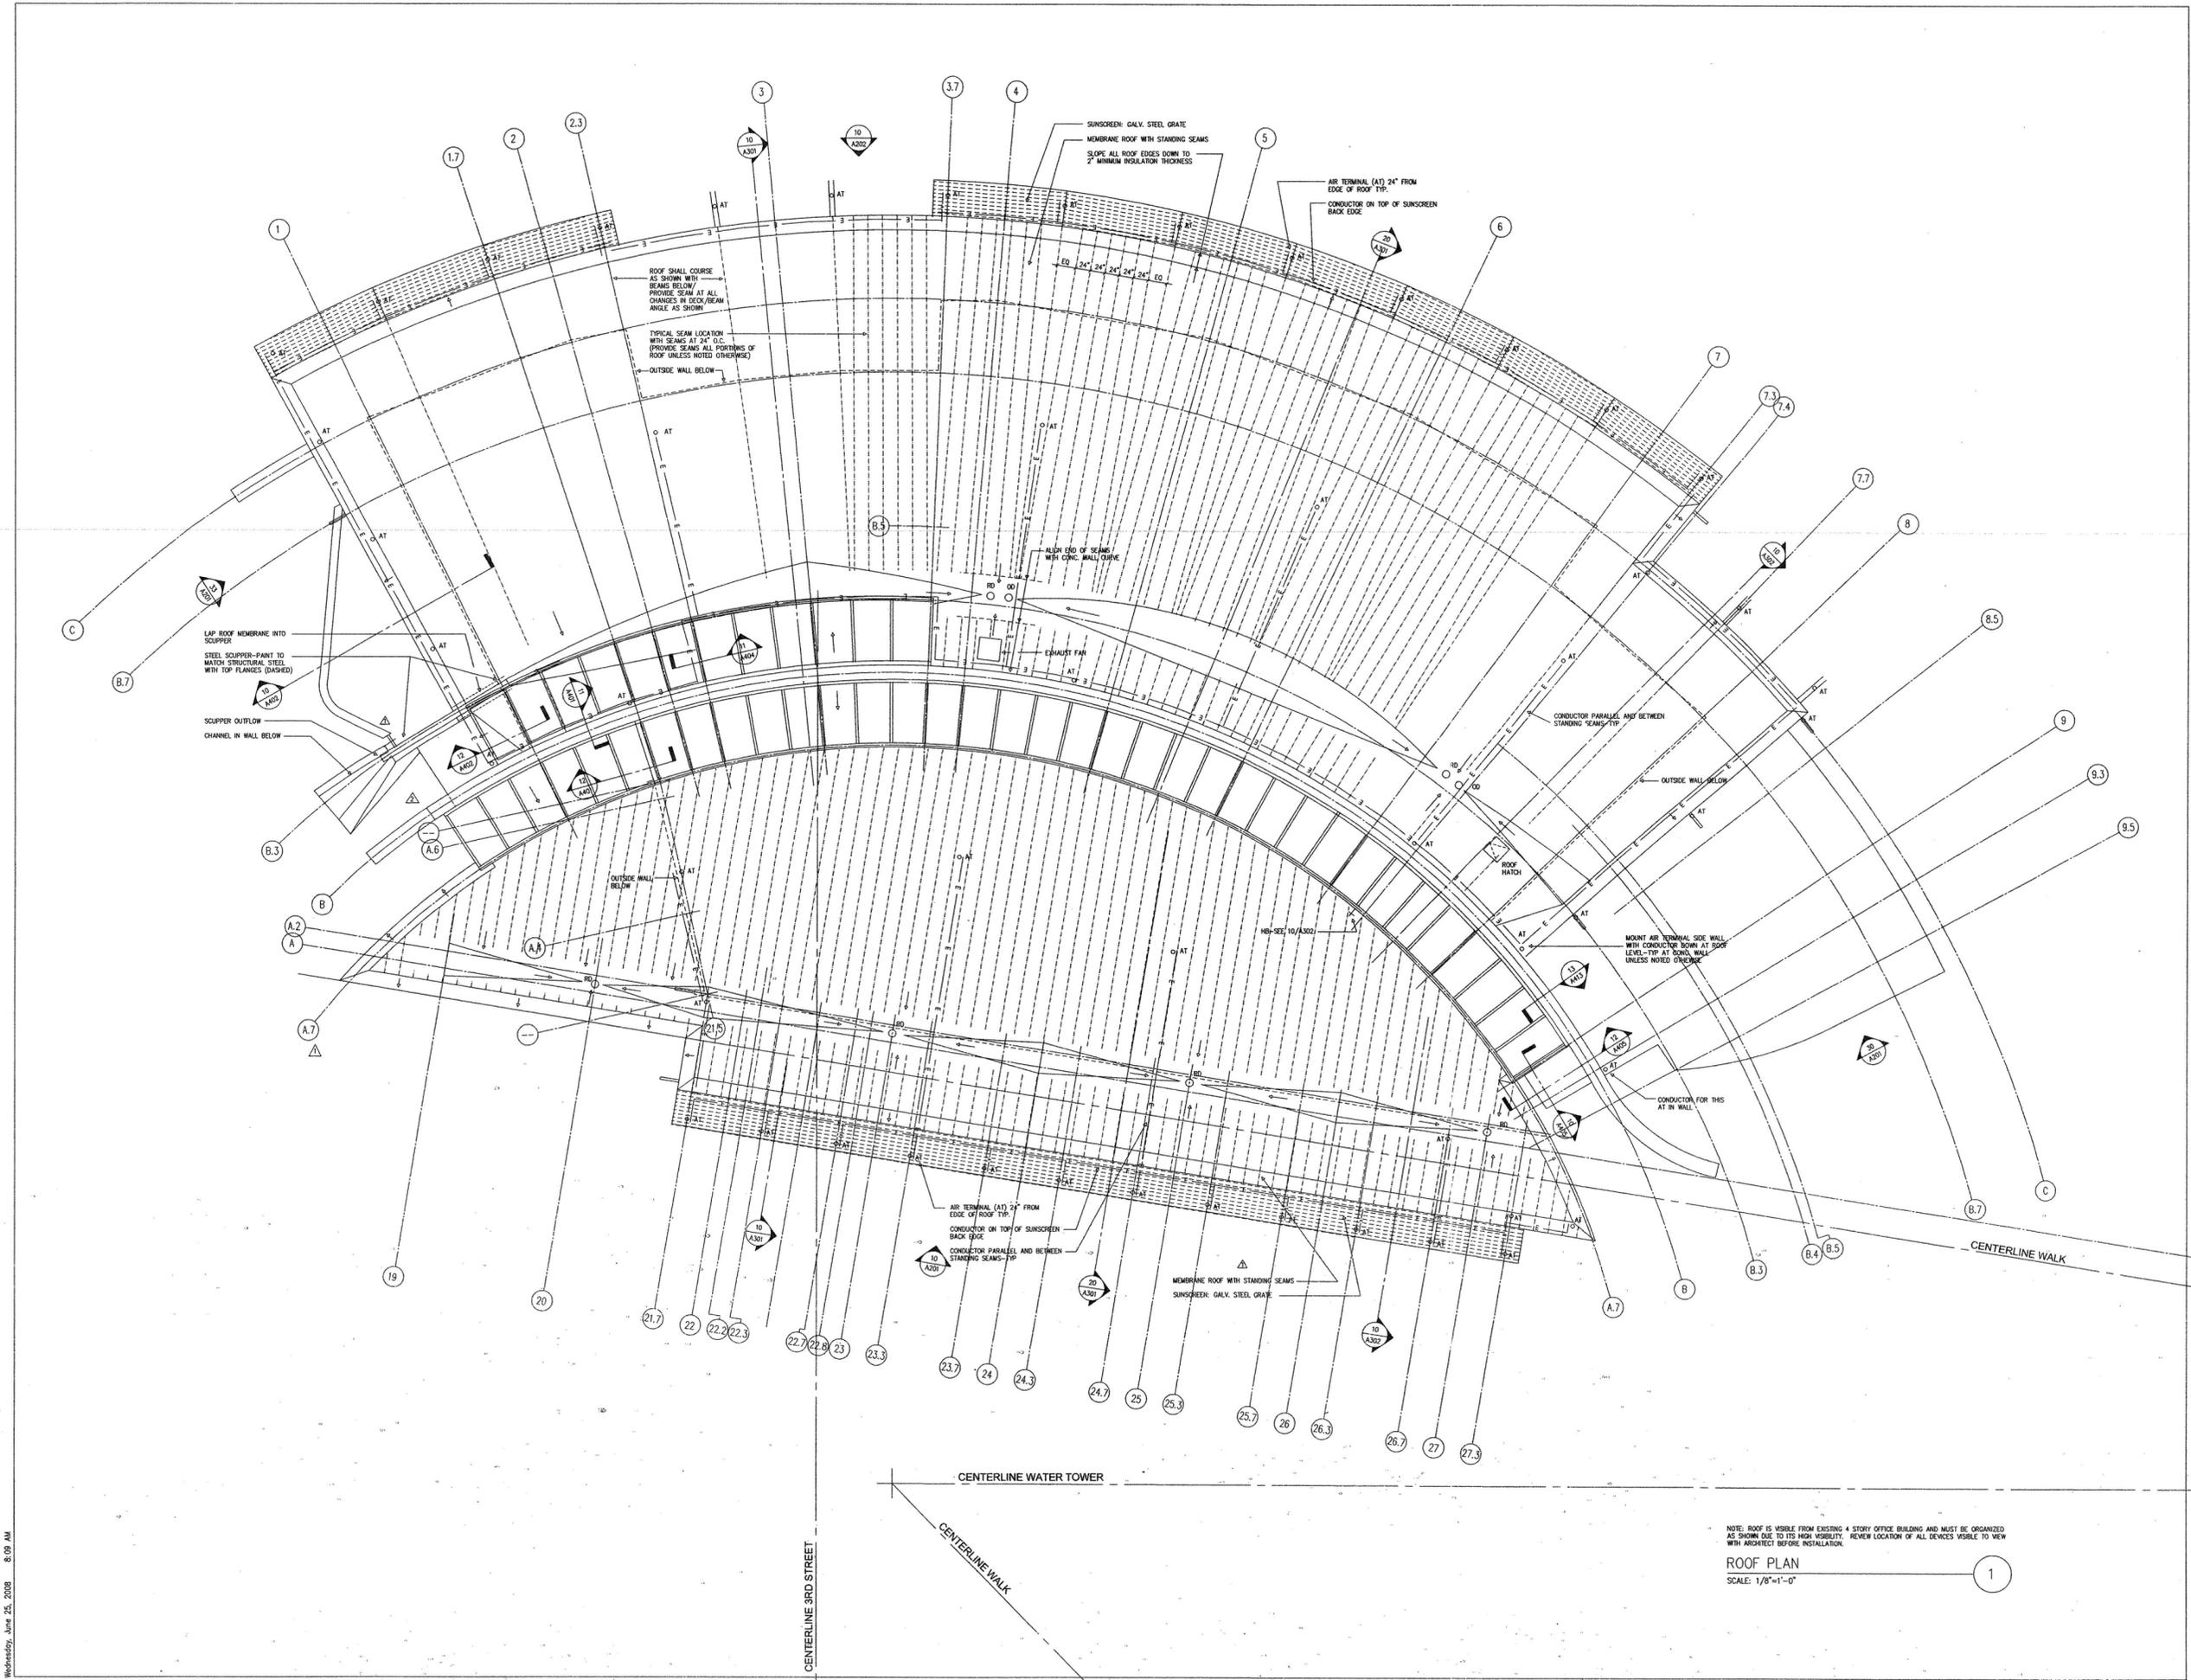

NOTE: ROOF IS VISIBLE FROM EXISTING 4 STORY OFFICE BUILDING AND MUST BE ORGANIZED AS SHOWN DUE TO ITS HIGH VISIBILITY. REVIEW LOCATION OF ALL DEVICES VISIBLE TO VIEW WITH ARCHITECT BEFORE INSTALLATION.

ROOF PLAN
SCALE: 1/8"=1'-0"



CONSULTANTS:
CIVIL ENGINEER:
MCCLELLAND ENGINEERS
LANDSCAPE ARCHITECT:
LARSON BURNS SMITH
STRUCTURAL ENGINEER:
CROMWELL ENGINEERS INC.
MECH., ELEC., PLUMB. ENGINEER:
CROMWELL ENGINEERS INC.
GLOBAL VILLAGE CONSULTANT
CAMBRIDGE SEVEN ASSOCIATES
INTERIOR DESIGNER:
POLK STANLEY ROWLAND
CURZON PORTER ARCHITECTS
GENERAL CONTRACTOR:
CDI CONTRACTORS, INC.

NOTES:
1. ALL GLAZED WALL SYSTEMS SHALL BE ALUMINUM
STOREFRONT UNLESS NOTED OTHERWISE
2. ALL GLAZING SHALL BE CLEAR INSULATED TYPE (I)
UNLESS NOTED OTHERWISE
3. SEE GENERAL FINISH NOTES ON A801 FOR
EXTERIOR FINISHES

ISSUE DATE:
17 SEPTEMBER 07

REVISIONS:


#	DATE	DESCRIPTION:
1	07 JAN 08	ASH NO. 1
2	24 MAR 08	ASH NO. 4
4	25 APR 08	ASH NO. 10
3	07 MAY 08	ASH NO. 13

**MURPHY KELLER
EDUCATION CENTER**

**HEIFER
INTERNATIONAL
CENTER**
LITTLE ROCK, ARKANSAS

PRSCP JOB NUMBER:
431E
CONTENTS:
BUILDING ELEVATIONS

SHEET NUMBER:
A201

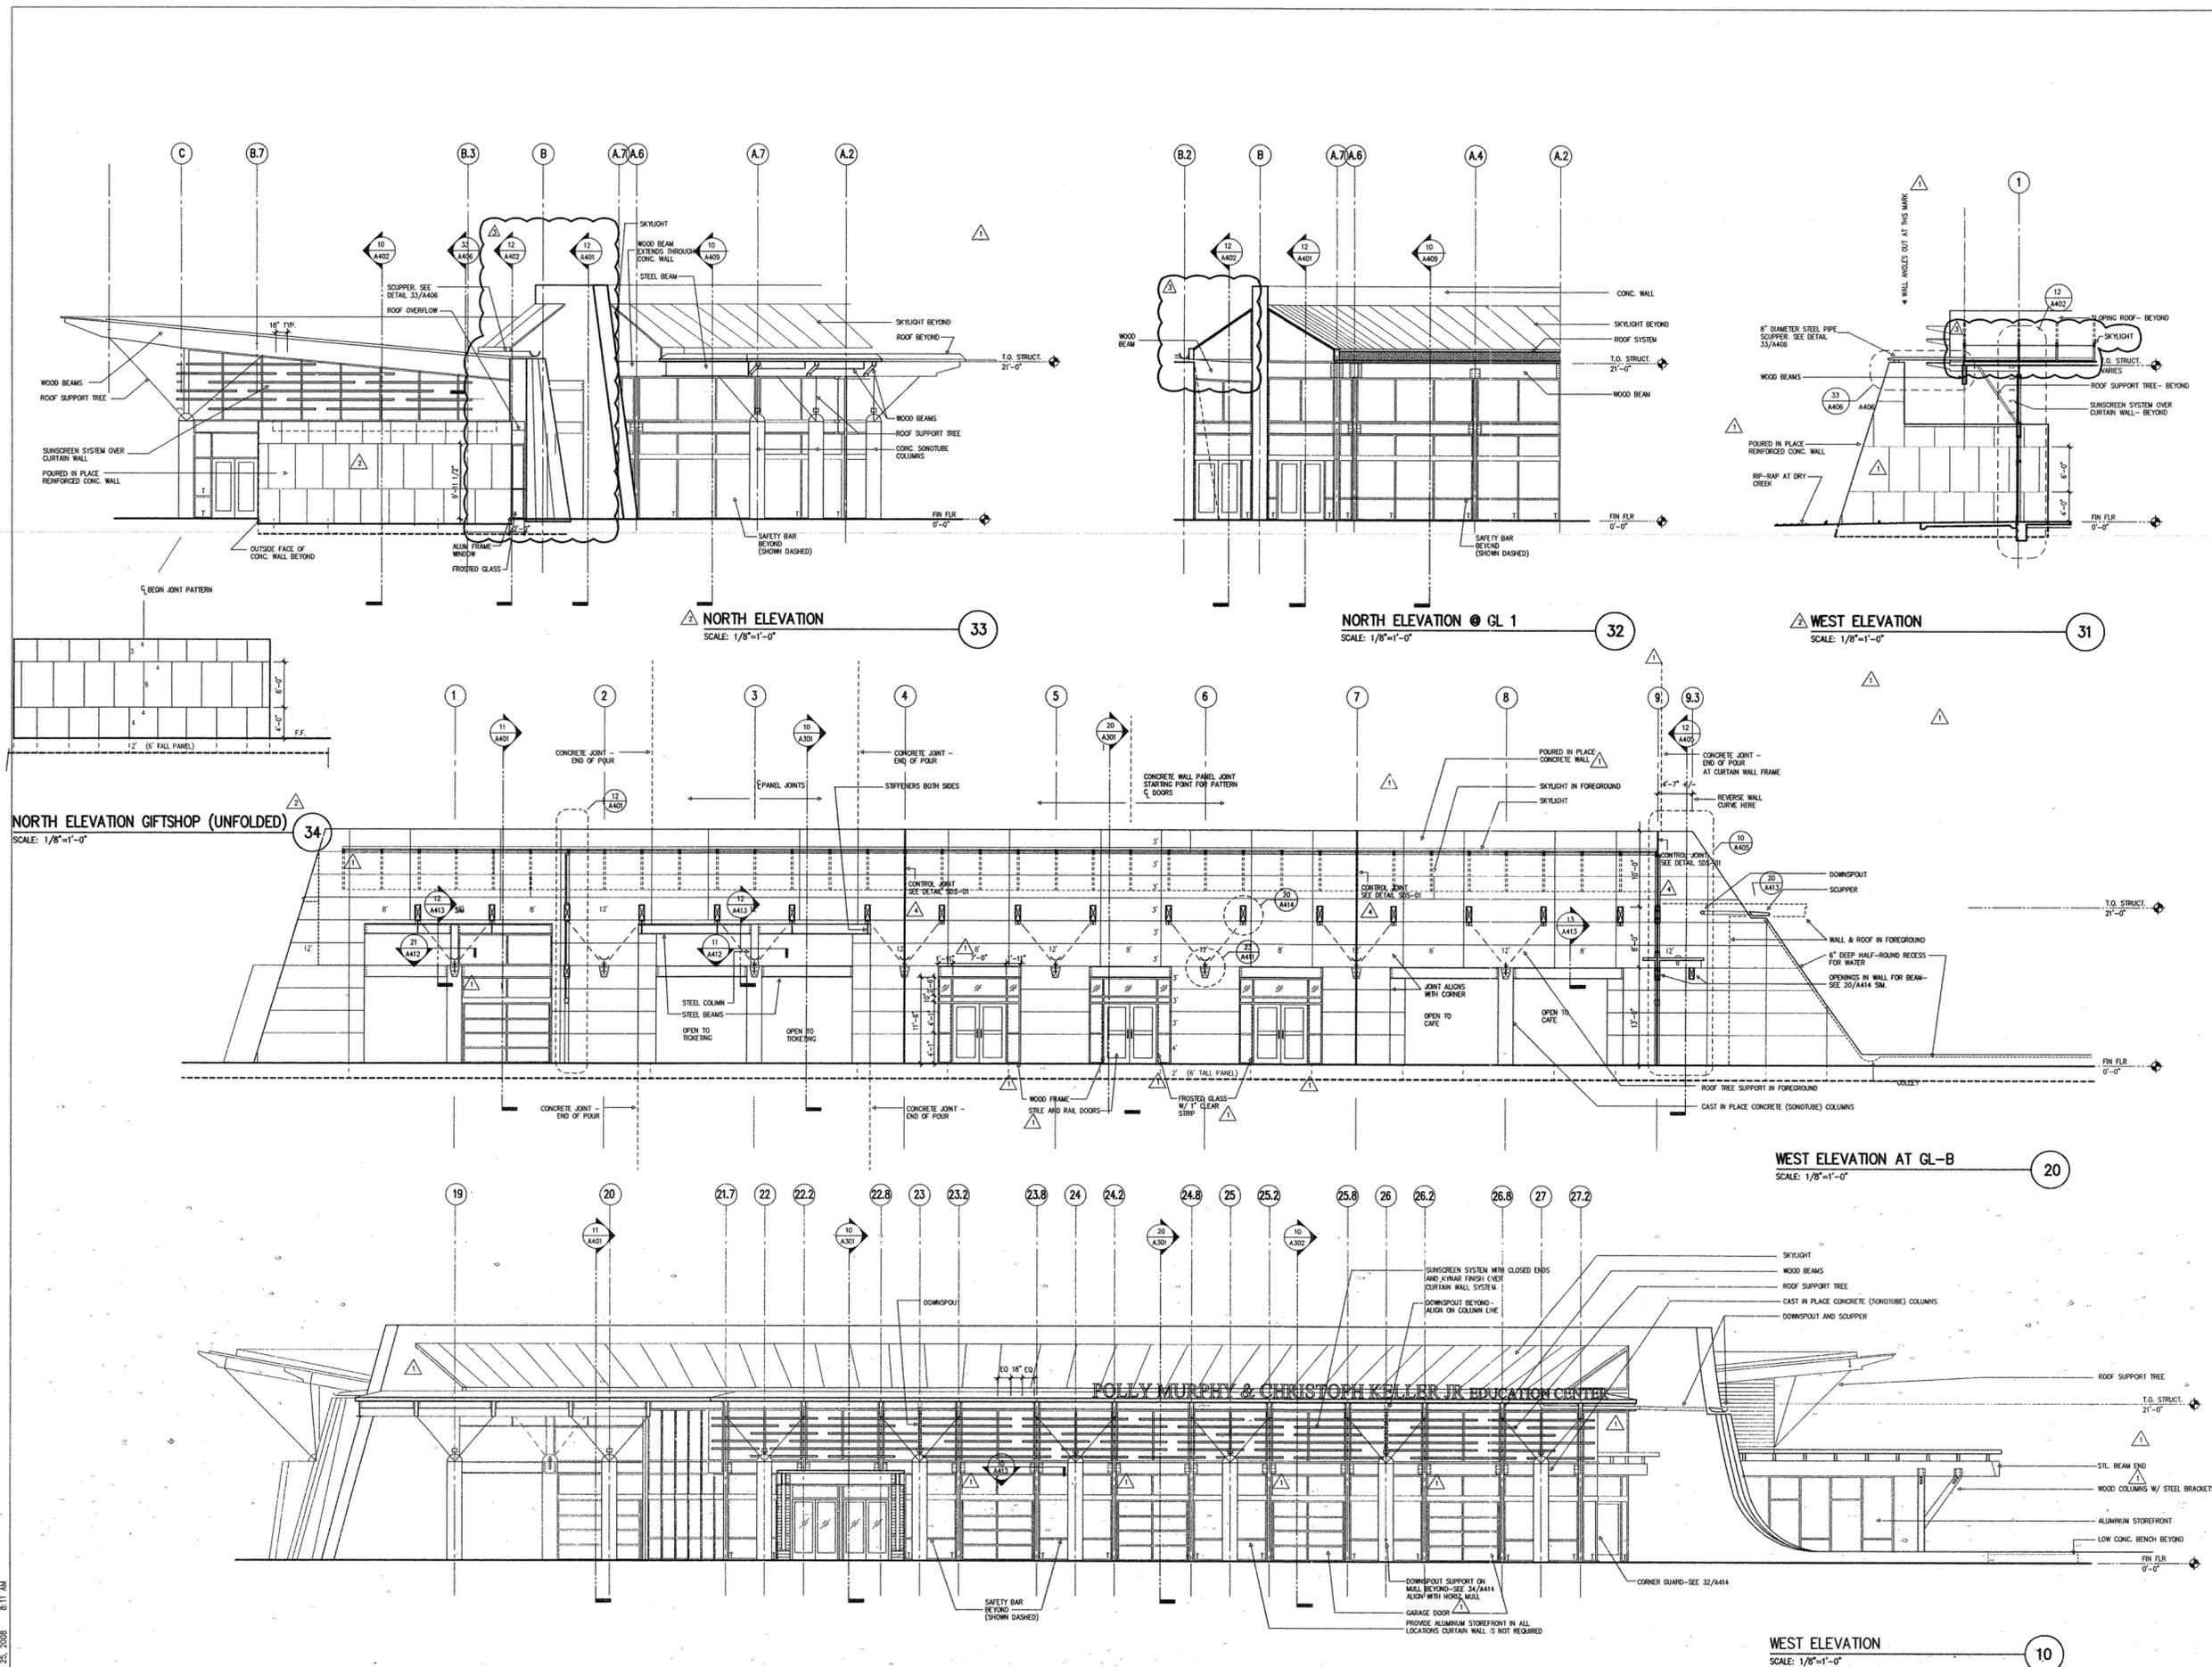

Wednesday, Jan 23, 2008 8:11 AM
 W:\Projects\431E\A201.dwg



CONSULTANTS:

- CIVIL ENGINEER:
MCLELLAND ENGINEERS
- LANDSCAPE ARCHITECT:
LARSON BURNS SMITH
- STRUCTURAL ENGINEER:
CROMWELL ENGINEERS INC.
- MECH., ELEC., PLUMB. ENGINEER
CROMWELL ENGINEERS INC.
- GLOBAL VILLAGE CONSULTANT
CAMBRIDGE SEVEN ASSOCIATES
- INTERIOR DESIGNER:
POLK STANLEY ROWLAND
CURZON PORTER ARCHITECTS
- GENERAL CONTRACTOR:
CDI CONTRACTORS, INC.

NOTES:

1. ALL GLAZED WALL SYSTEMS SHALL BE ALUMINUM STOREFRONT UNLESS NOTED OTHERWISE
2. ALL GLAZING SHALL BE CLEAR INSULATED TYPE (I) UNLESS NOTED OTHERWISE
3. SEE GENERAL FINISH NOTES ON A301 FOR EXTERIOR FINISHES

T.O. CONC. WALL
31'-0"


T.O. STRUCT.
21'-0"

FIN. FLOOR
0'-0"

ISSUE DATE:
17 SEPTEMBER 07

REVISIONS:

#	DATE	DESCRIPTION

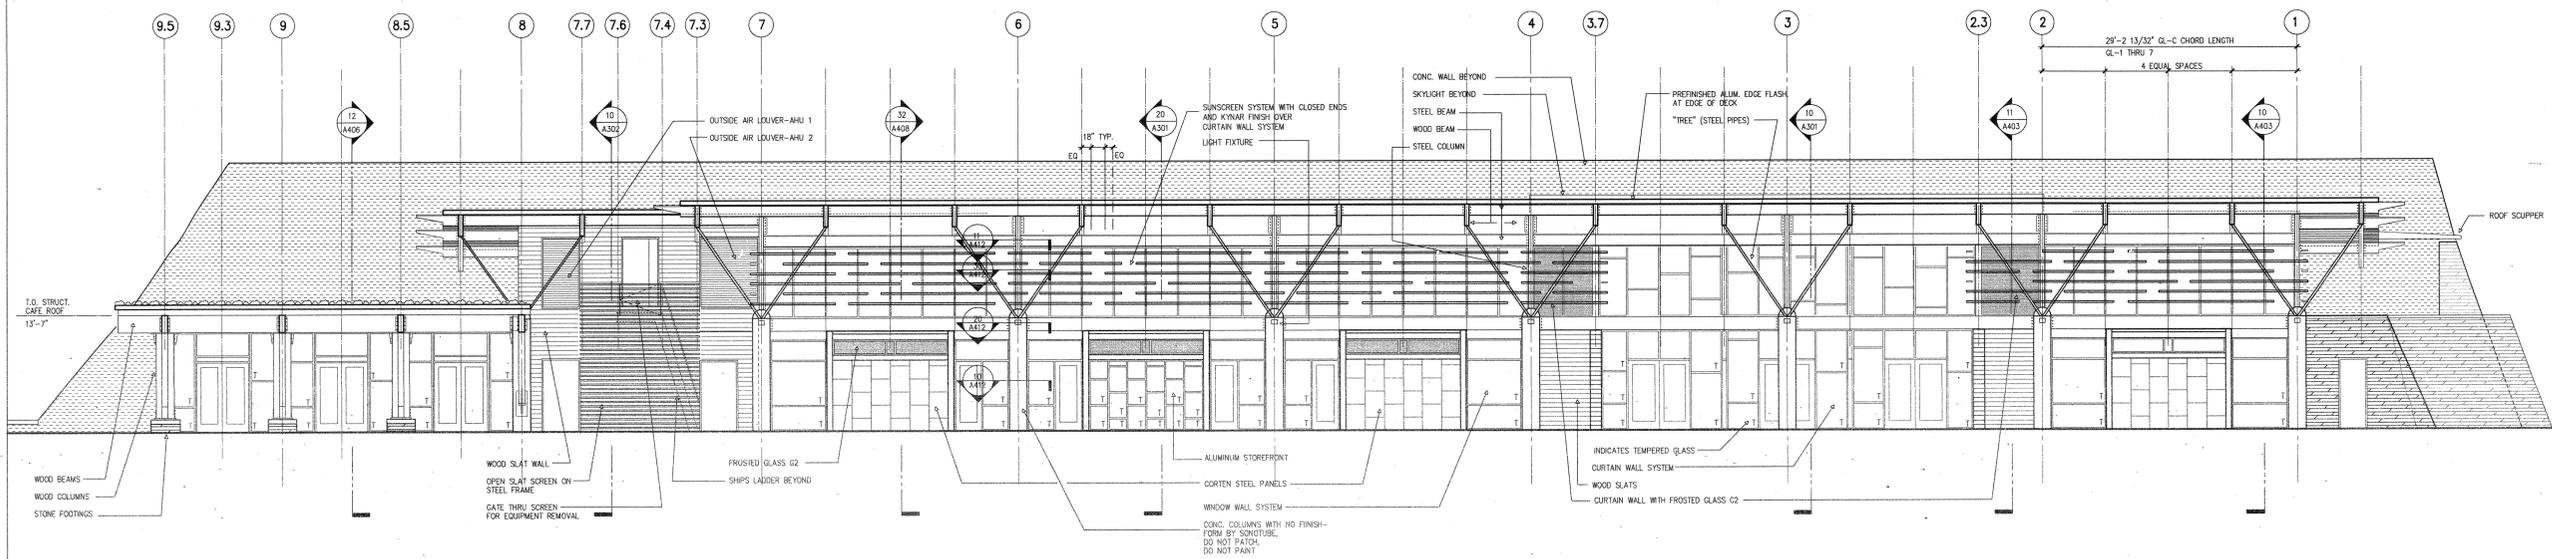

NOTE: SEE 20/A201 FOR WALL FORMWORK
EAST ELEVATION (FLAT)
SCALE: 1/8"=1'-0"

20

MURPHY KELLER
EDUCATION CENTER

HEIFER
INTERNATIONAL
CENTER
LITTLE ROCK, ARKANSAS

PSRCP JOB NUMBER:
431E

CONTENTS:
BUILDING ELEVATIONS

SHEET NUMBER:
A202



CONSULTANTS:

CIVIL ENGINEER:
MCCELLEND ENGINEERS

LANDSCAPE ARCHITECT:
LARSON BURNS SMITH

STRUCTURAL ENGINEER:
CROMWELL ENGINEERS INC.

MECH., ELEC., PLUMB. ENGINEER:
CROMWELL ENGINEERS INC.

GLOBAL VILLAGE CONSULTANT
CAMBRIDGE SEVEN ASSOCIATES

INTERIOR DESIGNER:
POLK STANLEY ROWLAND
CURZON PORTER ARCHITECTS

GENERAL CONTRACTOR:
CDI CONTRACTORS, INC.

NOTES:

- _____
- _____
- _____
- _____
- _____
- _____
- _____
- _____

ISSUE DATE:
17 SEPTEMBER 07

REVISIONS:

#	DATE	DESCRIPTION
1	07 JAN 08	ASI NO. 1
2	07 MAY 08	ASI NO. 13


**MURPHY KELLER
EDUCATION CENTER**

**HEIFER
INTERNATIONAL
CENTER**
LITTLE ROCK, ARKANSAS


PSRCP JOB NUMBER:
431E

CONTENTS:
WALL SECTIONS


SHEET NUMBER:
A401

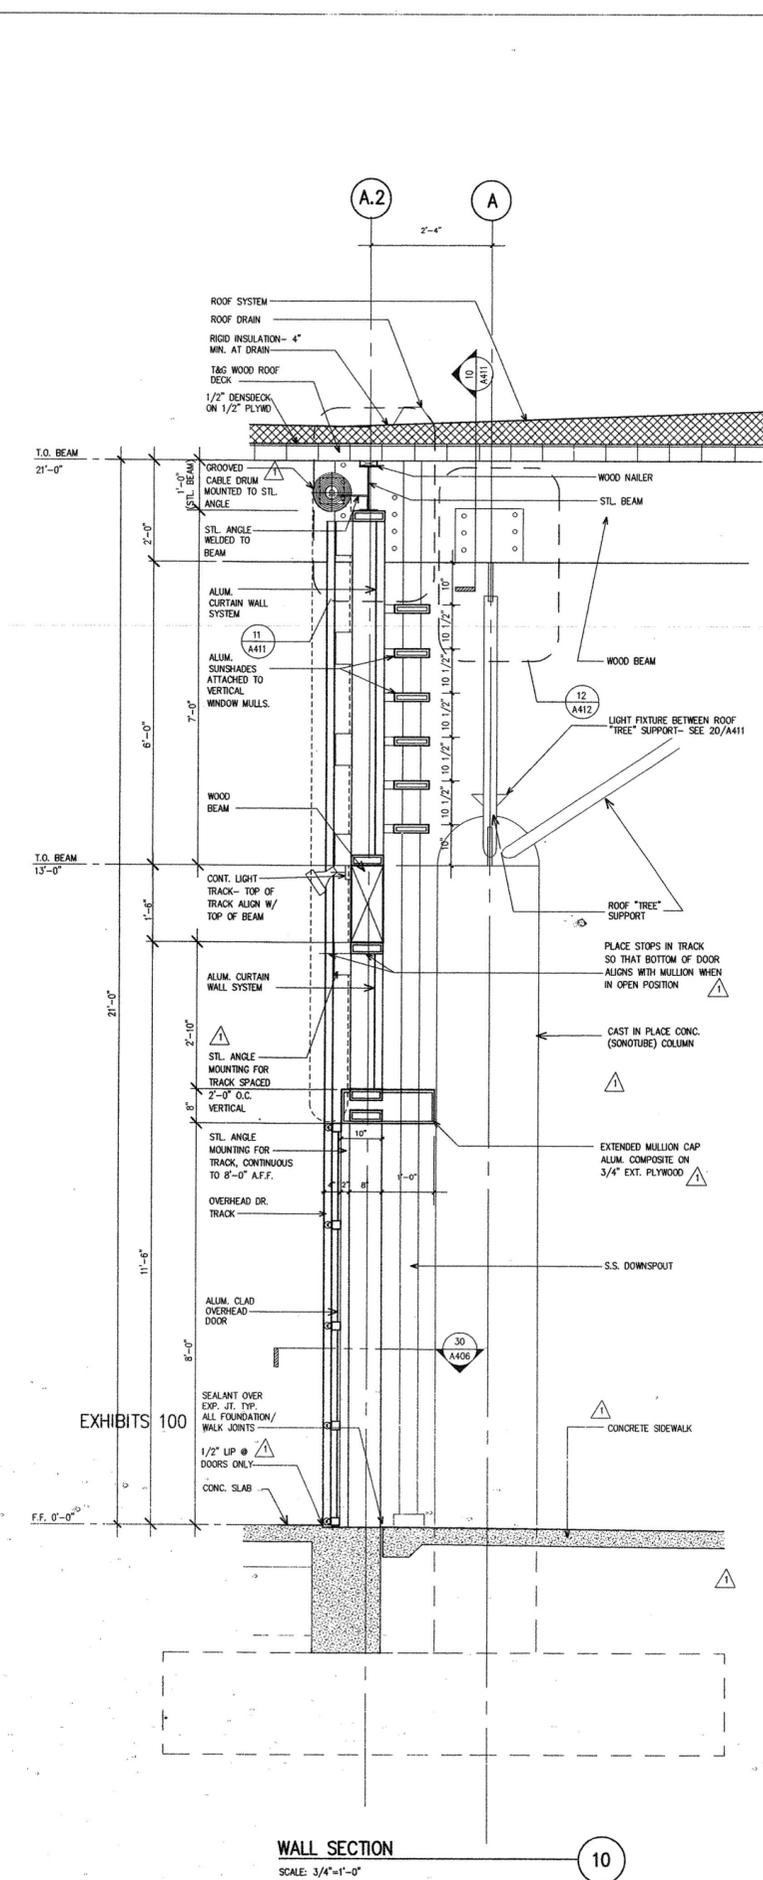

WALL SECTION 10
SCALE: 3/4"=1'-0"

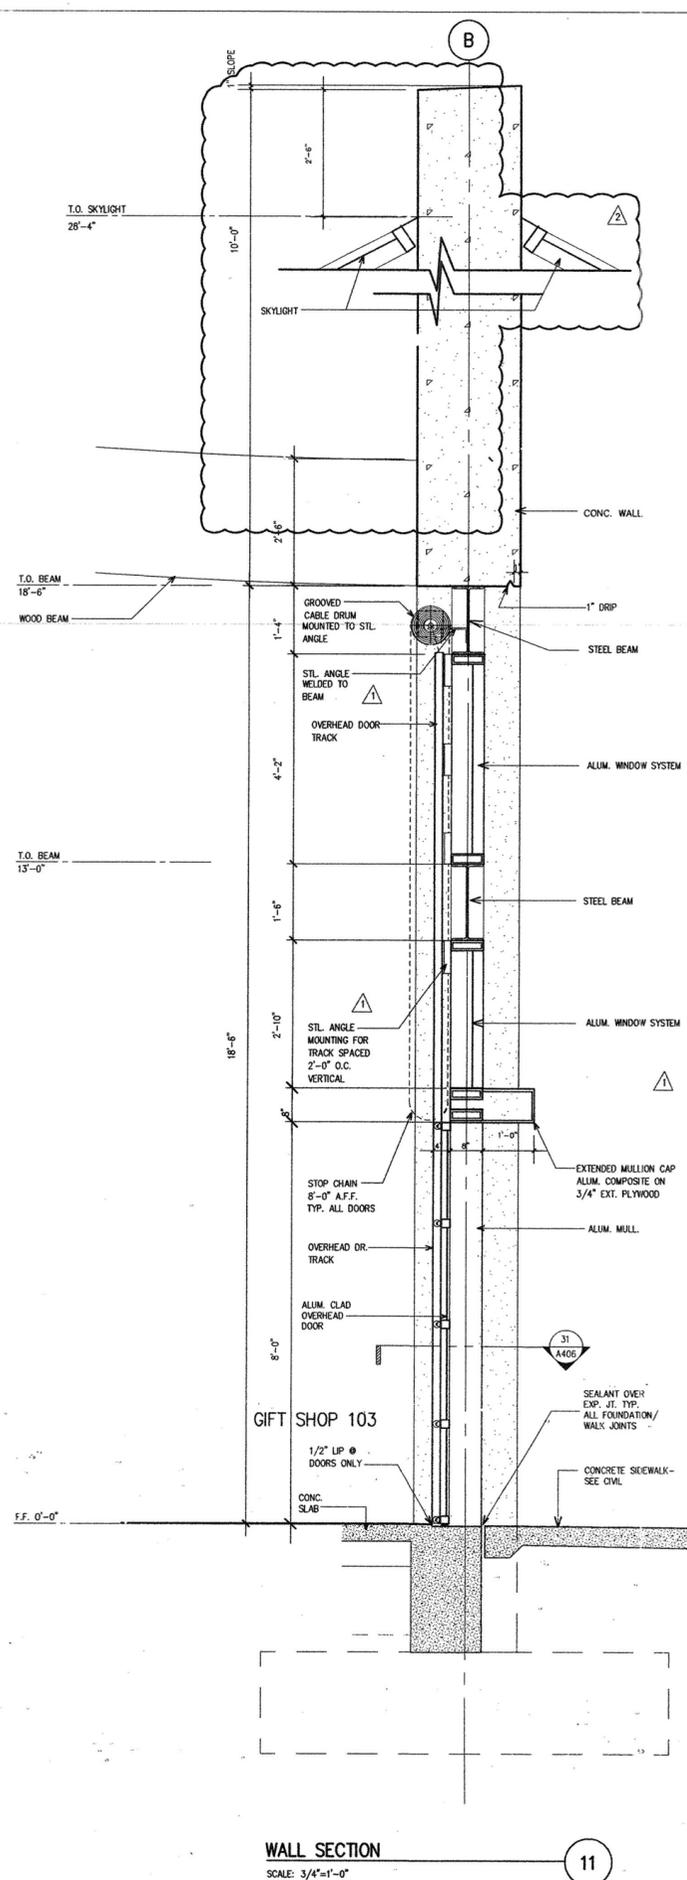

WALL SECTION 11
SCALE: 3/4"=1'-0"

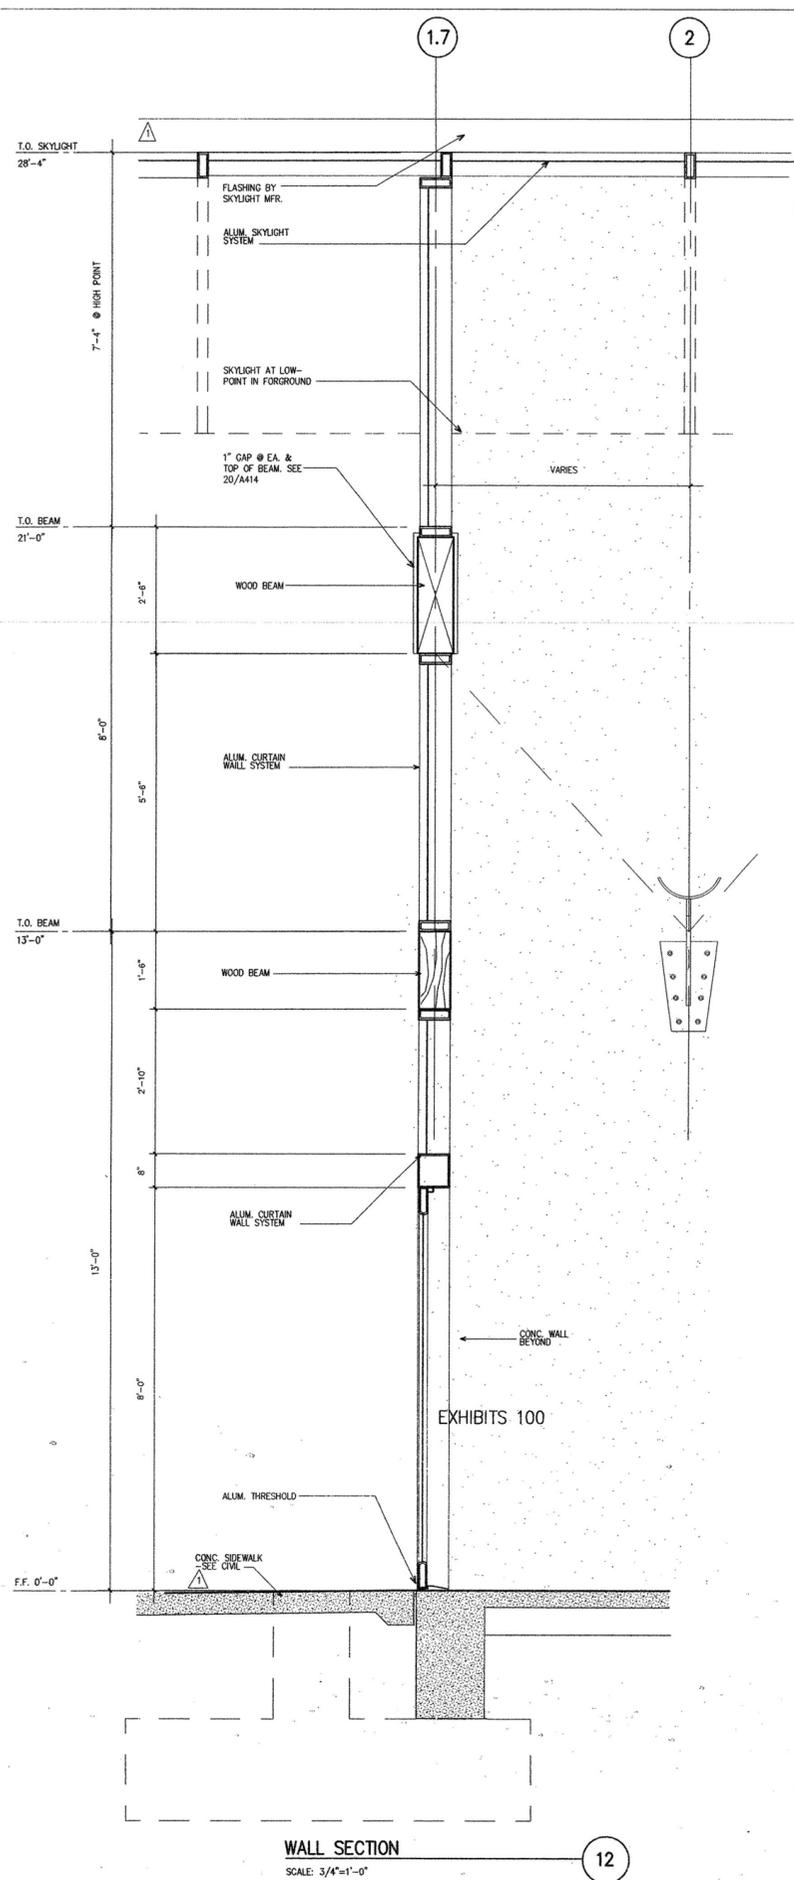

WALL SECTION 12
SCALE: 3/4"=1'-0"



CONSULTANTS:

- CIVIL ENGINEER:
MCCELLEND ENGINEERS
- LANDSCAPE ARCHITECT:
LARSON BURNS SMITH
- STRUCTURAL ENGINEER:
CROMWELL ENGINEERS INC.
- MECH., ELEC., PLUMB. ENGINEER
CROMWELL ENGINEERS INC.
- GLOBAL VILLAGE CONSULTANT
CAMBRIDGE SEVEN ASSOCIATES
- INTERIOR DESIGNER:
POLK STANLEY ROWLAND
CURZON PORTER ARCHITECTS
- GENERAL CONTRACTOR:
CDI CONTRACTORS, INC.

NOTES:

- _____
- _____
- _____
- _____
- _____
- _____
- _____
- _____

ISSUE DATE:
17 SEPTEMBER 07

REVISIONS:

#	DATE	DESCRIPTION
1	07 JAN 08	AS NO. 1
2	01 MARCH 08	AS NO. 3
3	07 MAY 08	AS NO. 13

**MURPHY KELLER
EDUCATION CENTER**

**HEIFER
INTERNATIONAL
CENTER**

LITTLE ROCK, ARKANSAS

PSRCP JOB NUMBER:


431E

CONTENTS:

WALL SECTIONS


SHEET NUMBER:

A402

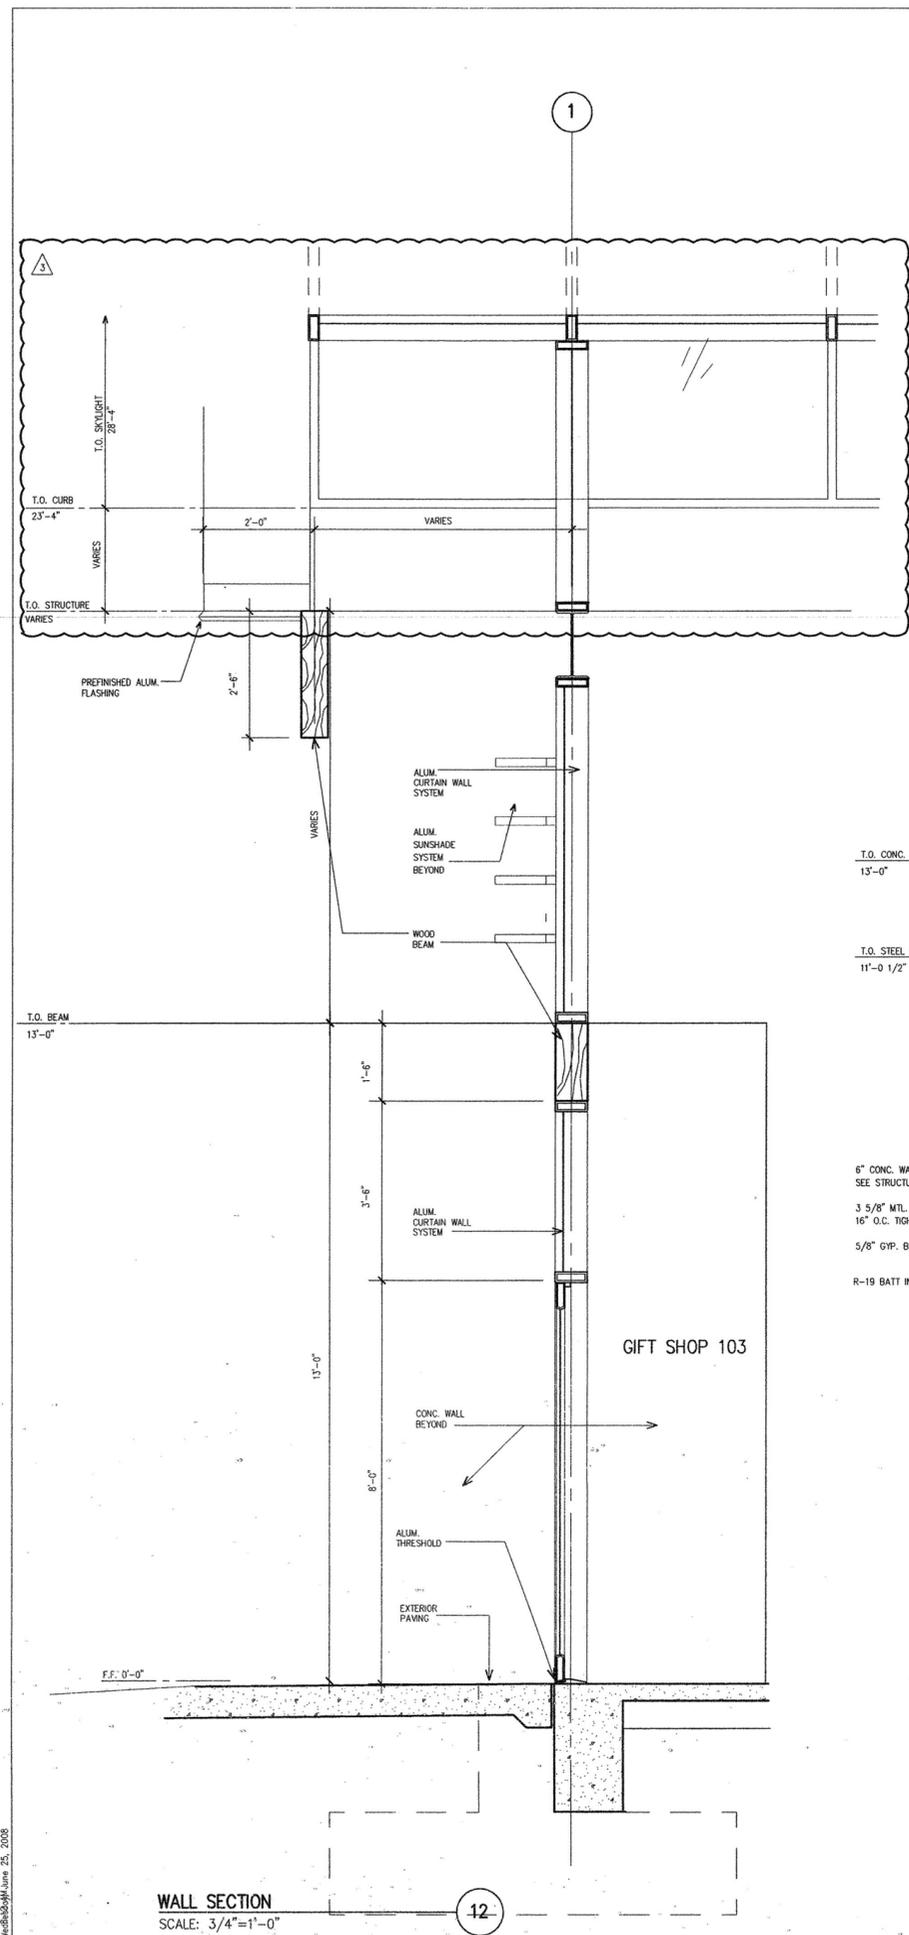


WALL SECTION
SCALE: 3/4"=1'-0"

12

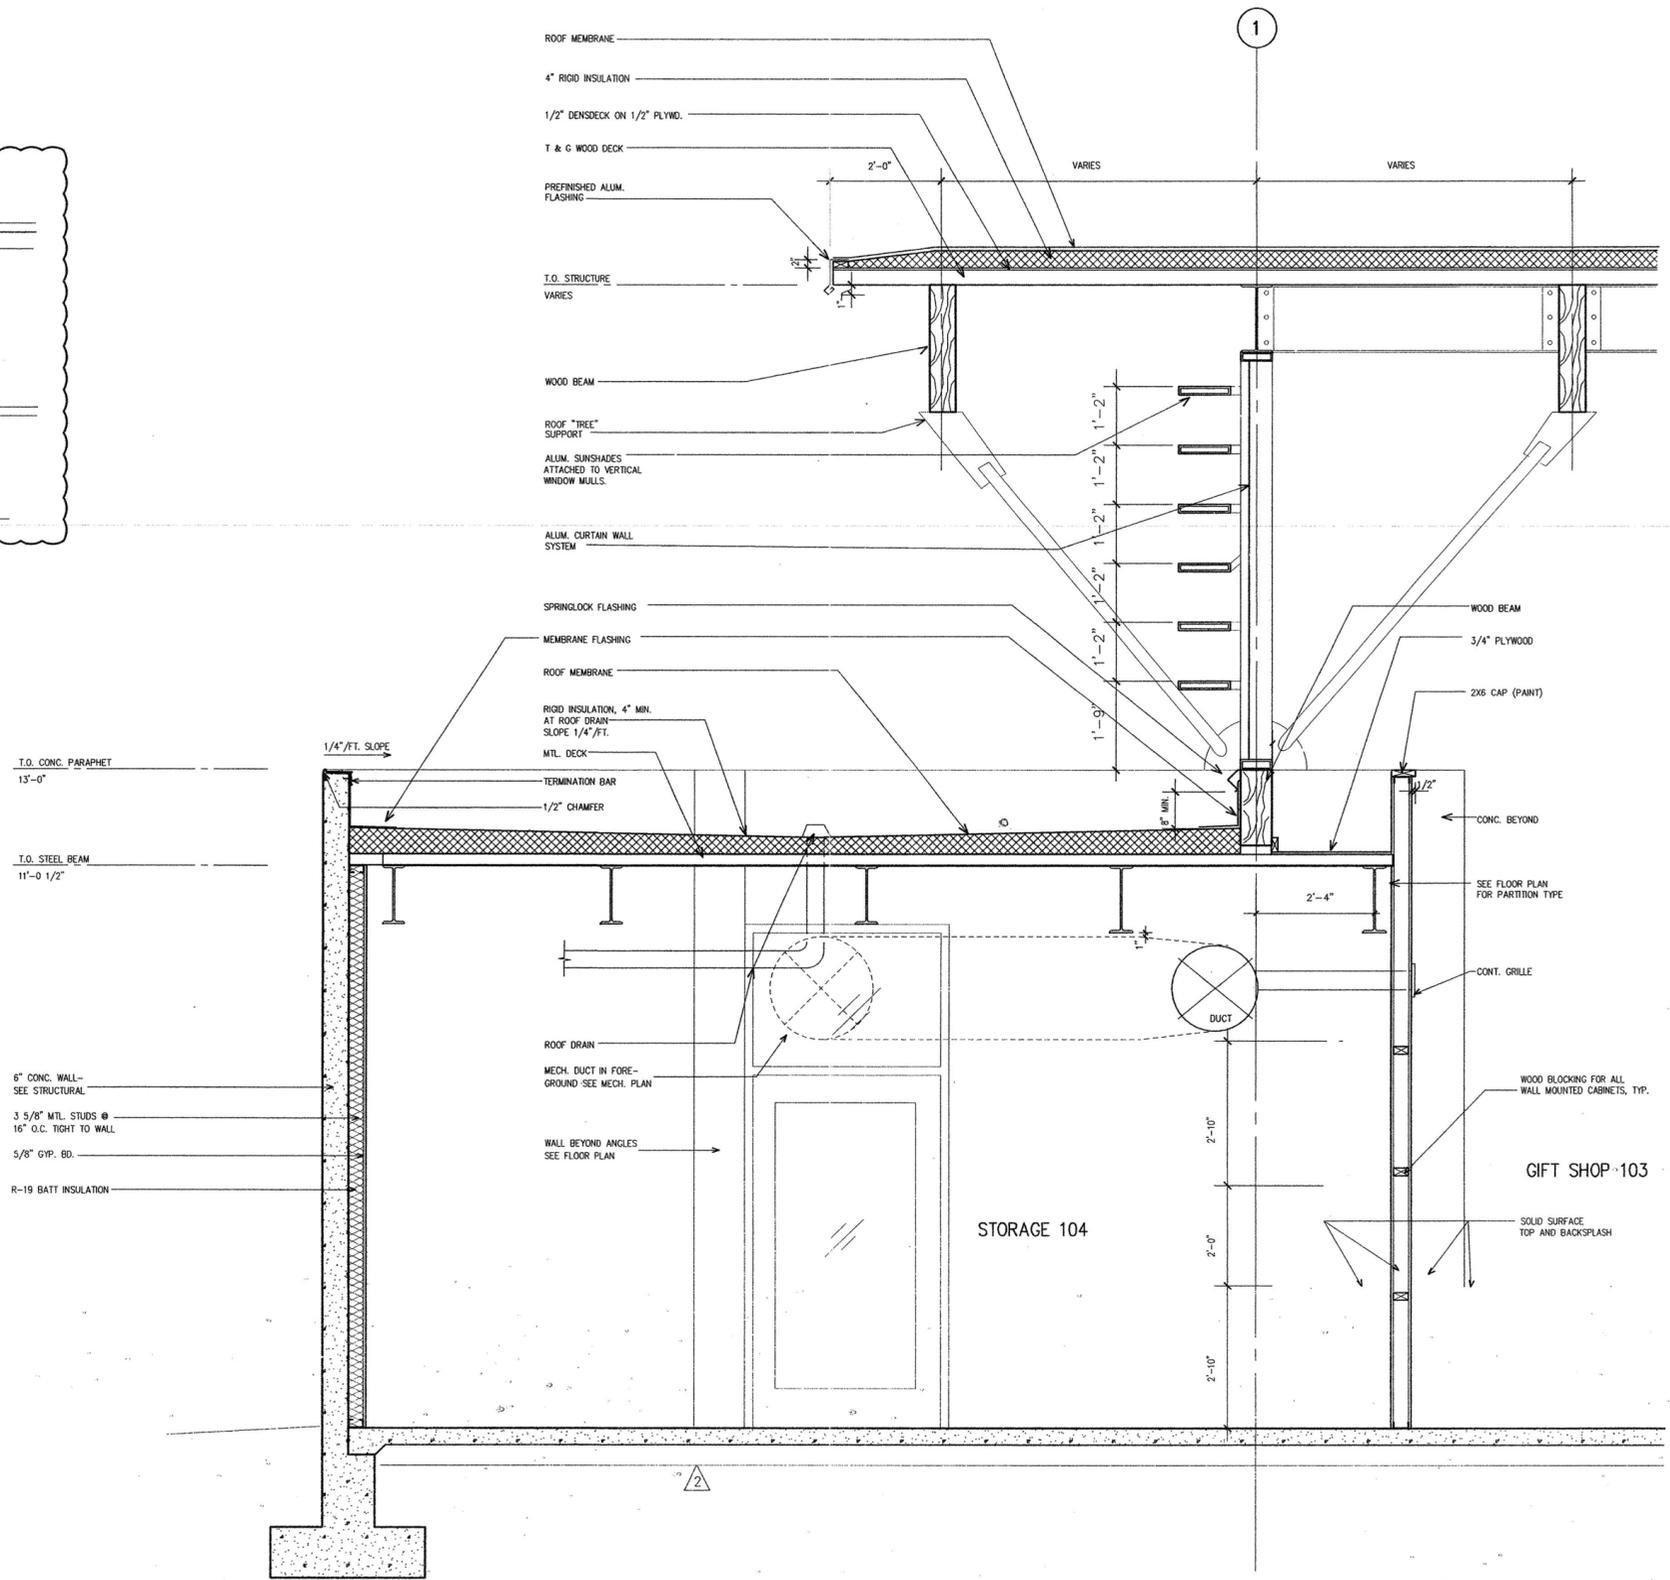

WALL SECTION
SCALE: 3/4"=1'-0"

10

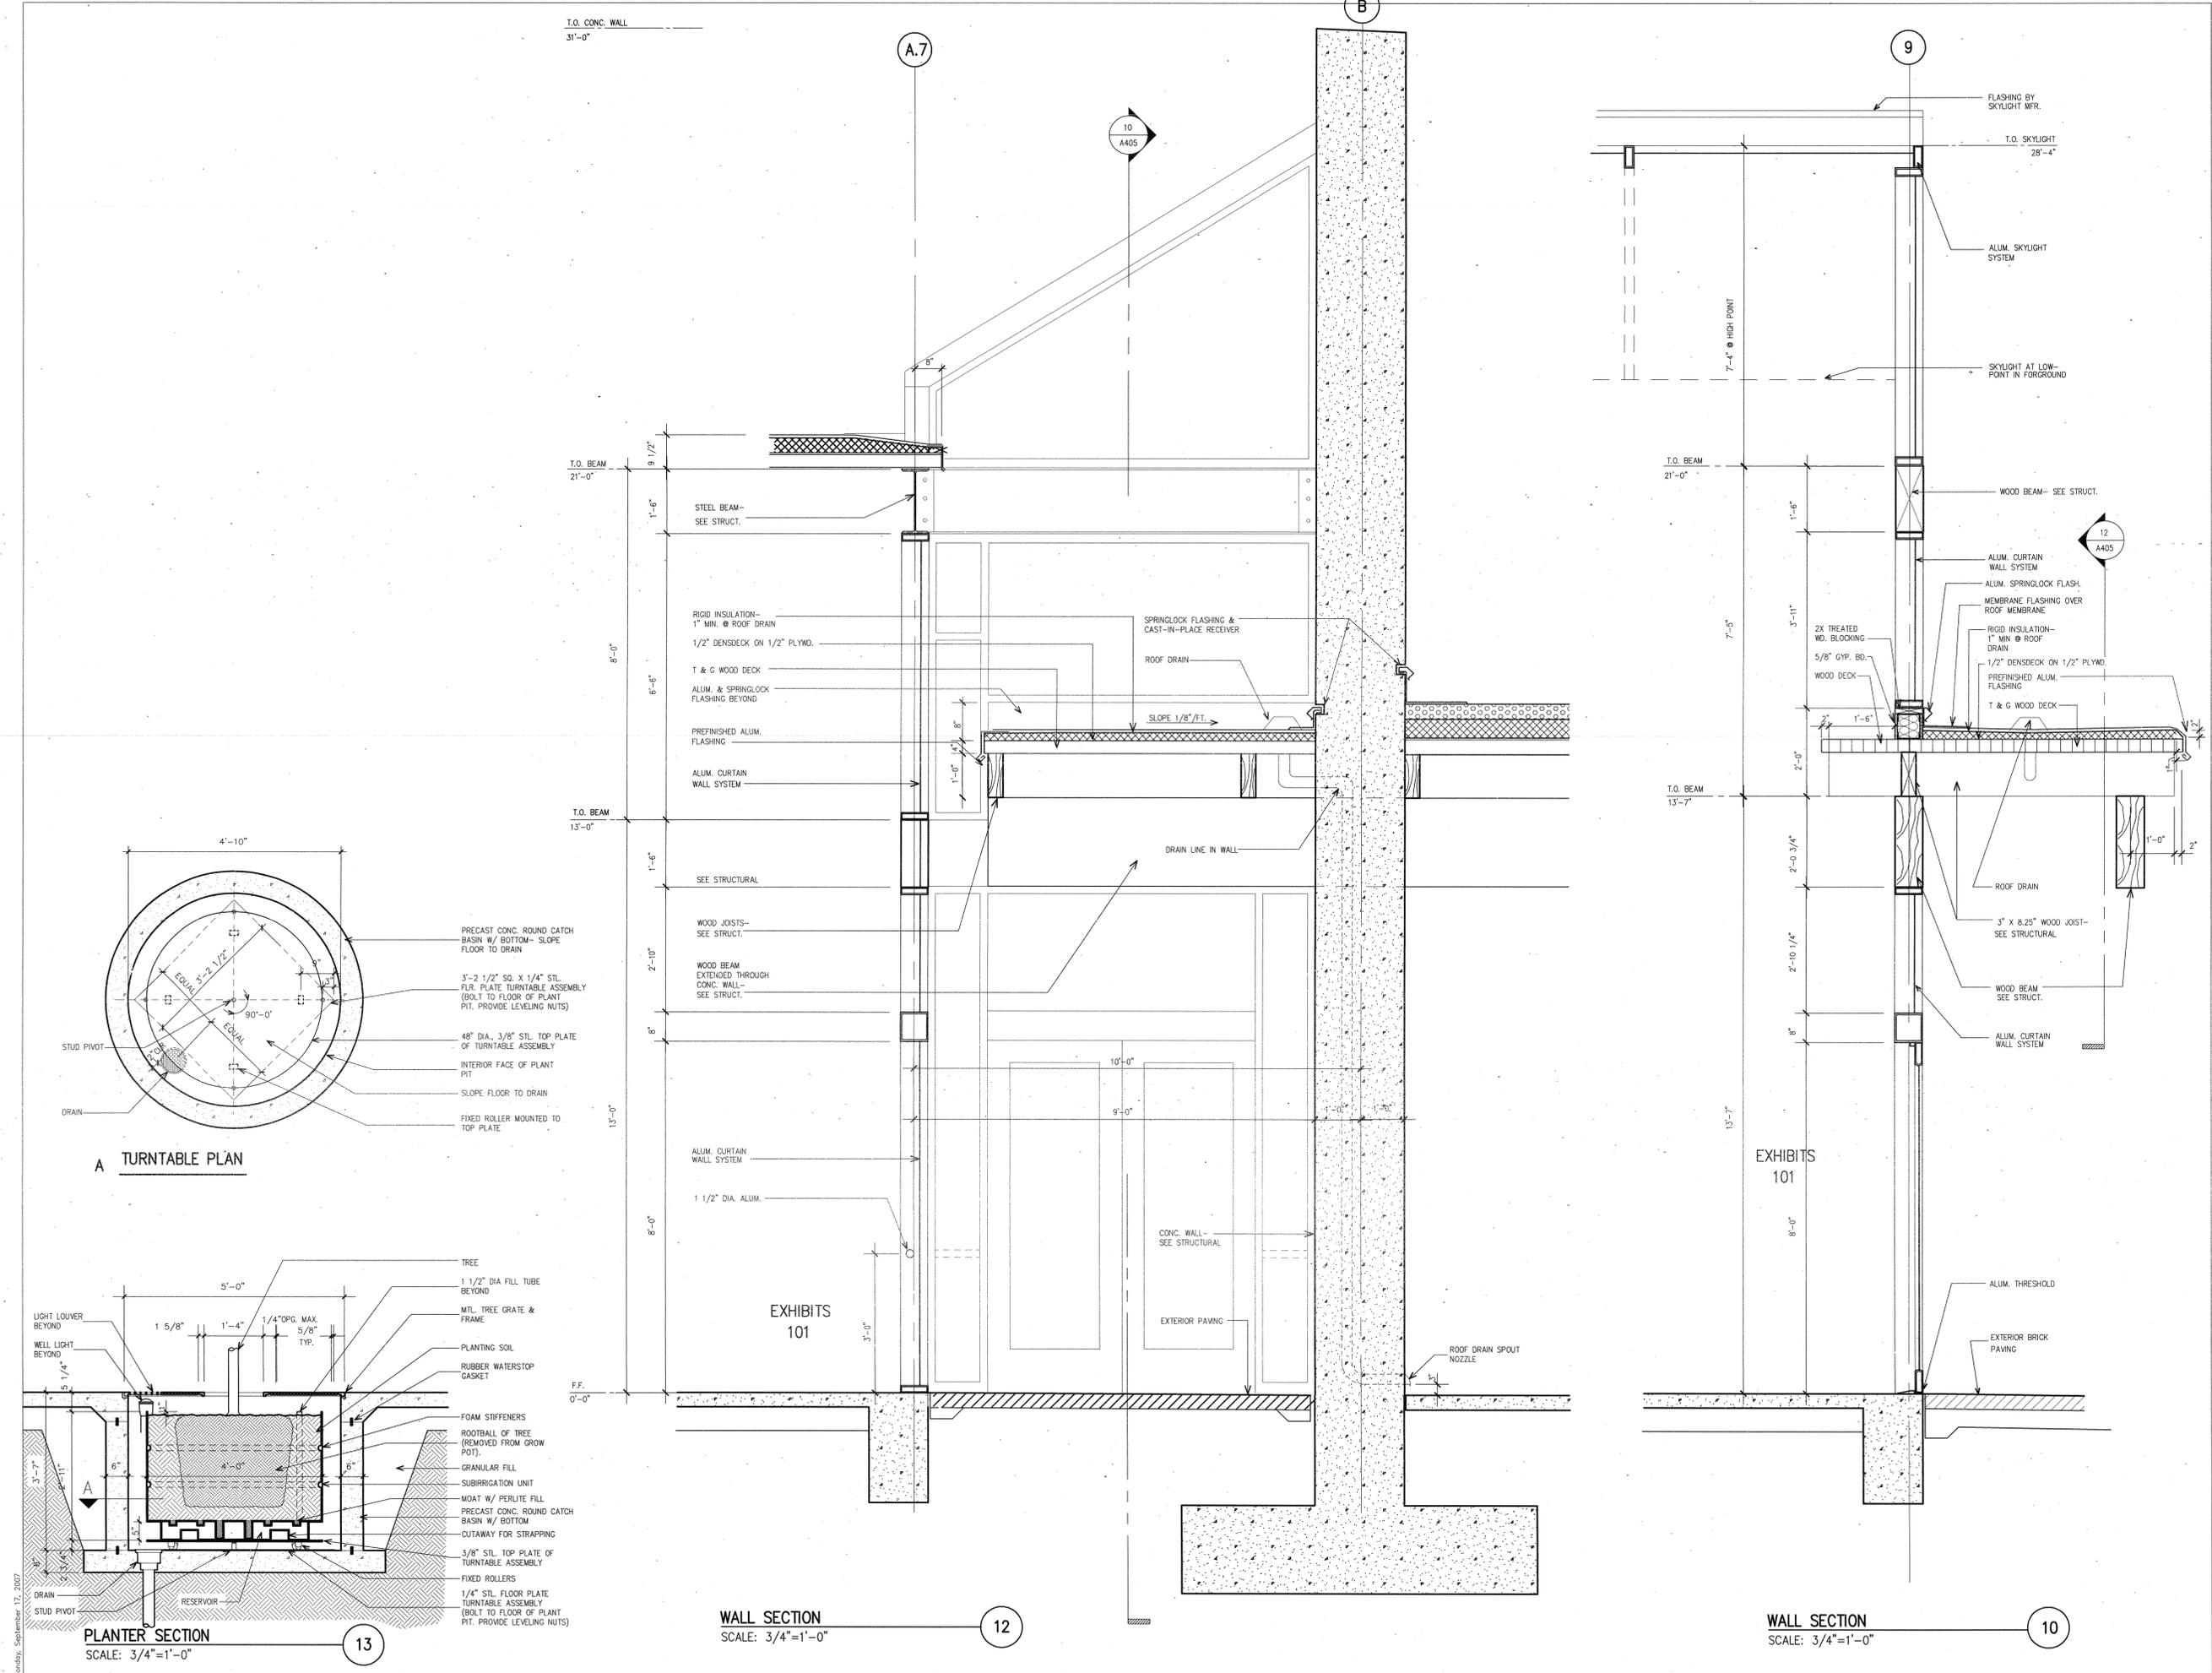

- CONSULTANTS:**
 CIVIL ENGINEER: MCELLENDAN ENGINEERS
 LANDSCAPE ARCHITECT: LARSON BURNS SMITH
 STRUCTURAL ENGINEER: CROMWELL ENGINEERS INC.
 MECH., ELEC., PLUMB. ENGINEER: CROMWELL ENGINEERS INC.
 GLOBAL VILLAGE CONSULTANT: CAMBRIDGE SEVEN ASSOCIATES
 INTERIOR DESIGNER: POLK STANLEY ROWLAND CURZON PORTER ARCHITECTS
 GENERAL CONTRACTOR: CDI CONTRACTORS, INC.

NOTES:

ISSUE DATE:
17 SEPTEMBER 07

REVISIONS:

#	DATE	DESCRIPTION

MURPHY KELLER
EDUCATION CENTER
HEIFER
INTERNATIONAL
CENTER
LITTLE ROCK, ARKANSAS

PSRCP JOB NUMBER:
431E
CONTENTS:
WALL SECTIONS

SHEET NUMBER:
A405

Monday, September 17, 2007



CONSULTANTS:
CIVIL ENGINEER:
 MCCLELLAND ENGINEERS
LANDSCAPE ARCHITECT:
 LARSON BURNS SMITH
STRUCTURAL ENGINEER:
 CROMWELL ENGINEERS INC.
MECH., ELEC., PLUMB. ENGINEER:
 CROMWELL ENGINEERS INC.
GLOBAL VILLAGE CONSULTANT
 CAMBRIDGE SEVEN ASSOCIATES
INTERIOR DESIGNER:
 POLK STANLEY ROWLAND
 CURZON PORTER ARCHITECTS
GENERAL CONTRACTOR:
 CDI CONTRACTORS, INC.

NOTES:

ISSUE DATE:
17 SEPTEMBER 07


REVISIONS:

#	DATE	DESCRIPTION

**MURPHY KELLER
EDUCATION CENTER**
**HEIFER
INTERNATIONAL
CENTER**
 LITTLE ROCK, ARKANSAS

PSRCP JOB NUMBER:
431E
 CONTENTS:
WALL SECTIONS

SHEET NUMBER:
A406

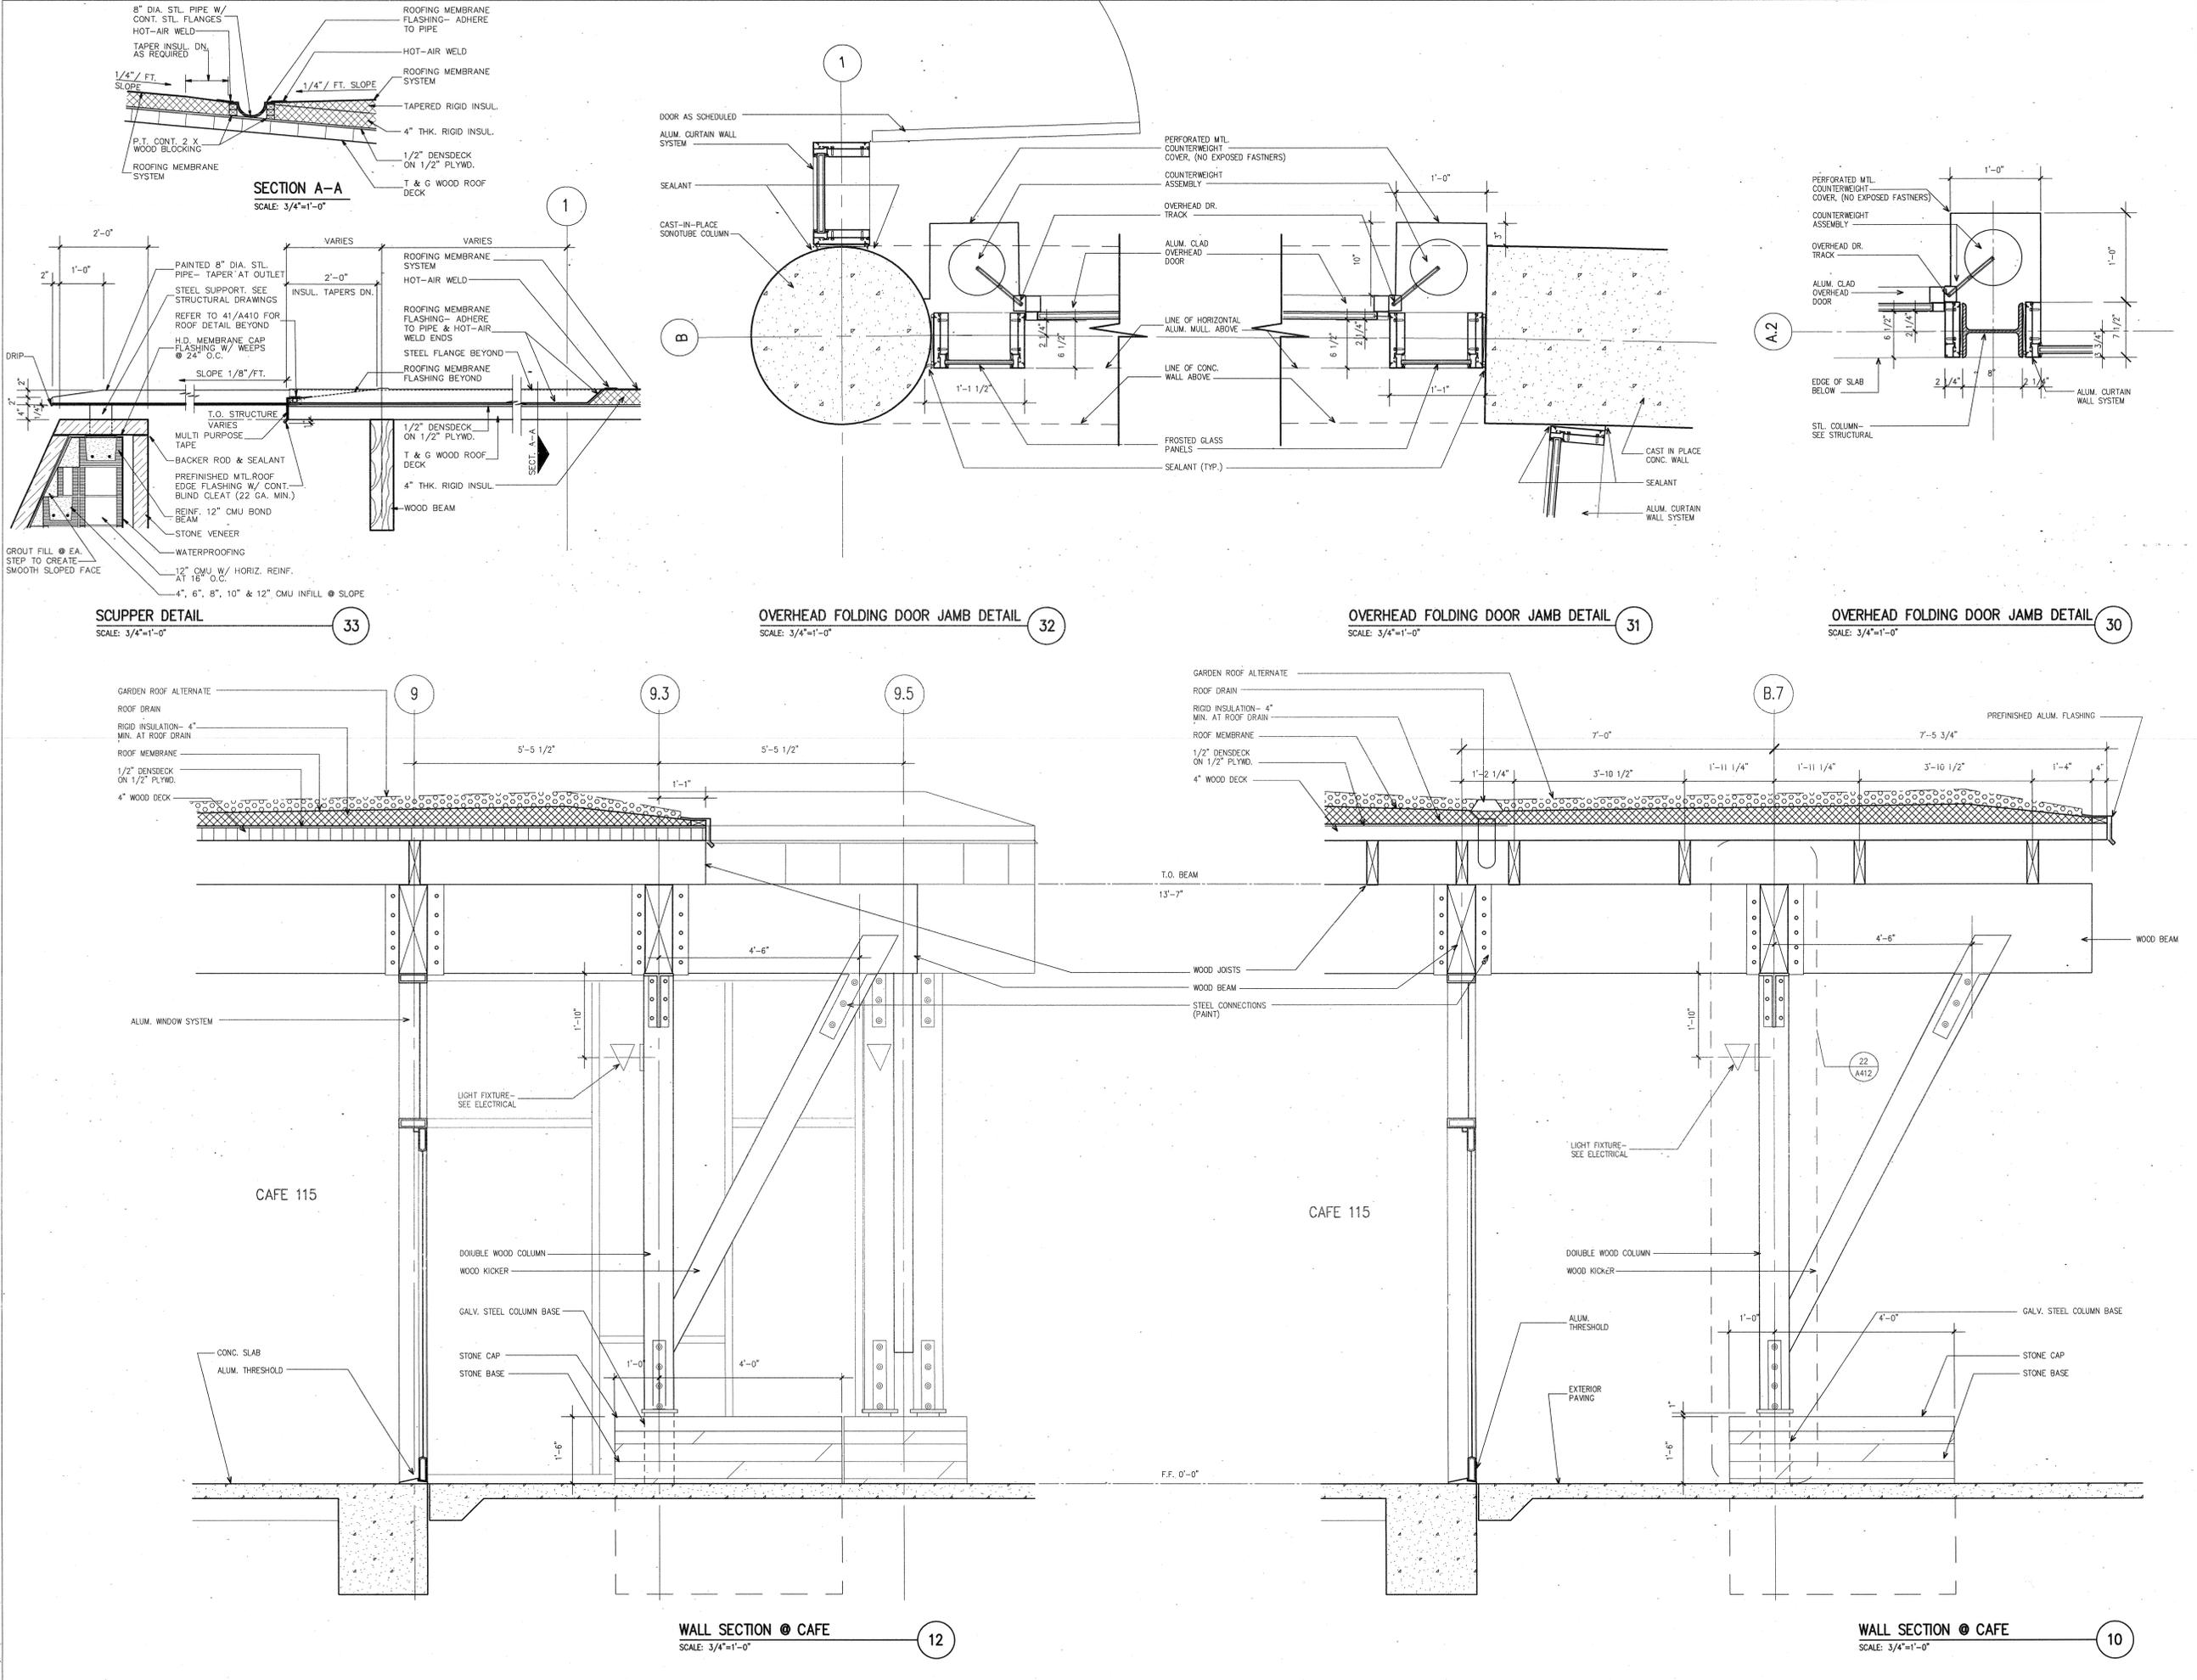

700 SOUTH SCHILLER
LITTLE ROCK, AR 72201
501.378.0878 office
501.372.7629 fax

509 W. SPRING STREET, SUITE 150
FAYETTEVILLE, AR 72701
479.444.0473 office
473.251.7216 fax

www.polkstanley.com

CONSULTANTS:

- CIVIL ENGINEER:**
MCLELLAND ENGINEERS
- LANDSCAPE ARCHITECT:**
LARSON BURNS SMITH
- STRUCTURAL ENGINEER:**
CROMWELL ENGINEERS INC.
- MECH., ELEC., PLUMB. ENGINEER:**
CROMWELL ENGINEERS INC.
- GLOBAL VILLAGE CONSULTANT**
CAMBRIDGE SEVEN ASSOCIATES
- INTERIOR DESIGNER:**
POLK STANLEY ROWLAND
CURZON PORTER ARCHITECTS
- GENERAL CONTRACTOR:**
CDI CONTRACTORS, INC.

NOTES:

- 1.
- 2.
- 3.
- 4.
- 5.
- 6.
- 7.
- 8.
- 9.
- 10.
- 11.
- 12.
- 13.
- 14.
- 15.
- 16.
- 17.
- 18.
- 19.
- 20.

ISSUE DATE:
17 SEPTEMBER 07

REVISIONS:


#	DATE	DESCRIPTION
1	07 JAN 08	ASI NO. 1
2	26 AUG 08	ASI NO. 20

**MURPHY KELLER
EDUCATION CENTER**

**HEIFER
INTERNATIONAL
CENTER**
LITTLE ROCK, ARKANSAS

PSRCP JOB NUMBER:
431E
CONTENTS:
WALL SECTIONS

SHEET NUMBER:
A407

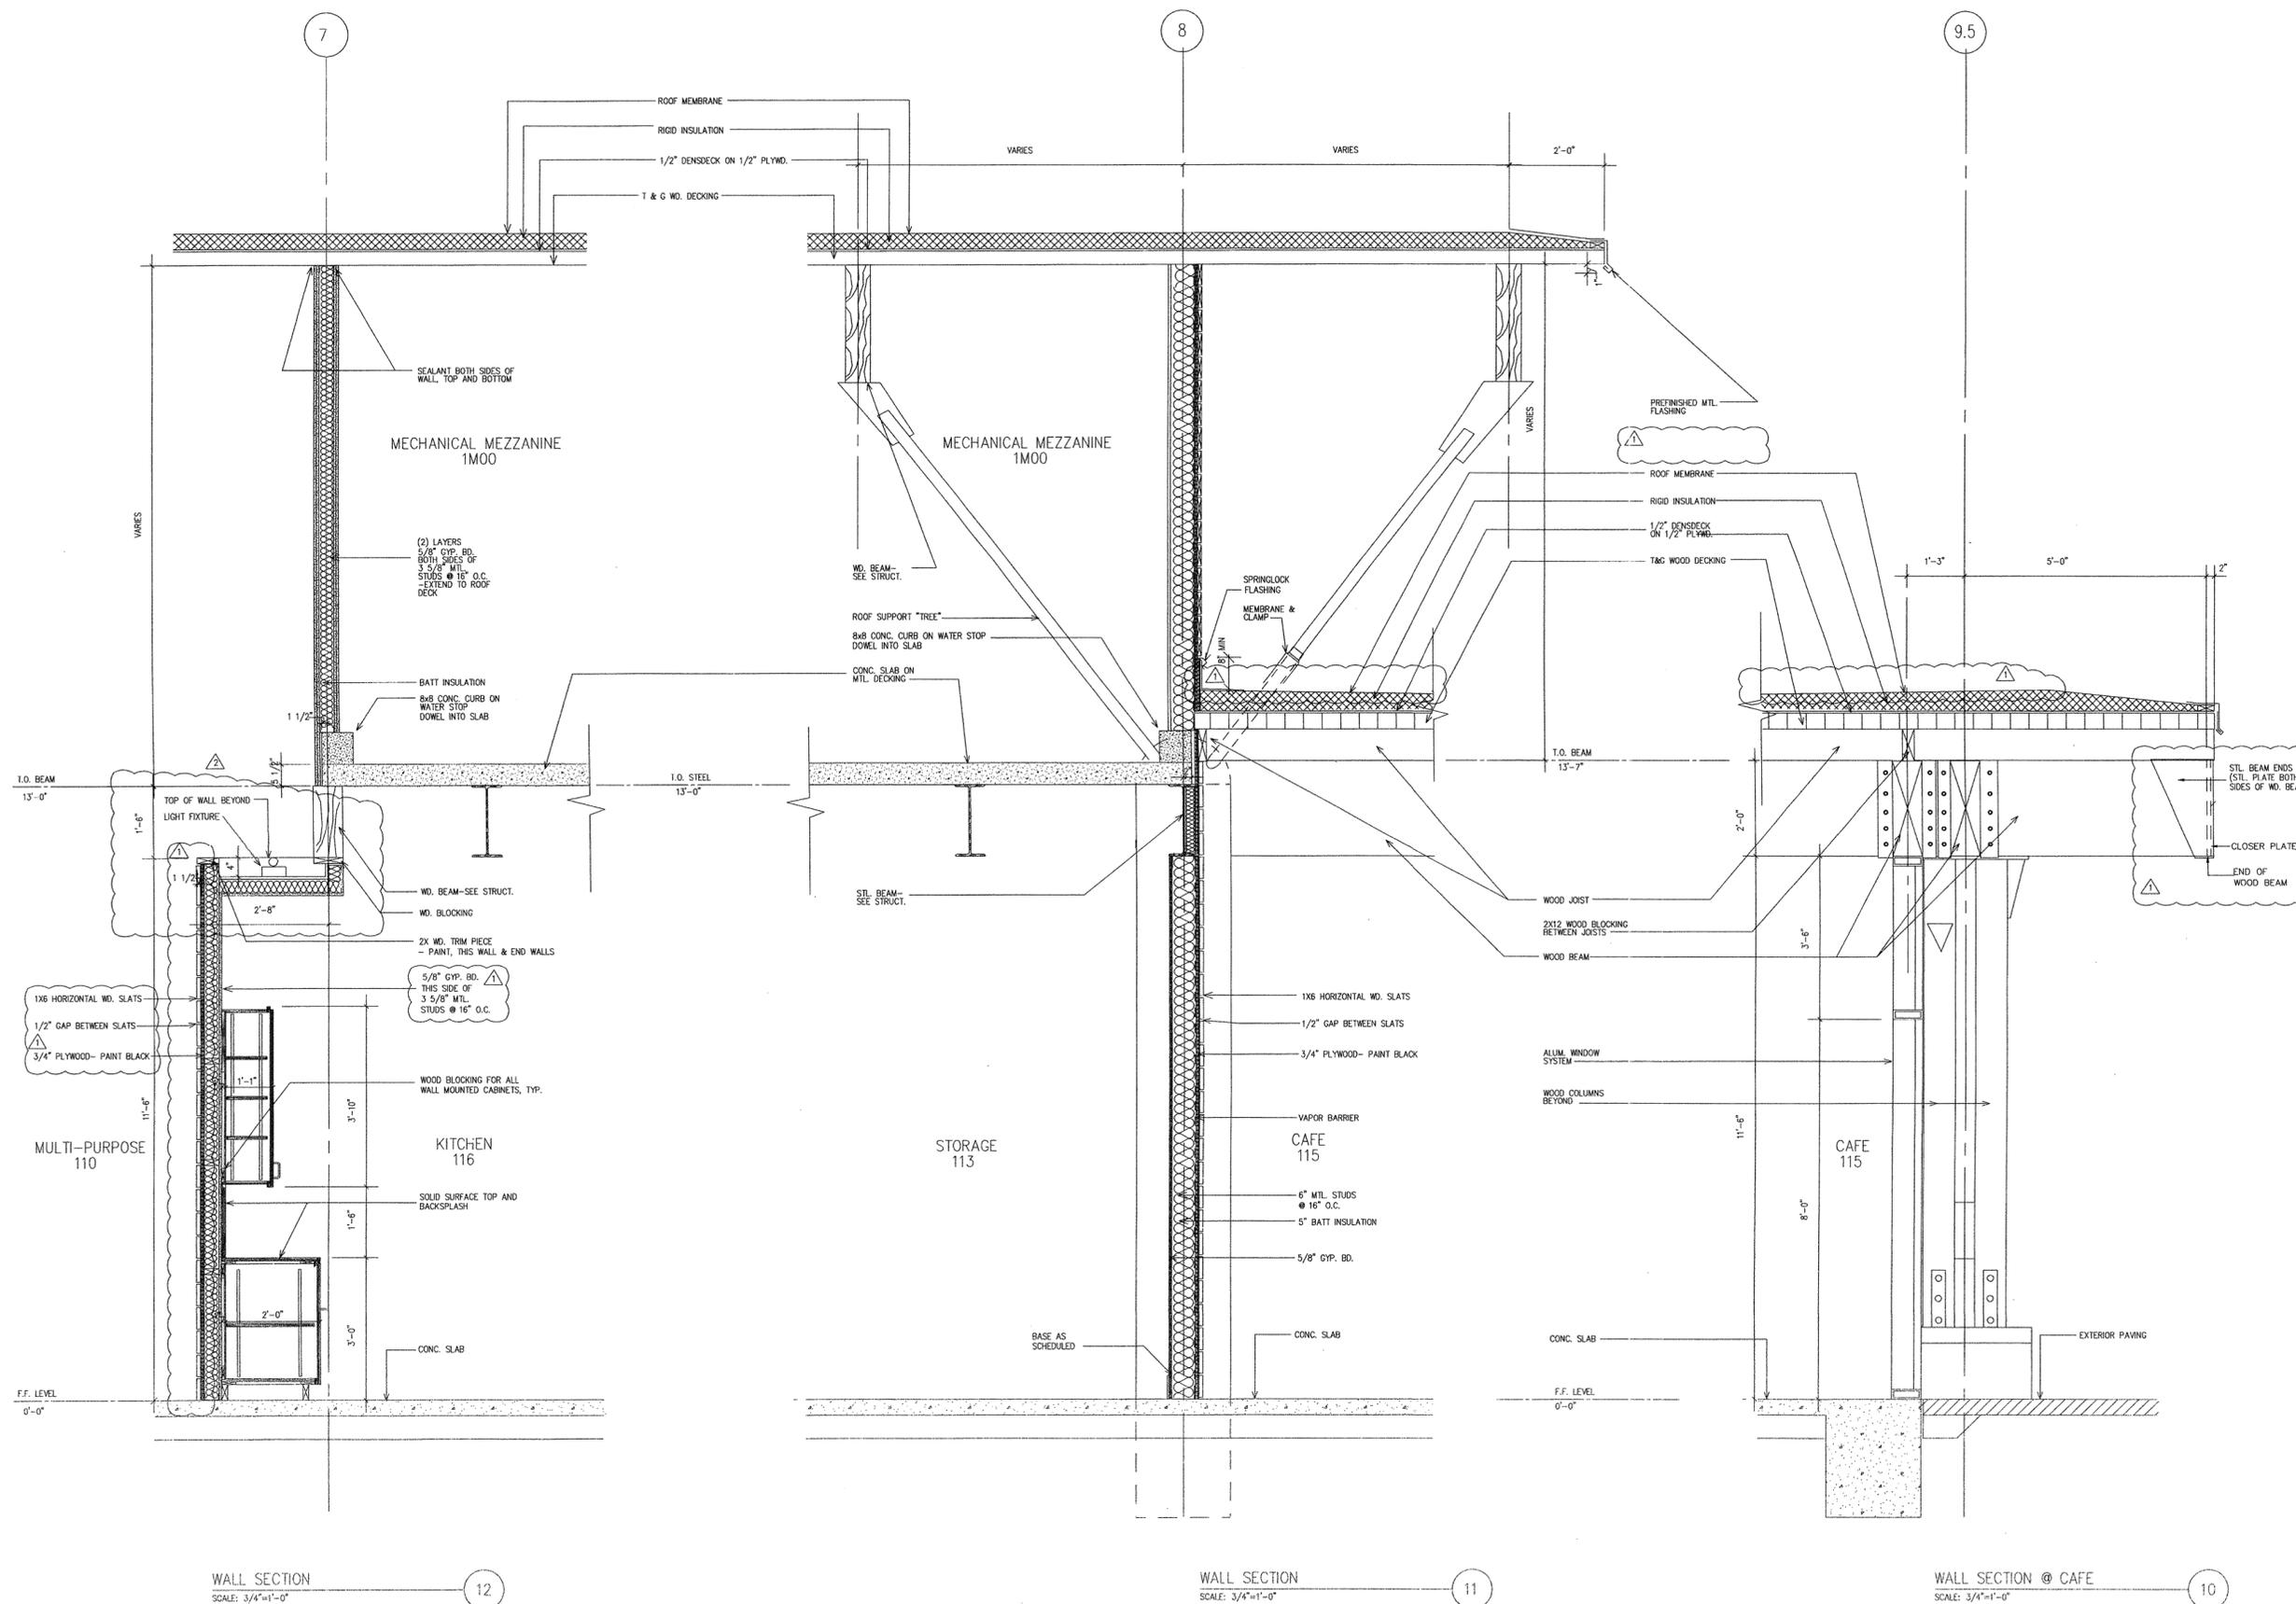

WALL SECTION
SCALE: 3/4"=1'-0"

12

WALL SECTION
SCALE: 3/4"=1'-0"

11

WALL SECTION @ CAFE
SCALE: 3/4"=1'-0"

10



CONSULTANTS:

CIVIL ENGINEER:
MCCELLEND ENGINEERS

LANDSCAPE ARCHITECT:
LARSON BURNS SMITH

STRUCTURAL ENGINEER:
CROMWELL ENGINEERS INC.

MECH., ELEC., PLUMB. ENGINEER:
CROMWELL ENGINEERS INC.

GLOBAL VILLAGE CONSULTANT
CAMBRIDGE SEVEN ASSOCIATES

INTERIOR DESIGNER:
POLK STANLEY ROWLAND
CURZON PORTER ARCHITECTS

GENERAL CONTRACTOR:
CDI CONTRACTORS, INC.

NOTES:

ISSUE DATE:
17 SEPTEMBER 07

REVISIONS:

#	DATE:	DESCRIPTION:


**MURPHY KELLER
EDUCATION CENTER**

**HEIFER
INTERNATIONAL
CENTER**
LITTLE ROCK, ARKANSAS

PSRCP JOB NUMBER:
431E

CONTENTS:
WALL SECTIONS

SHEET NUMBER:
A409

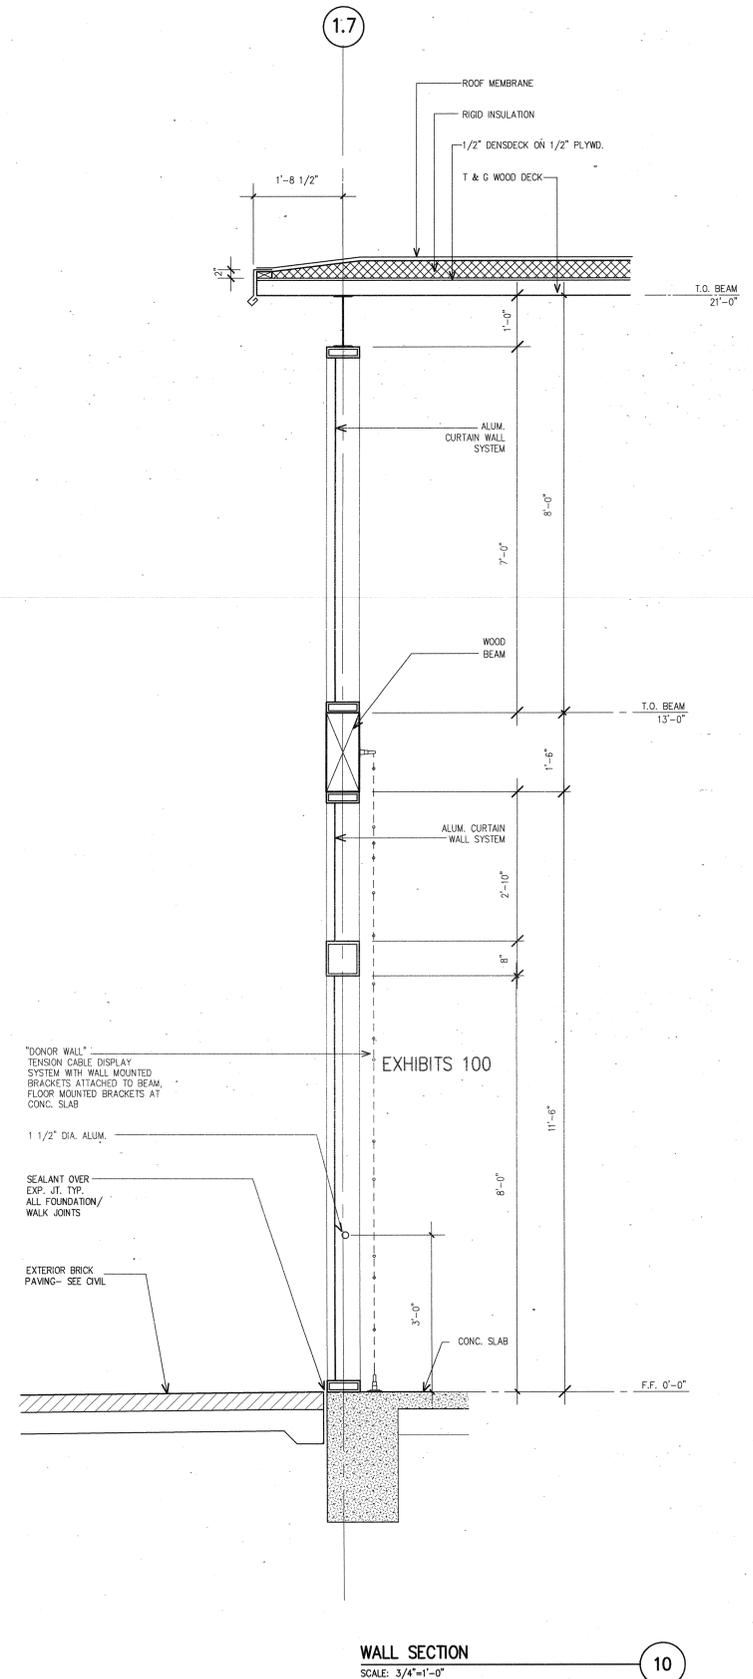



CONSULTANTS:

CIVIL ENGINEER:
MCLELLAND ENGINEERS

LANDSCAPE ARCHITECT:
LARSON BURNS SMITH


STRUCTURAL ENGINEER:
CROMWELL ENGINEERS INC.

MECH., ELEC., PLUMB. ENGINEER:
CROMWELL ENGINEERS INC.

GLOBAL VILLAGE CONSULTANT
CAMBRIDGE SEVEN ASSOCIATES

INTERIOR DESIGNER:
POLK STANLEY ROWLAND
CURZON PORTER ARCHITECTS

GENERAL CONTRACTOR:
CDI CONTRACTORS, INC.

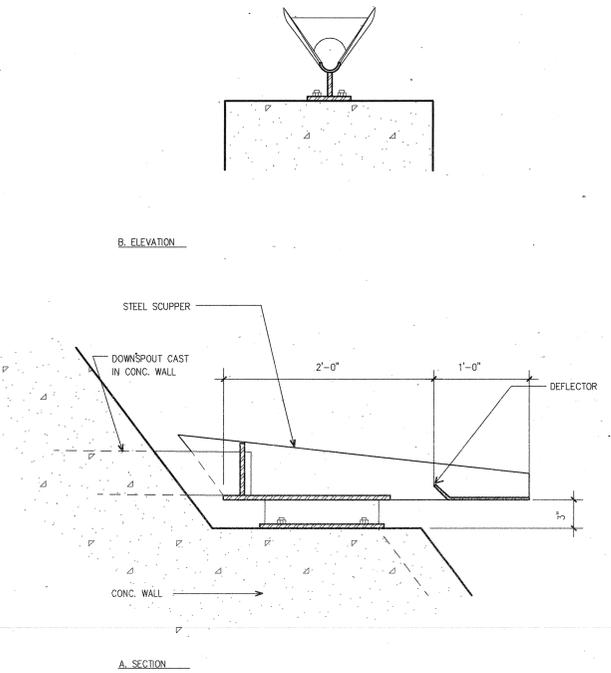

SOUTH SCUPPER SECTION
SCALE: 1 1/2"=1'-0"

20

NOTES:

ISSUE DATE:
17 SEPTEMBER 07

REVISIONS:

#	DATE	DESCRIPTION

**MURPHY KELLER
EDUCATION CENTER**

**HEIFER
INTERNATIONAL
CENTER**

LITTLE ROCK, ARKANSAS

PSRCP JOB NUMBER:


431E

CONTENTS:

STEEL CONNECTION
DETAILS


SHEET NUMBER:

A413

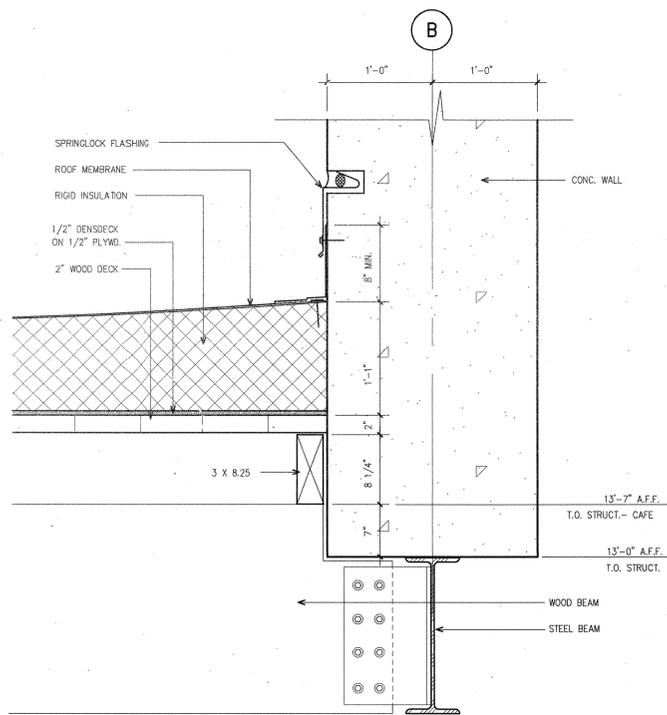


BEAM CONNECTION @ CAFE
SCALE: 1 1/2"=1'-0"

13

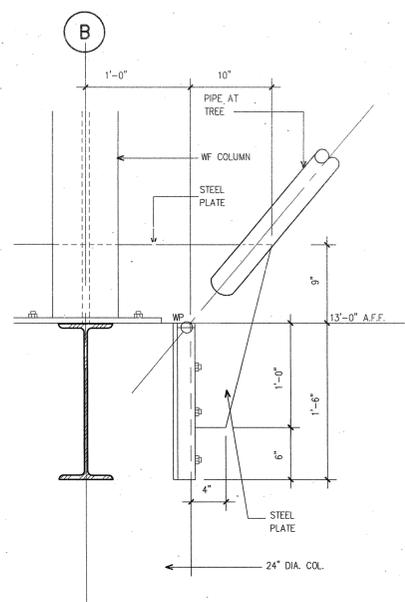


TREE BASE AT COL. B-3
SCALE: 1 1/2"=1'-0"

12

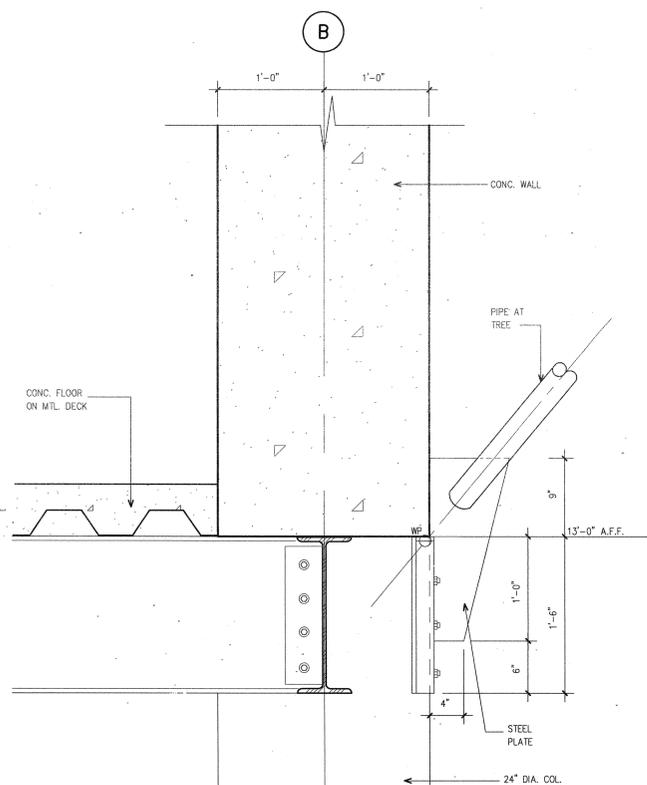

TREE BASE AT COL. B-8
SCALE: 1 1/2"=1'-0"

11

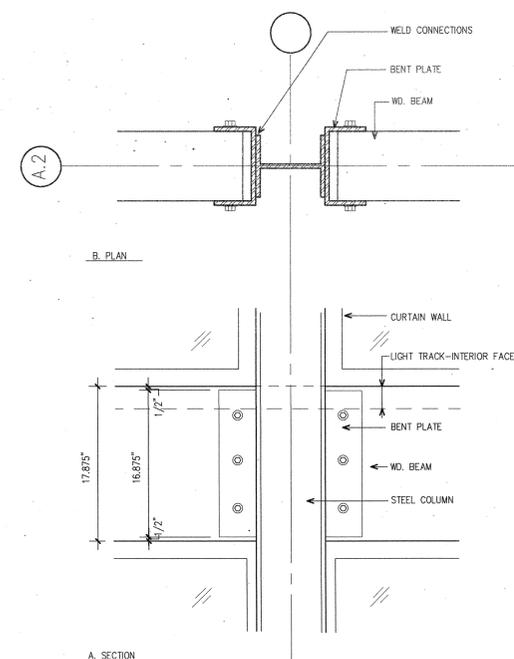

COLUMN/ WOOD BEAM DETAIL
SCALE: 1 1/2"=1'-0"

10



CONSULTANTS:
CIVIL ENGINEER: MCCLELLAND ENGINEERS
LANDSCAPE ARCHITECT: LARSON BURNS SMITH
STRUCTURAL ENGINEER: CROMWELL ENGINEERS INC.
MECH., ELEC., PLUMB. ENGINEER: CROMWELL ENGINEERS INC.
GLOBAL VILLAGE CONSULTANT: CAMBRIDGE SEVEN ASSOCIATES
INTERIOR DESIGNER: POLK STANLEY ROWLAND CURZON PORTER ARCHITECTS
GENERAL CONTRACTOR: CDI CONTRACTORS, INC.

NOTES:

ISSUE DATE:
17 SEPTEMBER 07

REVISIONS:


#	DATE	DESCRIPTION

**MURPHY KELLER
EDUCATION CENTER**


**HEIFER
INTERNATIONAL
CENTER**
LITTLE ROCK, ARKANSAS

PSRCP JOB NUMBER:
431E
CONTENTS:
ENLARGED DETAILS


SHEET NUMBER:
A414

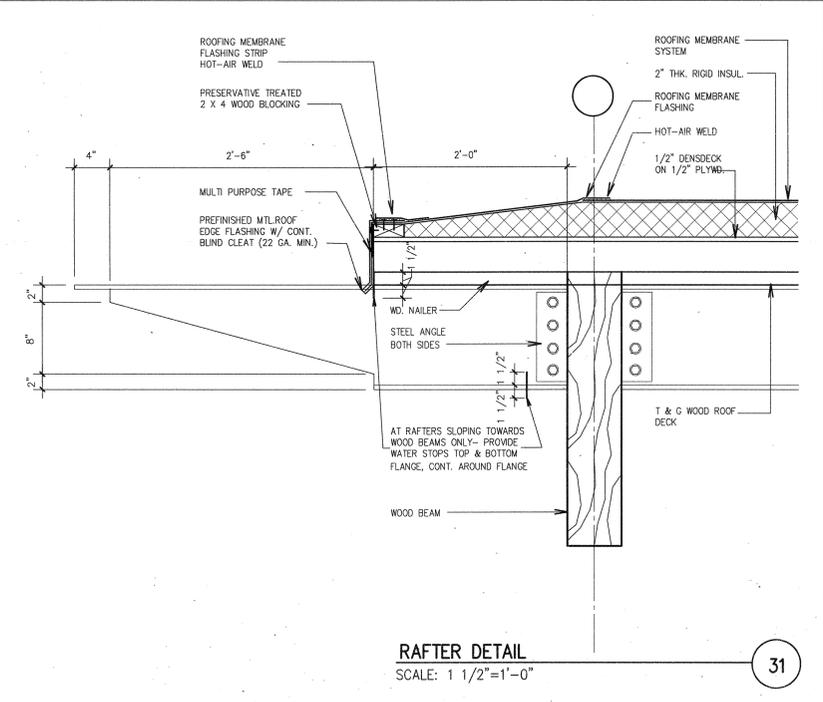

31
RAFTER DETAIL
SCALE: 1 1/2"=1'-0"

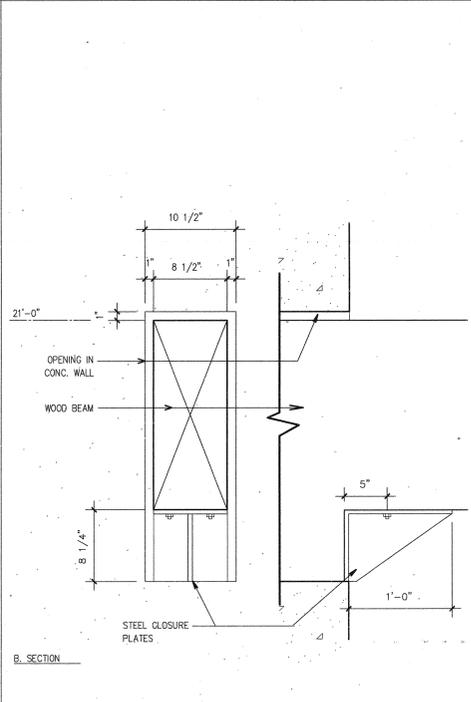


20
W.D. BEAM AT CONC. WALL
SCALE: 1 1/2"=1'-0"

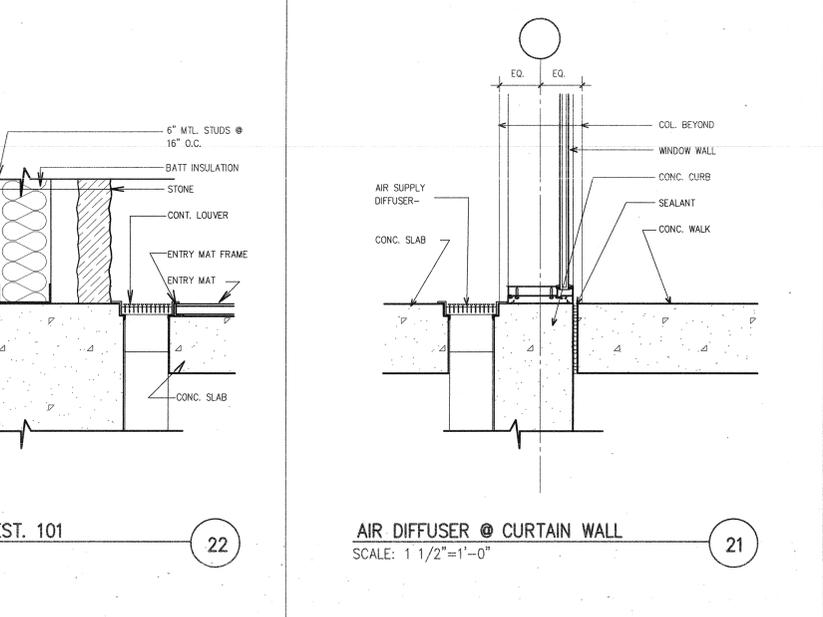


22
AIR DIFFUSER @ VEST. 101
SCALE: 1 1/2"=1'-0"


21
AIR DIFFUSER @ CURTAIN WALL
SCALE: 1 1/2"=1'-0"

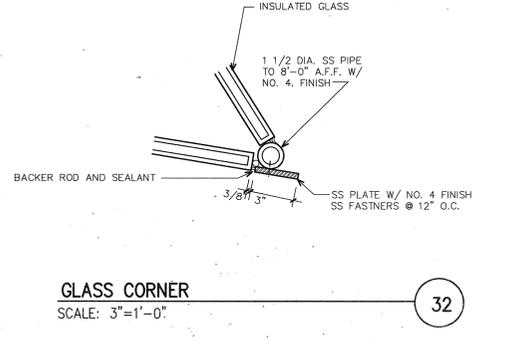


32
GLASS CORNER
SCALE: 3"=1'-0"

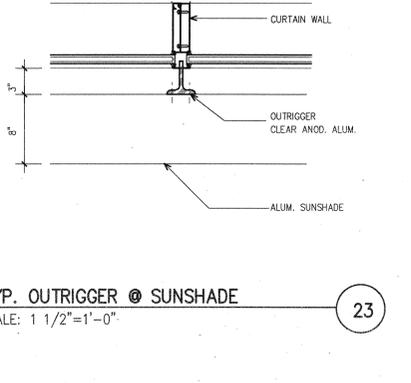


23
TYP. OUTRIGGER @ SUNSHADE
SCALE: 1 1/2"=1'-0"

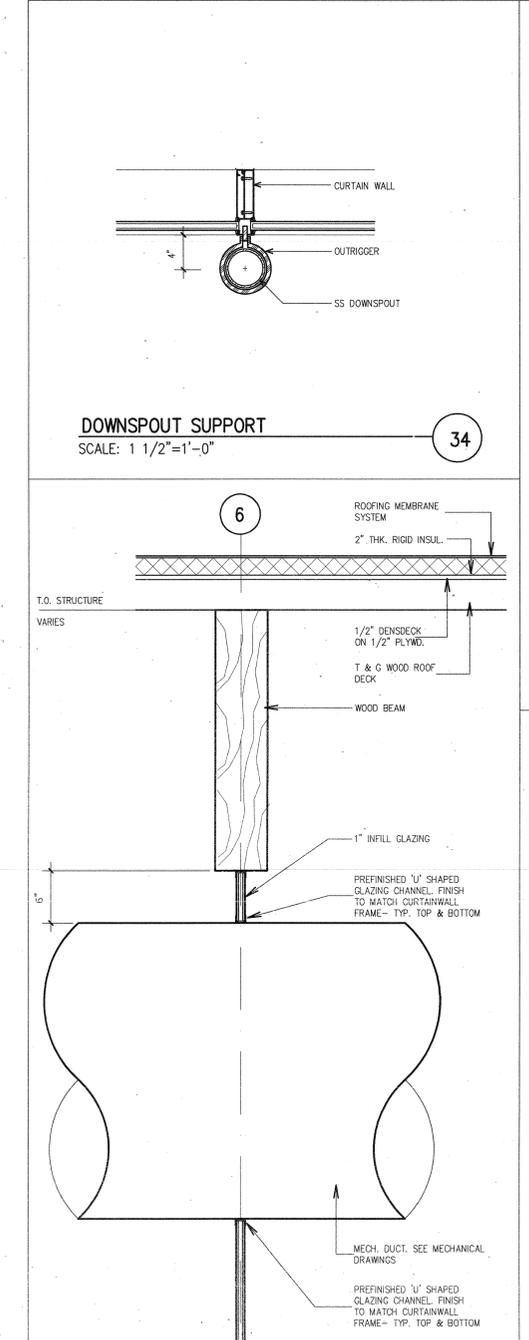


34
DOWNSPOUT SUPPORT
SCALE: 1 1/2"=1'-0"

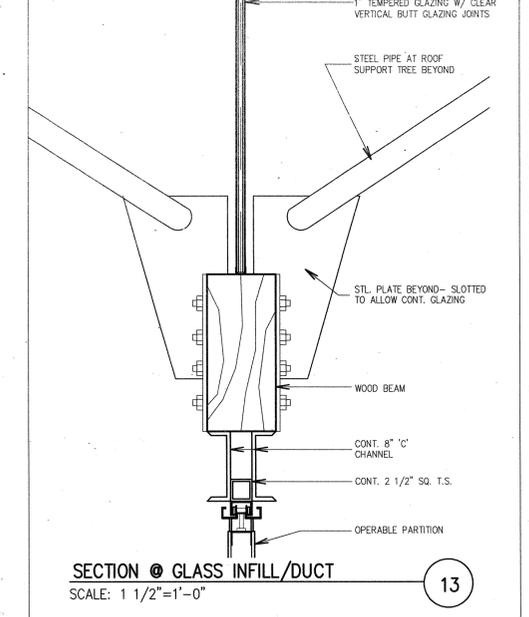


13
SECTION @ GLASS INFILL/DUCT
SCALE: 1 1/2"=1'-0"

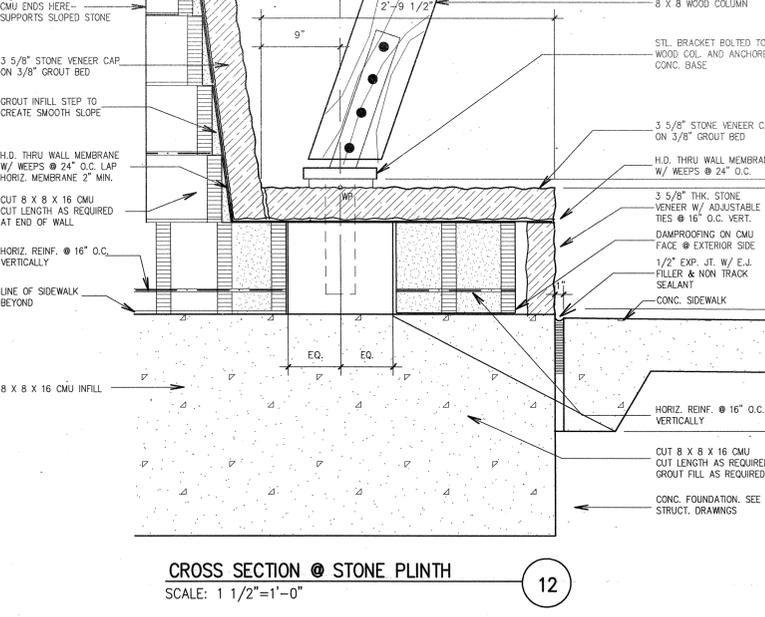

12
CROSS SECTION @ STONE PLINTH
SCALE: 1 1/2"=1'-0"

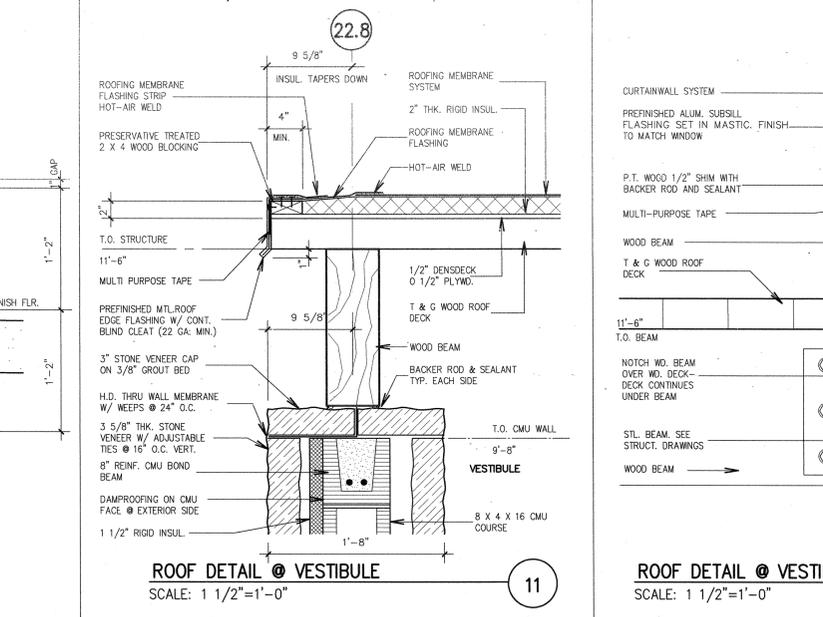

11
ROOF DETAIL @ VESTIBULE
SCALE: 1 1/2"=1'-0"

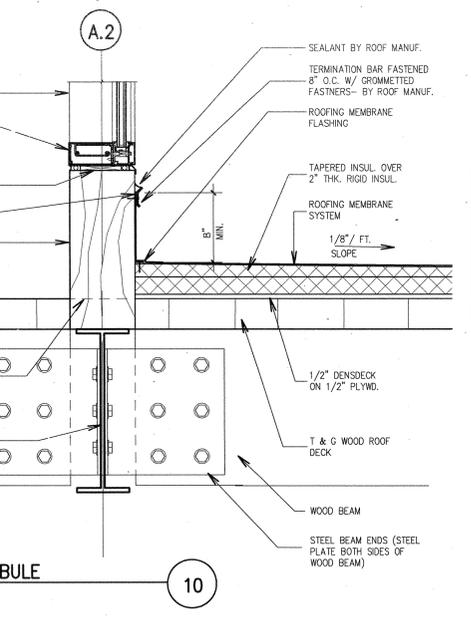

10
ROOF DETAIL @ VESTIBULE
SCALE: 1 1/2"=1'-0"



CONSULTANTS:

CIVIL ENGINEER:
MCCELLEND ENGINEERS

LANDSCAPE ARCHITECT:
LARSON BURNS SMITH

STRUCTURAL ENGINEER:
CROMWELL ENGINEERS INC.

MECH., ELEC., PLUMB. ENGINEER:
CROMWELL ENGINEERS INC.

GLOBAL VILLAGE CONSULTANT
CAMBRIDGE SEVEN ASSOCIATES

INTERIOR DESIGNER:
POLK STANLEY ROWLAND
CURZON PORTER ARCHITECTS

GENERAL CONTRACTOR:
CDI CONTRACTORS, INC.

NOTES:

ISSUE DATE:
17 SEPTEMBER 07

REVISIONS:

#	DATE:	DESCRIPTION:

**MURPHY KELLER
EDUCATION CENTER**

**HEIFER
INTERNATIONAL
CENTER**

LITTLE ROCK, ARKANSAS

PSRCP JOB NUMBER:


431E

CONTENTS:


MISCELLANEOUS
DETAILS

SHEET NUMBER:


A415

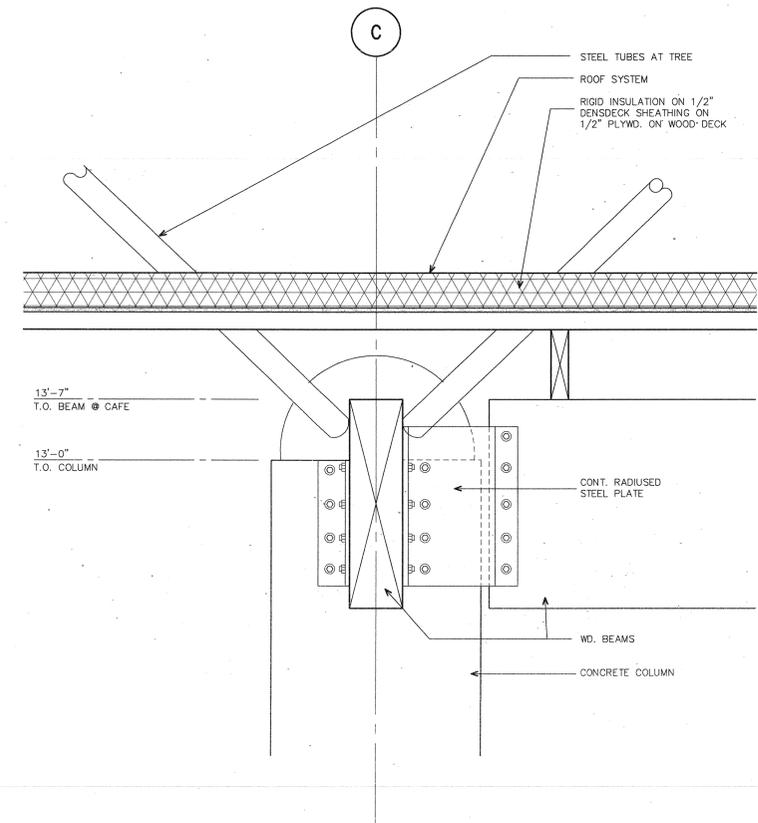


ELEVATION- COLUMN CAP @ GL-C
SCALE: 1 1/2"=1'-0" 20

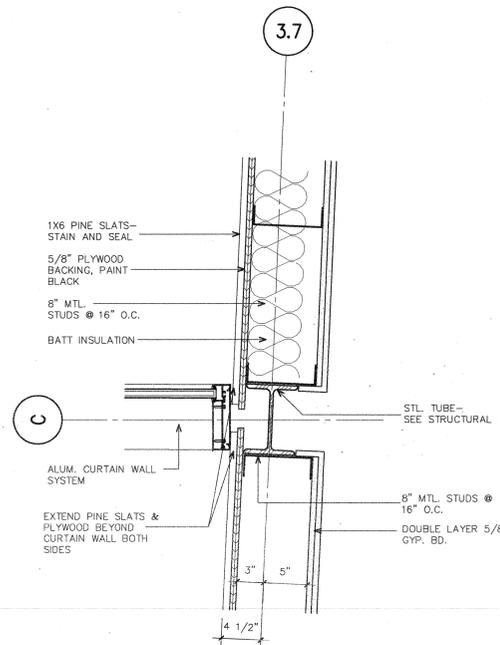


COLUMN DETAIL
SCALE: 1 1/2"=1'-0" 21

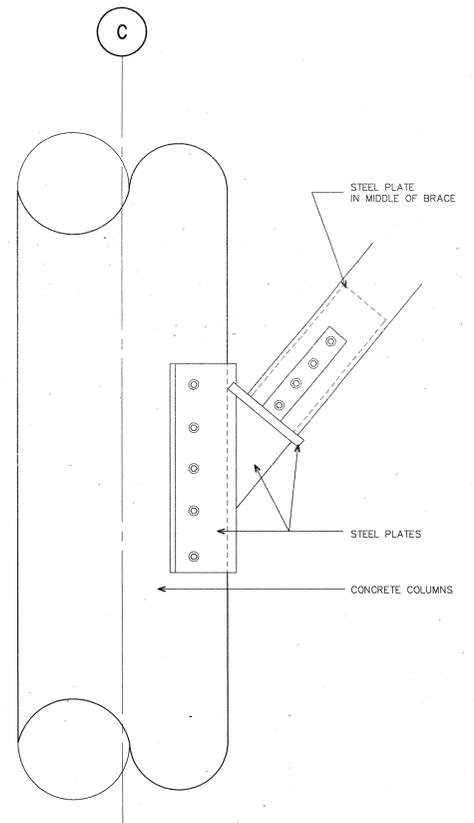

COLUMN DETAIL @ GL-C
SCALE: 1 1/2"=1'-0" 10

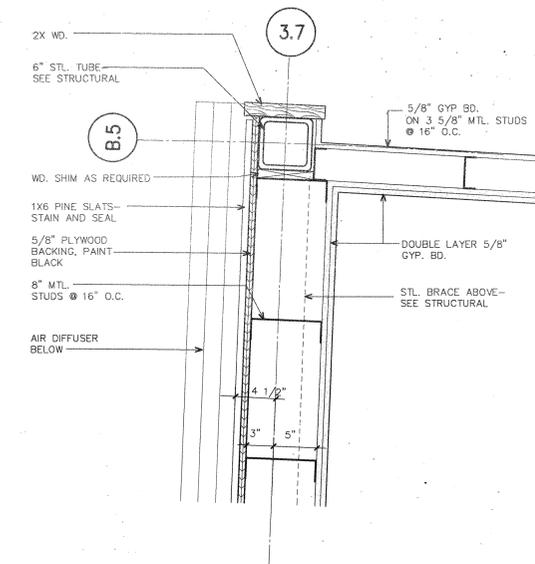

COLUMN DETAIL
SCALE: 1 1/2"=1'-0" 11

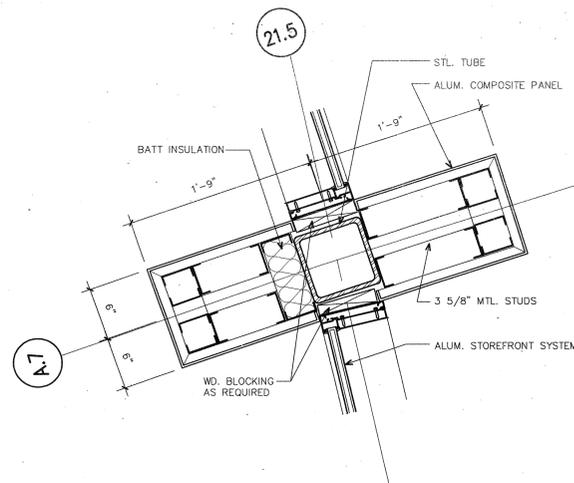

COLUMN DETAIL
SCALE: 1 1/2"=1'-0" 12

LEGEND

- 1 HOUR FIRE RATED PARTITION
- ▨ CEILING AREAS NOT INCLUDED
- ▨ METAL DECK
- ▨ CYP. BD CEILING
- ▨ WOOD DECK
- LIGHT FIXTURES
SEE ELECTRICAL DRAWINGS
- MECHANICAL DIFFUSERS & GRILLS
SEE MECHANICAL DRAWINGS
- SW SOUND WALL
- 8'-8" CEILING ELEVATION
ABOVE FINISHED FLOOR
- ⊙ EXIT SIGN
- ⊙ SMOKE DETECTOR
- ⊙ HEAT DETECTOR
- ⊙ INTERCOM/PAGING
SPEAKER
- ⊙ MOTION DETECTOR
- ⊙ OVERHEAD PROJECTOR
- ▨ ABOVE CEILING MOUNTED
MECHANICAL EQUIPMENT

**POLK
STANLEY
ROWLAND
CURZON
PORTER**
ARCHITECTS, LTD.

700 SOUTH SCHILLER
LITTLE ROCK, AR 72201
501.378.0878 office
501.372.7629 fax

509 W. SPRING STREET, SUITE 150
FAYETTEVILLE, AR 72701
479.444.0473 office
473.251.7216 fax

www.polkstanley.com



- CONSULTANTS:**
- CIVIL ENGINEER: MCCLELLAND ENGINEERS
 - LANDSCAPE ARCHITECT: LARSON BURNS SMITH
 - STRUCTURAL ENGINEER: CROMWELL ENGINEERS INC.
 - MECH., ELEC., PLUMB. ENGINEER: CROMWELL ENGINEERS INC.
 - GLOBAL VILLAGE CONSULTANT CAMBRIDGE SEVEN ASSOCIATES
 - INTERIOR DESIGNER: POLK STANLEY ROWLAND CURZON PORTER ARCHITECTS
 - GENERAL CONTRACTOR: CDI CONTRACTORS, INC.

- NOTES:**
1. ALL CONDUIT SHALL BE ON TOP OF ROOF DECK/
ROUTE INSULATION
 2. ALL WIRING EXPOSED TO VIEW SHALL BE RUN
INSIDE CONDUIT.

ISSUE DATE:
17 SEPTEMBER 07

REVISIONS:

#	DATE	DESCRIPTION
1	28 SEP 07	ADDENDUM 01
2	07 MAY 08	ASB NO. 13
3		


**MURPHY KELLER
EDUCATION CENTER**

**HEIFER
INTERNATIONAL
CENTER**
LITTLE ROCK, ARKANSAS


PSRCP JOB NUMBER:
431E

CONTENTS:
HIGH CEILING PLAN

SHEET NUMBER:
A601a

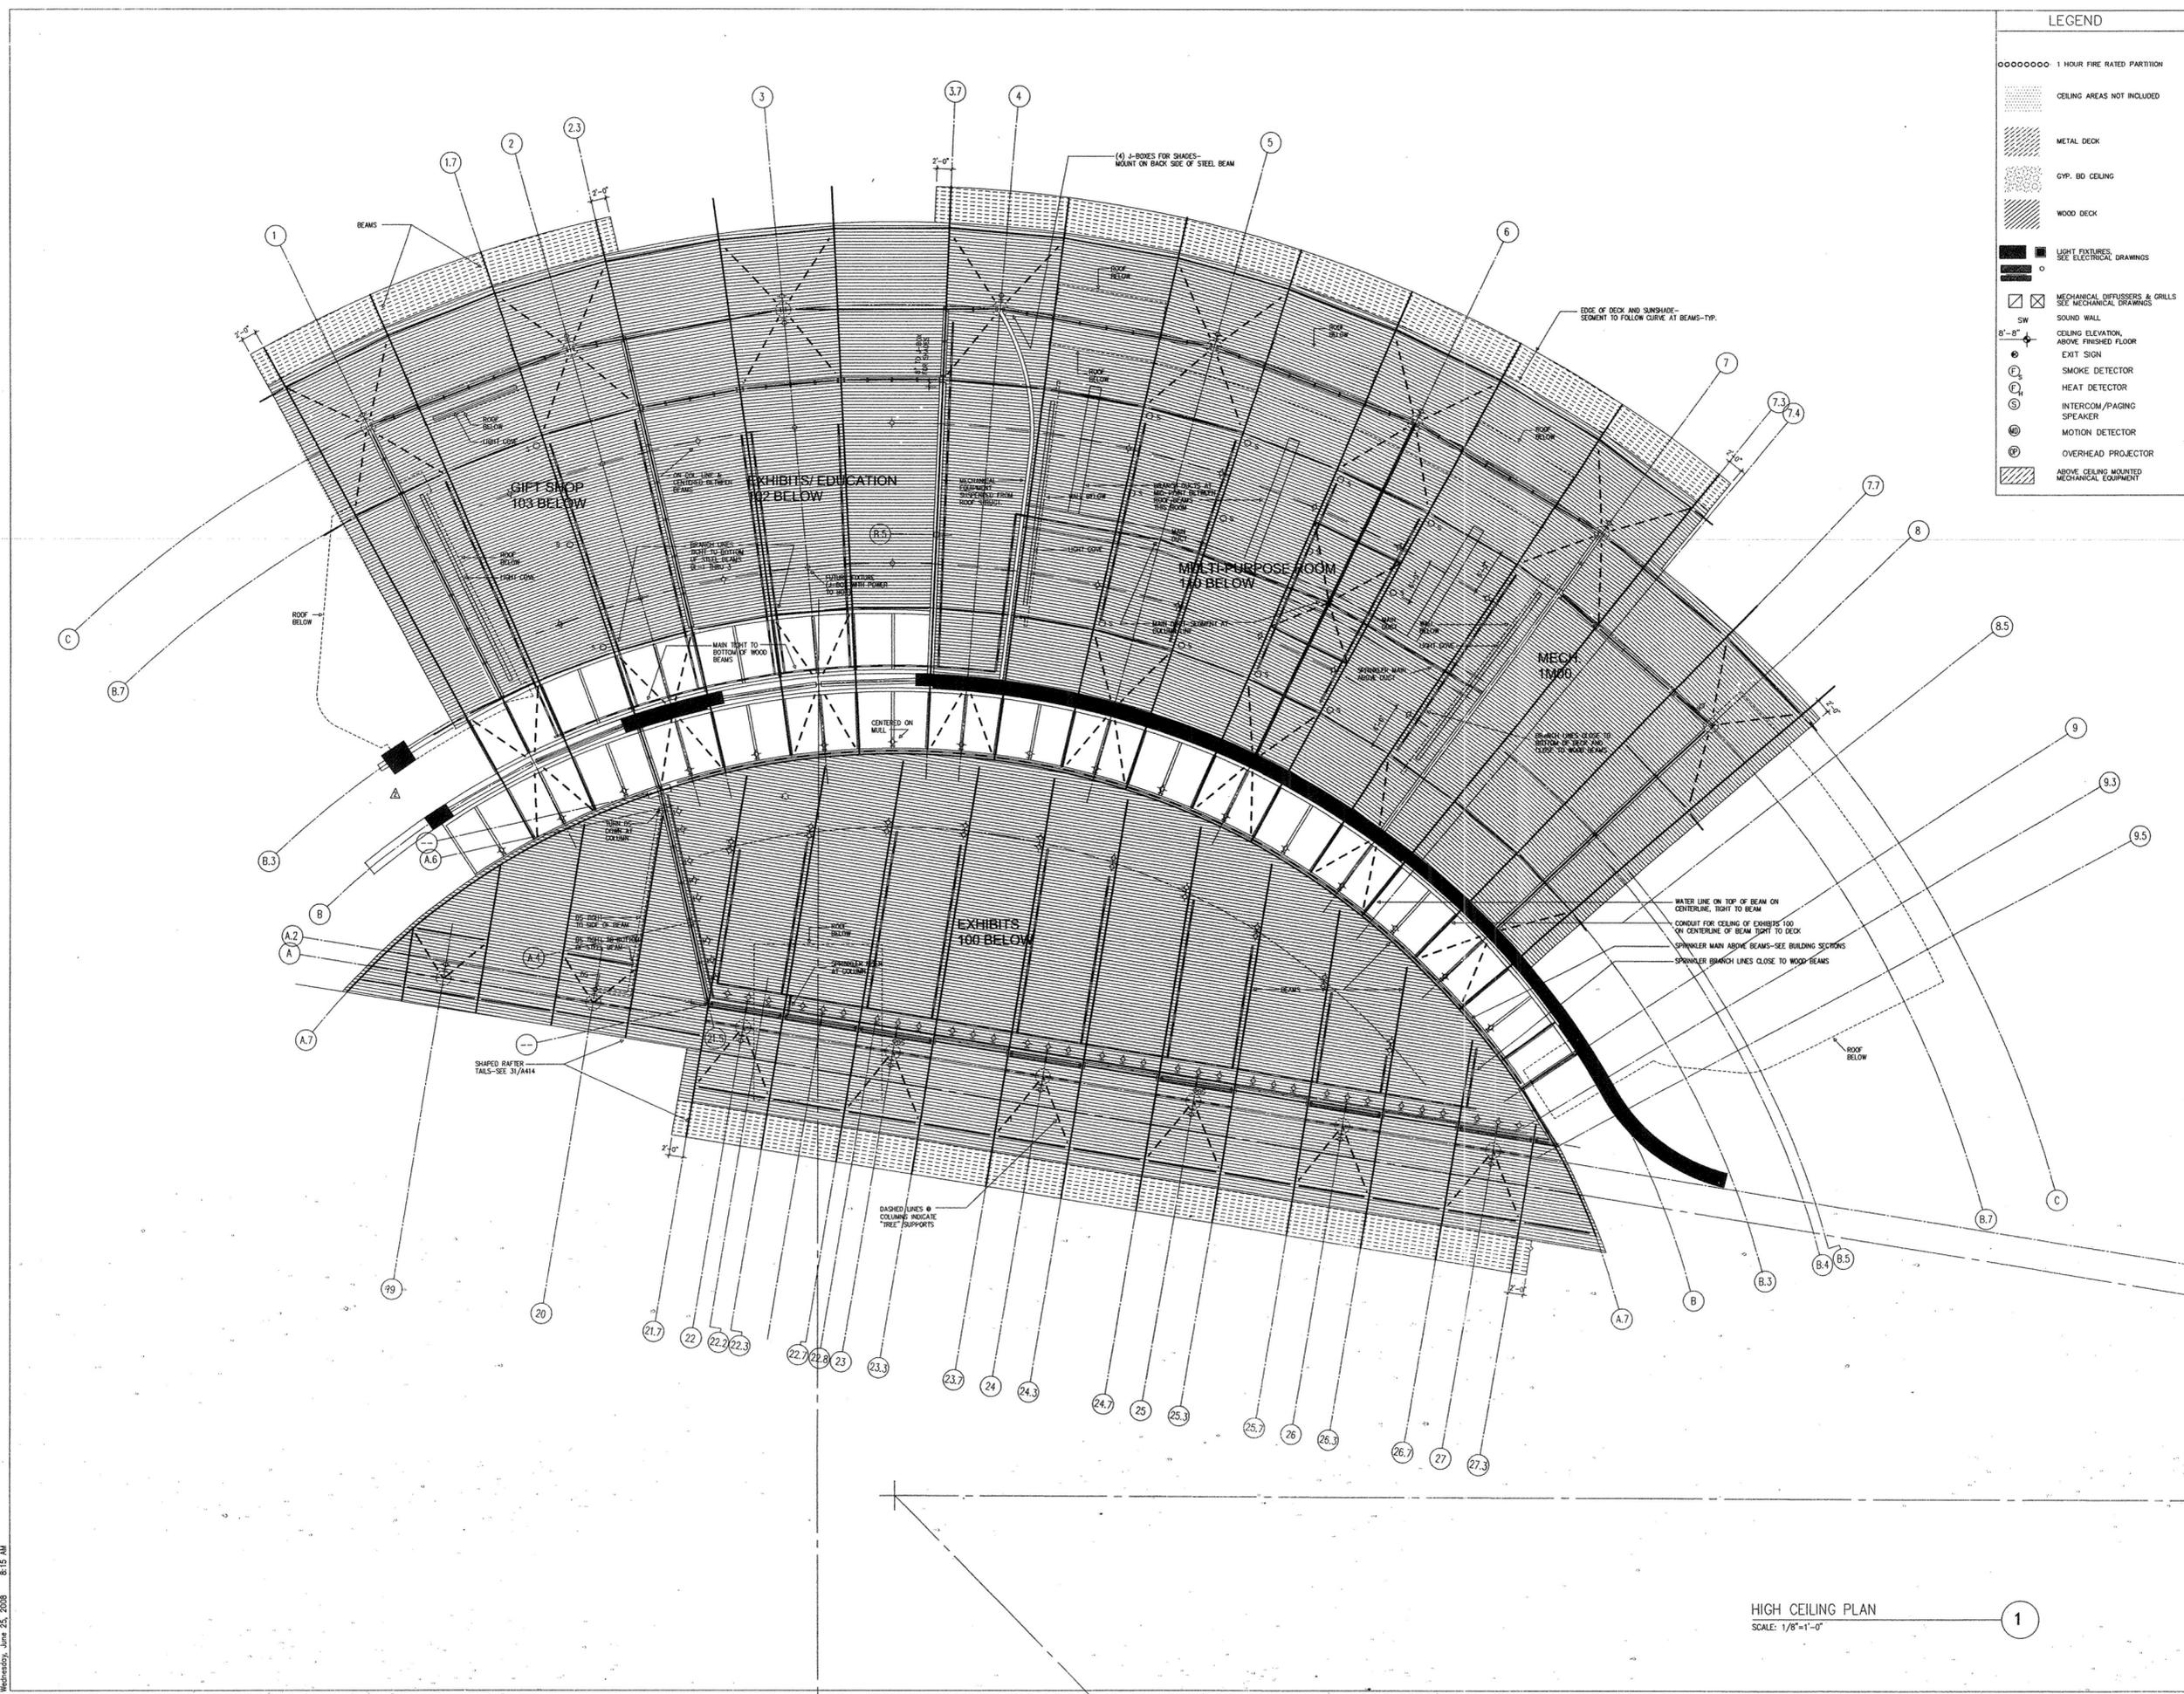

HIGH CEILING PLAN
SCALE: 1/8"=1'-0" 1

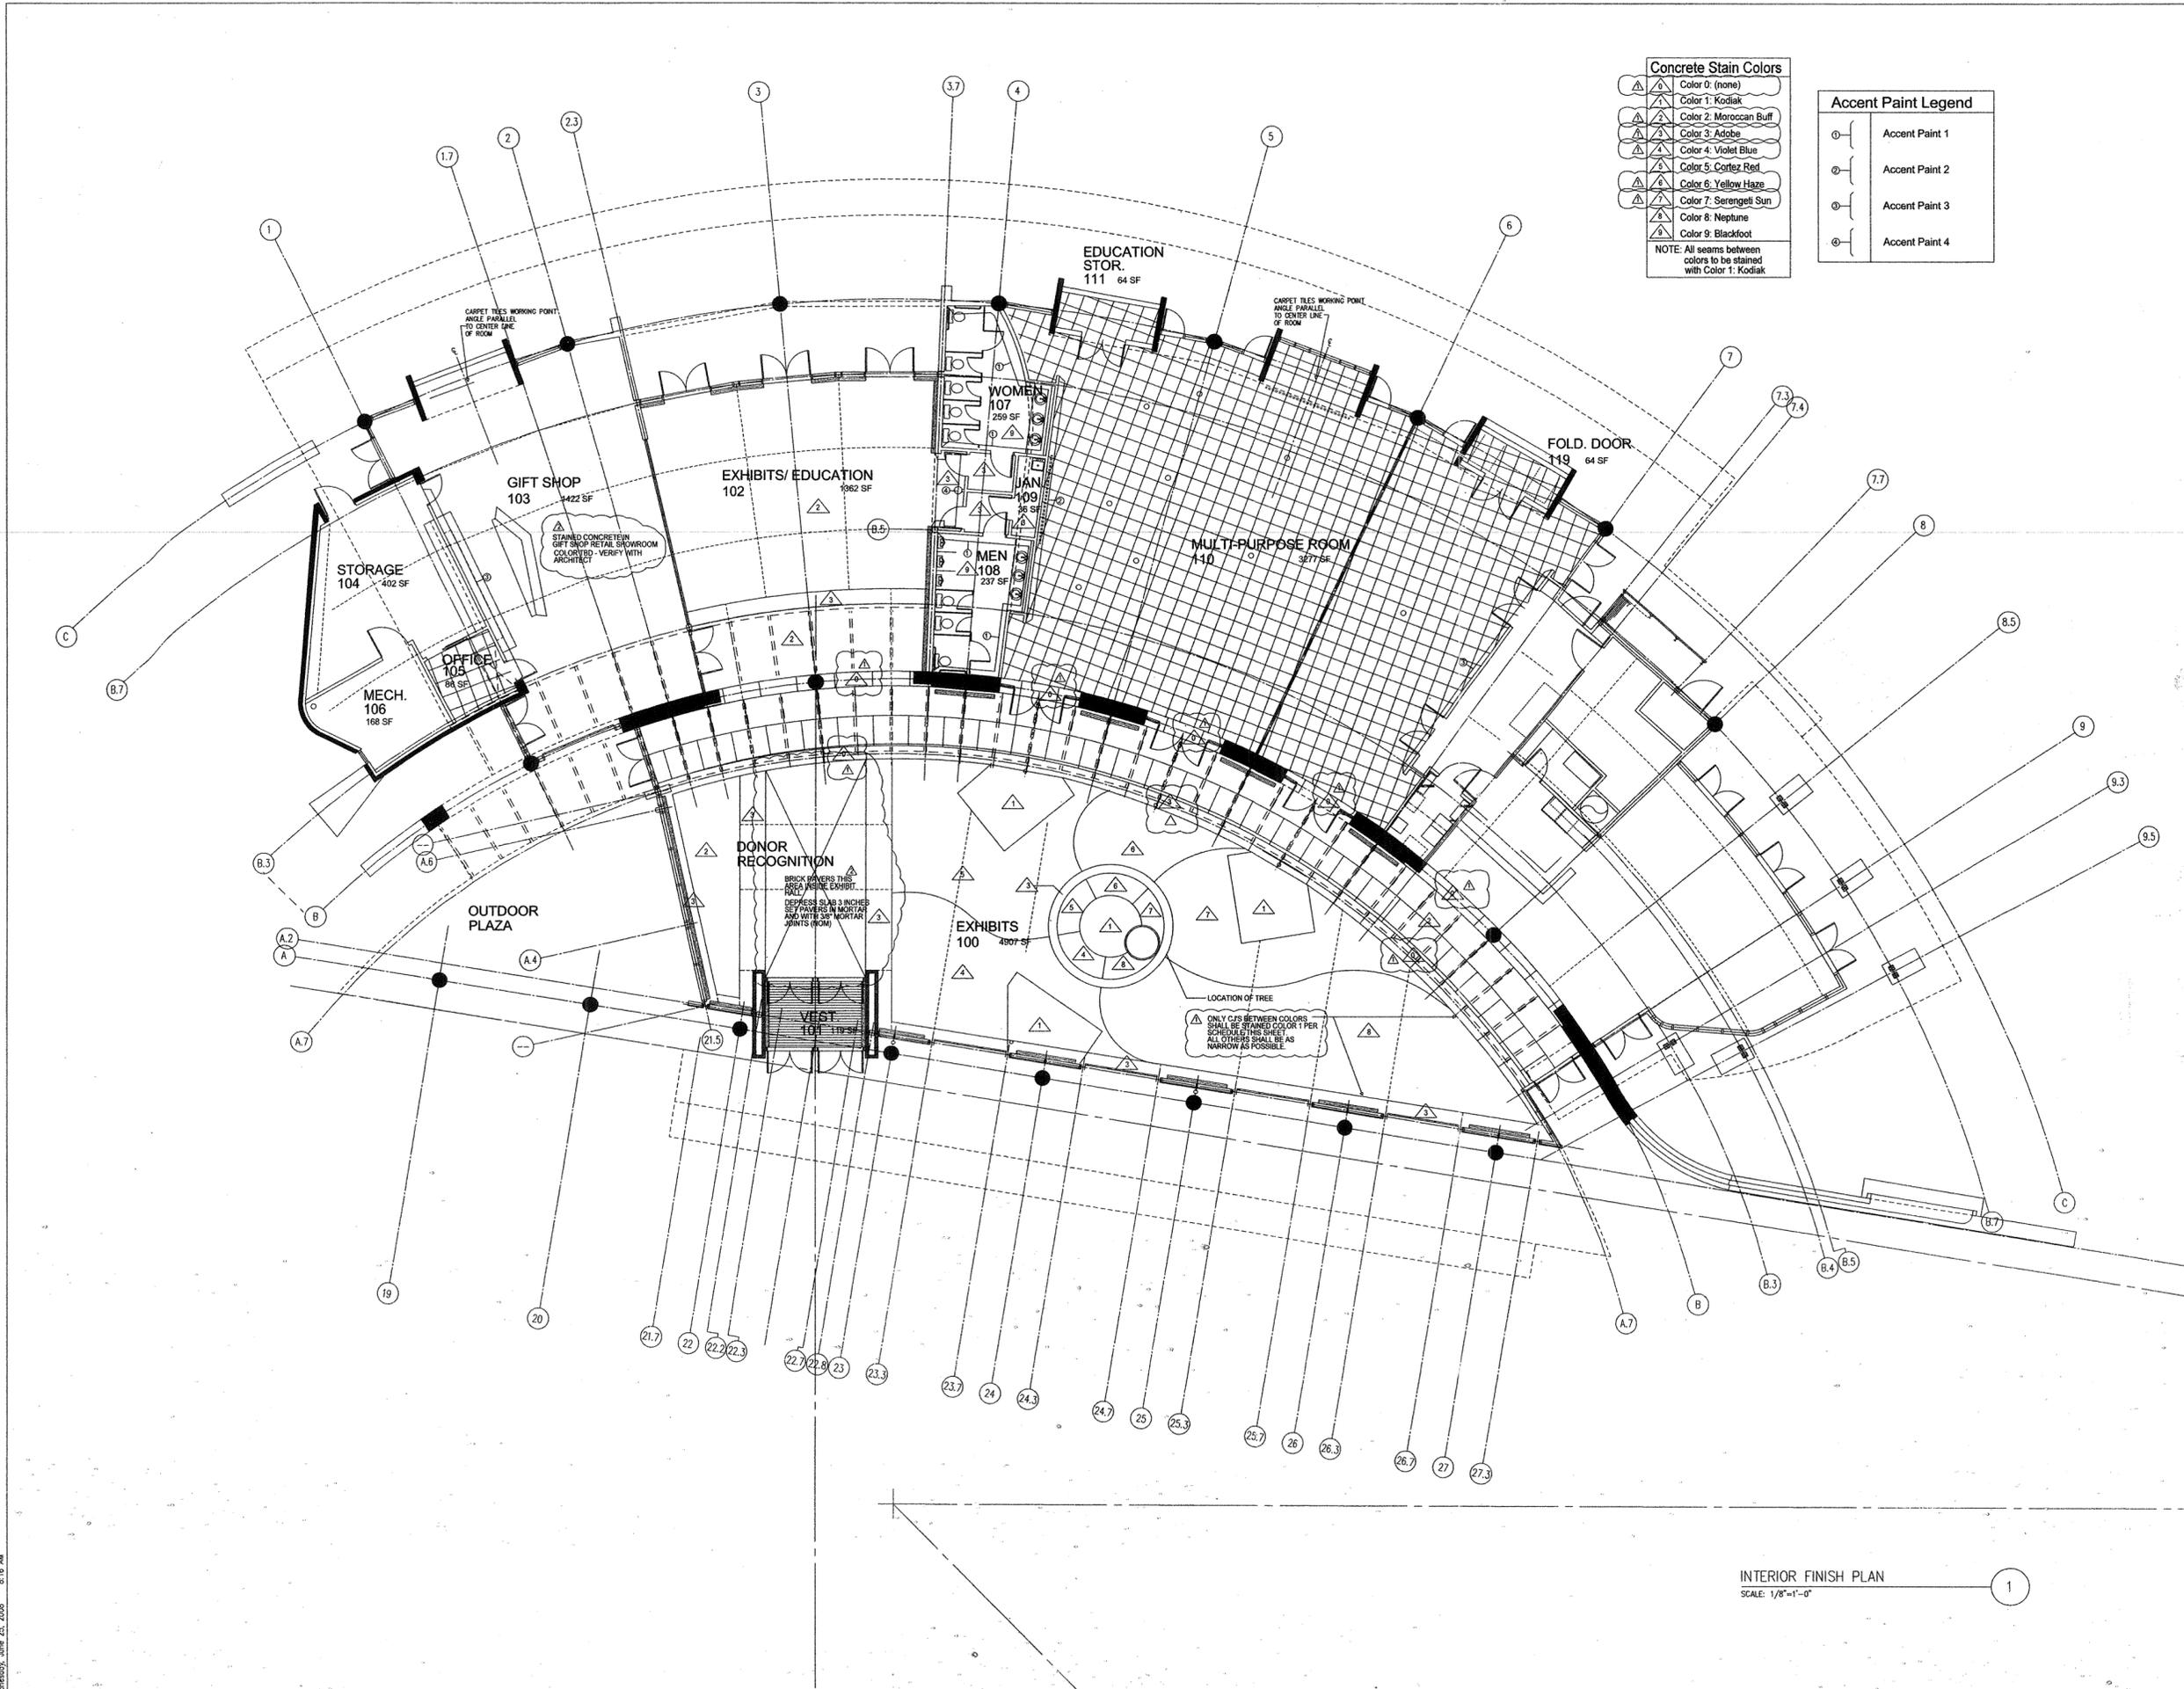

Concrete Stain Colors

- Color 0: (none)
- Color 1: Kodiak
- Color 2: Moroccan Buff
- Color 3: Adobe
- Color 4: Violet Blue
- Color 5: Cortez Red
- Color 6: Yellow Haze
- Color 7: Serengeti Sun
- Color 8: Neptune
- Color 9: Blackfoot

NOTE: All seams between colors to be stained with Color 1: Kodiak

Accent Paint Legend

- Accent Paint 1
- Accent Paint 2
- Accent Paint 3
- Accent Paint 4

**POLK
STANLEY
ROWLAND
CURZON
PORTER**
ARCHITECTS, LTD

700 SOUTH SCHILLER
LITTLE ROCK, AR 72201
501.378.0878 office
501.372.7629 fax

509 W. SPRING STREET, SUITE 151
FAYETTEVILLE, AR 72701
479.444.0473 office
473.251.7216 fax

www.polkstanley.com



- CONSULTANTS:**
- CIVIL ENGINEER: MCLELLAND ENGINEERS
 - LANDSCAPE ARCHITECT: LARSON BURNS SMITH
 - STRUCTURAL ENGINEER: CROMWELL ENGINEERS INC.
 - MECH., ELEC., PLUMB. ENGINEER: CROMWELL ENGINEERS INC.
 - GLOBAL VILLAGE CONSULTANT: CAMBRIDGE SEVEN ASSOCIATES
 - INTERIOR DESIGNER: POLK STANLEY ROWLAND CURZON PORTER ARCHITECTS
 - GENERAL CONTRACTOR: CDI CONTRACTORS, INC.

NOTES:

ISSUE DATE:
17 SEPTEMBER 07

REVISIONS:

#	DATE	DESCRIPTION
1	07 JAN 08	ASJ NO. 08
2	11 JUNE 08	ASJ NO. 15

**MURPHY KELLER
EDUCATION CENTER**

**HEIFER
INTERNATIONAL
CENTER**

LITTLE ROCK, ARKANSAS

PSRCP JOB NUMBER:
431E

CONTENTS:
INTERIOR FINISH PLAN

SHEET NUMBER:
A601b

INTERIOR FINISH PLAN
SCALE: 1/8"=1'-0"

Wednesday, June 26, 2008 8:16 AM



CONSULTANTS:

CIVIL ENGINEER:
MCCELLEND ENGINEERS

LANDSCAPE ARCHITECT:
LARSON BURNS SMITH

STRUCTURAL ENGINEER:
CROMWELL ENGINEERS INC.

MECH., ELEC., PLUMB. ENGINEER:
CROMWELL ENGINEERS INC.

GLOBAL VILLAGE CONSULTANT
CAMBRIDGE SEVEN ASSOCIATES

INTERIOR DESIGNER:
POLK STANLEY ROWLAND
CURZON PORTER ARCHITECTS

GENERAL CONTRACTOR:
CDI CONTRACTORS, INC.

NOTES:

ISSUE DATE:
17 SEPTEMBER 07

REVISIONS:


#	DATE:	DESCRIPTION:

**HEIFER
INTERNATIONAL
CENTER**
LITTLE ROCK, ARKANSAS

PSRCP JOB NUMBER:
431E

CONTENTS:
INTERIOR ELEVATIONS

SHEET NUMBER:
A703

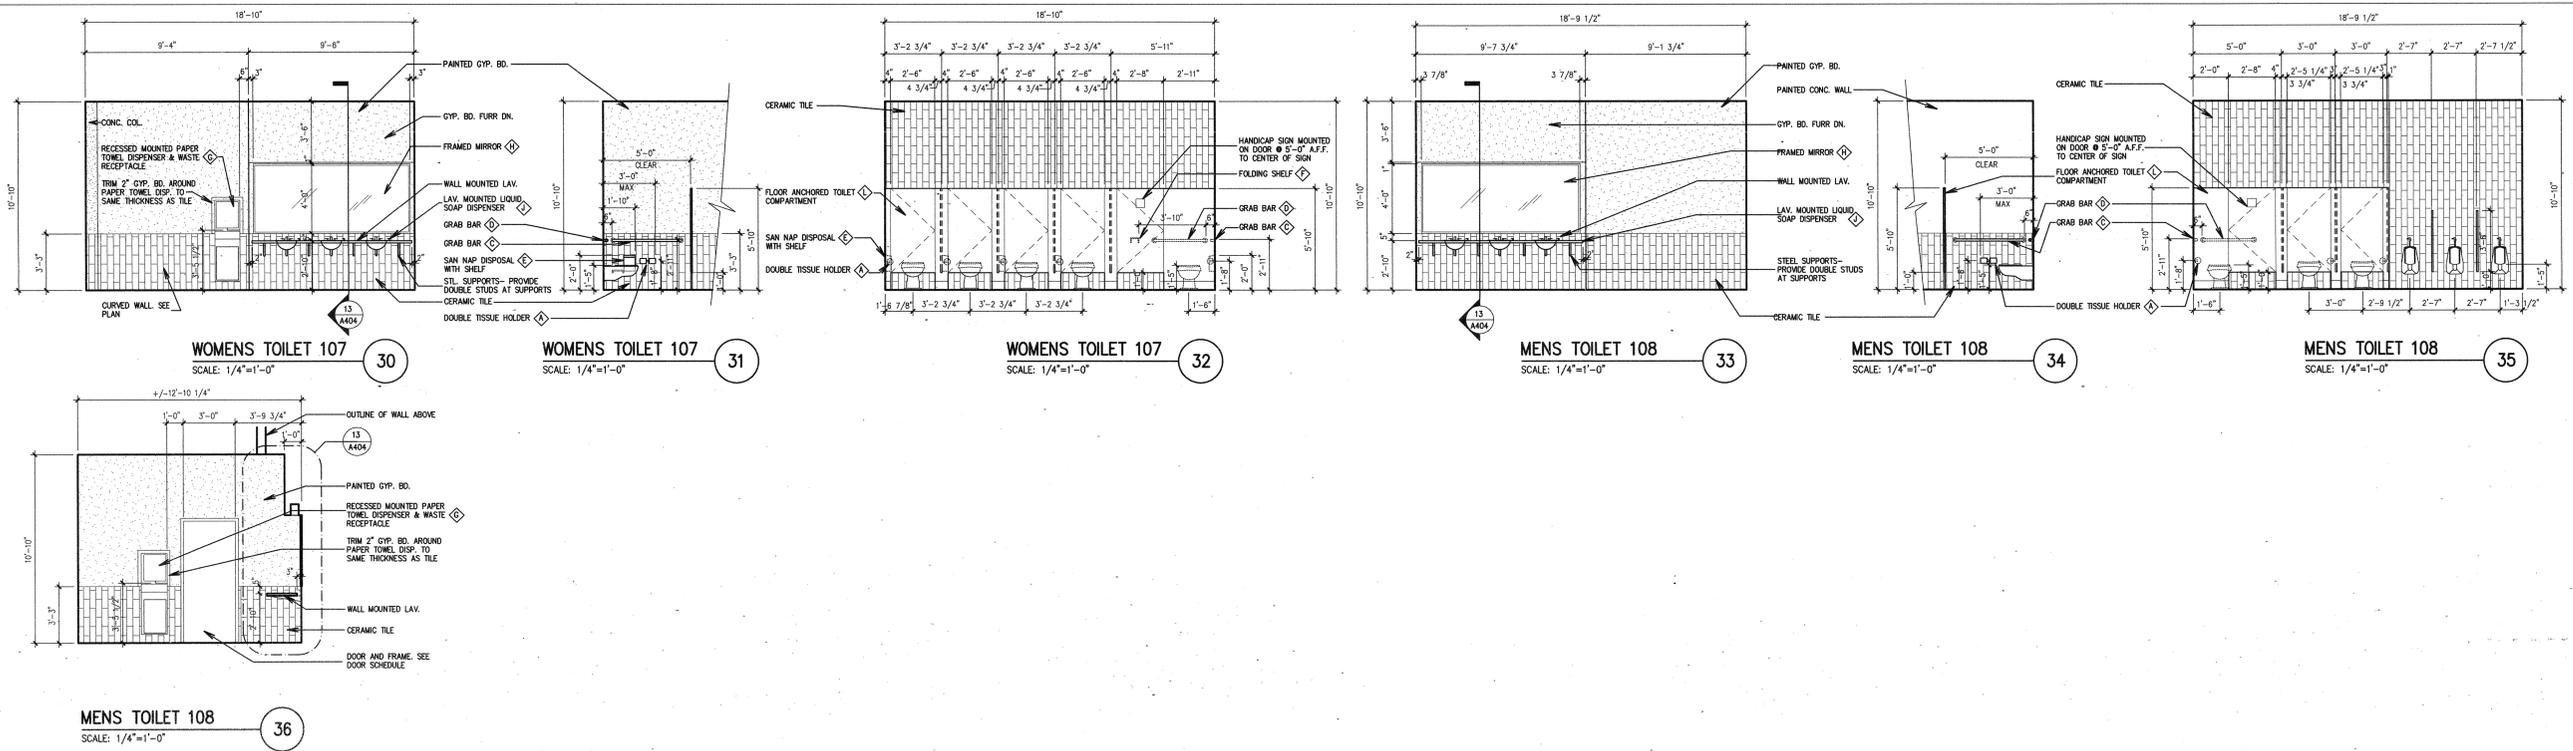

DOOR & FRAME SCHEDULE																
DOOR NUMBER	ROOM NAME	TYPE	DOOR		FRAME		HARDWARE	REMARKS	ROOM NUMBER	ROOM NAME	FLOOR	BASE	WALLS	CEILING	REMARKS	
			WIDTH	HEIGHT	THICKNESS	HEAD DETAIL										JAMB DETAIL
100	EXHIBITS	A	3'-0" (PAIR)	8'-0"	1 3/4"	AL 1	---	---	100	EXHIBITS	CONC. - ST. WITH PATTERN	(NONE)	CONC./CW/WW	EXP. STRUCT.		
100a	EXHIBITS	A	3'-0" (PAIR)	8'-0"	1 3/4"	AL 1	---	---	100	EXHIBITS	CONC. - ST. WITH PATTERN	(NONE)	CONC./CW/WW	EXP. STRUCT.	DRIP AT HEAD, PANIC	
100b	EXHIBITS	SEE 10/A201	9'-5"	8'-0"	2"	---	---	---	101	VESTIBULE	ENTRY MAT	(NONE)	STONE	EXP. STRUCT.		
100c	EXHIBITS	SEE 10/A201	9'-5"	8'-0"	2"	---	---	---	102	EXHIBITS/ EDUCATION	CONC. - ST WITH PATTERN	(NONE)/ B1 @ RESTROOM	WOOD/CW/WW ACCENT PAINT	EXP. STRUCT./ GB @ RESTROOM VEST.	ACCENT PAINT	
100d	EXHIBITS	SEE 10/A201	9'-5"	8'-0"	2"	---	---	---	103	GIFT SHOP	CARPET TILE	B1	CONC./CW/WW/GB	EXP. STRUCT.	ACCENT PAINT	
100e	EXHIBITS	SEE 10/A201	9'-5"	8'-0"	2"	---	---	---	104	VESTIBULE	CONC.	B2	GB	EXP. STRUCT.		
101	VESTIBULE	A	3'-0" (PAIR)	8'-0"	1 3/4"	AL 1	---	---	105	OFFICE	CARPET TILE	B2	GB	EXP. STRUCT.		
101a	VESTIBULE	A	3'-0" (PAIR)	8'-0"	1 3/4"	AL 1	---	---	106	MECHANICAL	CONC.	B2	GB	EXP. STRUCT.		
101b	VESTIBULE	A	3'-0" (PAIR)	8'-0"	1 3/4"	AL 1	---	---	107	WOMEN	CONC. - ST	T1	T1 (75%) & T2 (25%)	GB	EPOXY PAINT ACCENT PAINT	
101c	VESTIBULE	A	3'-0" (PAIR)	8'-0"	1 3/4"	AL 1	---	---	108	MEN	CONC. - ST	T1	T1 (75%) & T2 (25%)	GB	EPOXY PAINT ACCENT PAINT	
102	EXHIBITS/ EDUCATION	A	3'-0" (PAIR)	8'-0"	1 3/4"	AL 1	---	---	109	JANITOR	CONC. - ST	B2	GB	EXP. STRUCT.	EPOXY PAINT	
102a	EXHIBITS/ EDUCATION	A	3'-0" (PAIR)	8'-0"	1 3/4"	AL 1	---	---	110	MULTI-PURPOSE ROOM	CARPET TILE A, B, C, & D RANDOM MIX	B1	CONC./CW/GB	EXP. STRUCT.	ACCENT PAINT	
102b	EXHIBITS/ EDUCATION	A	3'-0" (PAIR)	8'-0"	1 3/4"	AL 1	---	---	111	STORAGE	CARPET TILE A, B, C, & D RANDOM MIX	B2	GB	EXP. STRUCT.		
103	GIFT SHOP	A	3'-0" (PAIR)	8'-0"	1 3/4"	AL 1	---	---	112	FURNITURE STORAGE	CONC.	B2	GB	EXP. STRUCT.		
103a	GIFT SHOP	A	3'-0" (PAIR)	8'-0"	1 3/4"	AL 1	---	---	113	SERVER	CONC.	B2	GB	EXP. STRUCT.		
103b	GIFT SHOP	A	3'-0" (PAIR)	8'-0"	1 3/4"	AL 1	---	---	114	FOOD SERV.	CONC. - ST.	B1	CONC./GB	EXP. STRUCT.	EPOXY PAINT	
103c	GIFT SHOP	SEE 33/A201	10'-0"	8'-0"	2"	---	---	---	115	CAFE	ACCENT PAINT	CONC. - ST.	B1	CONC./CW/GB/WD-1	EXP. STRUCT.	EPOXY PAINT
104	STORAGE	C	3'-0"	7'-0"	1 3/4"	AL 2	---	---	116	CATERING KITCHEN	CONC.	B2	GB	EXP. STRUCT.	EPOXY PAINT	
104a	STORAGE	C	4'-0"	8'-0"	1 3/4"	AL 2	---	---	117	WATER	CONC.	B2	GB	EXP. STRUCT.		
105	OFFICE	C	3'-0"	7'-0"	1 3/4"	AL 2	---	---	118	ELECTRICAL	CONC.	B2	PLYWD.-1	EXP. STRUCT.		
105a	OFFICE	B	3'-0"	7'-0"	1 3/4"	AL 2	---	---	119	FOLDING DOOR	CARPET TILE A, B, C, & D RANDOM MIX	B2	PLYWD.-1	EXP. STRUCT.		
106	MECHANICAL	B	4'-0"	7'-0"	1 3/4"	AL 1	---	---	1M00	MECHANICAL MEZZANINE	CONC.	B2	GB-TB	EXP. STRUCT. (DO NOT FINISH)		
107	WOMEN	B	3'-0"	7'-0"	1 3/4"	AL 1	---	---								
107a	WOMEN	B	3'-0"	7'-0"	1 3/4"	AL 1	---	---								
108	MEN	B	3'-0"	7'-0"	1 3/4"	AL 1	---	---								
108a	MEN	B	3'-0"	7'-0"	1 3/4"	AL 1	---	---								
109	JANITOR	B	3'-0"	7'-0"	1 3/4"	AL 1	---	---								
110	MULTI-PURPOSE ROOM	F	3'-6" (PAIR)	8'-0"	1 3/4"	WD-3	---	---								
110a	MULTI-PURPOSE ROOM	F	3'-6" (PAIR)	8'-0"	1 3/4"	WD-3	---	---								
110b	MULTI-PURPOSE ROOM	A	3'-0"	8'-0"	1 3/4"	AL 1	---	---								
110c	MULTI-PURPOSE ROOM	A	3'-0"	8'-0"	1 3/4"	AL 1	---	---								
110d	MULTI-PURPOSE ROOM	A	3'-0"	8'-0"	1 3/4"	AL 1	---	---								
110e	MULTI-PURPOSE ROOM	A	3'-0"	8'-0"	1 3/4"	AL 1	---	---								
110f	MULTI-PURPOSE ROOM	A	3'-0"	8'-0"	1 3/4"	AL 1	---	---								
110g	MULTI-PURPOSE ROOM	A	3'-0" (PAIR)	8'-0"	1 3/4"	AL 1	---	---								
111	STORAGE	B	3'-0" (PAIR)	8'-0"	1 3/4"	AL 1	---	---								
112	STORAGE	B	4'-0"	7'-0"	1 3/4"	AL 1	---	---								
113	SERVER	B	4'-0"	8'-0"	1 3/4"	AL 1	---	---								
114	FOOD SERV.	C	4'-0"	7'-0"	1 3/4"	AL 1	---	---								
114a	FOOD SERV.	B	3'-0"	7'-0"	1 3/4"	AL 1	---	---								
115	CAFE	A	3'-0" (PAIR)	8'-0"	1 3/4"	AL 1	---	---								
115a	CAFE	A	3'-0" (PAIR)	8'-0"	1 3/4"	AL 1	---	---								
115b	CAFE	A	3'-0" (PAIR)	8'-0"	1 3/4"	AL 1	---	---								
115	CAFE	A	3'-0" (PAIR)	8'-0"	1 3/4"	AL 1	---	---								
116	KITCHEN	D	4'-0"	7'-0"	1 3/4"	HM 2	30/A801	20/A801								
116a	KITCHEN	C	3'-0" (PAIR)	8'-0"	1 3/4"	AL 1	37/A801	27/A801								
116b	KITCHEN	C	3'-0" (PAIR)	8'-0"	1 3/4"	AL 1	37/A801	27/A801								
117	WATER	D	4'-0"	7'-0"	1 3/4"	H.M.2	30/A801	20/A801								
1M00	MECHANICAL MEZZANINE	D	3'-0"	7'-0"	1 3/4"	H.M.2	---	---								
119	FOLDING DOOR RM.	B	3'-0" (PAIR)	8'-0"	1 3/4"	AL 1	---	---								

FINISH SCHEDULE									
ROOM NUMBER	ROOM NAME	FLOOR	BASE	WALLS	CEILING	REMARKS			
100	EXHIBITS	CONC. - ST. WITH PATTERN	(NONE)	CONC./CW/WW	EXP. STRUCT.				
101	VESTIBULE	ENTRY MAT	(NONE)	STONE	EXP. STRUCT.				
102	EXHIBITS/ EDUCATION	CONC. - ST WITH PATTERN	(NONE)/ B1 @ RESTROOM	WOOD/CW/WW ACCENT PAINT	EXP. STRUCT./ GB @ RESTROOM VEST.	ACCENT PAINT			
103	GIFT SHOP	CARPET TILE	B1	CONC./CW/WW/GB	EXP. STRUCT.	ACCENT PAINT			
104	STORAGE	CONC.	B2	GB	EXP. STRUCT.				
105	OFFICE	CARPET TILE	B2	GB	EXP. STRUCT.				
106	MECHANICAL	CONC.	B2	GB	EXP. STRUCT.				
107	WOMEN	CONC. - ST	T1	T1 (75%) & T2 (25%)	GB	EPOXY PAINT ACCENT PAINT			
108	MEN	CONC. - ST	T1	T1 (75%) & T2 (25%)	GB	EPOXY PAINT ACCENT PAINT			
109	JANITOR	CONC. - ST	B2	GB	EXP. STRUCT.	EPOXY PAINT			
110	MULTI-PURPOSE ROOM	CARPET TILE A, B, C, & D RANDOM MIX	B1	CONC./CW/GB	EXP. STRUCT.	ACCENT PAINT			
111	STORAGE	CARPET TILE A, B, C, & D RANDOM MIX	B2	GB	EXP. STRUCT.				
112	FURNITURE STORAGE	CONC.	B2	GB	EXP. STRUCT.				
113	SERVER	CONC.	B2	GB	EXP. STRUCT.				
114	FOOD SERV.	CONC. - ST.	B1	CONC./GB	EXP. STRUCT.	EPOXY PAINT			
115	CAFE	ACCENT PAINT	CONC. - ST.	B1	CONC./CW/GB/WD-1	EXP. STRUCT.	EPOXY PAINT		
116	CATERING KITCHEN	CONC.	B2	GB	EXP. STRUCT.	EPOXY PAINT			
117	WATER	CONC.	B2	GB	EXP. STRUCT.				
118	ELECTRICAL	CONC.	B2	PLYWD.-1	EXP. STRUCT.				
119	FOLDING DOOR	CARPET TILE A, B, C, & D RANDOM MIX	B2	PLYWD.-1	EXP. STRUCT.				
1M00	MECHANICAL MEZZANINE	CONC.	B2	GB-TB	EXP. STRUCT. (DO NOT FINISH)				

FINISHES KEY

CONC.	CONC. (SEAL)
CONC. - ST	CONC. - STAIN
CW	CURTAIN WALL
WW	WINDOW WALL
EXP STRUCT	EXPOSED STRUCTURE
GB	GYPSUM BOARD
PLYWD.-1	PLYWOOD (SEAL)
PLYWD.-2	PLYWOOD (PAINT)
GB-TAB	GYPSUM BOARD, TAPE & BEAD ONLY
B1	STAINED WD. BASE: 1X6 MAPLE (SEE DTL.1)
B2	VINYL BASE
T1	TILE TYPE 1 - FIELD
T2	TILE TYPE 2 - ACCENT
WD-1	WOOD SLATS

- GENERAL FINISH NOTES**
1. STAIN & SEAL ALL WOOD STRUCTURAL MEMBERS, INCLUDING WOOD DECK.
 2. STAIN & SEAL ALL WOOD SLATS
 3. PAINT ALL STRUCTURAL STEEL EXPOSED TO VIEW (UNLESS NOTED OTHERWISE)
 4. DO NOT PAINT METAL DECK
 5. PAINT ALL BUILDING SYSTEMS EXPOSED TO VIEW (UNLESS OTHERWISE NOTED) EXCEPT FOR DUETS
 6. SEAL ALL STRUCTURAL CONC. WALLS & COLUMNS
 7. PROVIDE WALL BASES FOR ONLY FOR GYP. BD. WALLS
 8. PROVIDE SEALER FOR ALL STONE VENEER
 9. PAINT ALL GYP. BD. & PLYWOOD (UNLESS OTHERWISE NOTED)

GLAZING SCHEDULE

TYPE G1: CLEAR INSULATED
 TYPE G2: INSULATED FROSTED
 TYPE G3: (SKYLIGHT)
 TYPE G4: 1/4" CLEAR FLOAT
 TYPE G5: 1/4" FROSTED

GENERAL NOTES:









1. ALL EXTERIOR GLAZING SHALL BE CLEAR INSULATED (TYPE G1) UNLESS NOTED OTHERWISE.
2. ALL INTERIOR GLAZING SHALL BE CLEAR FLOAT (TYPE G4) UNLESS NOTED OTHERWISE.
3. SEE DRAWINGS FOR ALL LOCATIONS WITH SAFETY GLAZING - ("T").

PARTITION TYPES:

SYMBOL	DESCRIPTION
1	3 5/8" X 20 GA. METAL STUDS @ 16" O.C. W/ 5/8" GYP. BD. EACH SIDE
1A	SOUND PARTITION- 3" SOUND BATTS / SEAL TOP & BOTTOM OF PARTITION
1B	SOUND PARTITION- (SEE 1A) - GYP. BD. ONE SIDE ONLY ABOVE FINISH CEILING.
2	8" X 20 GA. METAL STUDS @ 16" O.C. W/ 5/8" GYP. BD. EACH SIDE
2A	SOUND PARTITION- 3" SOUND BATTS / SEAL TOP & BOTTOM OF PARTITION
3	SOUND PARTITION- 3 5/8" X 20 GA. MTL. STUDS @ 16" O.C. W/ 2 LAYERS 5/8" GYP. BD. EA. SIDE/ 3" SOUND BATTS/ SEAL TOP AND BOTTOM OF PARTITION.
4	3 5/8" X 20 GA. METAL STUDS @ 16" O.C. W/ 5/8" GYP. BD. ONE SIDE
5	6" X 20 GA. METAL STUDS @ 16" O.C. W/ 5/8" GYP. BD. BOTH SIDES

GENERAL PARTITION NOTES:

 1. ALL PARTITION TO DECK UNLESS NOTED OTHERWISE.
2. PROVIDE "GREEN" GYP. BD. ON INSIDE FACE OF STUDS IN ROOMS 107, 108, 109.
3. PROVIDE TAIL BACKER BD. IN LIEU OF GYP. BD. IN ALL LOCATIONS WITH TILE.

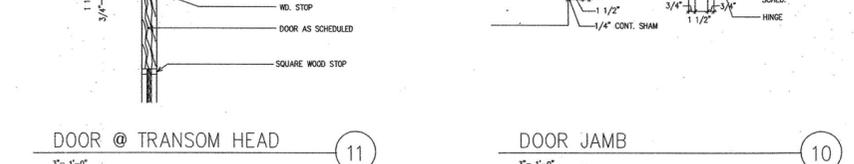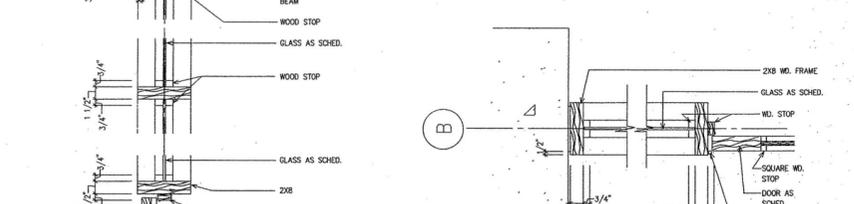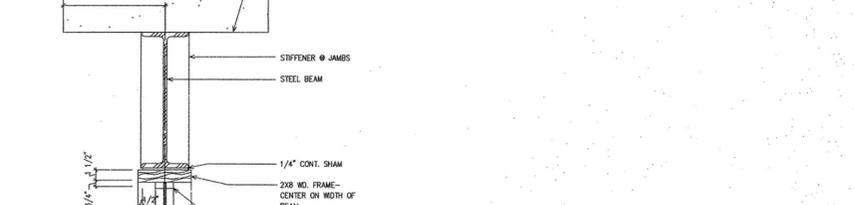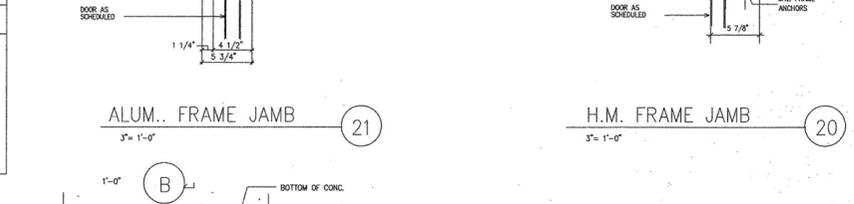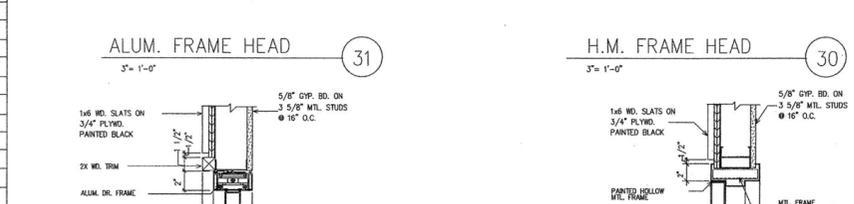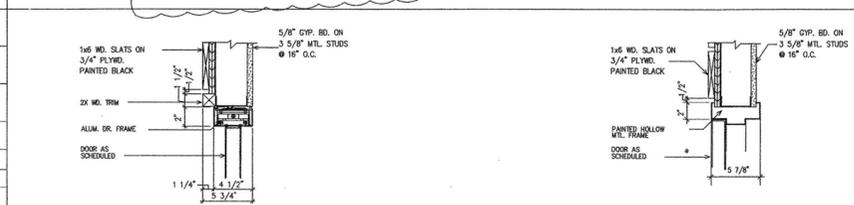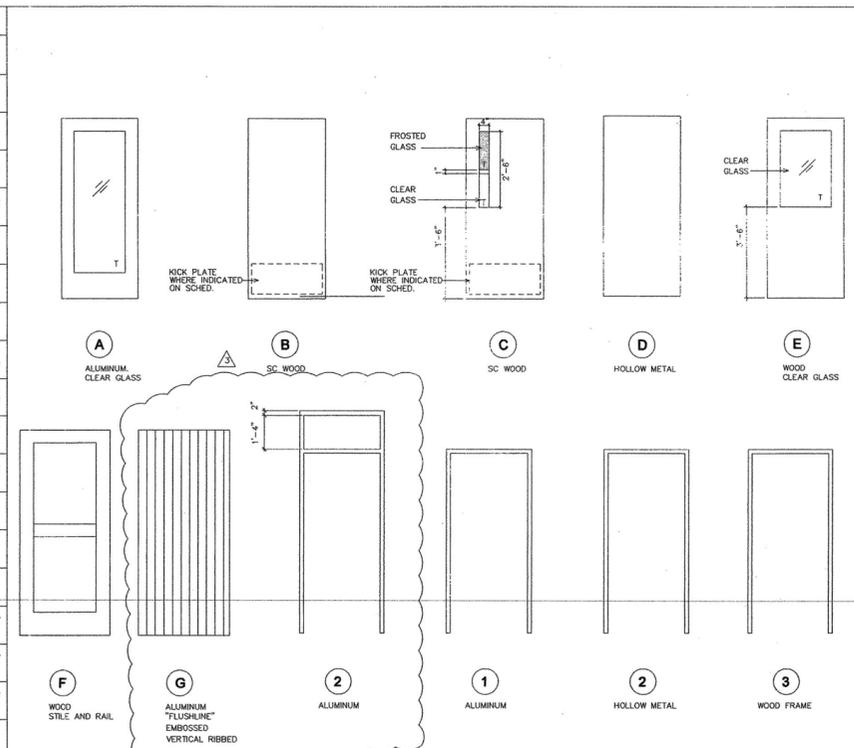

POLK STANLEY ROWLAND CURZON PORTER ARCHITECTS, LTD.

700 SOUTH SCHILLER
 LITTLE ROCK, AR 72201
 501.378.0878 office
 501.372.7629 fax

509 W. SPRING STREET, SUITE 150
 FAYETTEVILLE, AR 72701
 479.444.0473 office
 473.251.7216 fax

www.polkstanley.com

CONSULTANTS:
 CIVIL ENGINEER: MCCLELLAND ENGINEERS
 LANDSCAPE ARCHITECT: LARSON BURNS SMITH
 STRUCTURAL ENGINEER: CROMWELL ENGINEERS INC.
 MECH., ELEC., PLUMB. ENGINEER: CROMWELL ENGINEERS INC.
 GLOBAL VILLAGE CONSULTANT: CAMBRIDGE SEVEN ASSOCIATES

INTERIOR DESIGNER:
 POLK STANLEY ROWLAND CURZON PORTER ARCHITECTS

GENERAL CONTRACTOR:
 CDI CONTRACTORS, INC.

NOTES:

ISSUE DATE:
 17 SEPTEMBER 07

REVISIONS:

#	DATE	DESCRIPTION
1	07 JAN. 08	ASH NO. 1
2	01 MARCH 08	ASH NO. 3
3	25 AUG 08	ASH NO. 19

MURPHY KELLER EDUCATION CENTER

HEIFER INTERNATIONAL CENTER
 LITTLE ROCK, ARKANSAS

PSRCP JOB NUMBER:
 431E

CONTENTS:
 FINISH SCHED, PARTITION TYPES, DOOR SCHED.

SHEET NUMBER:
A801

HEIFER INTERNATIONAL CENTER

MURPHY KELLER EDUCATION CENTER

LITTLE ROCK, ARKANSAS

PROJECT NO. 431E
SEPTEMBER 17, 2007

100% CONSTRUCTION DOCUMENTS - VOLUME 2



v1

v2

v3

<p>GENERAL</p> <p>G000 COVER SHEET WITH INDEX TO DRAWINGS</p> <p>CIVIL</p> <p>C201 EROSION CONTROL AND DEMOLITION PLAN C202 SITE EROSION CONTROL DETAILS</p> <p>C301 SITE PLAN C302 SITE PAVING DETAILS</p> <p>C401 SITE LAYOUT PLAN</p> <p>C501 SITE DRAINAGE PLAN C502 SITE GRADING PLAN C503 SITE DRAINAGE DETAILS</p> <p>C601 SITE UTILITY PLAN C602 SITE UTILITY DETAILS</p> <p>LANDSCAPE</p> <p>L100 COMMONS SITE AND LAYOUT PLAN L101 COMMONS GRADING AND DRAINAGE PLAN L102 NORTH WETLAND SITE AND LAYOUT PLAN L103 NORTH WETLAND GRADING AND DRAINAGE PLAN L104 SITEWORK DETAILS L105 SITEWORK DETAILS</p> <p>L200 PARKING LOT PLANTING PLAN L201 COMMONS PLANTING PLAN L202 NORTH WETLANDS PLANTING PLAN L203 NORTH WETLANDS AND COMMONS PLANT LIST AND PLANTING DETAILS</p> <p>L300 PARKING LOT IRRIGATION PLAN L301 COMMONS AND THIRD STREET EXTENSION IRRIGATION PLAN L302 IRRIGATION DETAILS</p>	<p>GENERAL</p> <p>G000 COVER SHEET WITH INDEX TO DRAWINGS G001 GENERAL DATA SHEET</p> <p>ARCHITECTURAL</p> <p>A100 SITE PLAN A101 FLOOR PLAN A101a MECHANICAL MEZZANINE FLOOR PLAN A102 ROOF PLAN</p> <p>A201 BUILDING ELEVATIONS A202 BUILDING ELEVATIONS</p> <p>A301 BUILDING SECTIONS A302 BUILDING SECTIONS</p> <p>A401 WALL SECTIONS A402 WALL SECTIONS A403 WALL SECTIONS A404 WALL SECTIONS A405 WALL SECTIONS A406 WALL SECTIONS A407 WALL SECTIONS A408 WALL SECTIONS A409 WALL SECTIONS A410 ROOF DETAILS A411 STEEL CONNECTION DETAILS A412 STEEL CONNECTION DETAILS A413 STEEL CONNECTION DETAILS A414 STEEL CONNECTION DETAILS A415 MISCELLANEOUS DETAILS</p> <p>A501 ENLARGED PLANS</p> <p>A601 LOW CEILING PLAN A601a HIGH CEILING PLAN A601b FLOOR FINISH PLAN</p> <p>A701 INTERIOR ELEVATIONS A702 INTERIOR ELEVATIONS A703 INTERIOR ELEVATIONS</p> <p>A801 FINISH SCHEDULE, PARTITION TYPES, DOOR SCHEDULE A802 INTERIOR FINISH PLAN</p>	<p>STRUCTURAL</p> <p>S001 GENERAL NOTES S101 FOUNDATION PLAN S102 FIRST FLOOR SLAB PLAN S103 LOW ROOF/ MEZZANINE FRAMING PLAN S104 ROOF FRAMING PLAN</p> <p>S201 BRACE ELEVATION S202 BRACE ELEVATION S203 BRACING CONNECTION DETAILS S204 BRACING CONNECTION DETAILS</p> <p>S301 FOUNDATION SECTION AND DETAILS S302 FOUNDATION SECTION AND DETAILS S303 FOUNDATION SECTIONS AND DETAILS</p> <p>S401 TYPICAL CONNECTION DETAILS</p> <p>S501 SECTIONS AND DETAILS S502 SECTIONS AND DETAILS</p>		<p>GENERAL</p> <p>G000 COVER SHEET WITH INDEX TO DRAWINGS</p> <p>MECHANICAL</p> <p>M001 MECHANICAL LEGEND M101 MECHANICAL FLOOR PLAN M101a MECHANICAL MEZZANINE FLOOR PLAN M102 MECHANICAL DETAILS</p> <p>M201 MECHANICAL DETAILS M202 MECHANICAL DETAILS M203 MECHANICAL DETAILS</p> <p>M301 MECHANICAL CONTROLS M302 MECHANICAL CONTROLS</p> <p>M401 MECHANICAL SCHEDULES</p>	<p>PLUMBING</p> <p>P101 PLUMBING PLAN</p> <p>P501 PLUMBING MEZZANINE AND PLAN DETAILS P601 PLUMBING SCHEDULE & LEGENDS P901 PLUMBING RISER DIAGRAM</p> <p>FIRE PROTECTION</p> <p>FP101 FIRE PROTECTION FLOOR PLAN FP101a FIRE PROTECTION FLOOR PLAN FP201 FIRE PROTECTION DETAILS</p>	<p>ELECTRICAL</p> <p>E001 ELECTRICAL SYMBOLS</p> <p>ES101 ELECTRICAL SITE PLAN E100 HQ BUILDING POWER PLAN E101A-L MEZZANINE LIGHTING PLAN E101A-P MEZZANINE POWER PLAN E101L LIGHTING PLAN E101P POWER PLAN E101S SYSTEMS PLAN E102G ELECTRICAL ROOF PLAN</p> <p>E401 ENLARGED PLAN</p> <p>E501 ELECTRICAL DETAILS</p> <p>E601 SINGLE LINE DIAGRAM E602 PANEL SCHEDULES</p>
---	--	--	--	---	---	---



REVISIONS:

GLOBAL VILLAGE CONSULTANT:
CAMBRIDGE SEVEN ASSOCIATES

LANDSCAPE ARCHITECT:
LARSON BURNS SMITH

CIVIL ENGINEER:
McCLELLAND ENGINEERS

STRUCTURAL ENGINEER:
CROMWELL ENGINEERS INC.

MECHANICAL, ELECTRICAL, & PLUMBING ENGINEER:
CROMWELL ENGINEERS INC.

INTERIOR DESIGN:
POLK STANLEY ROWLAND CURZON PORTER ARCHITECTS

GENERAL CONTRACTOR:
CDI CONTRACTORS, INC.

POLK STANLEY ROWLAND CURZON PORTER
ARCHITECTS, LTD.

700 SOUTH SCHILLER STREET
LITTLE ROCK, AR 72201
VOICE: 501-378-0878
FAX: 501-378-0878

21 WEST MOUNTAIN, SUITE 227
FAYETTEVILLE, AR 72701
VOICE: 479-444-0473
FAX: 479-251-7216