

700 SOUTH SCHILLER  
LITTLE ROCK, AR 72201  
501.378.0878 office  
501.372.7629 fax

509 W. SPRING STREET, SUITE 150  
FAYETTEVILLE, AR 72701  
479.444.0473 office  
473.251.7216 fax

www.polkstanley.com

**CONSULTANTS:**

**CIVIL ENGINEER:**  
MCCLELLAND ENGINEERS

**LANDSCAPE ARCHITECT:**  
LARSON BURNS SMITH

**STRUCTURAL ENGINEER:**  
CROMWELL ENGINEERS INC.

**MECH., ELEC., PLUMB. ENGINEER:**  
CROMWELL ENGINEERS INC.

**GLOBAL VILLAGE CONSULTANT:**  
CAMBRIDGE SEVEN ASSOCIATES

**INTERIOR DESIGNER:**  
POLK STANLEY ROWLAND  
CURZON PORTER ARCHITECTS

**GENERAL CONTRACTOR:**  
CDI CONTRACTORS, INC.

**NOTES:**

Blank lines for notes.

**ISSUE DATE:**  
17 SEPTEMBER 07

**REVISIONS:**

#	DATE	DESCRIPTION
1	07 JAN 07	ASH NO. 01
2	14 FEB 08	ASH NO. 2
3	24 MAR 08	ASH NO. 4
4	30 JULY 08	ASH NO. 17
5	28 AUG 08	ASH NO. 20

**MURPHY KELLER  
EDUCATION CENTER**

**HEIFER  
INTERNATIONAL  
CENTER**  
LITTLE ROCK, ARKANSAS

**PSRCP JOB NUMBER:**


431E

**CONTENTS:**

FLOOR PLAN 9'-8 5/8"

**SHEET NUMBER:**

**A101**

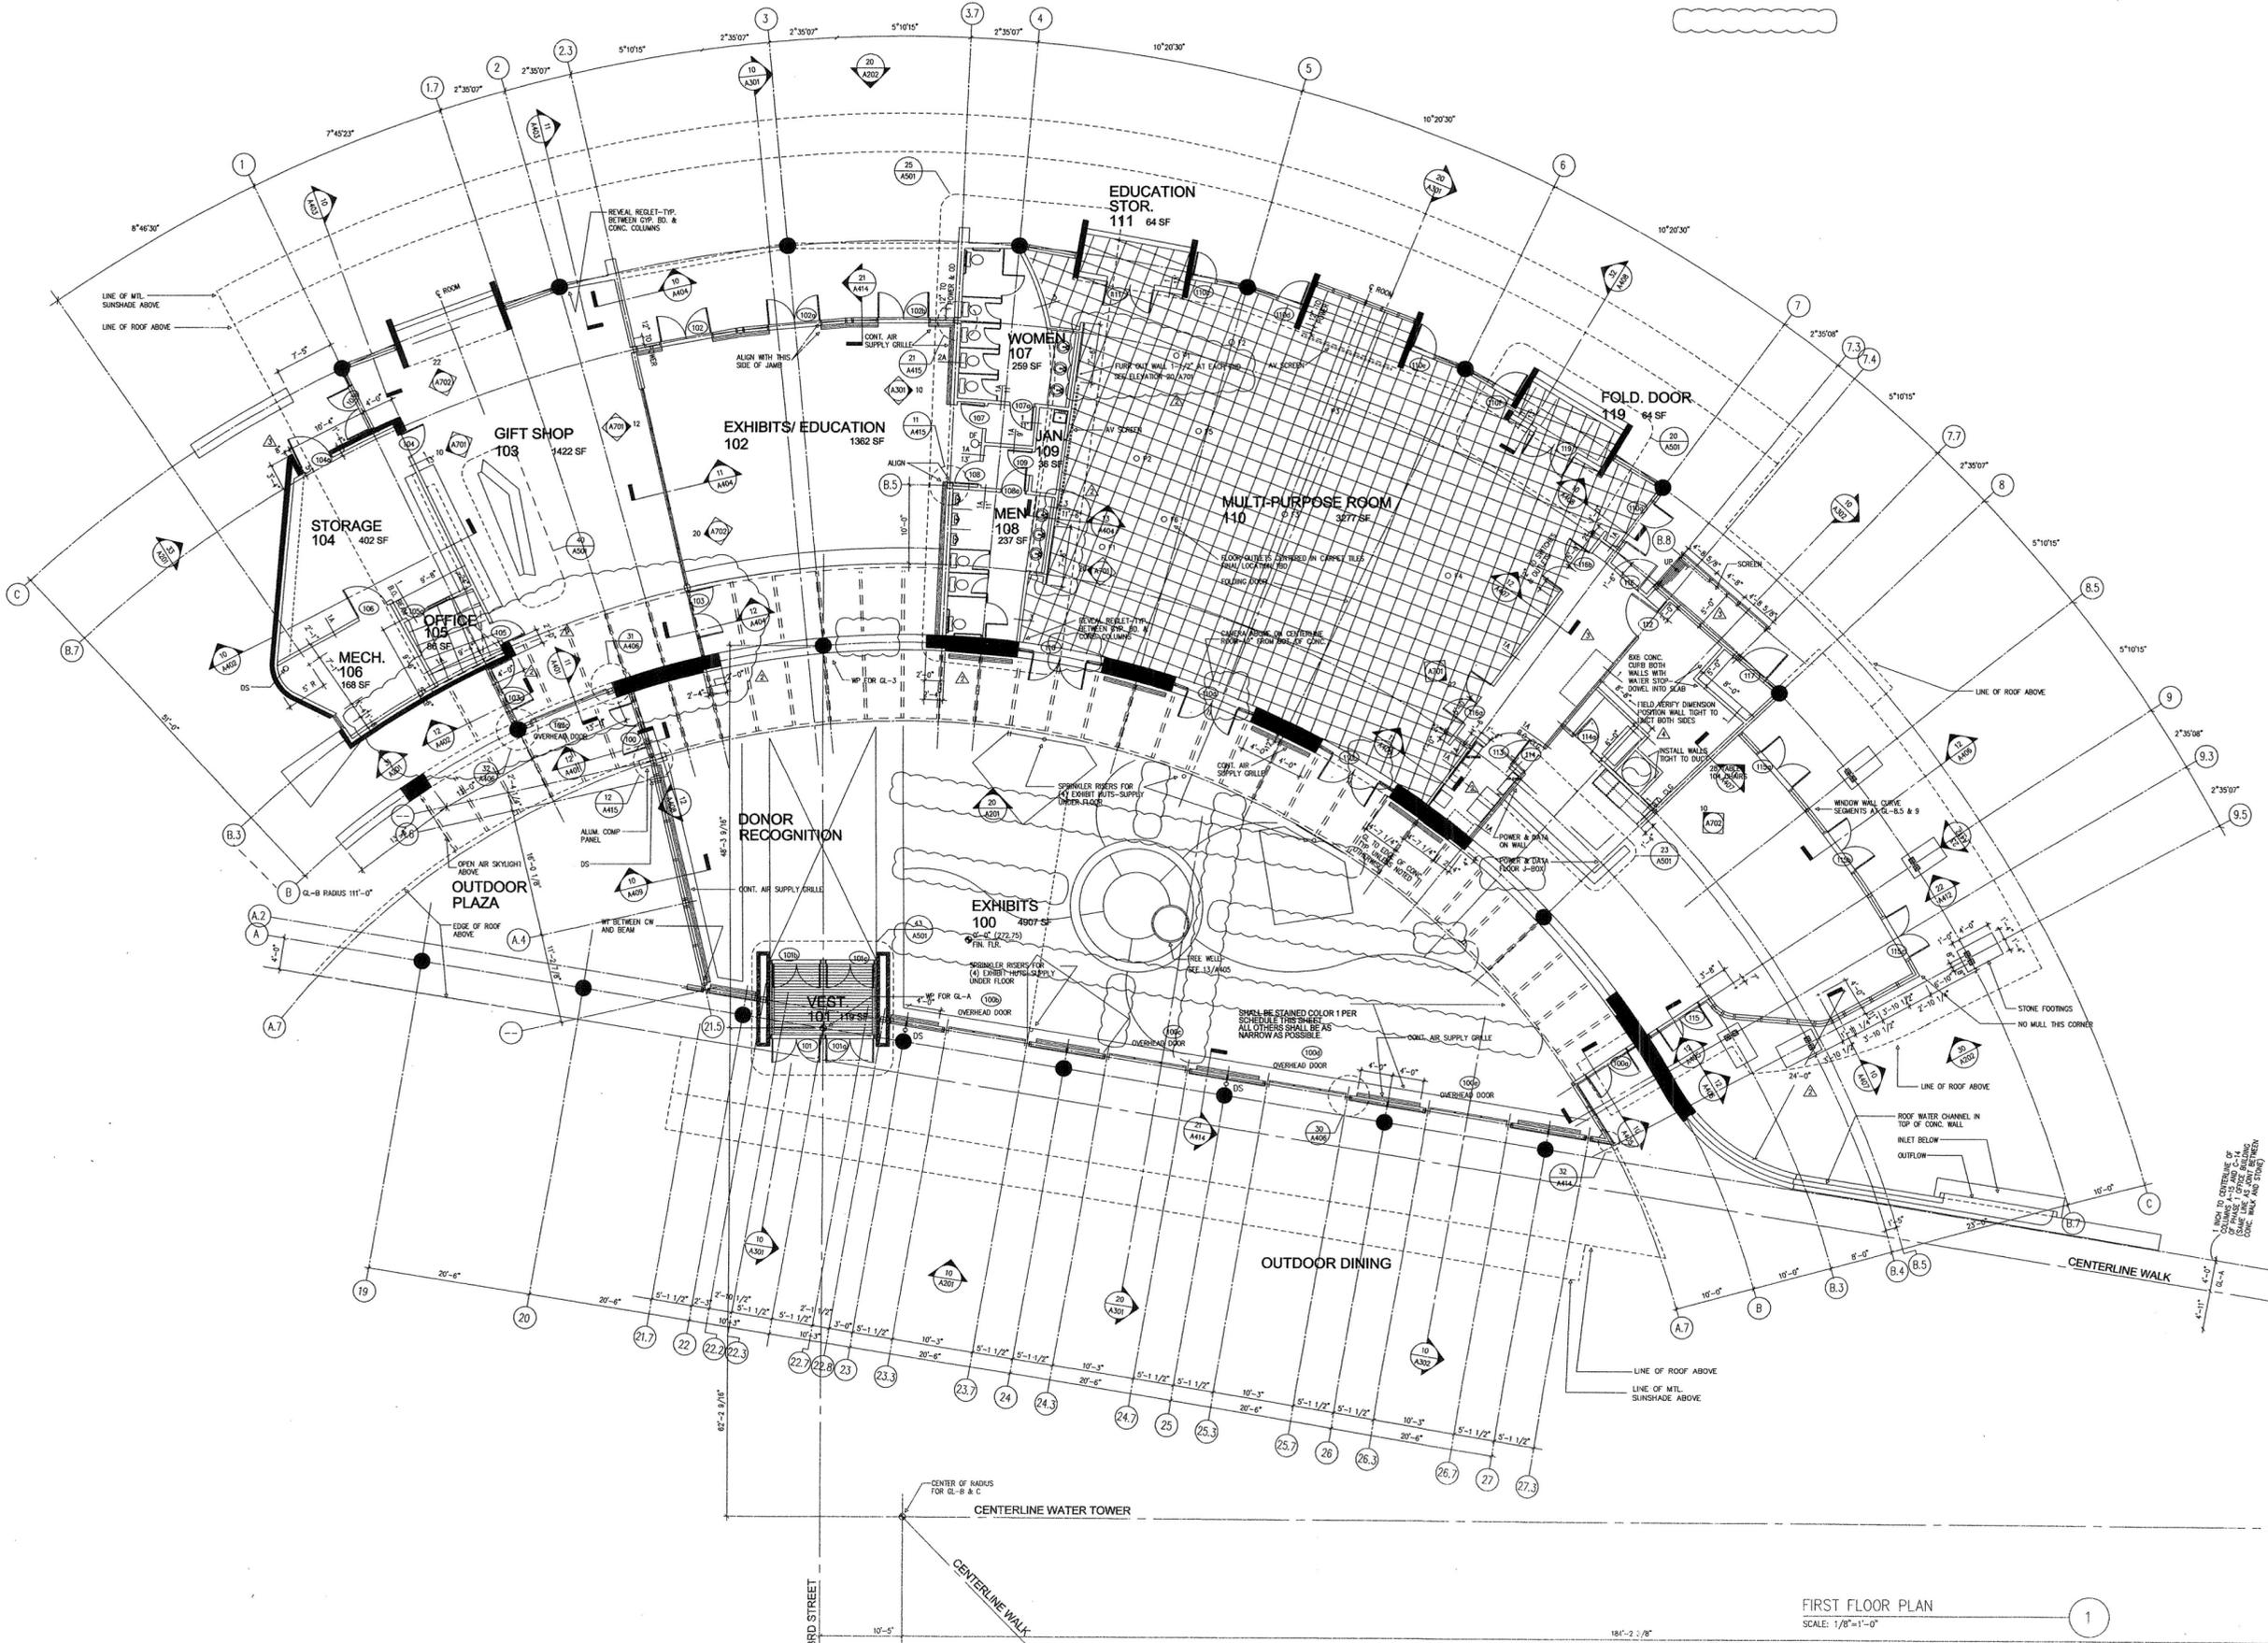

FIRST FLOOR PLAN  
SCALE: 1/8"=1'-0"  
1