



CONSULTANTS:

- CIVIL ENGINEER:
MCLELLAND ENGINEERS
- LANDSCAPE ARCHITECT:
LARSON BURNS SMITH
- STRUCTURAL ENGINEER:
CROMWELL ENGINEERS INC.
- MECH., ELEC., PLUMB. ENGINEER:
CROMWELL ENGINEERS INC.
- GLOBAL VILLAGE CONSULTANT
CAMBRIDGE SEVEN ASSOCIATES
- INTERIOR DESIGNER:
POLK STANLEY ROWLAND
CURZON PORTER ARCHITECTS
- GENERAL CONTRACTOR:
CDI CONTRACTORS, INC.

NOTES:

ISSUE DATE:
17 SEPTEMBER 07

REVISIONS:

#	DATE:	DESCRIPTION:

**MURPHY KELLER
EDUCATION CENTER**

**HEIFER
INTERNATIONAL
CENTER**
LITTLE ROCK, ARKANSAS

PSRCP JOB NUMBER:


431E

CONTENTS:

MECHANICAL
MEZZANINE
FLOOR PLAN

SHEET NUMBER:

A101a

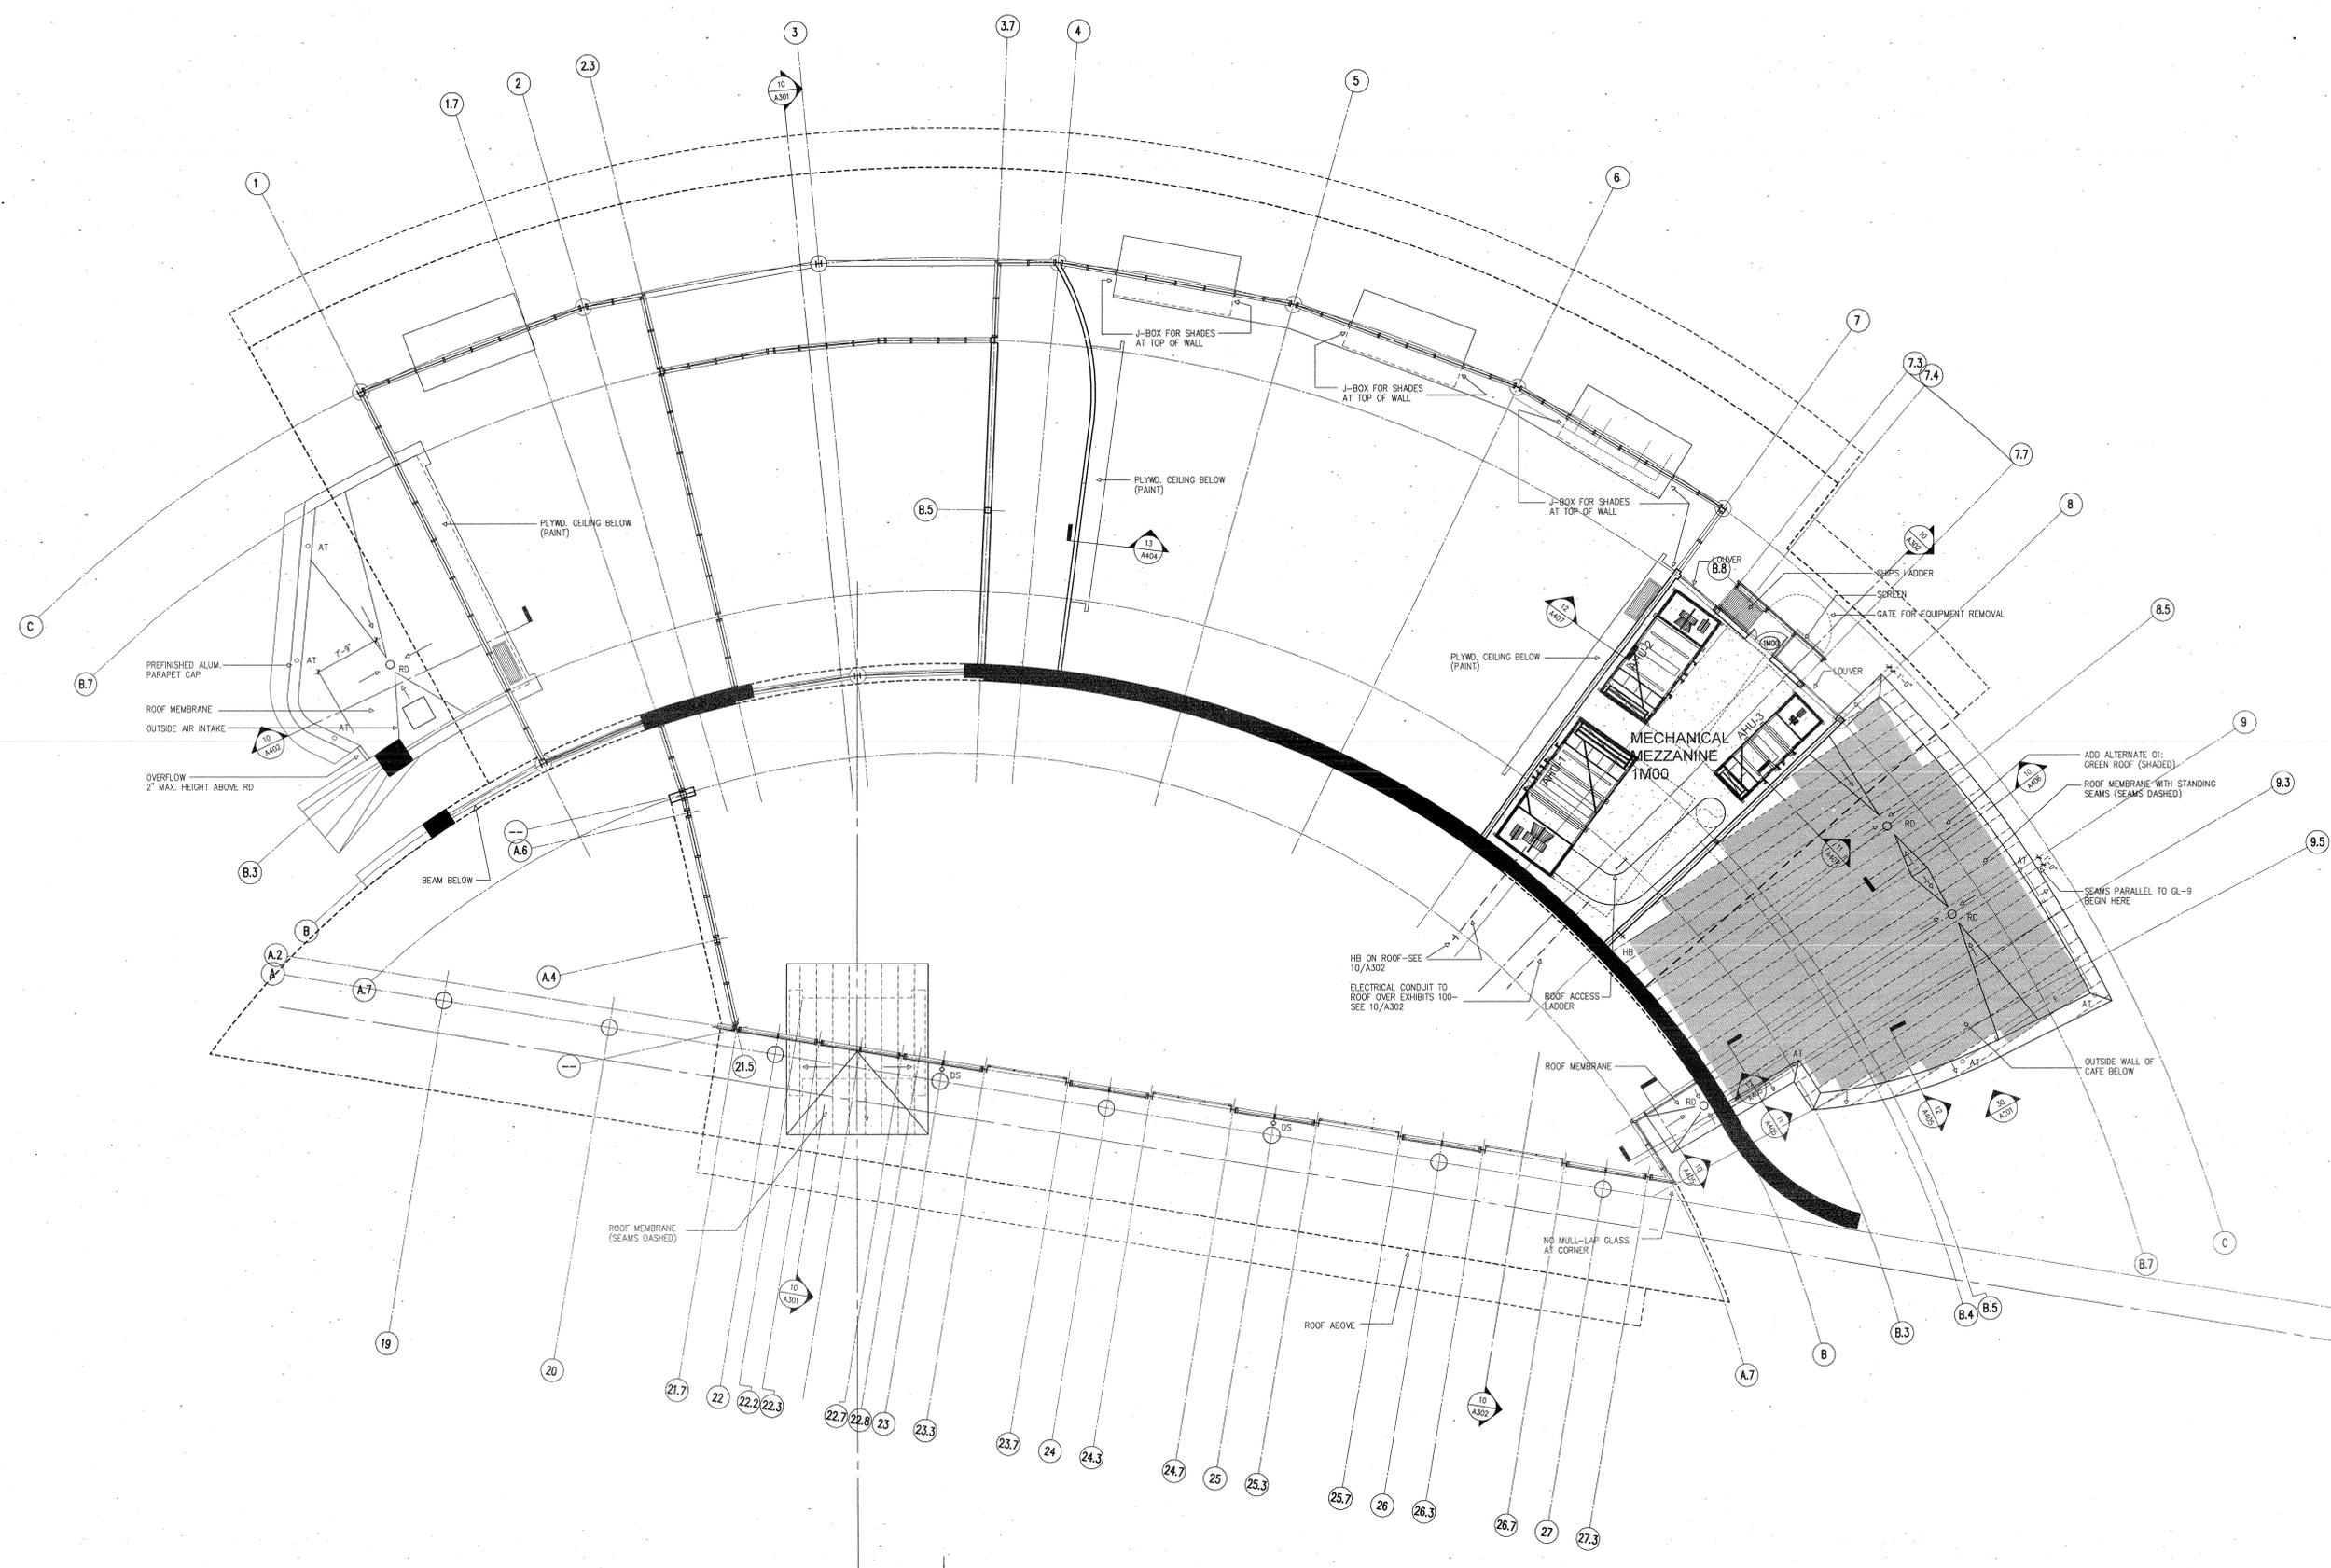

NOTE: ROOF IS VISIBLE FROM EXISTING 4 STORY OFFICE BUILDING AND MUST BE ORGANIZED AS SHOWN DUE TO ITS HIGH VISIBILITY. REVIEW LOCATION OF ALL DEVICES VISIBLE TO VIEW WITH ARCHITECT BEFORE INSTALLATION.
MECHANICAL MEZZANINE FLOOR PLAN 1
SCALE: 1/8"=1'-0"