

700 SOUTH SCHILLER
LITTLE ROCK, AR 72201
501.378.0878 office
501.372.7629 fax

509 W. SPRING STREET, SUITE 150
FAYETTEVILLE, AR 72701
479.444.0473 office
473.251.7216 fax

www.polkstanley.com



CONSULTANTS:

CIVIL ENGINEER:
MCLELLAND ENGINEERS

LANDSCAPE ARCHITECT:
LARSON BURNS SMITH

STRUCTURAL ENGINEER:
CROMWELL ENGINEERS INC.

MECH., ELEC., PLUMB. ENGINEER:
CROMWELL ENGINEERS INC.

GLOBAL VILLAGE CONSULTANT
CAMBRIDGE SEVEN ASSOCIATES

INTERIOR DESIGNER:
POLK STANLEY ROWLAND
CURZON PORTER ARCHITECTS

GENERAL CONTRACTOR:
CDI CONTRACTORS, INC.

NOTES:

ISSUE DATE:
17 SEPTEMBER 07

REVISIONS:

#	DATE	DESCRIPTION
1	07 JAN 07	ASB NO. 01
2	07 MAY 08	ASB NO. 13

MURPHY KELLER
EDUCATION CENTER


HEIFER
INTERNATIONAL
CENTER

LITTLE ROCK, ARKANSAS

PSRCP JOB NUMBER:
431E

CONTENTS:
ROOF PLAN

SHEET NUMBER:
A102

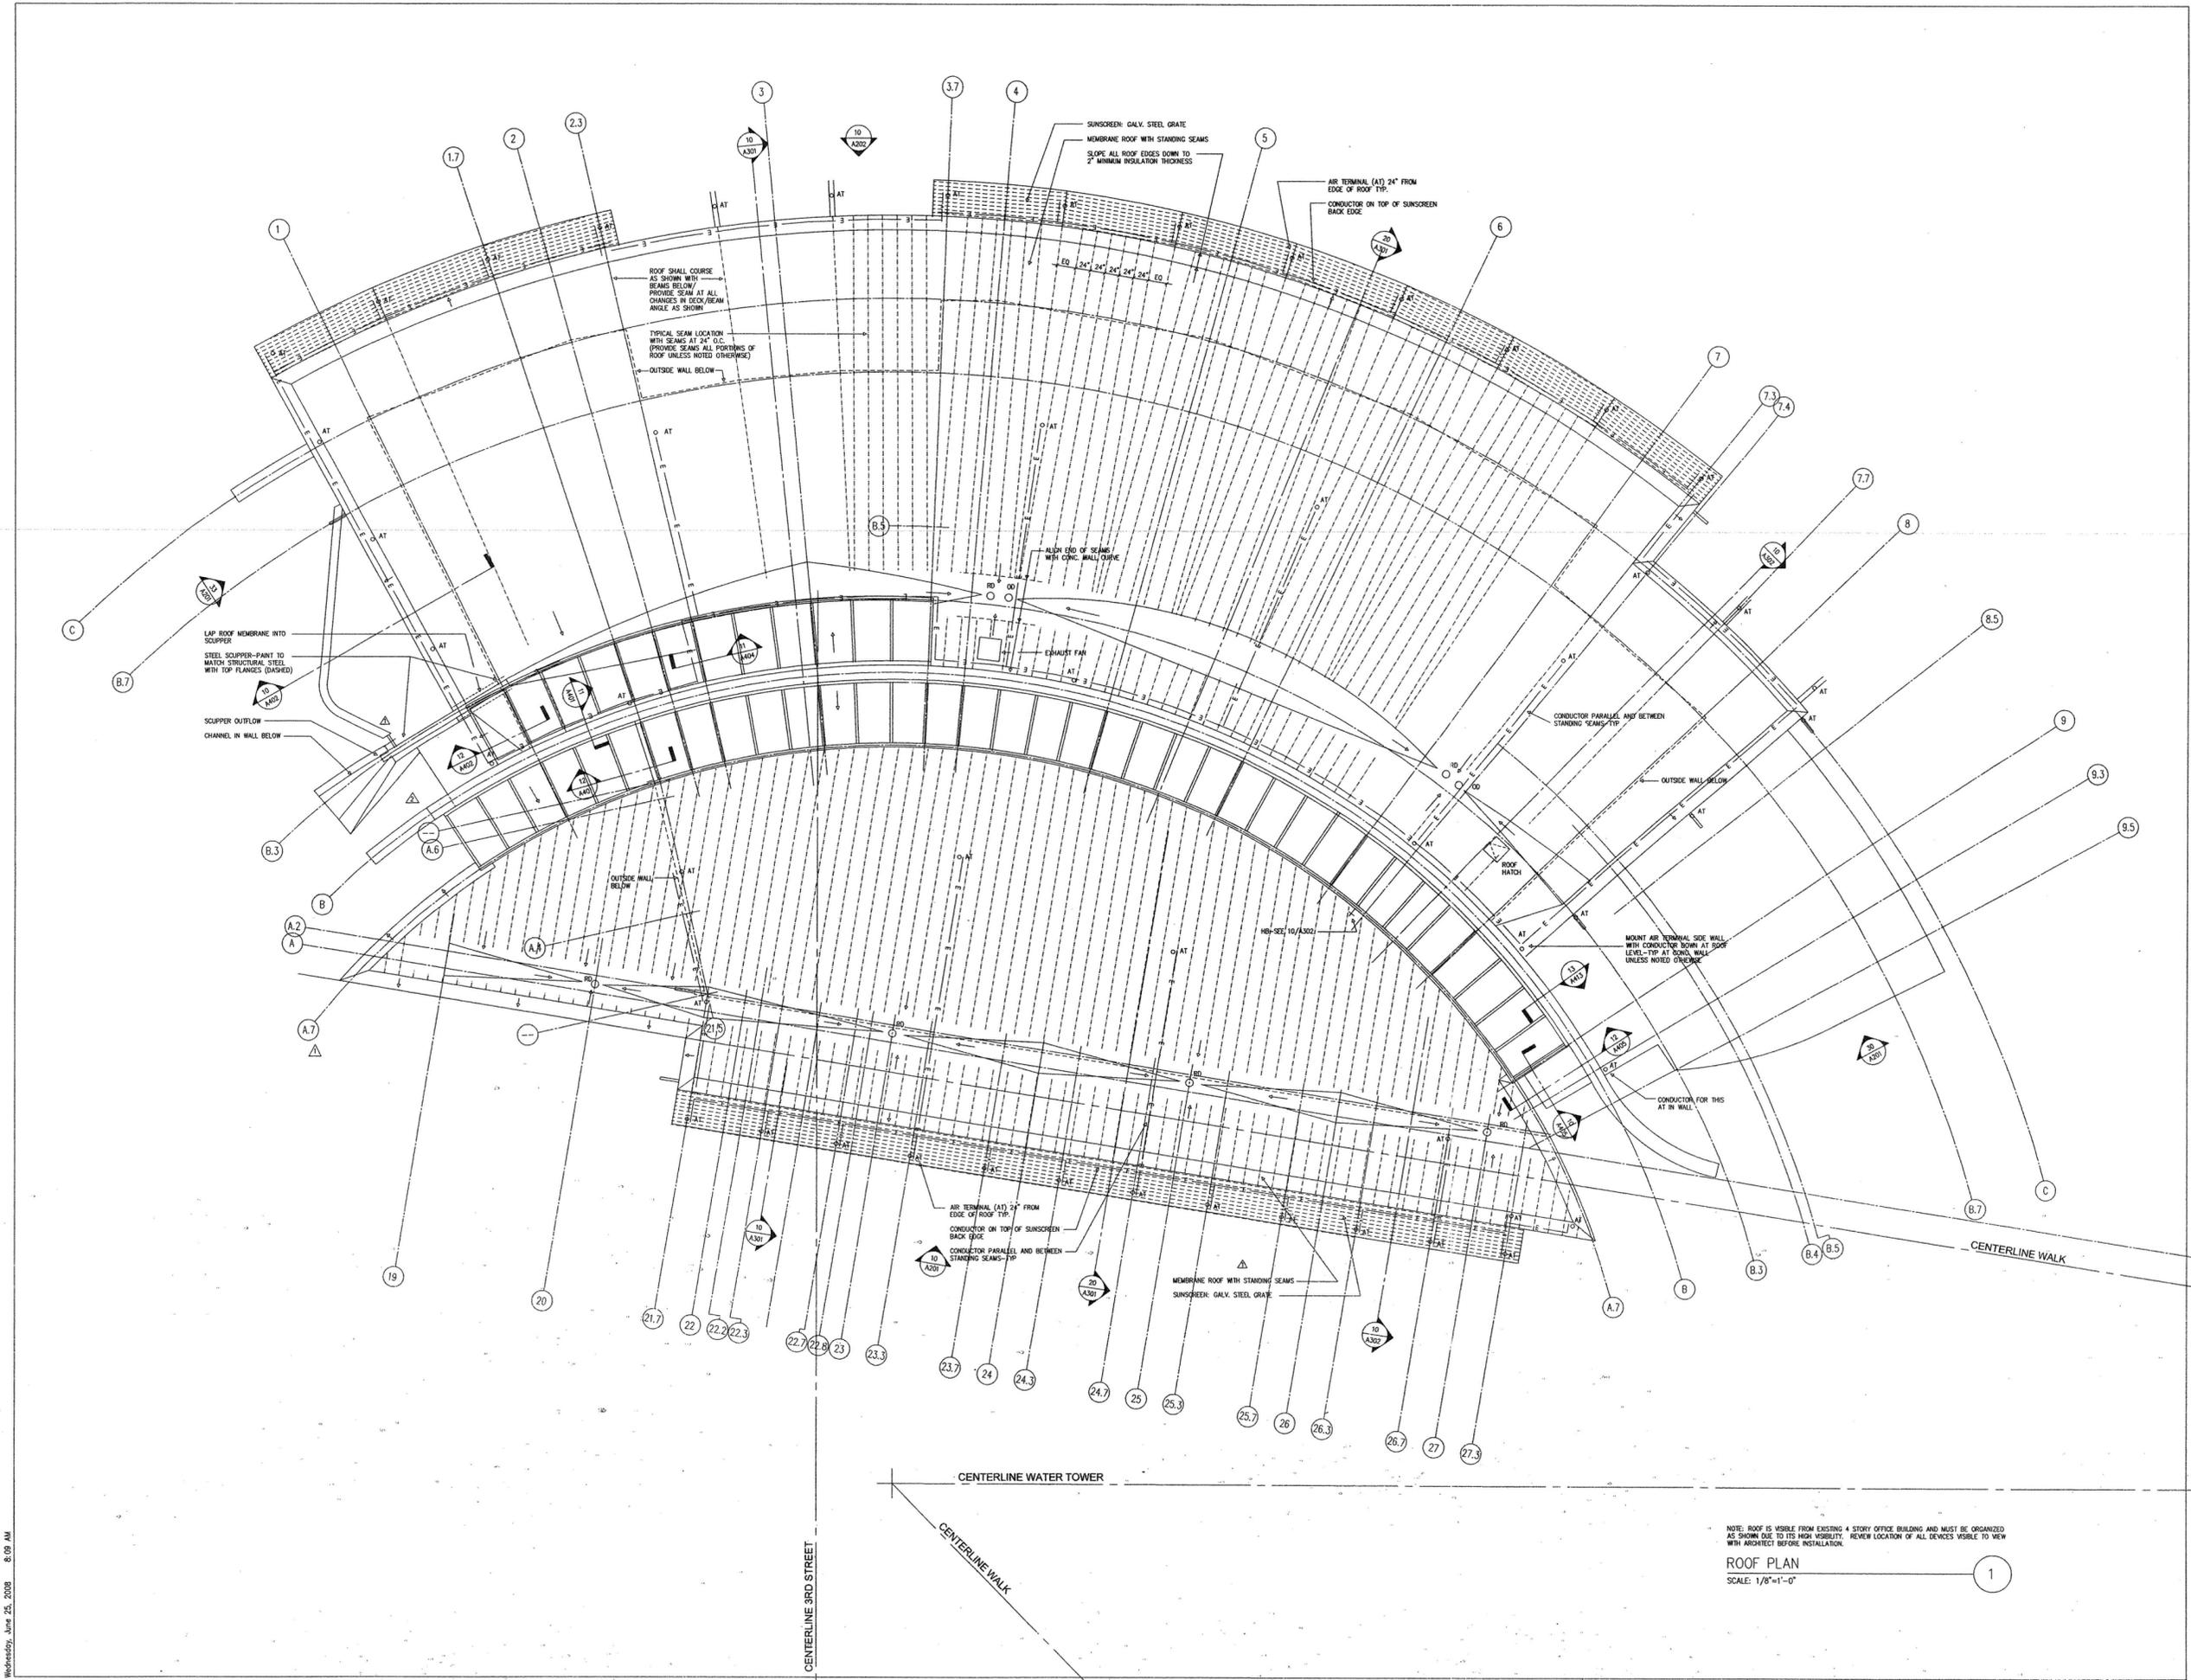

NOTE: ROOF IS VISIBLE FROM EXISTING 4 STORY OFFICE BUILDING AND MUST BE ORGANIZED AS SHOWN DUE TO ITS HIGH VISIBILITY. REVIEW LOCATION OF ALL DEVICES VISIBLE TO VIEW WITH ARCHITECT BEFORE INSTALLATION.

ROOF PLAN
SCALE: 1/8"=1'-0"