



CONSULTANTS:

- CIVIL ENGINEER:**
MCLELLAND ENGINEERS
- LANDSCAPE ARCHITECT:**
LARSON BURNS SMITH
- STRUCTURAL ENGINEER:**
CROMWELL ENGINEERS INC.
- MECH., ELEC., PLUMB. ENGINEER:**
CROMWELL ENGINEERS INC.
- GLOBAL VILLAGE CONSULTANT:**
CAMBRIDGE SEVEN ASSOCIATES
- INTERIOR DESIGNER:**
POLK STANLEY ROWLAND
CURZON PORTER ARCHITECTS
- GENERAL CONTRACTOR:**
CDI CONTRACTORS, INC.

NOTES:

1. ALL GLAZED WALL SYSTEMS SHALL BE ALUMINUM STOREFRONT UNLESS NOTED OTHERWISE
2. ALL GLAZING SHALL BE CLEAR INSULATED TYPE (I) UNLESS NOTED OTHERWISE
3. SEE GENERAL FINISH NOTES ON A301 FOR EXTERIOR FINISHES

T.O. CONC. WALL
31'-0"


T.O. STRUCT.
21'-0"

FIN. FLOOR
0'-0"

ISSUE DATE:
17 SEPTEMBER 07

REVISIONS:

#	DATE	DESCRIPTION

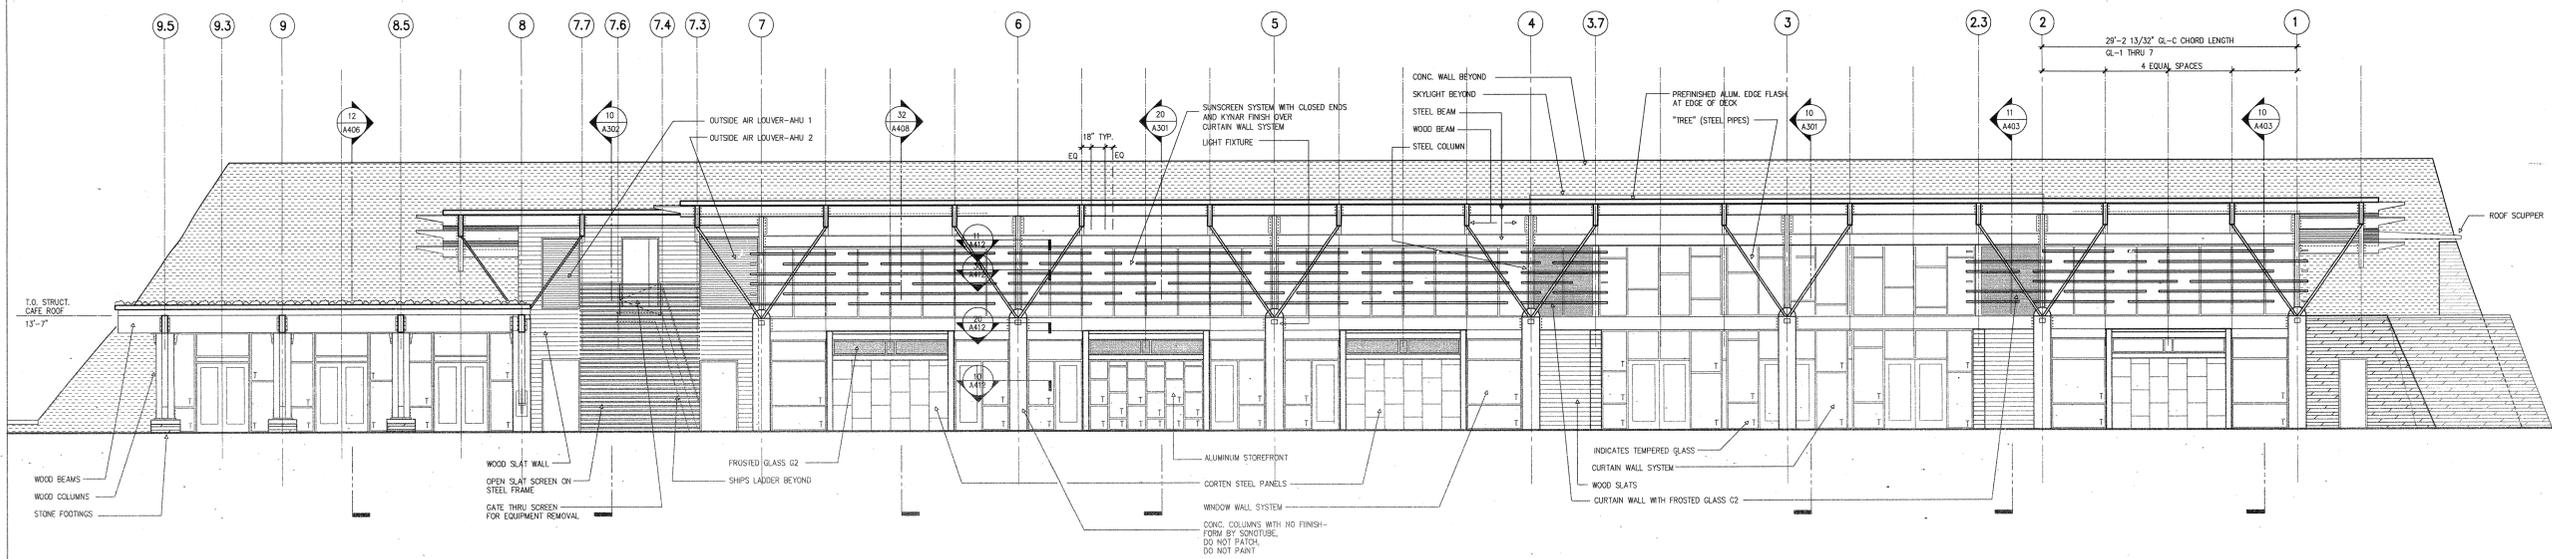

NOTE: SEE 20/A201 FOR WALL FORMWORK
EAST ELEVATION (FLAT)
SCALE: 1/8"=1'-0"

20

**MURPHY KELLER
EDUCATION CENTER**

**HEIFER
INTERNATIONAL
CENTER**
LITTLE ROCK, ARKANSAS

PSRCP JOB NUMBER:

431E

CONTENTS:

BUILDING ELEVATIONS

SHEET NUMBER:

A202