



CONSULTANTS:

- CIVIL ENGINEER:  
MCCELLEND ENGINEERS
- LANDSCAPE ARCHITECT:  
LARSON BURNS SMITH
- STRUCTURAL ENGINEER:  
CROMWELL ENGINEERS INC.
- MECH., ELEC., PLUMB. ENGINEER:  
CROMWELL ENGINEERS INC.
- GLOBAL VILLAGE CONSULTANT  
CAMBRIDGE SEVEN ASSOCIATES
- INTERIOR DESIGNER:  
POLK STANLEY ROWLAND  
CURZON PORTER ARCHITECTS
- GENERAL CONTRACTOR:  
CDI CONTRACTORS, INC.

NOTES:

- \_\_\_\_\_
- \_\_\_\_\_
- \_\_\_\_\_
- \_\_\_\_\_
- \_\_\_\_\_
- \_\_\_\_\_
- \_\_\_\_\_
- \_\_\_\_\_

ISSUE DATE:  
17 SEPTEMBER 07


REVISIONS:

#	DATE	DESCRIPTION
1	07 JAN 08	AS NO. 1
2	01 MARCH 08	AS NO. 3
3	07 MAY 08	AS NO. 13

MURPHY KELLER  
EDUCATION CENTER  
**HEIFER  
INTERNATIONAL  
CENTER**  
LITTLE ROCK, ARKANSAS


PSRCP JOB NUMBER:  
431E  
CONTENTS:  
WALL SECTIONS

SHEET NUMBER:  
**A402**

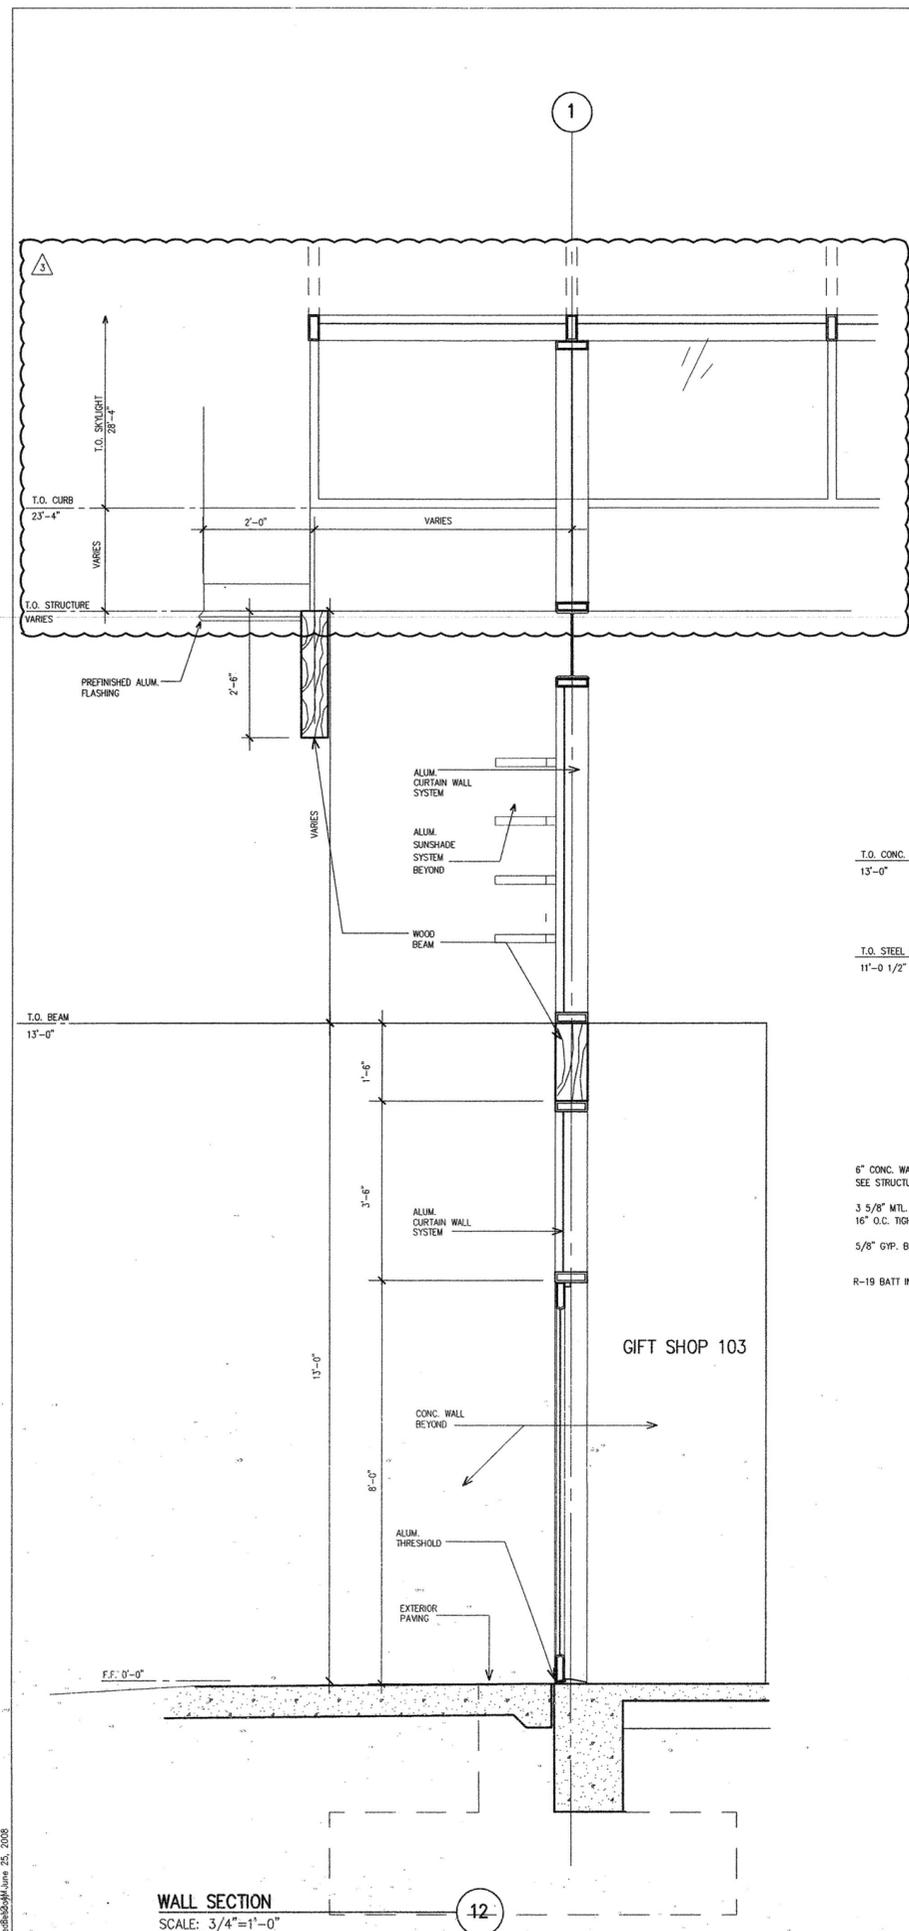

WALL SECTION  
SCALE: 3/4"=1'-0"

12

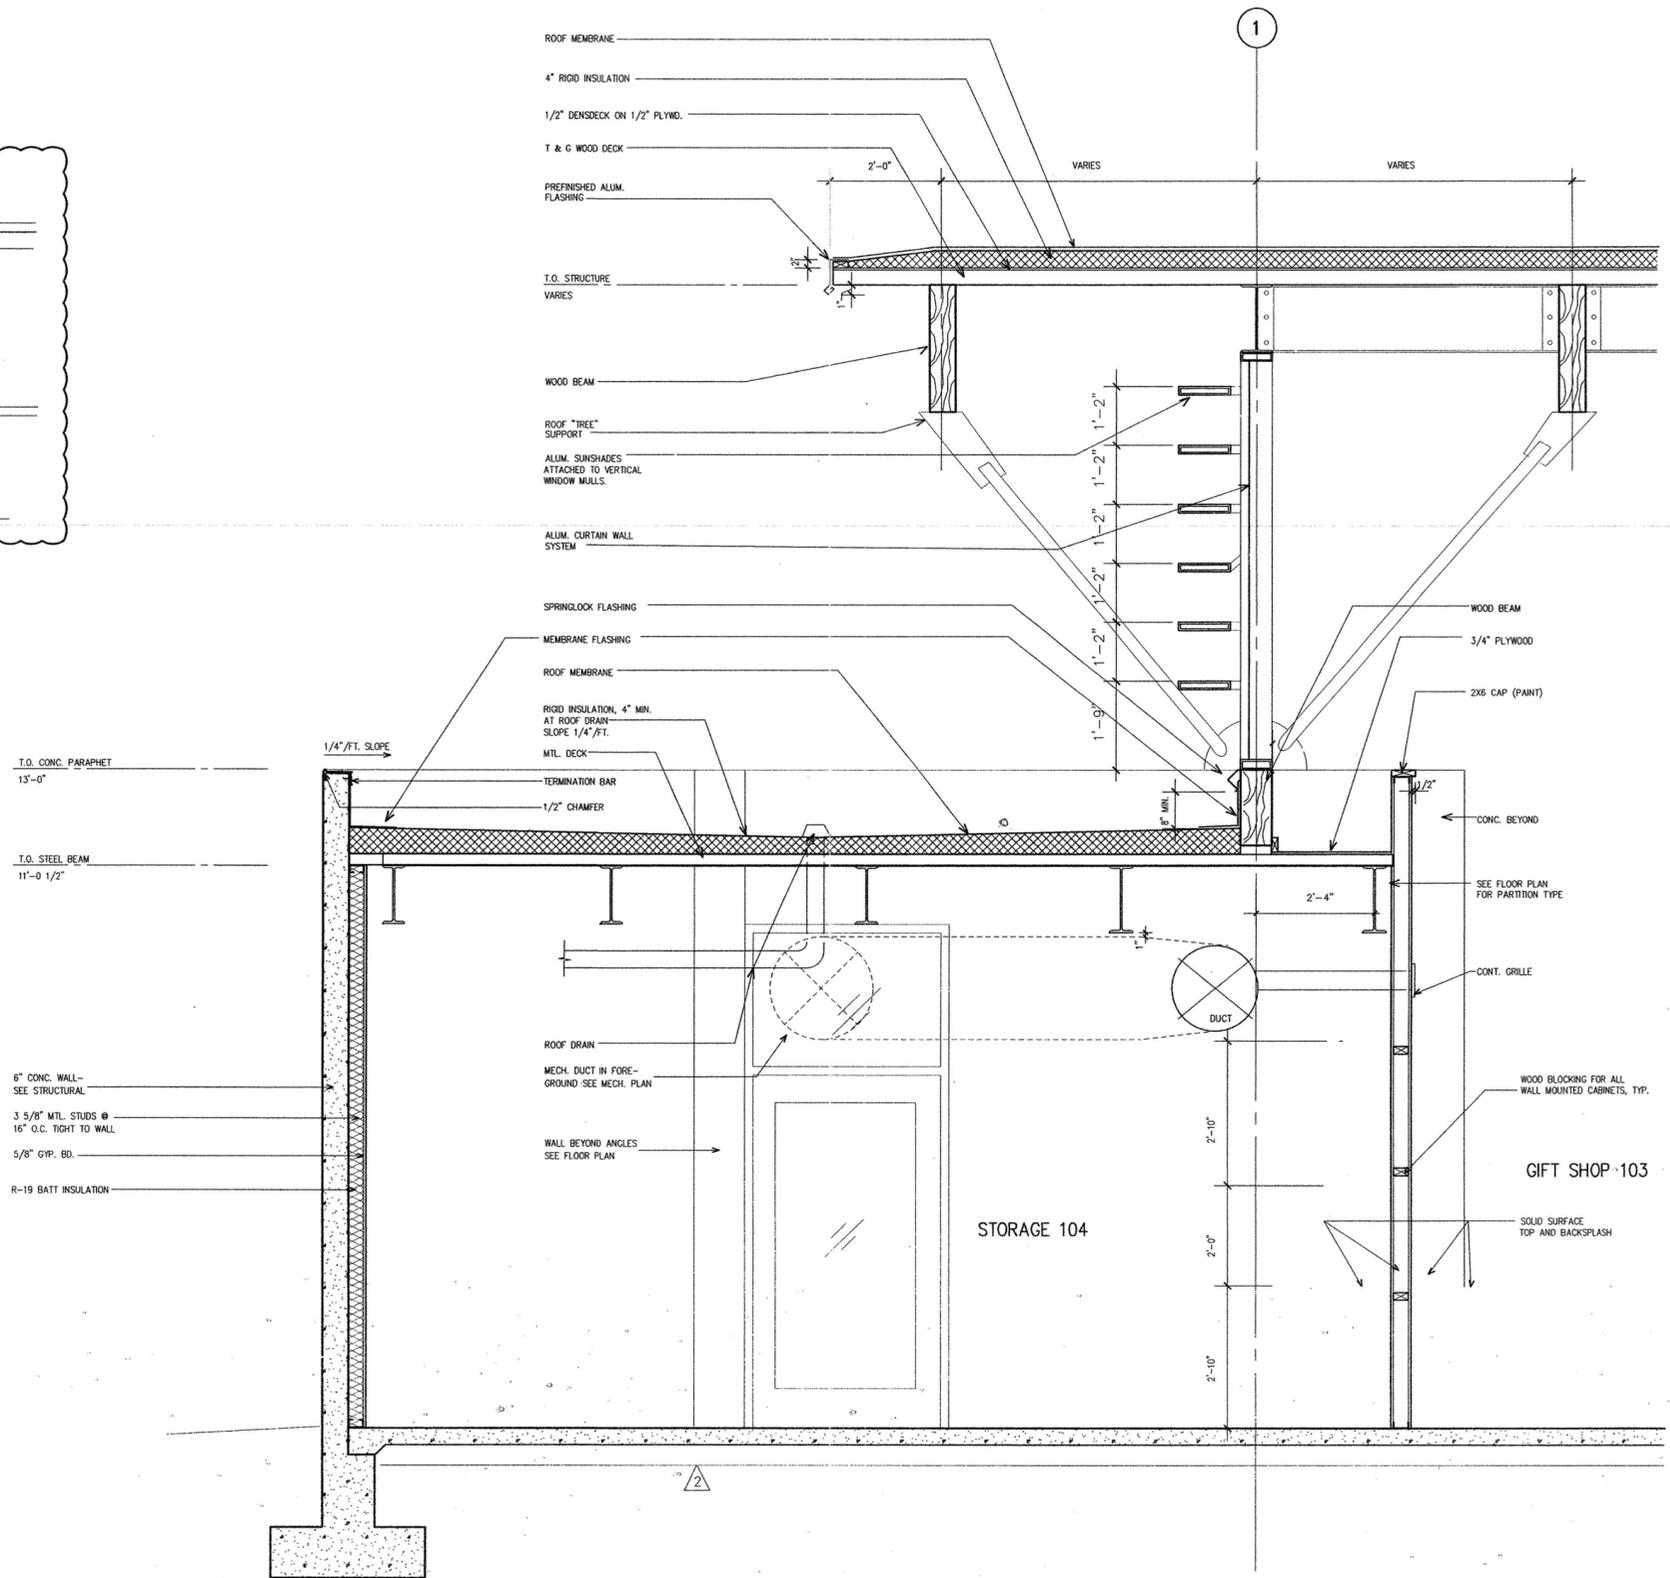

WALL SECTION  
SCALE: 3/4"=1'-0"

10