



- CONSULTANTS:**
CIVIL ENGINEER: MCCLELLAND ENGINEERS
LANDSCAPE ARCHITECT: LARSON BURNS SMITH
STRUCTURAL ENGINEER: CROMWELL ENGINEERS INC.
MECH., ELEC., PLUMB. ENGINEER: CROMWELL ENGINEERS INC.
GLOBAL VILLAGE CONSULTANT: CAMBRIDGE SEVEN ASSOCIATES
INTERIOR DESIGNER: POLK STANLEY ROWLAND CURZON PORTER ARCHITECTS
GENERAL CONTRACTOR: CDI CONTRACTORS, INC.

NOTES:

ISSUE DATE:
17 SEPTEMBER 07


REVISIONS:

#	DATE:	DESCRIPTION:
1	07 JAN. 08	ASI NO. 1
2	07 MAY 08	ASI NO. 13

**MURPHY KELLER
EDUCATION CENTER**
**HEIFER
INTERNATIONAL
CENTER**
 LITTLE ROCK, ARKANSAS

PSRCP JOB NUMBER:
431E
CONTENTS:
WALL SECTIONS

SHEET NUMBER:
A404

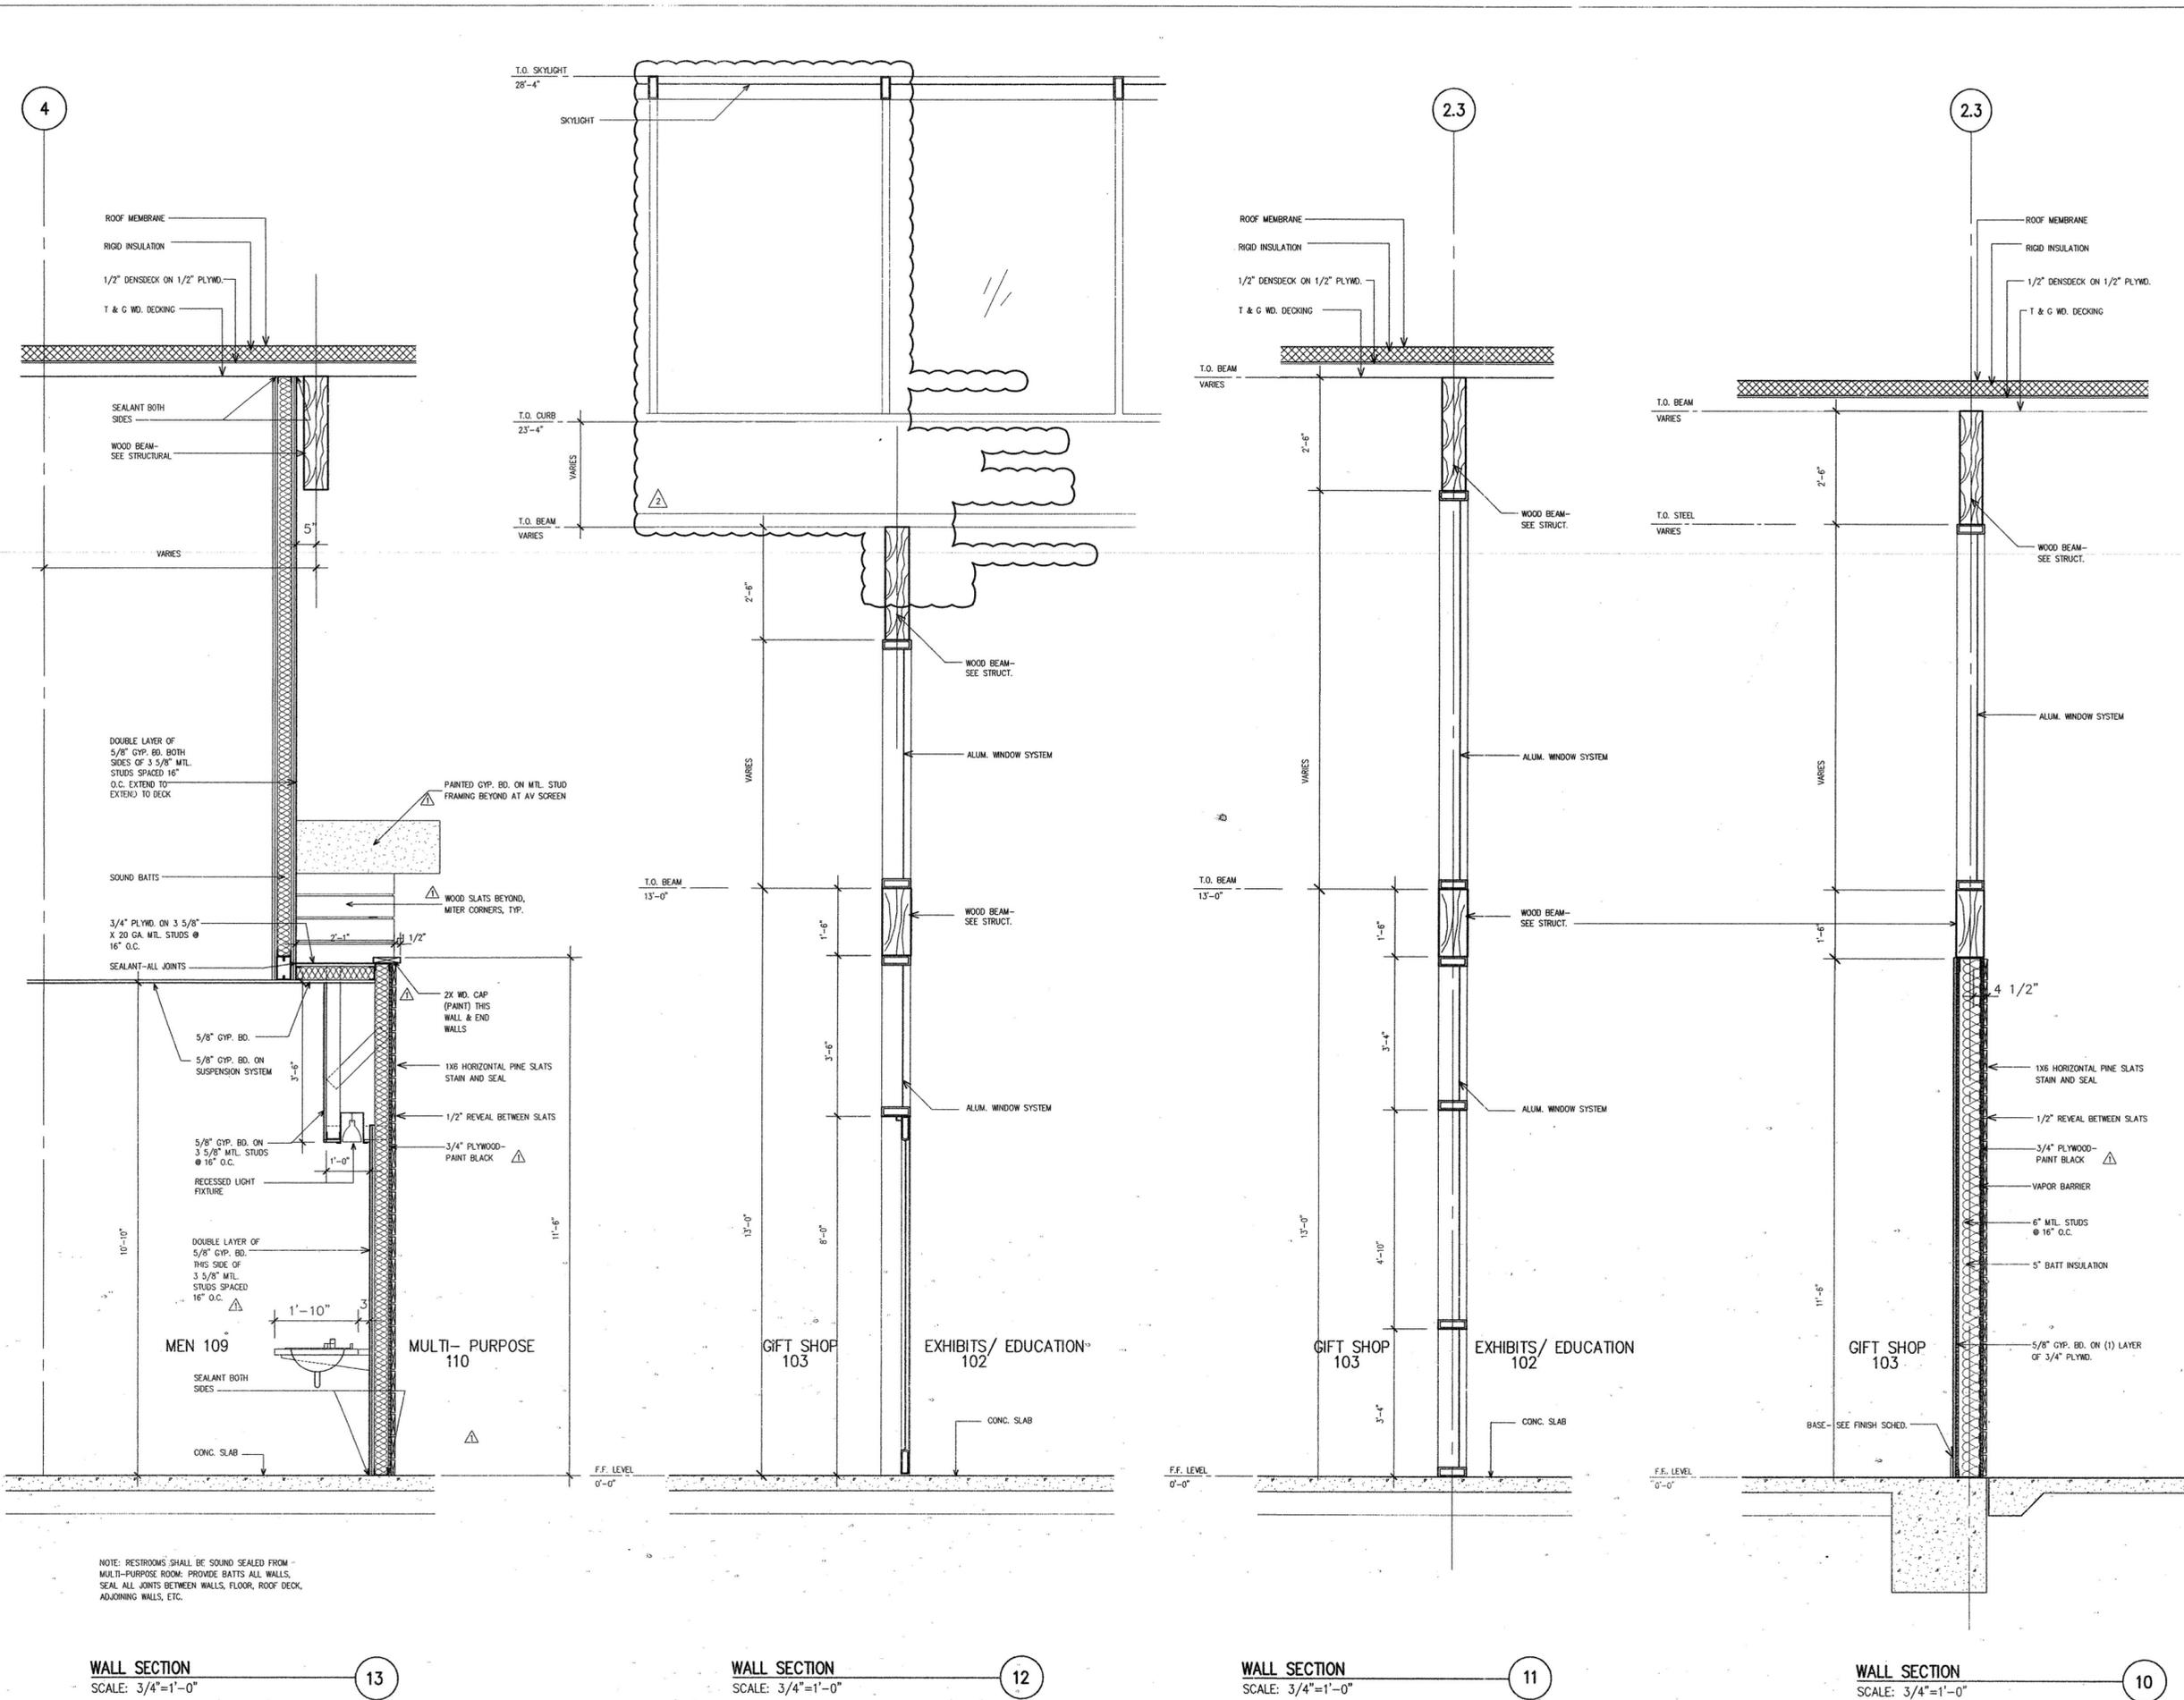

WALL SECTION
SCALE: 3/4"=1'-0"

13

WALL SECTION
SCALE: 3/4"=1'-0"

12

WALL SECTION
SCALE: 3/4"=1'-0"

11

WALL SECTION
SCALE: 3/4"=1'-0"

10

NOTE: RESTROOMS SHALL BE SOUND SEALED FROM MULTI-PURPOSE ROOM. PROVIDE BATTS ALL WALLS. SEAL ALL JOINTS BETWEEN WALLS, FLOOR, ROOF DECK, ADJOINING WALLS, ETC.