

- CONSULTANTS:**
CIVIL ENGINEER:
 MCCELLEND ENGINEERS
LANDSCAPE ARCHITECT:
 LARSON BURNS SMITH
STRUCTURAL ENGINEER:
 CROMWELL ENGINEERS INC.
MECH., ELEC., PLUMB. ENGINEER:
 CROMWELL ENGINEERS INC.
GLOBAL VILLAGE CONSULTANT
 CAMBRIDGE SEVEN ASSOCIATES
INTERIOR DESIGNER:
 POLK STANLEY ROWLAND
 CURZON PORTER ARCHITECTS
GENERAL CONTRACTOR:
 CDI CONTRACTORS, INC.

NOTES:

ISSUE DATE:
17 SEPTEMBER 2007

REVISIONS:

#	DATE	DESCRIPTION


MURPHY - KELLER
EDUCATIONAL CENTER

HEIFER
INTERNATIONAL
CENTER
LITTLE ROCK, ARKANSAS

PSRCP JOB NUMBER:
431E

CONTENTS:
HQ BUILDING POWER PLAN

SHEET NUMBER:
E100

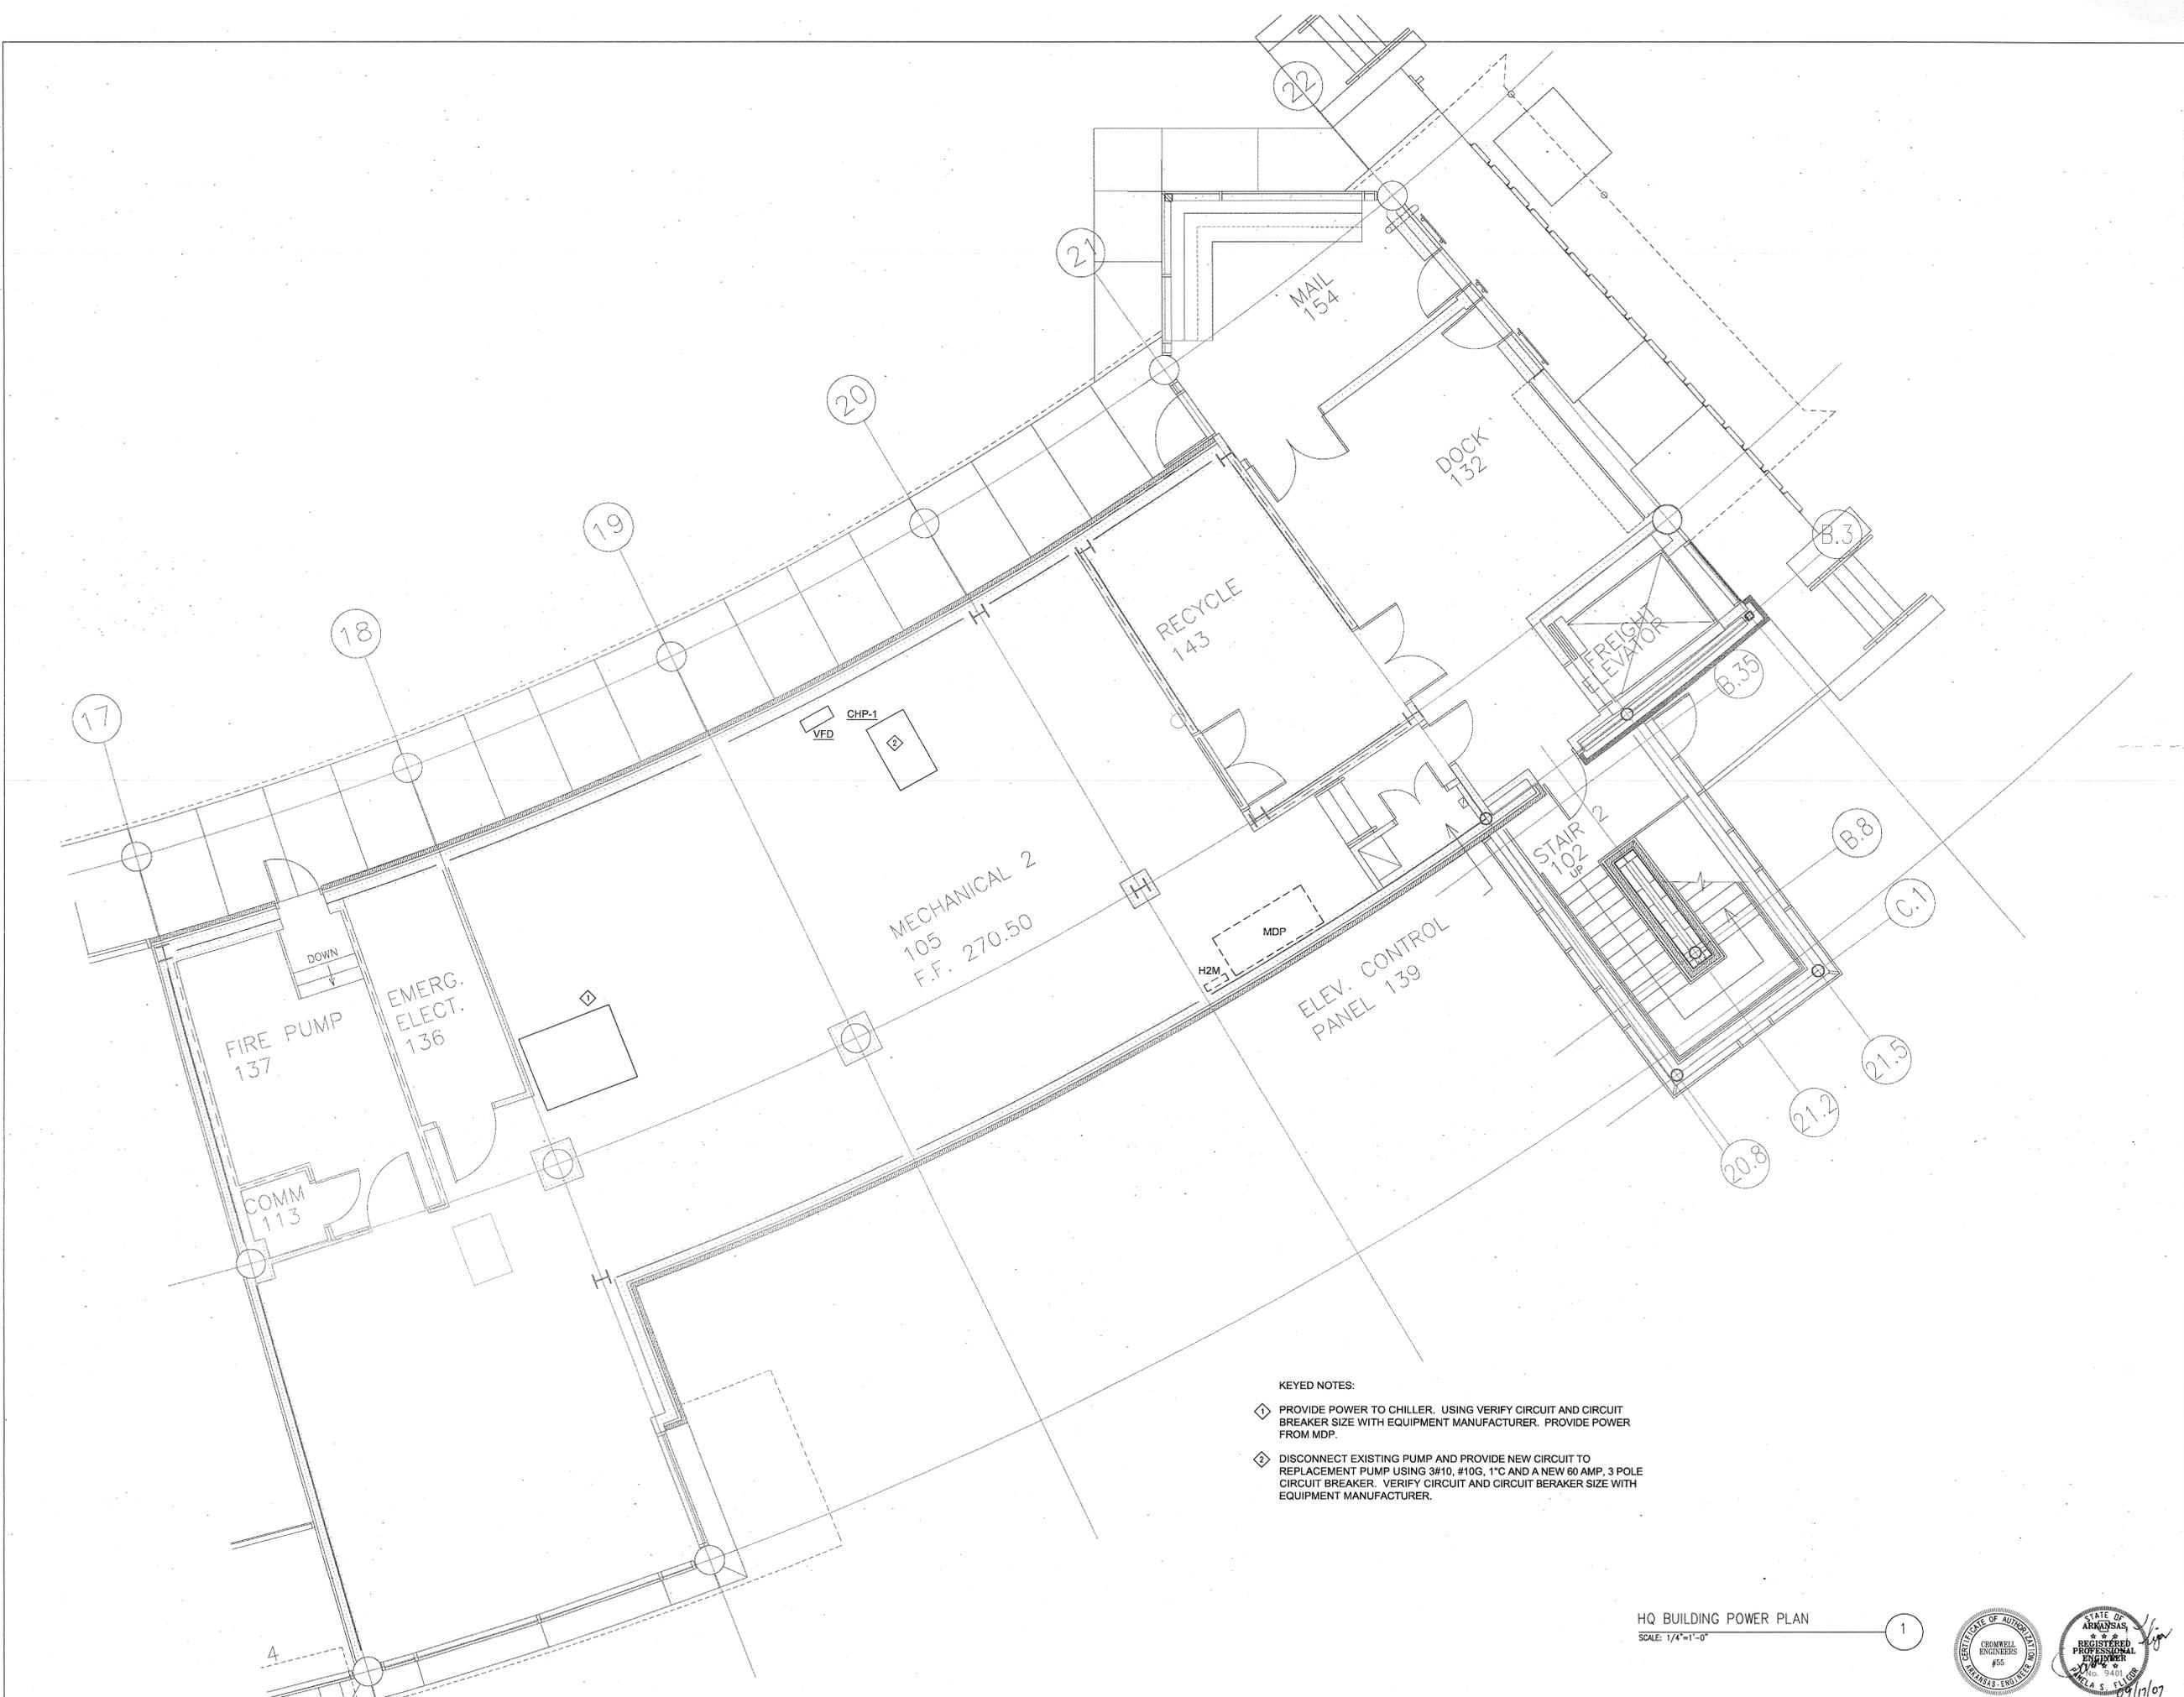

- KEYED NOTES:**
- ◇ PROVIDE POWER TO CHILLER. USING VERIFY CIRCUIT AND CIRCUIT BREAKER SIZE WITH EQUIPMENT MANUFACTURER. PROVIDE POWER FROM MDP.
 - ◇ DISCONNECT EXISTING PUMP AND PROVIDE NEW CIRCUIT TO REPLACEMENT PUMP USING 3#10, #10G, 1" AND A NEW 60 AMP, 3 POLE CIRCUIT BREAKER. VERIFY CIRCUIT AND CIRCUIT BREAKER SIZE WITH EQUIPMENT MANUFACTURER.

HQ BUILDING POWER PLAN
SCALE: 1/4"=1'-0" 1

