

- CONSULTANTS:**
- CIVIL ENGINEER:  
MCLELLAND ENGINEERS
  - LANDSCAPE ARCHITECT:  
LARSON BURNS SMITH
  - STRUCTURAL ENGINEER:  
CROMWELL ENGINEERS INC.
  - MECH., ELEC., PLUMB. ENGINEER:  
CROMWELL ENGINEERS INC.
  - GLOBAL VILLAGE CONSULTANT  
CAMBRIDGE SEVEN ASSOCIATES
  - INTERIOR DESIGNER:  
POLK STANLEY ROWLAND  
CURZON PORTER ARCHITECTS
  - GENERAL CONTRACTOR:  
CDI CONTRACTORS, INC.

**NOTES:**

---



---



---



---



---



---



---



---

ISSUE DATE:  
17 SEPTEMBER 2007

REVISIONS:

#	DATE	DESCRIPTION


MURPHY - KELLER  
EDUCATIONAL CENTER

HEIFER  
INTERNATIONAL  
CENTER  
LITTLE ROCK, ARKANSAS

PSRCP JOB NUMBER:  
431E

CONTENTS:  
MEZZANINE LIGHTING  
PLAN

SHEET NUMBER:  
**E101A-L**

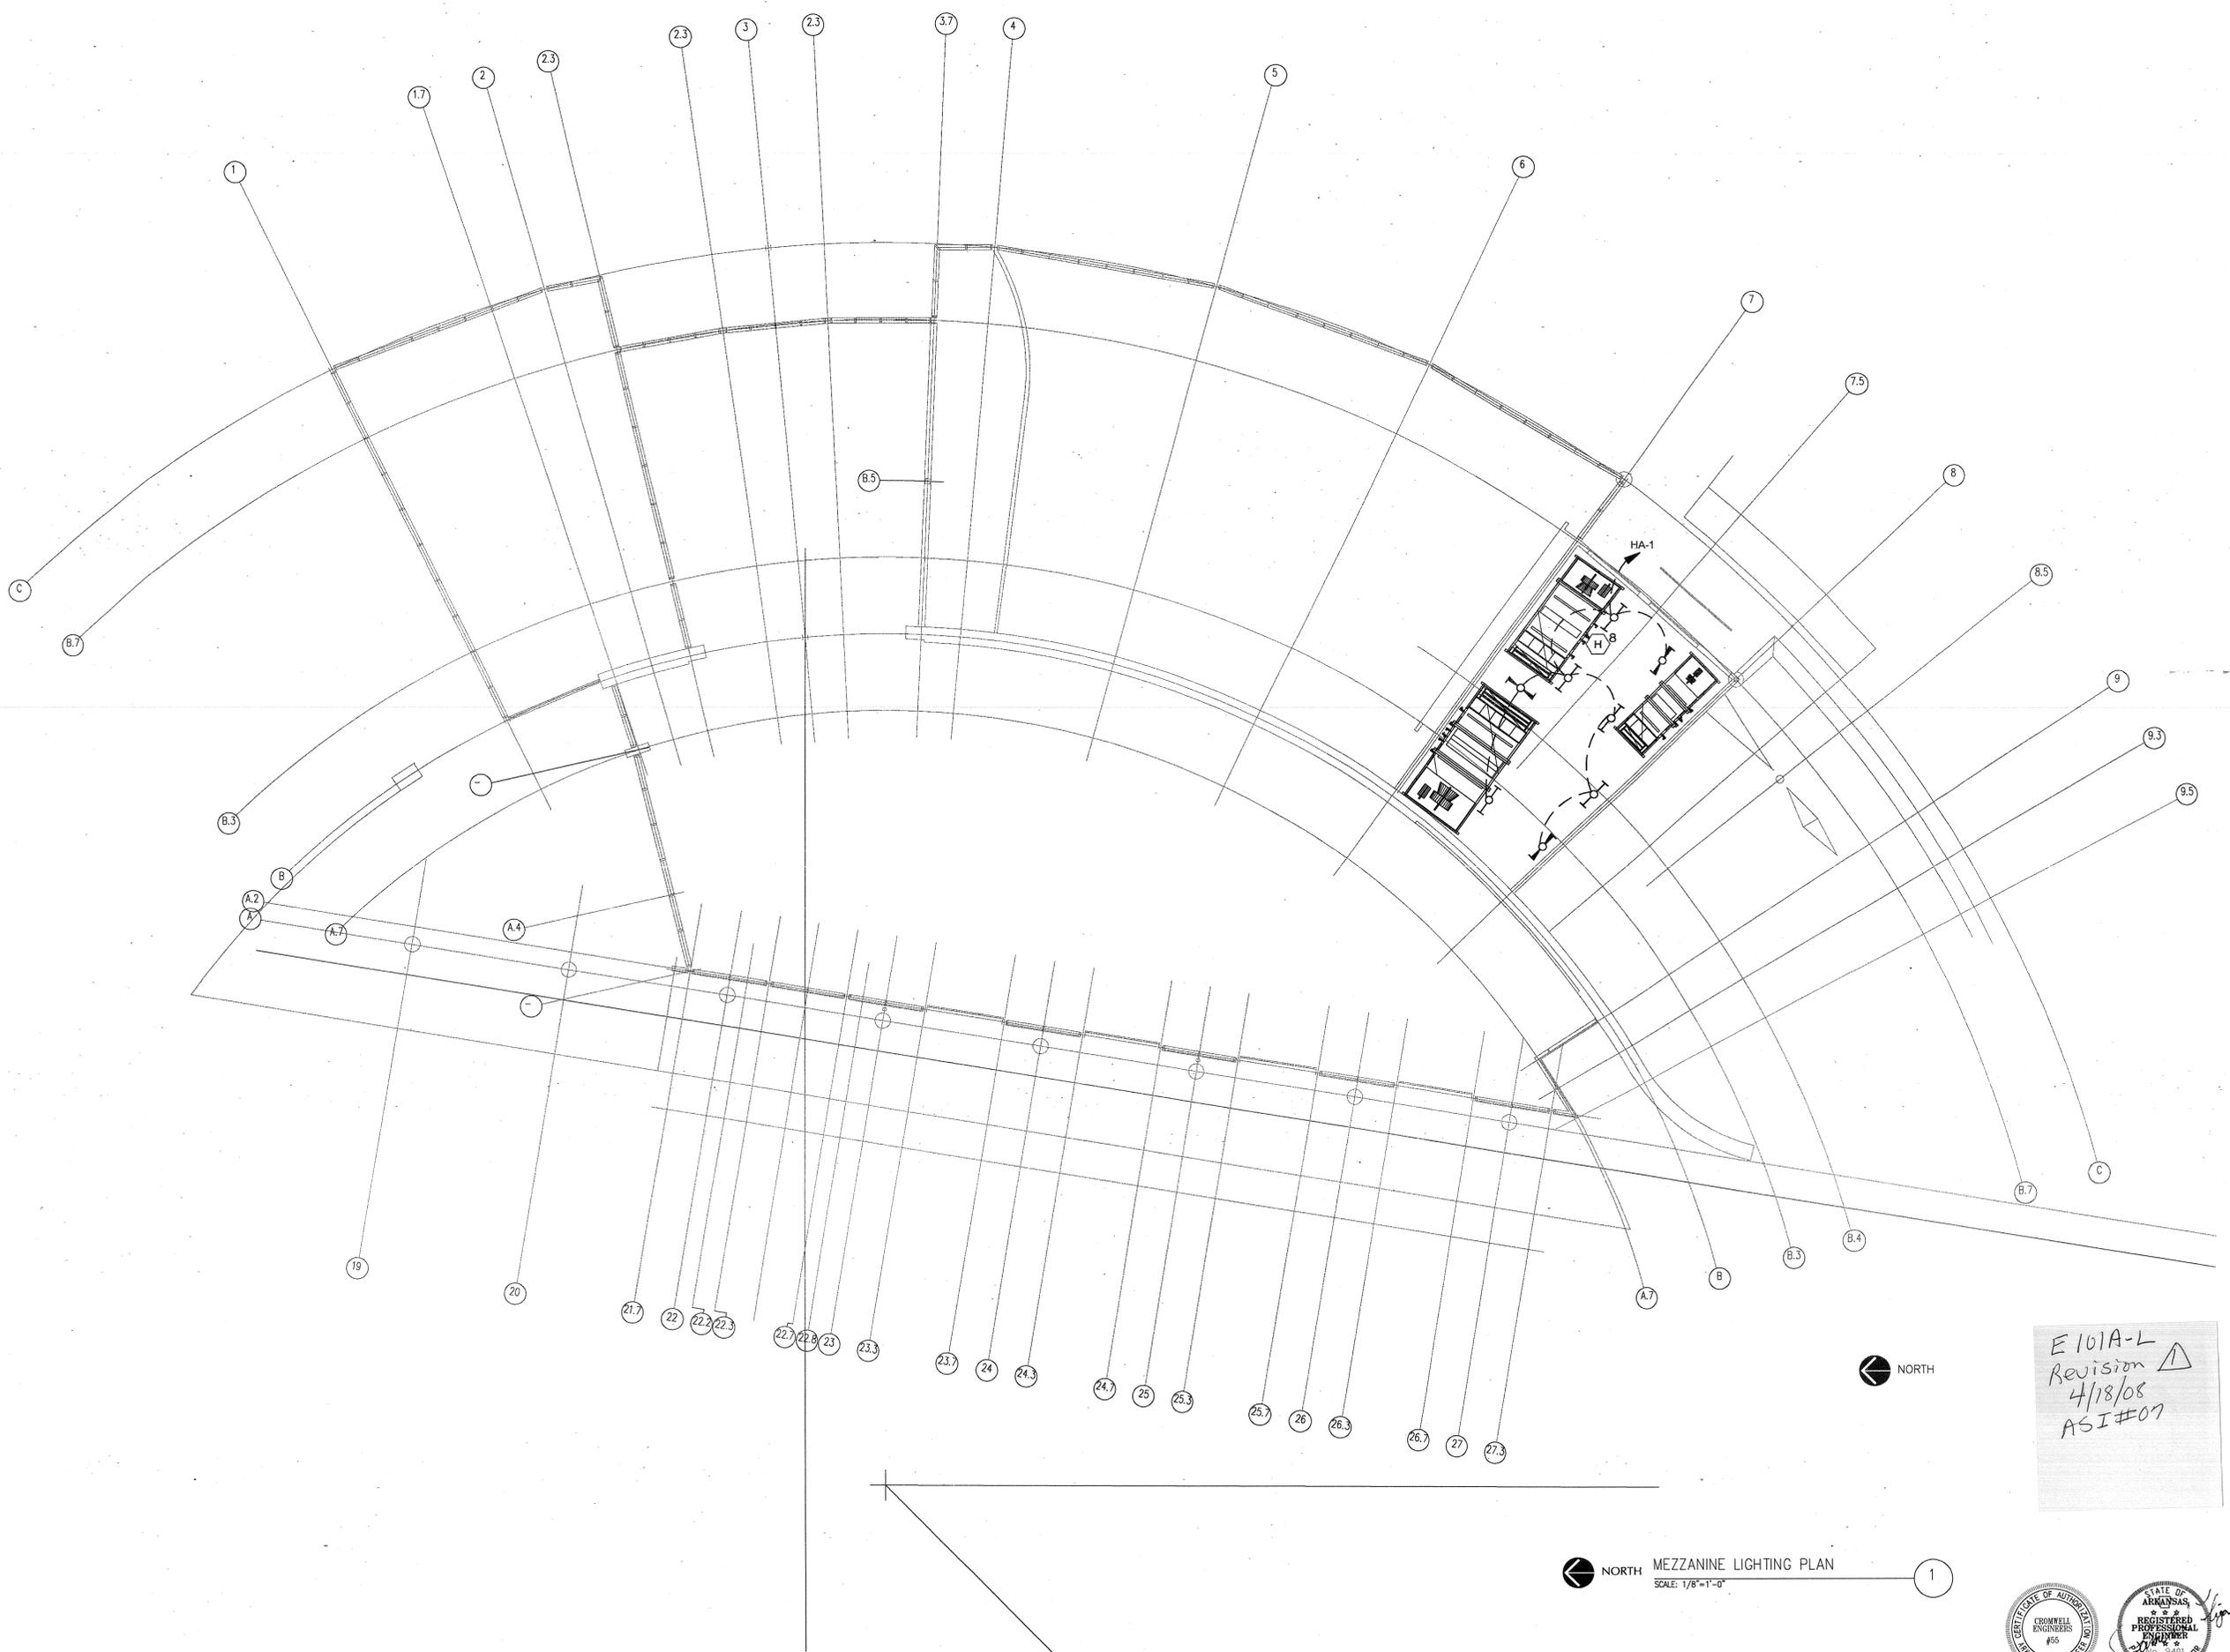

E101A-L  
Revision  
4/18/08  
ASI#07

**MEZZANINE LIGHTING PLAN**  
SCALE: 1/8"=1'-0"

