

700 SOUTH SCHILLER
LITTLE ROCK, AR 72201
501.378.0878 office
501.372.7629 fax

509 W. SPRING STREET,
SUITE 150
FAYETTEVILLE, AR 72701
479.444.0473 office
473.251.7216 fax

www.polkstanley.com

CONSULTANTS:

CIVIL ENGINEER:
MCCELLEND ENGINEERS

LANDSCAPE ARCHITECT:
LARSON BURNS SMITH

STRUCTURAL ENGINEER:
CROMWELL ENGINEERS INC.

MECH., ELEC., PLUMB. ENGINEER:
CROMWELL ENGINEERS INC.

GLOBAL VILLAGE CONSULTANT
CAMBRIDGE SEVEN ASSOCIATES

INTERIOR DESIGNER:
POLK STANLEY ROWLAND
CURZON PORTER ARCHITECTS

GENERAL CONTRACTOR:
CDI CONTRACTORS, INC.

NOTES:

- _____
- _____
- _____
- _____
- _____
- _____
- _____
- _____

ISSUE DATE:
17 SEPTEMBER 2007

REVISIONS:

#	DATE:	DESCRIPTION:
Δ	02/27/09	ASI #37

**MURPHY - KELLER
EDUCATIONAL CENTER**

**HEIFER
INTERNATIONAL
CENTER**

LITTLE ROCK, ARKANSAS

PSRCP JOB NUMBER:

431E

CONTENTS:

MEZZANINE POWER PLAN

SHEET NUMBER:


E101A-P

GENERAL NOTES:

1. COORDINATE LOCATION AND REQUIREMENTS OF DUCT SMOKE DETECTORS WITH MECHANICAL.

KEYED NOTES:

- ① MAKE CONNECTIONS TO VFD
- ② FOR CONTROL PANEL. VERIFY LOCATION WITH MECHANICAL
- ③ VERIFY LOCATION WITH MECHANICAL EQUIPMENT, MECHANICAL CLEARANCES, AND ARCHITECTURAL/STRUCTURAL ITEMS. LOCATION TO MEET ALL NEC REQUIREMENTS.

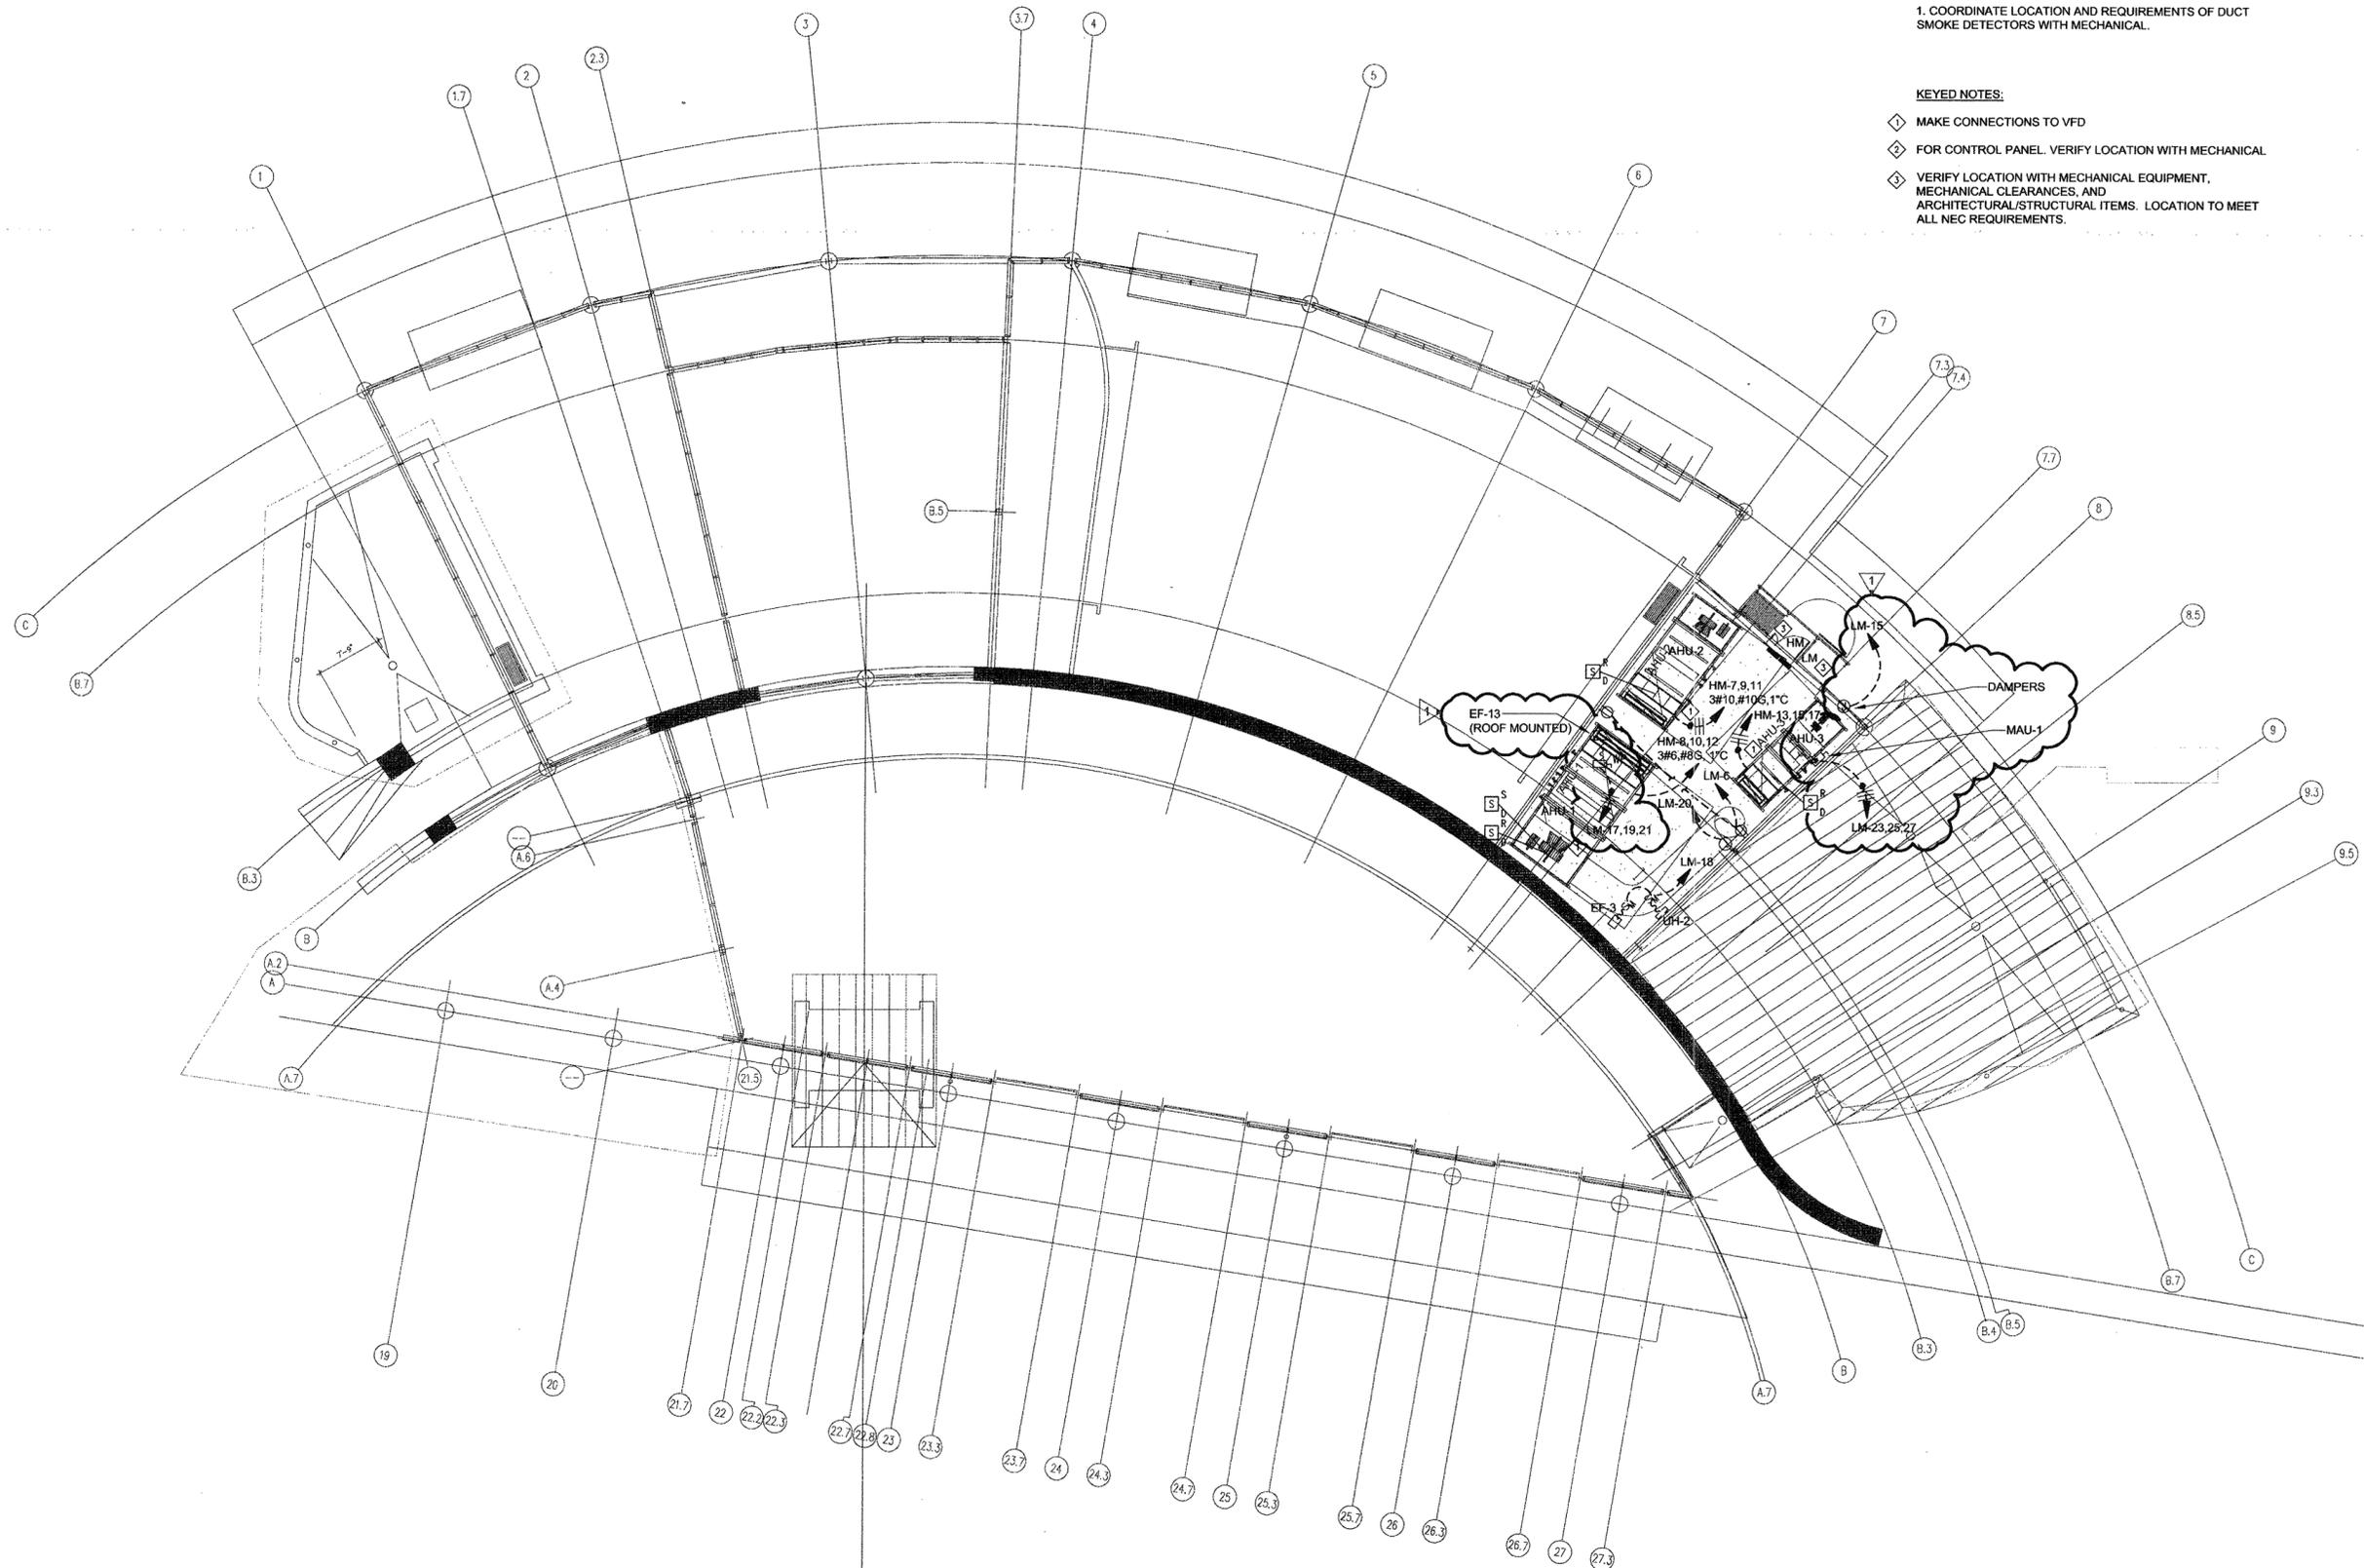

MEZZANINE POWER PLAN
SCALE: 1/8"=1'-0"

1

