

- CONSULTANTS:**
- CIVIL ENGINEER: MCCLELLAND ENGINEERS
 - LANDSCAPE ARCHITECT: LARSON BURNS SMITH
 - STRUCTURAL ENGINEER: CROMWELL ENGINEERS INC.
 - MECH., ELEC., PLUMB. ENGINEER: CROMWELL ENGINEERS INC.
 - GLOBAL VILLAGE CONSULTANT: CAMBRIDGE SEVEN ASSOCIATES
 - INTERIOR DESIGNER: POLK STANLEY ROWLAND CURZON PORTER ARCHITECTS
 - GENERAL CONTRACTOR: CDI CONTRACTORS, INC.

NOTES:

ISSUE DATE:
17 SEPTEMBER 2007

REVISIONS:

#	DATE	DESCRIPTION

MURPHY - KELLER
EDUCATIONAL CENTER
**HEIFER
INTERNATIONAL
CENTER**
LITTLE ROCK, ARKANSAS

PSRCP JOB NUMBER:
431E

CONTENTS:
POWER PLAN


SHEET NUMBER:
E101-P

KEYED NOTES:

- ① MOUNT ON TOP OF WALL
- ② COORDINATE WITH LOCATION OF MICROWAVE.
- ③ COORDINATE OUTLET TYPE(S) CIRCUIT BREAKER, CONDUCTOR AND CONDUIT SIZES WITH EQUIPMENT (STACKING OVENS). CIRCUIT AS REQUIRED BY EQUIPMENT.
- ④ FOR DISPOSER. PROVIDE WALL MOUNTED SWITCH AND MAKE ALL CONNECTIONS.
- ⑤ FOR SCREEN. MAKE CONNECTIONS TO UP-OFF-DOWN SWITCH AND/OR AV CONTROLS AS REQUIRED
- ⑥ FOR SHADES. VERIFY LOCATION AND REQUIREMENTS WITH SHADE PROVIDER. VERIFY ROUTING OF CONDUIT AND CONNECTION LOCATIONS WITH ARCHITECTURAL.
- ⑦ VERIFY CONDUCTOR/ CIRCUIT REQUIREMENTS
- ⑧ MAKE CONNECTIONS TO VFD.
- ⑨ COORDINATE POWER DOOR REQUIREMENTS WITH ARCHITECTURAL
- ⑩ MAKE ALL CONNECTIONS BETWEEN MHP-1 AND MAC-1.

GENERAL NOTES:

1. PROVIDE FLOOR BOXES, JUNCTION BOXES, AND CONDUIT BETWEEN AV DEVICES AS SHOWN ON AV DRAWINGS.
2. SEE ARCHITECTURAL FOR LOCATION OF ALL DEVICES, BOXES, CONDUIT, ETC., EXPOSED TO VIEW INCLUDING ROOF MOUNTED DEVICES.

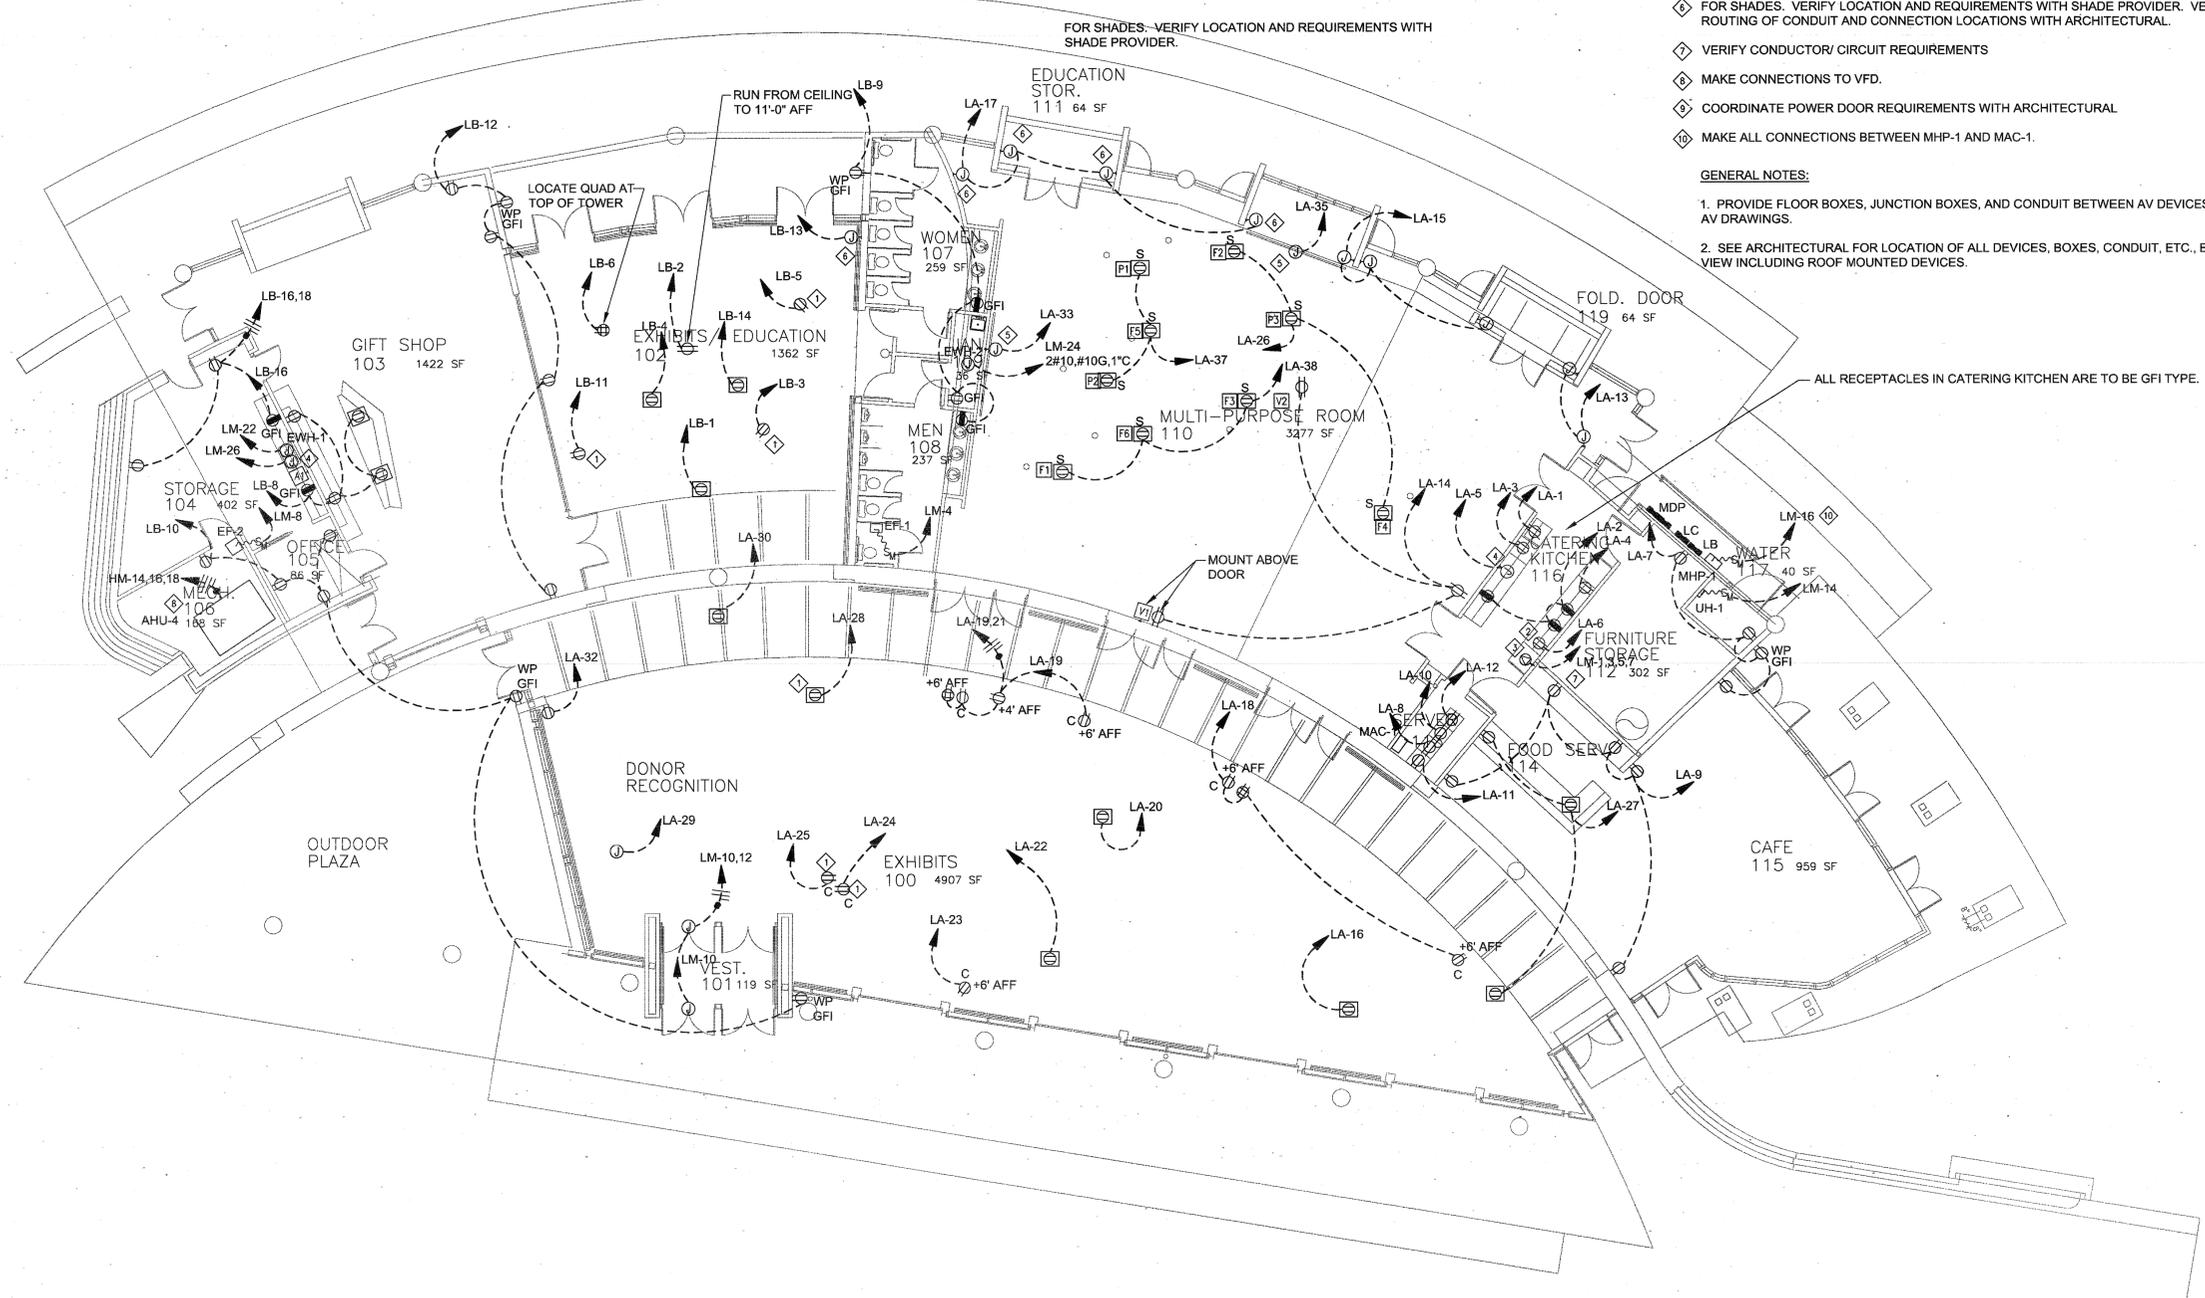

POWER PLAN
SCALE: 1/8"=1'-0"

1

