

- CONSULTANTS:**
- CIVIL ENGINEER: MCCLELLAND ENGINEERS
 - LANDSCAPE ARCHITECT: LARSON BURNS SMITH
 - STRUCTURAL ENGINEER: CROMWELL ENGINEERS INC.
 - MECH., ELEC., PLUMB. ENGINEER: CROMWELL ENGINEERS INC.
 - GLOBAL VILLAGE CONSULTANT: CAMBRIDGE SEVEN ASSOCIATES
 - INTERIOR DESIGNER: POLK STANLEY ROWLAND CURZON PORTER ARCHITECTS
 - GENERAL CONTRACTOR: CDI CONTRACTORS, INC.

NOTES:

ISSUE DATE:
17 SEPTEMBER 2007

REVISIONS:

#	DATE	DESCRIPTION
△	9/27/07	ADDENDUM #1
△	07 JAN 08	ASI #01
△	07 MAR 08	ASI #05
△	5/16/08	ASI # 14

MURPHY - KELLER
EDUCATIONAL CENTER


HEIFER
INTERNATIONAL
CENTER
LITTLE ROCK, ARKANSAS

PSRCP JOB NUMBER:
431E
CONTENTS:
SYSTEMS PLAN

SHEET NUMBER:
E101-S

- KEYED NOTES:**
- ◇ FIRE ALARM PANEL LOCATION - PROVIDE SMOKE DETECTOR
 - ◇ FIRE ALARM REMOTE ANNUCIATOR LOCATION.
 - ◇ MOUNT ON TOP OF VESTIBULE
 - ◇ TAP NETWORK DATA DROPS. MOUNT AT 9 - 10' AFF. OR AS INDICATED. SEE GENERAL NOTE 1.
 - ◇ CEILING MOUNT
 - ◇ "J" NUMBERS REFER TO ACT AV DRAWINGS. MAKE ALL CONNECTIONS.
 - ◇ MOUNT ABOVE CABINET

- GENERAL NOTES:**
1. SEE ARCHITECTURAL FOR LOCATION OF ALL DEVICES, BOXES, CONDUIT, ETC., EXPOSED TO VIEW INCLUDING ROOF MOUNTED DEVICES.
 2. VERIFY FIRE SPRINKLER RISER LOCATION AND REQUIREMENTS. PROVIDE FLOW AND TAMPER SWITCHES BASED ON CODE AND ACTUAL INSTALLATION.
 3. VERIFY HORN/STROBE LOCATIONS WITH EXHIBITS, CODE, AND CANDELLA RATING. PROVIDE COVERAGE THAT MEETS OR EXCEEDS ALL CODE REQUIREMENTS.
 4. PROVIDE FLOOR BOXES, JUNCTION BOXES, AND CONDUIT BETWEEN AV DEVICES AS SHOWN ON AV DRAWINGS.
 5. ROUTE COMMUNICATIONS CONDUITS GOING TO COMMON LOCATIONS TO A CENTRAL POINT IN A NON-PUBLIC SPACE. THEN ROUTE ONE LARGER CONDUIT FROM A JUNCTION BOX TO THE RACK/AV CLOSET, ETC. SIZE LARGER CONDUIT FOR NO MORE THAN 40% FILL. THIS NOTE DOES NOT APPLY TO AV CONDUITS INDICATED ON EITHER SET OF AV DRAWINGS

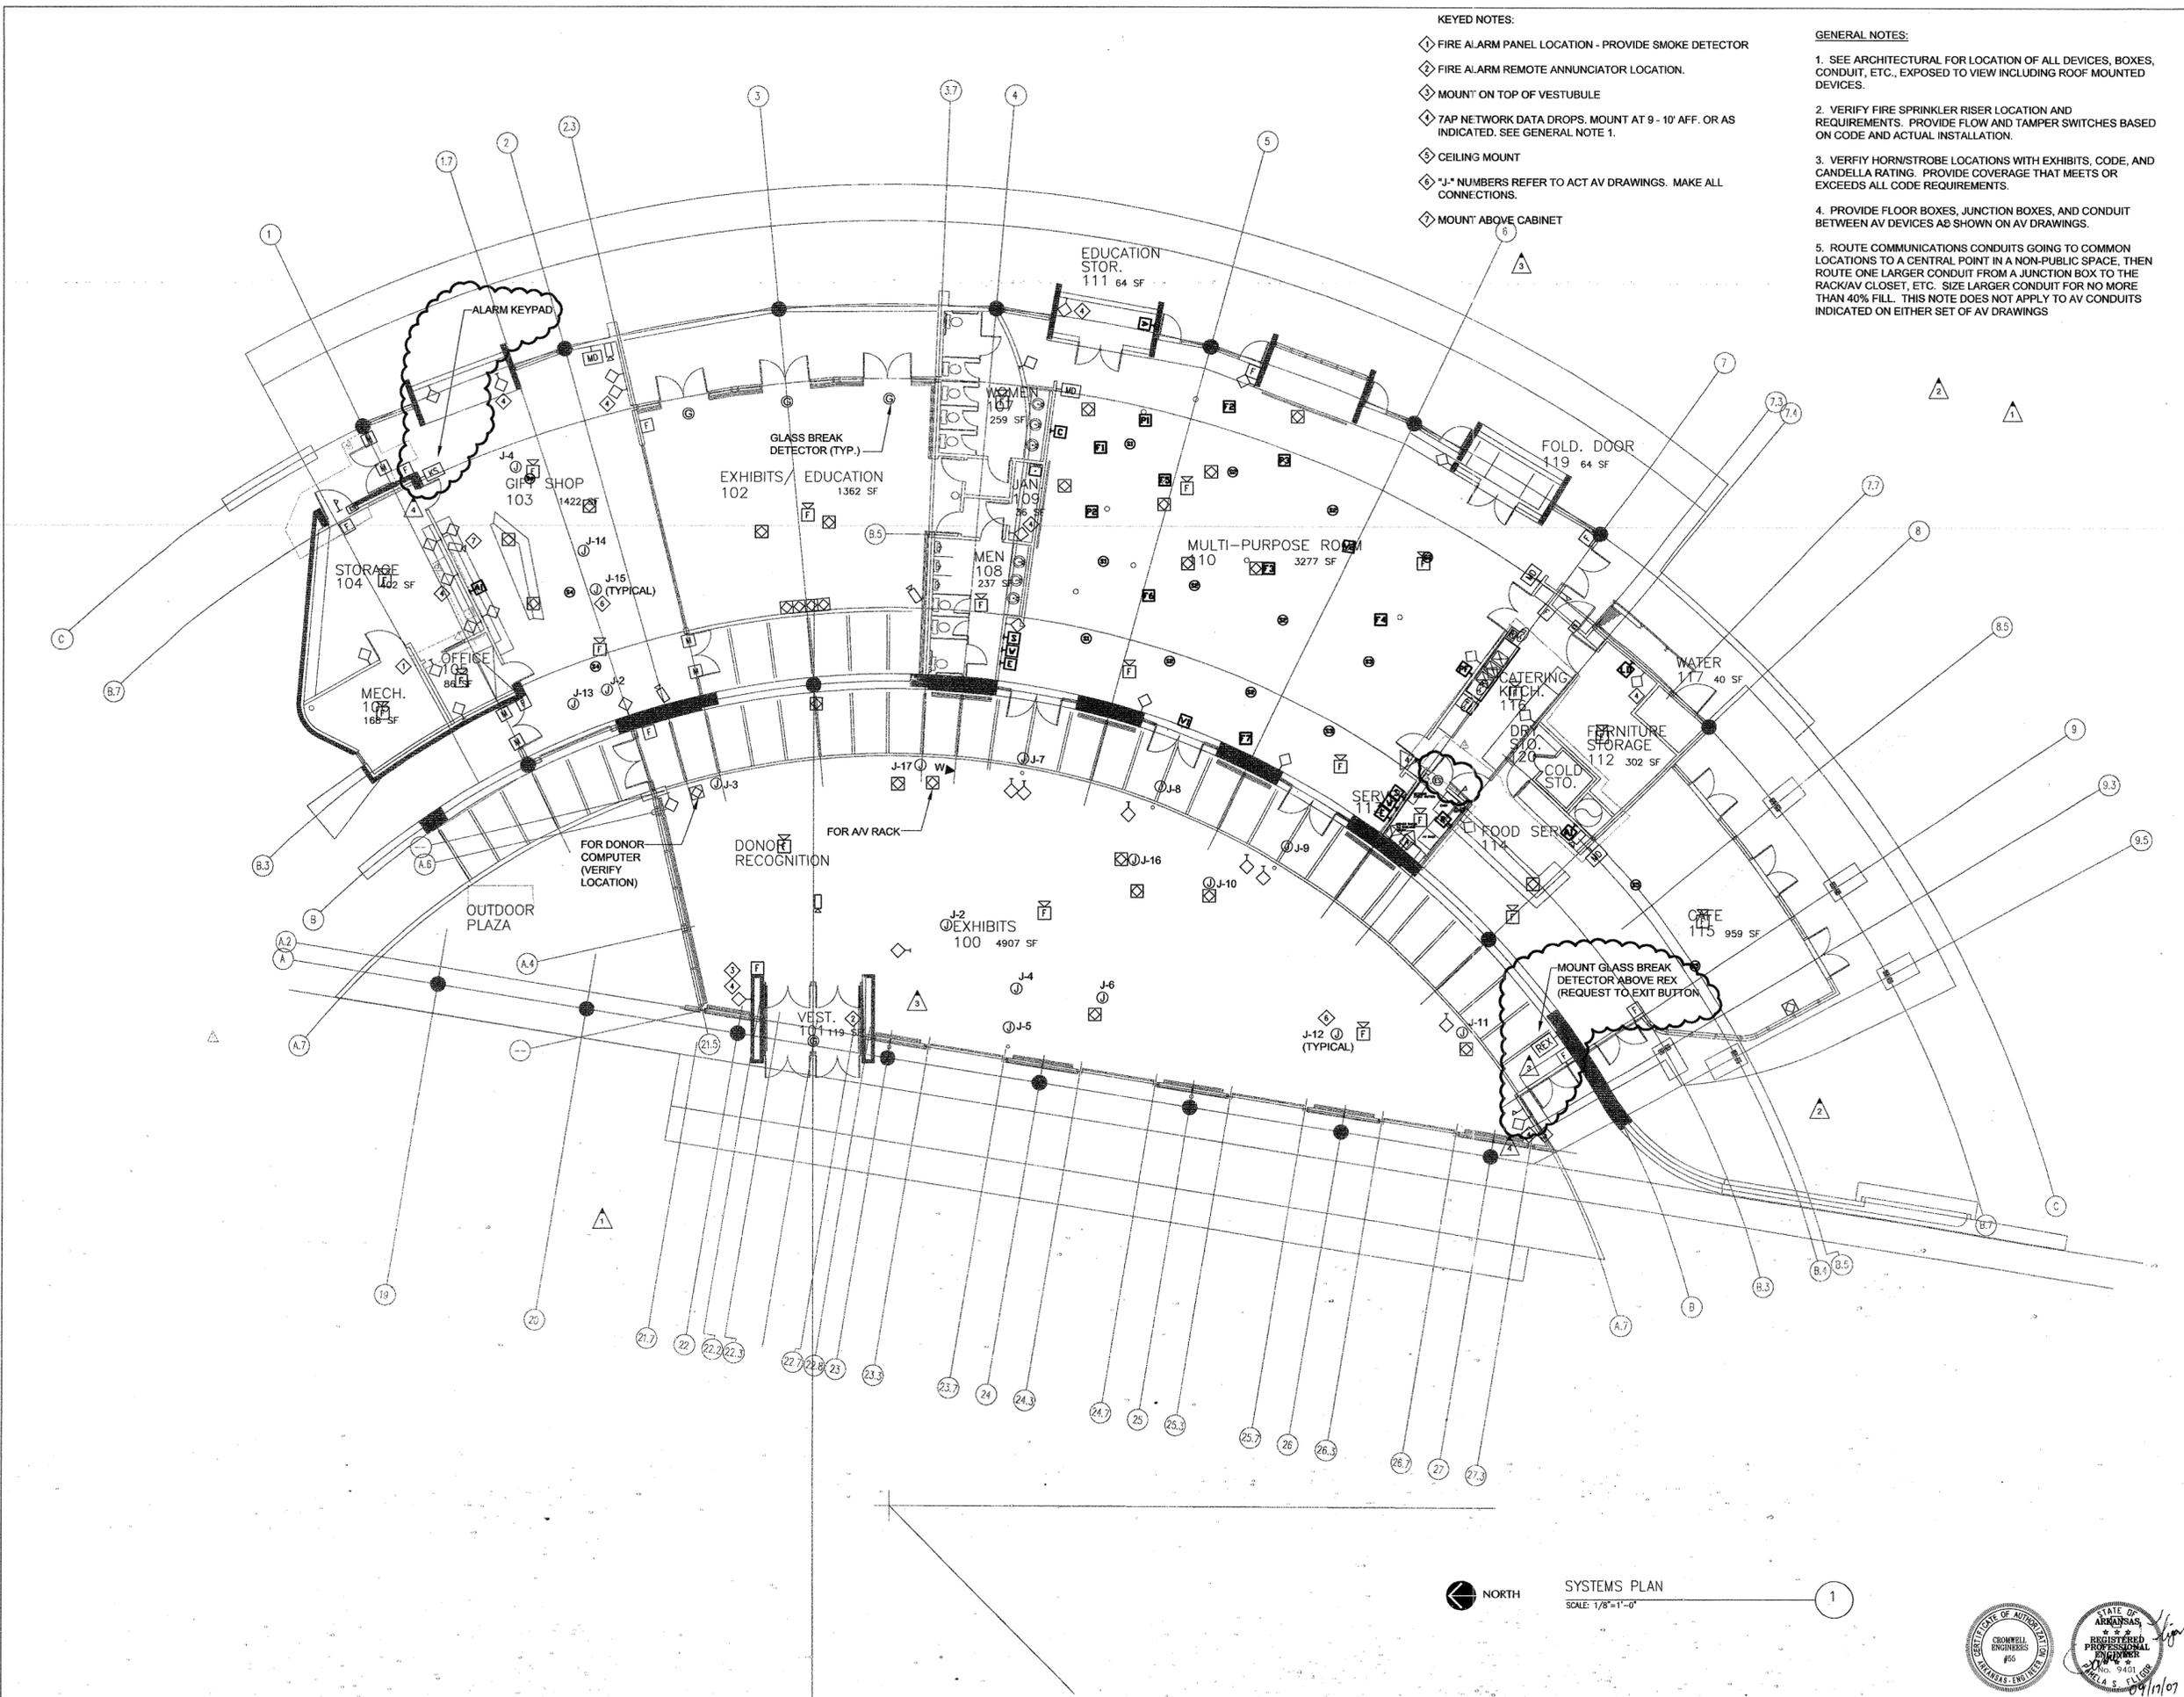

SYSTEMS PLAN
SCALE: 1/8"=1'-0"

1

