

EQUIPMENT LIST			
ITEM NO	QTY	EQUIPMENT CATEGORY	EQUIPMENT REMARKS
01	2	HAND SINK	WALL BACKING REQUIRED BY G.C. *
02	1	ICE MAKER W/ BIN	
03	1	REACH-IN FREEZER	
04	1	CHARBROILER W/ CABINET BASE	
05	1	WORK TABLE W/ SHELVES	WALL BACKING REQUIRED BY G.C. *
06	1	UNDERCOUNTER DISHWASHER	BELOW DRAINBOARD
07	1	3 COMP'T SINK W/SHELVES & POT RACK	WALL BACKING REQUIRED BY G.C. *
08	1	UTILITY CART	NOT SHOWN
09	1	VENT HOOD W/ FIRE SUPPRESSION	
10	1	RANGE ON CONVECTION OVEN BASE	
11	1	WORK TOP REFRIG. W/ SHELVES	WALL BACKING REQUIRED BY G.C. *
12	2	MOBILE PAN RACK	
13	1	CONVEYOR OVEN	VERIFY CLEARANCE REQUIREMENT
14	2	MOBILE TABLE	
15	1	GRIDDLE ON CONVECTION OVEN BASE	
16	1	FRYER	
17	1	WORK TABLE	
18	1	STAINLESS STEEL SHELF UNIT	
19	5	STORAGE SHELVING	2 UNITS WITH CASTERS
20	1	COOLER SHELVING PACKAGE	
21	1	WALK-IN COOLER	
22	1	VENTLESS GRIDDLE/FRYER	
23	1	SANDWICH PREP UNIT W/ OVERSHELVES	WALL BACKING REQUIRED BY G.C. *
24	1	WORK COUNTER	
25	1	UNDERCOUNTER REFRIGERATOR	
26	1	PANINNI GRIDDLE	
27	2	PORTABLE FOOD WELL	
28	1	GRAB & GO DISPLAY	
29	1	CASH REGISTER	BY OTHERS
30	1	PHONE	BY OTHERS
31	1	FRONT COUNTER	
32	1	HEATED CABINET	
33	1	UNDERCOUNTER FREEZER	
34	1	BEVERAGE COUNTER	
35	1	ICE/BEVERAGE DISPENSER	
36	1	COFFEE BREWER(120/208)	W/ PORTABLE SATELLITES
37	1	TEA MAKER	W/ PORTABLE DISPENSERS
38	2	TRASH RECEPTACLE	VERIFY LOCATION WITH OWNER
39	1	DISPOSAL	
40	1	S/S DOOR TRIM	

* ALL WALL SHELVES TO BE TWO TIER --SEE BACKING DETAILS ON PAGE K4 FOR WALL MOUNTED ITEMS

GENERAL NOTES

- A- KITCHEN EQUIPMENT CONTRACTOR TO DELIVER AND SET IN PLACE ALL NEW EQUIPMENT. ALL ITEMS LABELED AS "EXISTING" OR "BY OTHERS" SHALL BE DELIVERED AND SET BY OTHERS.
- B- KITCHEN EQUIPMENT CONTRACTOR SHALL DELIVER WALK-INS, ERECT PANELS AS SHOWN, MOUNT ALL REFRIGERATION COMPONENTS, INSTALL REFRIGERATION LINES, CHARGE SYSTEM, AND MAKE SYSTEM READY FOR FINAL ELECTRICAL AND PLUMBING CONNECTIONS BY RESPECTIVE TRADES. ALL WIRING, CONTROL WIRING AND DRAINLINE HEATER BY ELECTRICAL, EVAPORATOR DRAINS BY PLUMBING
- C- VENT HOOD, FANS AND CURBS TO BE SUPPLIED BY KITCHEN CONTRACTOR. HANGING OF HOOD BY KITCHEN EQUIPMENT CONTRACTOR. DUCTWORK TO BE PROVIDED AND INSTALLED BY MECHANICAL.
- D- FANS & CURBS TO BE LOCATED AND INSTALLED BY MECHANICAL AND/OR GENERAL CONTRACTOR
- E- GENERAL CONTRACTOR TO PROVIDE ALL WALL BACKING NECESSARY FOR WALL MOUNTED ITEMS AND ALL WALL/ROOF/FLOOR PENETRATIONS REQUIRED. COORDINATE ON SITE.
- F- COORDINATE WITH OTHER TRADES WHEN LOCATING PERMANENT FIXTURES.
- G- DO NOT LOCATE HVAC DIFFUSERS NEAR VENT HOOD. IF NECESSARY, USE PERFORATED TYPE.
- H- KITCHEN EQUIPMENT CONTRACTOR NOT RESPONSIBLE FOR ANY ARCHITECTURAL DEVIATIONS FROM THIS PLAN

SCALE: 1/4" = 1'

SHEET TITLE:
**KITCHEN EQUIPMENT
 ARRANGEMENT PLAN**

HEIFER INTERNATIONAL
PHASE 2 BUILDING
LITTLE ROCK , AR





SHEET NO.
K1
 SHEET 1 OF 5
 PROJECT NO.
 HEIF01
 DATE
 03/13/08
 REVISION
 02/02/09

DRAWN BY: MT



VENT HOOD NOTES

- H1. E.C. TO PROVIDE 2 EACH 208/1/15AMP CIRCUITS TO FIRE CABINET FOR POWER TO FAN CONTACTORS.
 - H2. E.C. TO FIELD WIRE FROM CONTACTORS TO EXHAUST AND SUPPLY FAN AS REQUIRED.
 - H3. E.C. TO PROVIDE 115/1/15AMP CIRCUIT TO FIRE CABINET FOR LIGHTS.
 - H4. E.C. TO FIELD WIRE FROM FIRE CABINET TO LIGHT JUNCTION BOX AT HOOD.
 - H5. E.C. TO PROVIDE 115/1/15AMP CIRCUIT TO FIRE CABINET FOR FIRE SYSTEM CONTROLS.
 - H6. E.C. TO INTERCONNECT DRY CONTACTS TO SHUNT TRIP AND BUILDING FIRE ALARM AS REQUIRED.
 - H7. E.C. TO FIELD WIRE FROM FIRE CABINET TO FAN SWITCH AT HOOD--NORMALLY THREE WIRES.
- *** SEE TYPICAL ELECTRICAL DIAGRAM THIS PAGE FOR ADDITIONAL INFORMATION.

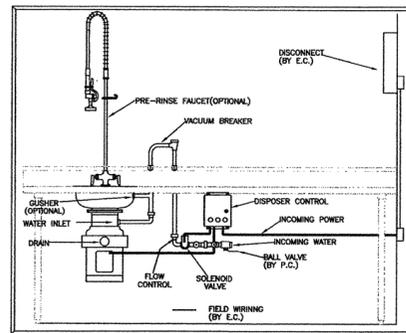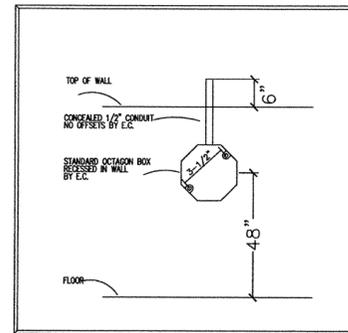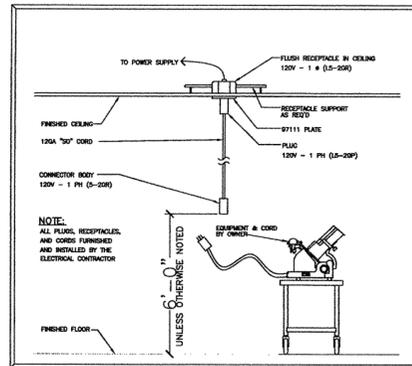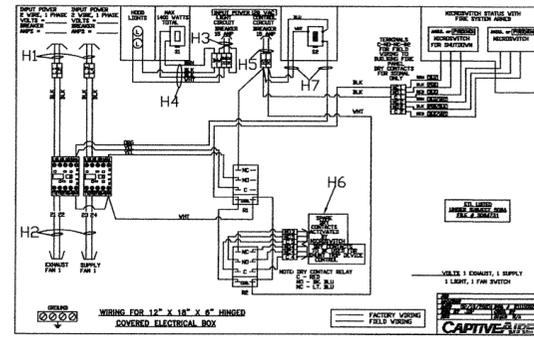

ELECTRICAL SCHEDULE

ITEM NO	QTY	DESCRIPTION	VOLTS	PHASE	AMPS	DIRECT PLUG	NEMA	ELECTRICAL AFF. (IN)	
02	1	ICE MAKER W/ BIN	208	1	16.0	X		84	ELECTRICAL ROUGH-IN
03	1	REACH-IN FREEZER	120	1	11.0		5-15P	30	E.C. TO SUPPLY CORD & ANGLE PLUG
06	1	UNDERCOUNTER DISHWASHER	208	3	45.0	X		8	SEE DISPOSER & DISCONNECT DETAILS
09	1	VENT HOOD W/ FIRE SUPPRESSION	230	1	5.4	X		108	SUPPLY FAN--SEE HOOD NOTES
		VENT HOOD W/ FIRE SUPPRESSION	230	1	10.2	X		108	EXHAUST FAN--SEE HOOD NOTES
		VENT HOOD W/ FIRE SUPPRESSION	115	1	15.0	X		108	HOOD CONTROLS--SEE HOOD NOTES
		VENT HOOD W/ FIRE SUPPRESSION	115	1	15.0	X		108	HOOD LIGHTS--SEE HOOD NOTES
10	1	RANGE ON CONVECTION OVEN BASE	115	1	5.0	X	5-15P	18	
11	1	WORK TOP REFRIG. W/ SHELVES	115	1	11.0	X	5-15P	30	
13	1	CONVEYOR OVEN	208	1	29.0	X		46	E.C. TO SUPPLY CORD & PLUG
14	1	MOBILE TABLE(DROP CORD)	120	1	20.0	X	5-20P	23	E.C. TO PROVIDE DROP CORDSET-- SEE DETAIL
15	1	GRIDDLE ON CONVECTION OVEN BASE	115	1	5.0	X	5-15P	18	
17	1	WORK TABLE	120	1	16.0	X	5-20P	44	CONVENIENCE OUTLET
21	1	WALK-IN COOLER	208	1	11.0	X	6-15P	106	POWER FOR REFRIGERATION ON TOP OF BOX
21.1			115	1	4.0	X		84	POWER FOR LIGHTS INSIDE BOX
22	1	VENTLESS GRIDDLE/FRYER	208	3	28.0	X	15-60P	3	LOCATE OUTLET UNDER BASE--6" MAX CLEAR
23	1	SANDWICH PREP UNIT W/ OVERSHELVES	115	1	5.0	X	5-15P	12	
24	1	WORK COUNTER	120	1	18.0	X	5-20P	44	CONVENIENCE OUTLET
25	1	UNDERCOUNTER REFRIGERATOR	115	1	4.0	X	5-15P	12	E.C. TO WIRE TO OUTLET IN COUNTER
26	1	PANINNI GRIDDLE	208	1	13.0	X	5-15P	41	E.C. TO WIRE TO OUTLET IN COUNTER
27	2	PORTABLE FOOD WELL	115	1	12.0	X	5-15P	41	E.C. TO WIRE TO OUTLET IN COUNTER
28	1	GRAB & GO DISPLAY	220	1	14.0	X	14-20P	10	E.C. TO WIRE TO OUTLET IN COUNTER--4WIRES
29	1	CASH REGISTER	120	1	20.0	X	5-20P	23	BY OWNER--E.C. WIRE TO OUTLET IN COUNTER
30	1	PHONE							E.C. TO PULL DATA CABLE AS REQ'D
31	1	FRONT COUNTER							ROUTE POWER TO EQUIPMENT THROUGH CHASE
32	1	HEATED CABINET	120	1	17.0	X	5-20P	48	
33	1	UNDERCOUNTER FREEZER	115	1	9.0	X	5-15P	12	E.C. TO WIRE TO OUTLET IN COUNTER
34	1	BEVERAGE COUNTER	115	1	15.0	X	5-20P	46	CONVENIENCE OUTLET
34.1	1	POWER FOR CARBONATOR	115	1	15.0	X		24	CARBONATOR BY OTHERS
35	1	ICE/BEVERAGE DISPENSER	120	1	4.0	X	5-15P	24	COORDINATE POWER WITH VENDOR
36	1	COFFEE BREWER(120/208)	220	1	29.0	X		50	3 WIRES & GROUND--E.C. TO PROVIDE CORDSET
37	1	TEA MAKER	120	1	13.0	X	5-20P	52	
39	1	DISPOSAL	208	3	4.0	X		12	COORDINATE DISCONNECT W/ EQUIPMENT
V0	2	FUTURE VENDING MACHINES(BY OWNER)	120	1	20.0	X	5-20P	18	COORDINATE POWER WITH OWNER

* - SEE MILLWORK SHOP DRAWING FOR ADDITIONAL DETAILS. E.C. TO INTERCONNECT ALL OUTLETS BUILT-IN TO COUNTER THROUGH CHASE AND FINAL CONNECT TO OUTLETS AS REQUIRED.

GENERAL NOTES

- A- ELECTRICAL CONTRACTOR TO PROVIDE ALL LABOR AND MATERIAL NECESSARY TO ROUGH-IN AND MAKE FINAL CONNECTIONS TO ALL KITCHEN EQUIPMENT PER ALL APPLICABLE CODES INCLUDING BUT NOT LIMITED TO CONTROL WIRING, STARTERS, OVERLOADS, DISCONNECTS, SHUNT DEVICES AND CORDSETS REQUIRED TO MAKE EACH ITEM FULLY FUNCTIONAL.
- B- ELECTRICAL CONTRACTOR TO VERIFY REQUIREMENTS FOR ALL ITEMS DENOTED AS "EXISTING" OR "BY OTHERS" BEFORE ROUGHING IN AND MAKING FINAL CONNECTIONS
- C- ELECTRICAL CONTRACTOR TO FURNISH AND INSTALL ALL STARTERS, OVERLOADS AND DISCONNECTS THAT ARE NOT INCLUDED AS STANDARD ITEMS FOR KITCHEN EQUIPMENT
- D- SEE ARCHITECTURAL DRAWINGS FOR CONTINUATION OF ELECTRICAL OF OUTLETS
- E- ALL WIRING, CONDUIT, JUNCTION BOXES, RECEPTACLES AND DISCONNECT SWITCHES IN WET OR COLD AREAS ARE TO BE WEATHER TIGHT, COMMERCIAL GRADE GFCI OUTLETS AS APPLICABLE
- F- THIS PLAN ONLY COVERS KITCHEN ITEMS, ROUGH IN REQUIREMENTS FOR OTHER EQUIPMENT SHALL BE COORDINATED IN OTHER PLANS. VERIFY ADDITIONAL OUTLETS WITH ARCHITECT
- G- ALL PIPING FOR ROUGH-INS SHALL BE CONCEALED
- H- ELECTRICAL CONTRACTOR TO ROUGH-IN OCTAGON BOX FOR FIRE SYSTEM REMOTE PULL VERIFY TAB LOCATION WITH SYSTEM SUPPLIER (SEE DETAIL THIS PAGE)


SCALE: 1/4" = 1'

SHEET TITLE:
**KITCHEN EQUIPMENT
ELECTRICAL PLAN**

HEIFER INTERNATIONAL
PHASE 2 BUILDING
LITTLE ROCK, AR


SHEET NO.
K2
SHEET 2 OF 5
PROJECT NO.
HEIF01
DATE
03/13/08
REVISION
02/02/09

DRAWN BY: MT

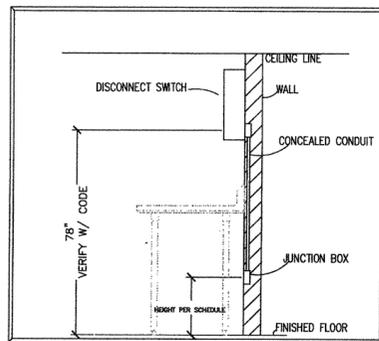

- LEGEND**
- ⊕ - DUPLEX OUTLET
 - - SINGLE OUTLET
 - ⊖ - DROP CORD
 - ⊞ - JUNCTION BOX
 - ⊞ - DISCONNECT *
 - ⊞ - SWITCH
 - KEC - KITCHEN EQUIPMENT CONTRACTOR
 - AFF - ABOVE FINISHED FLOOR
 - CO - CONVENIENCE OUTLET
 - E.C. - ELECTRICAL CONTRACTOR




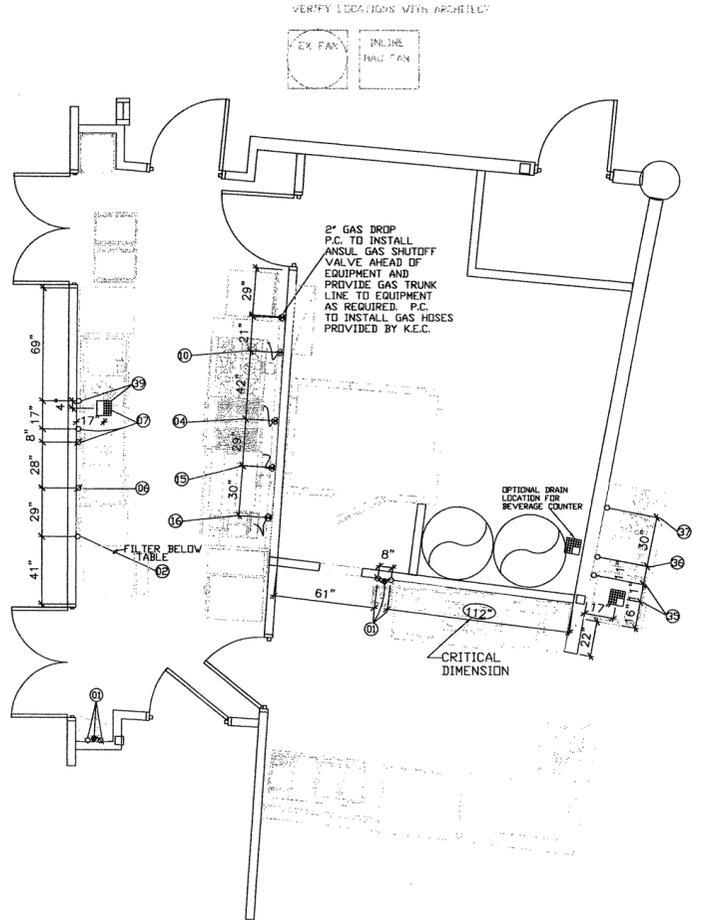

PLUMBING SCHEDULE																	
ITEM NO	QTY	DESCRIPTION	COLD WATER SIZE (IN)	COLD WATER AFF (IN)	COLD-WATER ROUGH-IN	HOT WATER SIZE (IN)	HOT WATER AFF (IN)	HOT-WATER ROUGH-IN	DIRECT DRAIN SIZE (IN)	DIRECT DRAIN AFF (IN)	INDIR DRAIN SIZE (IN)	INDIR DRAIN AFF (IN)	INDIRECT-DRAIN ROUGH-IN	GAS SIZE (IN)	GAS AFF (IN)	MBTUH	GAS ROUGH-IN
01	2	HAND SINK	1/2	20		1/2	20		1-1/2	17							
02	1	ICE MAKER W/ BIN	3/8	28	CONNECT THROUGH FILTER						3/4		F.S. BIN DRAIN --- ROUTE TO F.S. BY P.C.				
04	1	CHARBROILER W/ CABINET BASE									3/4		F.S. PURGE DRAIN---ROUTE TO F.S. BY P.C.				
06	1	UNDERCOUNTER DISHWASHER				1/2		110 DEGREE WATER REQ'D			5/8		F.S. P.C. TO ROUTE TO FLOOR SINK				
07	1	3 COMP'T SINK W/SHELVES & POT RACK	1/2	15		1/2	15				2		F.S. P.C. TO ROUTE TO FLOOR SINK				
10	1	RANGE ON CONVECTION OVEN BASE												3/4	12	230	BRANCH TO CONNECTION
15	1	GRIDDLE ON CONVECTION OVEN BASE												3/4	12	96	BRANCH TO CONNECTION
16	1	FRYER												3/4	12	110	BRANCH TO CONNECTION
34	1	BEVERAGE COUNTER										1	F.S. P.C. TO ROUTE DRAINS TO F.S.				
35	1	ICE/BEVERAGE DISPENSER	1/2	18	BRANCH TO CONNECTION						3/4		F.S. P.C. TO ROUTE DRAINS TO F.S.				
36	1	COFFEE BREWER(120/208)	1/2	48	BRANCH TO CONNECTION												
37	1	TEA MAKER	1/2	48	BRANCH TO CONNECTION												
39	1	DISPOSAL	1/2	12	BRANCH TO CONNECTION							2	F.S. P.C. TO ROUTE DRAIN THROUGH INTERCEPTOR				

GENERAL NOTES

- A- PLUMBING CONTRACTOR TO PROVIDE ALL LABOR AND MATERIAL NECESSARY TO ROUGH-IN, TRIM, AND MAKE FINAL CONNECTIONS TO KITCHEN EQUIPMENT PER ALL APPLICABLE CODES. INCLUDES BUT NOT LIMITED TO VALVES, STOPS, TRIM, INDIRECT LINES AND DRAINS, REGULATORS, TRAPS, INSULATION, ETC., NOT SUPPLIED WITH KITCHEN EQUIPMENT
- B- PLUMBING CONTRACTOR TO FLUSH ALL LINES BEFORE MAKING FINAL CONNECTIONS
- C- REFER TO PLUMBING DRAWINGS FOR CONTINUATION OF OUTLETS
- D- THIS PLAN COVERS KITCHEN EQUIPMENT ROUGH-INS, OTHER ITEMS TO BE SET BY OTHERS
- E- ROUGH INS SHOULD BE CONCEALED WHERE POSSIBLE
- F- VERIFY LOCAL CODES BEFORE CONNECTING DISPOSER TO GREASE TRAP
- G- PLUMBING CONTRACTOR TO LOCATE AND HANG ALL WALL MOUNT FIXTURES
- H- PLUMBING CONTRACTOR TO INSULATE AND INSTALL INDIRECT DRAIN LINES
- I- PLUMBING CONTRACTOR TO VERIFY UTILITY REQUIREMENTS FOR ALL EQUIPMENT MARKED AS "EXISTING" OR "BY OTHERS"
- J- FLOOR DRAINS REFLECTED ON THIS PLAN ARE SHOWN FOR EQUIPMENT USE ONLY. VERIFY AREA DRAINS ON MECHANICAL PLANS. PROVIDE AIR GAP PER CODE
- K- EXPOSED HORIZONTAL DRAINLINES MUST HAVE PROPER CLEARANCE BELOW FOR CLEANING
- L- PLUMBING CONTRACTOR TO REGULATE GAS PRESSURE FOR EQUIPMENT(7-10"W.C. TYPICAL)

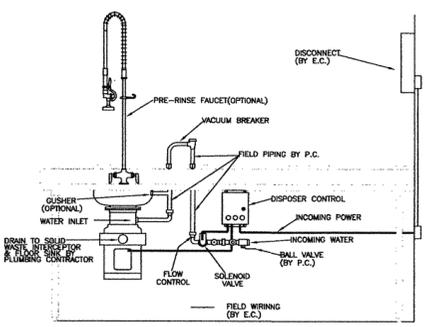

TYPICAL DISPOSER DETAIL
SCALE=NONE

LEGEND

- - COLD WATER
- - HOT WATER
- - WALL DRAIN
- - GAS CONNECTION
- - FLOOR DRAIN
- - FLOOR SINK W/ STRAINER
- AFF - ABOVE FINISHED FLOOR
- P.C. - PLUMBING CONTRACTOR
- KEC - KITCHEN EQUIPMENT CONTRACTOR
- F.S. - FLOOR SINK DRAIN
- AD - AREA FLOOR DRAIN

SCALE: 1/4" = 1'


SHEET TITLE:
*KITCHEN EQUIPMENT
PLUMBING PLAN*

HEIFER INTERNATIONAL
PHASE 2 BUILDING
LITTLE ROCK, AR

SHEET NO.
K3
SHEET 3 OF 5
PROJECT NO.
HEIF01
DATE
03/13/08
REVISION
02/02/09

DRAWN BY: MT




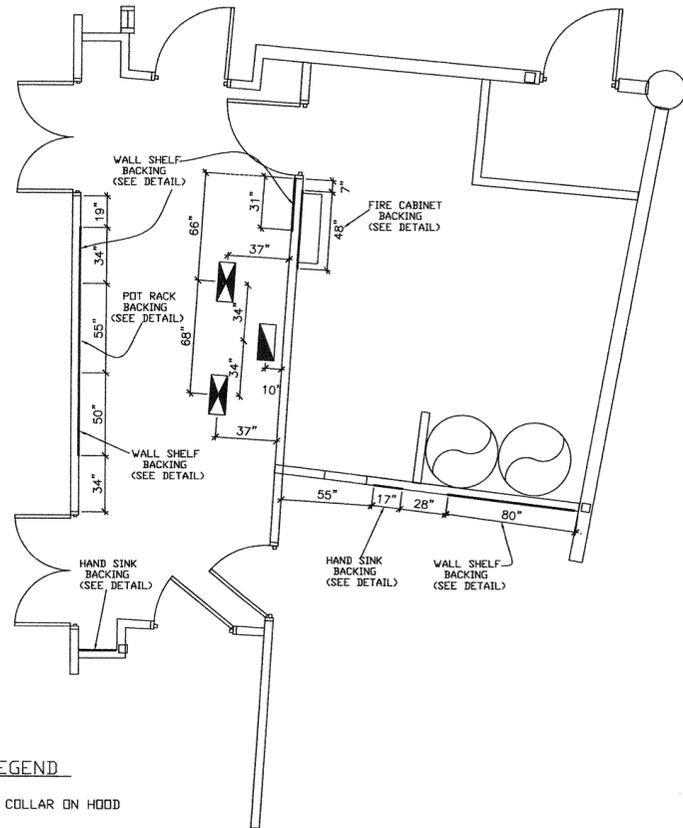


LEGEND

-  - MAU COLLAR ON HOOD
-  - EXHAUST COLLAR ON HOOD

* SEE PAGE K5 FOR COLLAR SIZES AND HOOD DETAILS

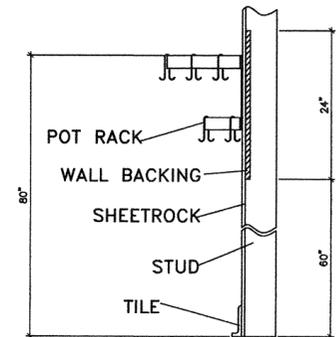


POT RACK BACKING DETAIL

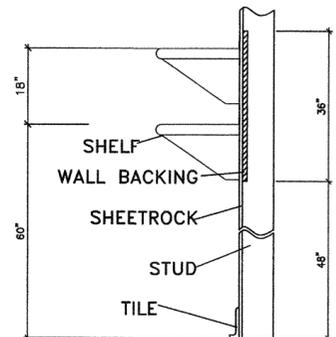


WALL SHELF BACKING DETAIL

GENERAL NOTES


- A- GENERAL CONTRACTOR TO PROVIDE AND INSTALL WALL BACKING AS DETAILED ON THIS PAGE. INSTALL IN SUCH A MANNER AS TO PROVIDE ADEQUATE SUPPORT FOR WALL MOUNTED ITEMS.
- C- VENT HOOD, FANS AND CURBS TO BE SUPPLIED BY KITCHEN CONTRACTOR. HANGING OF HOOD BY KITCHEN EQUIPMENT CONTRACTOR. DUCTWORK TO BE PROVIDED AND INSTALLED BY MECHANICAL.
- D- FANS & CURBS TO BE LOCATED AND INSTALLED BY MECHANICAL AND/OR GENERAL CONTRACTOR
- E- GENERAL CONTRACTOR TO PROVIDE ALL WALL BACKING NECESSARY FOR WALL MOUNTED ITEMS AND ALL WALL/ROOF/FLOOR PENETRATIONS REQUIRED. SEE DETAILS ON THIS PAGE.
- F- COORDINATE WITH OTHER TRADES WHEN LOCATING PERMANENT FIXTURES.
- G- DO NOT LOCATE HVAC DIFFUSERS NEAR VENT HOOD. IF NECESSARY, USE PERFORATED TYPE.

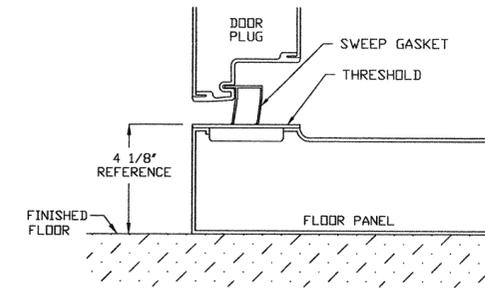

WALK-IN COOLER FLOOR DETAIL

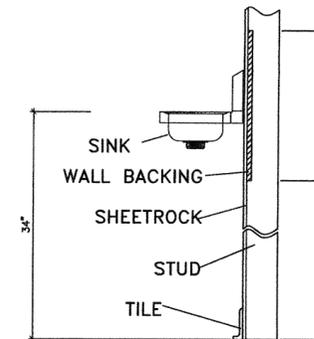

HAND SINK BACKING DETAIL

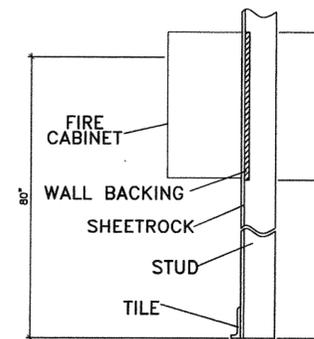

FIRE CABINET BACKING DETAIL

SCALE: 1/4" = 1'

SHEET TITLE:

*KITCHEN EQUIPMENT
SPECIAL CONDITION PLAN*

HEIFER INTERNATIONAL
PHASE 2 BUILDING
LITTLE ROCK, AR

SHEET NO.

K4

SHEET 4 OF 5

PROJECT NO.

HEIF01

DATE

03/13/08

REVISION

02/02/09

DRAWN BY: MT






HOOD INFORMATION																
HOOD NO.	MODEL	LENGTH	MAX. COOKING TEMP.	EXHAUST FAN(S)				SUPPLY FAN(S)				HOOD CONSTRUCTION	END TO ROW	SWITCHES ON HOOD		
1	2847 BD	11' 6.00"OD	300	EXH. CFM	WIDTH	LENS DIA.	S.P.	SUP. CFM	WIDTH	LENS DIA.	S.P.	430 SS Where Exposed	ALDNE	N/A	1 Light	1 Fan
2	166 MISC-PSP	11' 6.00"OD	300	0				1840				430 SS Where Exposed	ALDNE	N/A		

HOOD INFORMATION													
HOOD NO.	TYPE	QTY	HEIGHT	LENGTH	WIDTH	TYPE	LOCATION	TYPE	SIZE	ELECTRICAL MODEL #	SWITCHES LOCATION	FIRE SYSTEM	HOOD HEIGHT
1	Stainless Steel High E	1	16"	16'	4'	Incandescent Light Fix	NO	REMOTE	ANSUL RISE	30/15	2111002	YES	90 LBS.
2		6	16"	25'	4'							NO	91 LBS.

PERFORATED SUPPLY PLENUM(S)											
HOOD NO.	POS.	LENGTH	WIDTH	HEIGHT	WIDTH	LENS DIA.	CFM	S.P.			
1	Front	138"	16"	6"	10"	24"	920	0.132"			
2					10"	24"	920	0.132"			

HOOD OPTIONS												
HOOD NO.	OPTION											
1	BACKSLASH	43.00"	High	X 138.00"	Long	430	SS					
2	FIELD WRAPPER	6.00"	High	Front, Left, Right								
3	BACK STANDOFF	3"	Wide									

FAN INFORMATION																					
FAN UNIT NO.	FAN UNIT MODEL #	MODEL	TAG	CFM	S.P.	RPM	HP.	#	VOLT	FLA	BLDWR	HOUSING	TAG	CFM	S.P.	RPM	HP.	#	VOLT	FLA	
1	NCAIBPFA	NCAIBPFA		2300	1.500"	1120	1.500	1	230	10.2											
2	INLINE-GLD										GLD	INLINE-GL		1840	0.500"	990	0.750	1	230	5.4	

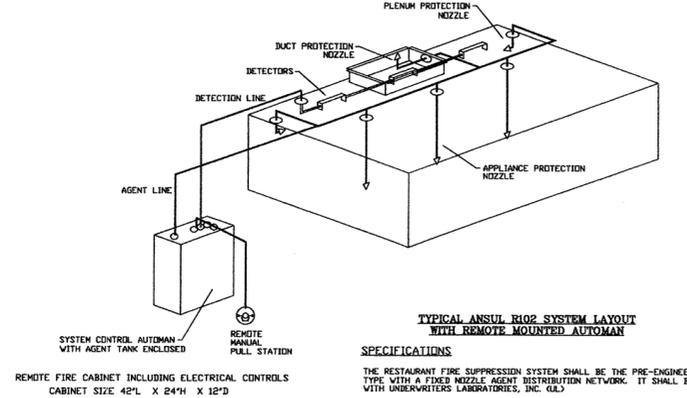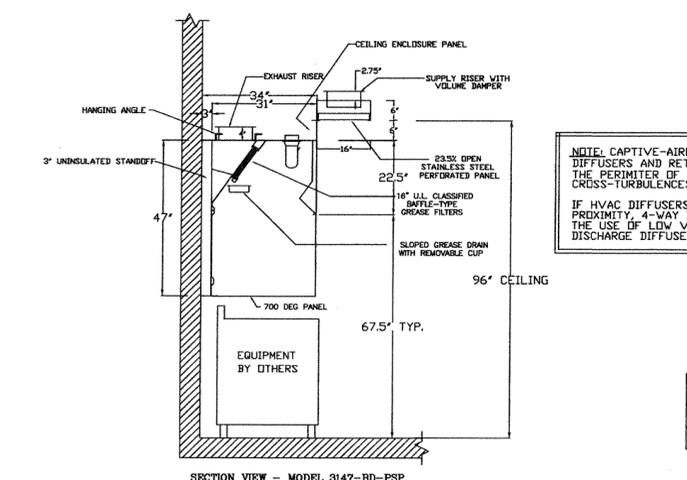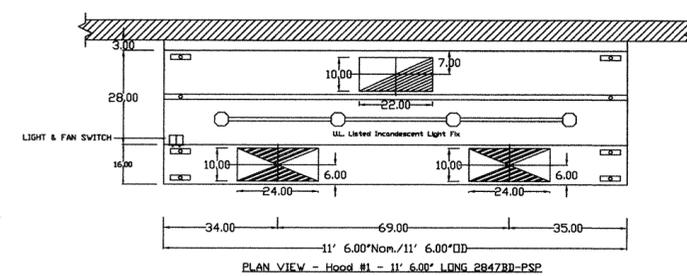



SPECIFICATIONS

THE RESTAURANT FIRE SUPPRESSION SYSTEM SHALL BE THE PRE-ENGINEERED TYPE WITH A FIXED NOZZLE AGENT DISTRIBUTION NETWORK. IT SHALL BE LISTED WITH UNDERWATERS LABORATORIES, INC. (UL).

THE SYSTEM SHALL BE CAPABLE OF AUTOMATIC DETECTION AND ACTUATION WITH LOCAL OR REMOTE MANUAL ACTUATION. ACCESSORIES SHALL BE AVAILABLE FOR MECHANICAL OR ELECTRICAL GAS LINE SHUT-OFF APPLICATIONS.

THE EXTINGUISHING AGENT SHALL BE A POTASSIUM CARBONATE, POTASSIUM ACETATE-BASED FORMULATION DESIGNED FOR FLAME KNOCKDOWN AND SUPPRESSION OF GREASE RELATED FIRES. IT SHALL BE AVAILABLE IN PLASTIC CONTAINERS WITH INSTRUCTIONS FOR LIQUID AGENT HANDLING AND USAGE.

THE REGULATED RELEASE MECHANISM SHALL BE COMPATIBLE WITH A FUSIBLE LINK DETECTION SYSTEM. THE FUSIBLE LINK SHALL BE SELECTED AND INSTALLED ACCORDING TO THE OPERATING TEMPERATURE IN THE VENTILATING SYSTEM. THE FUSIBLE LINK SHALL BE SUPPORTED BY A DETECTOR BRACKET/LINKAGE ASSEMBLY.

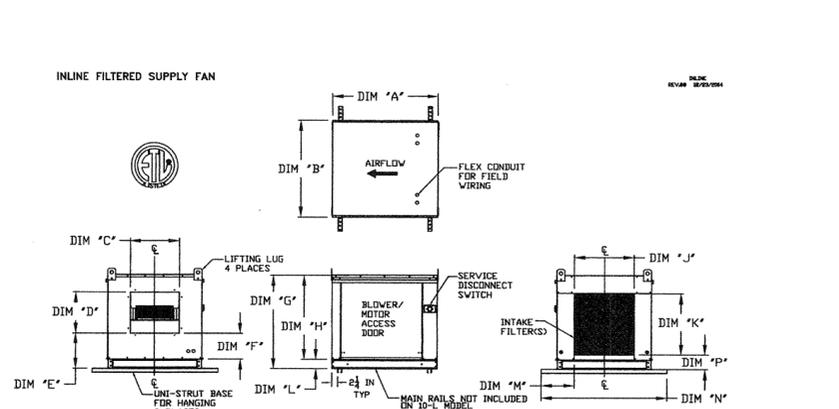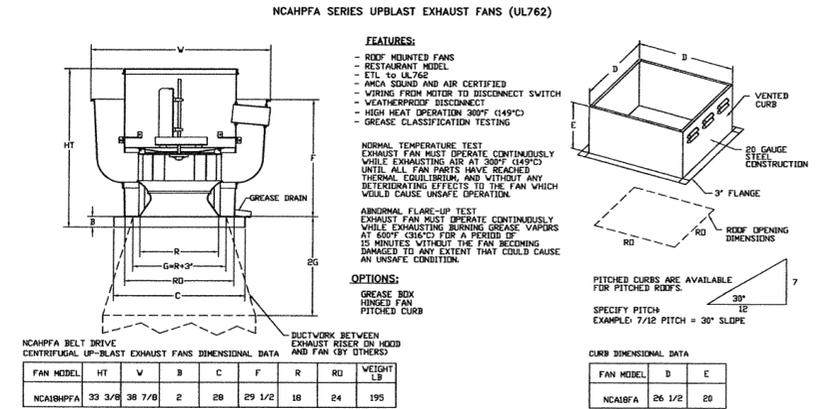

BLDWR	FILTER SIZE	BLDWR SIZE	WEIGHT (lbs)	A	B	C	D	E	F	G	H	J	K	L	M	N	P
18"	18"	18" x 20"	185	38 1/8	27 3/8	13 1/4	11 1/2	N/A	8 1/8	N/A	22 1/16	16	18	N/A	5 1/16	36	2 1/8
18"	18"	18" x 20"	200	38 1/8	27 3/8	13 1/4	11 1/2	11 3/16	8 1/8	N/A	22 1/16	16	18	3 3/4	5 1/16	48	3 1/4
18"	18"	18" x 25"	290	40 1/8	27 3/8	15 3/4	13 9/16	1 1/16	3 3/8	38 3/4	33 1/16	22 3/4	24	3 3/4	5 1/16	48	3 3/4
18"	18"	18" x 25"	320	40 1/8	27 3/8	15 3/4	13 9/16	1 1/16	3 3/8	38 3/4	33 1/16	22 3/4	24	3 3/4	5 1/16	48	3 3/4
18"	18"	18" x 25"	470	42 1/8	21 1/2	3 1/8	22	19	17 1/8	12 5/8	43 3/8	38 1/16	30	18 1/4	5 1/16	60	7 1/2

BD Series with PSP Accessory Specification

The BD series hood with PSP accessory is a low profile, compact hood system. Hood shall have size, shape and performance specified on drawings.

Construction shall be type 430 stainless steel with a #3 or #4 polish where exposed. Individual component construction shall be determined by manufacturer, ETL, and NSF. Construction shall be dependent on the structural application to minimize distortion and other defects. All seams, joints and penetrations of the hood enclosure shall have a liquid-tight continuous external weld in accordance with NFPA 96. Hood shall be well type with a minimum of four connections for hanger rods. Connectors shall have 9/16" holes pre-punched in single iron at the factory to allow for hanger rod connection by others.

Ventilator shall be furnished with UL classified stainless steel high efficiency baffle filters, supplied in size and quantity as required by ventilator. The filters shall extend the full length of the hood and the filter panels shall not be more than 6" in width.

The hood manufacturer shall supply complete computer generated submittal drawings including hood section view(s) and hood plan view(s). These drawings must be available to the engineer, architect and owner for their use in construction, operation and maintenance.

Exhaust duct collar to be 4" high with 1" flange. Duct sizes, CFM and static pressure requirements shall be as shown on drawings. Static pressure requirements shall be precise and accurate; air velocity and volume information shall be accurate within 1-ft increments along the length of the ventilator.

UL incandescent light fixtures and globes shall be installed and pre-wired to a junction box. The light fixtures shall be installed with a minimum of 4" spacing on center and allow up to a 100 watt standard light bulb.

The hood shall have:
 - A double wall insulated front to eliminate condensation and increase rigidity. The insulation shall be 1" thick, have a flexural modulus of 475 EI, meet UL 181 requirements and be in accordance with NFPA 96A and 96B.
 - An integral baffle to direct grease laden vapors toward the exhaust filter bank.
 - A built-in wing chase shall be provided for outlets and electrical controls on hood face and shall not penetrate capture the area or require an external chase.
 - Low velocity make-up air (up to 900 provided through front and side plenums (PSP accessory)).
 - A sloped grease drain system which shall be an enclosed integral part of the hood back with an exposed, removable x pint grease cup to facilitate cleaning.


The hood shall be ETL Listed as "Exhaust Hood Without Exhaust Damper", NSF Listed and built in accordance with NFPA 96. The hood shall be listed for 450° F cooking surfaces at 150 CFM/ft. and for 700° F cooking surfaces at 200 CFM/ft.

ELECTRICAL PACKAGES											
NO.	TAG	PACKAGE #	LOCATION	SWITCHES	ROOF TOP STARTERS	OPTION	FANS CONTROLLED				
				LOCATION	QUANTITY		TYPE	#	HP.	VOLT	FLA
1		2111002	Wall Mount in SS Box	SS Wall Mount Box	1 Light	Exhaust in Fire	Exhaust	1	1.500	230	10.2
							Supply	1	0.750	230	5.4

HOOD SHALL HAVE A PRE-WIRED ELECTRICAL CONTROL PACKAGE LOCATED IN THE UTILITY CABINET TO OPERATE THE FAN PACKAGE. WIRING OPTION SHALL INCLUDE A STAINLESS STEEL SWITCH PANEL CONSISTING OF ONE LIGHT SWITCH AND ONE RED-LIGHTED FAN SWITCH FOR EACH SET OF INTERLOCKED FANS, A HINGED COVERED JUNCTION BOX WITH RELAY FOR SUPPLY SHUTDOWN, A NUMBERED INPUT/OUTPUT TERMINAL STRIP, AND A WIRING DIAGRAM. ADDITIONALLY, THE MICROSWITCH FOR ANSUL SHUTDOWN SHALL BE PRE-WIRED TO J-BOX.

A STARTER/OVERLOAD ASSEMBLY FOR EACH FAN WILL BE LOCATED IN THE UTILITY CABINET. ONE ELECTRICAL CONDUIT DROP FROM THE FAN PACKAGE SHALL BE CONNECTED TO THE NUMBERED TERMINAL STRIP. CONDUIT BETWEEN HOOD AND FAN PACKAGE SHALL BE SUPPLIED BY THE ELECTRICAL CONTRACTOR.

NOTE: IF WALL MOUNT PREWIRE, OR FIELD INSTALLED FIRE SYSTEM MICROSWITCH TERMINALS SHOWING FACTORY WIRING MUST BE FIELD WIRED

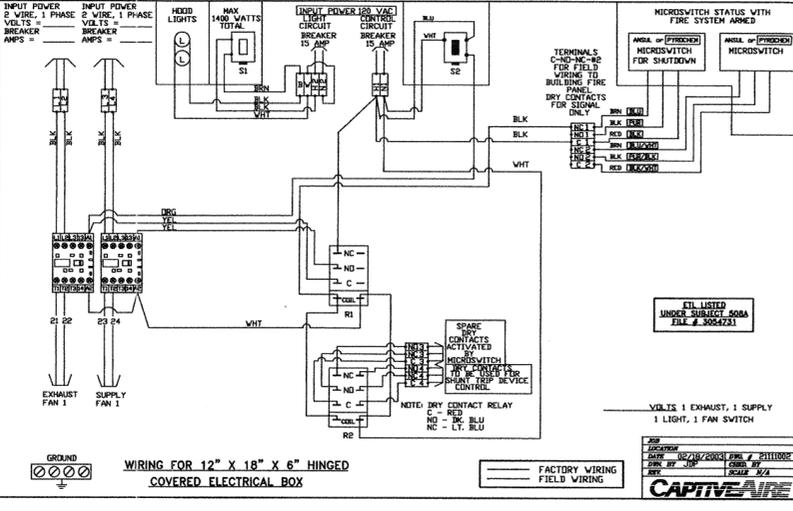

SCALE: NDNE

SHEET TITLE:
**KITCHEN EQUIPMENT
 SPECIAL CONDITION PLAN**

HEIFER INTERNATIONAL
PHASE 2 BUILDING
LITTLE ROCK, AR

SHEET NO. K5
SHEET 5 OF 5
PROJECT NO. HEIF01
DATE 03/13/08
REVISION 02/02/09

DRAWN BY: MT

CONSULTANTS:

CIVIL ENGINEER:
MCLELLAND ENGINEERS

LANDSCAPE ARCHITECT:
LARSON BURNS SMITH

STRUCTURAL ENGINEER:
CROMWELL ENGINEERS INC.

MECH., ELEC., PLUMB. ENGINEER:
CROMWELL ENGINEERS INC.

GLOBAL VILLAGE CONSULTANT
CAMBRIDGE SEVEN ASSOCIATES

INTERIOR DESIGNER:
POLK STANLEY ROWLAND
CURZON PORTER ARCHITECTS

GENERAL CONTRACTOR:
CDI CONTRACTORS, INC.

NOTES:

ISSUE DATE:

17 SEPTEMBER 2007

REVISIONS:

#	DATE	DESCRIPTION

MURPHY - KELLER
EDUCATIONAL CENTER

HEIFER
INTERNATIONAL
CENTER

LITTLE ROCK, ARKANSAS

PSRCP JOB NUMBER:


431E

CONTENTS:

MECHANICAL CONTROLS

SHEET NUMBER:

M301

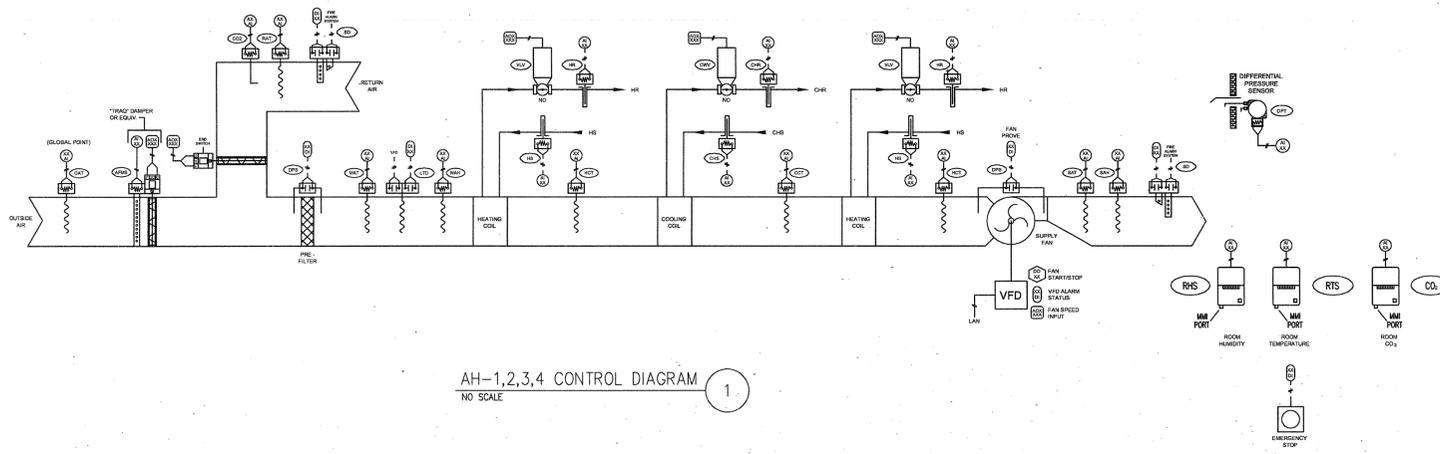

CONTROL LEGEND			
SYMBOL	DESCRIPTION	SYMBOL	DESCRIPTION
(AI)	ANALOG INPUT POINT	VFD	VARIABLE FREQUENCY DRIVE
(AO)	ANALOG OUTPUT POINT	AFMS	AIR FLOW MONITOR
(DI)	DIGITAL INPUT POINT	CC	CHILLED WATER COIL
(DO)	DIGITAL OUTPUT POINT	HC	HOT WATER COIL
(DPS)	DIFFERENTIAL PRESSURE SENSOR	HSU	HIGH STATIC LIMIT
(SP)	STATIC PRESSURE SENSOR	T	ROOM TEMPERATURE SENSOR
(SD)	SMOKE DETECTOR	H	HUMIDITY SENSOR
(DA)	DAMPER ACTUATOR	CO2	CO2 SENSOR
FBD	FACE & BYPASS DAMPER	NO	NORMALLY OPEN
SAT	SUPPLY AIR TEMPERATURE SENSOR	NC	NORMALLY CLOSED
(PH)	PREHEAT TEMPERATURE	C	COMMON
CCT	COOLING COIL TEMPERATURE	S	SUPPLY
MAT	MIXED AIR TEMPERATURE	R	RETURN
LTD	LOW TEMPERATURE DETECTOR	DM	DAMPER MOTOR
HWV	HOT WATER VALVE	SDM	SMOKE DAMPER MOTOR
CWV	CHILLED WATER VALVE	CWV	CHILLED WATER VALVE
DTS	DISCHARGE AIR TEMPERATURE	(CHR)	CHILLED WATER RETURN
OSAT	OUTSIDE AIR TEMPERATURE SENSOR	(CHS)	CHILLED WATER SUPPLY
MAH	MIXED AIR HUMIDITY	(HR)	HOT WATER RETURN
SAH	SUPPLY AIR HUMIDITY SENSOR	(HS)	HOT WATER SUPPLY
RAT	RETURN AIR TEMPERATURE SENSOR		

SEQUENCE OF OPERATIONS: AH-1,2,3,4


- System Off**
Under unoccupied conditions, system will be off. When system is off, the air handling unit supply fan is off. The outside air damper is closed, and the return damper is closed. The normally closed two-way control valve to the cooling and heating coils will be in the closed position.
- System Start**
When the system is called to start (system is to be operated according to an occupancy schedule), the return air damper shall open. When the return air damper has proven 100% open by its end switch, the supply fan shall start. The outside air damper shall be set to intake minimum outside air required. The return damper shall be coordinated to deliver the balance of the supply air that is being discharged.
When the system comes on line, air handling unit and return fan shall be placed under the control of the BAS.
- System Run**
A temperature sensor located in the supply fan discharge will modulate the two-way chilled water control valve and heating coil control valve as required to maintain discharge dry-bulb temperature and set point immediately downstream of the coil (initially set at 53°F cooling, 85°F heating- adjustable).
Normal Operation
Cooling
Under normal operation, the air handler shall run delivering a variable volume of air between 25% and 100% (adjustable) of scheduled cooling airflow. Outside air damper shall modulate to maintain minimum outside air requirements (based on CO2 readings), and maintain space pressurization.
Cooling/Dehumidifying
When air handler airflow has reached 25% of scheduled airflow, the cooling coil shall modulate to maintain space temperature. If space humidity rises above setpoint, the cooling coil discharge temperature shall be set at 53°F (adjustable), and the reheat hot water valve shall modulate to maintain space temperature. Outside air damper shall modulate to maintain minimum outside air requirements (based on CO2 readings), and maintain space pressurization.
Preheating
The preheat hot water valve shall modulate to maintain 53° downstream of the preheat coil.
Reheating
Air handler shall deliver 25% of the scheduled airflow (adjustable). The reheat hot water valve shall modulate to maintain space temperature. Outside air damper shall modulate to maintain minimum outside air requirements (based on CO2 readings), and maintain space pressurization.
- System Stop**
When the air-handling unit stops, the supply and return fan for the air handling unit stops and the normally closed dampers shall close. The cooling coil control valve shall close.
- Safeties**
A freeze-stat mounted in the heating coil discharge will stop the air handling unit whenever the air temperature at the freeze-stat element falls below its set point of 40°F through a hard wired interlock. A critical alarm will sound at the BAS.
A smoke duct detector mounted in the return and the discharge ductwork of the air handling unit will stop the entire system whenever any of the smoke duct detectors senses particles of combustion. A critical alarm will sound at the BAS.
- Emergency Stop Button**
A red, industrial oil-tight, mushroom head (2" diameter) push button shall be provided. It shall be mounted in a prominent, readily accessible location. It shall be the maintained contact type.
When pressed, the emergency stop shall immediately stop all fans and suspend operation of all valves. Spring operated valves shall be spring driven to the design condition.
Provide status of emergency stop to BAS. Critical alarm on activation.
Manual reset shall be required to restore operation.

INPUT/OUTPUT SUMMARY: AH-1,2,3,4

Analog Inputs	Analog Outputs
- Space Temperature	- Chilled Water Coil Control Valve
- Space Relative Humidity	- Hot Water Coil Control Valve
- Space CO2 Level	- Outside Air Damper ("Track")
- Space Differential Pressure	- Return Air Damper
- Outside Air Temperature (global point)	- AH Supply Fan Speed (VFD)
- AH Discharge Temperature	
- AH Discharge Humidity	
- AH Return Air Temperature	
- AH Mixed Air Temperature	
- AH Mixed Air Humidity	
- Cooling Coil Discharge Air Temperature	
- Heating Coil Discharge Air Temperature	
- Chilled Water Entering Temperature	
- Chilled Water Leaving Temperature	
- Hot Water Entering Temperature	
- Hot Water Leaving Temperature	
- Outside Airflow ("Track")	

Digital Inputs	Digital Outputs
- Smoke Detector (2)	- Unit Supply Fan Start/Stop (VFD)
- Filter Pressure Drop (2)	
- Freeze-stat	
- VFD Alarm Status	
- Fan Prove (pressure)	
- Emergency Stop Status	

Note: Dewpoint shall be calculated and displayed for all humidity sensing points outside the building, inside the building, in the air handlers and in the ductwork units.

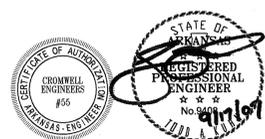

SEQUENCE OF OPERATIONS: CHILLED/CONDENSER WATER SYSTEM

CHILLED WATER PUMPS - CHP 1 & 2
 WHEN THERE IS A CALL FOR THE CHILLER PLANT, CHP1 OR 2 SHALL BE STARTED DEPENDING UPON WHICH CHILLED WATER PUMP IS PLACED FOR OPERATION. THE PUMP SELECTION SHALL BE DONE AUTOMATICALLY BASED UPON RUNTIME HOURS TO EQUALIZE EQUIPMENT WEAR. THE DUTY PUMP SHALL BE SWITCHED AUTOMATICALLY AFTER 300 HOURS (ADJ) OR BASED UPON AN OPERATOR ASSIGNED SCHEDULE. PUMP ENABLE AND SPEED SHALL BE CONTROLLED BY THE EXISTING CONTROL METHODOLOGY OF THE EXISTING CONTROL SYSTEM. AN ADDITIONAL DIFFERENTIAL PRESSURE SENSOR SHALL BE INSTALLED 2/3 DOWNSTREAM TO THE MURPHY KELLER FACILITY AND SHALL BE USED IN CONJUNCTION TO THE SENSOR IN THE MAIN BUILDING TO DETERMINE PUMP SPEEDS. THE PUMP SPEED SHALL BE MODULATED TO MAINTAIN THE LOWEST PRESSURE READING AT THE MINIMUM DIFFERENTIAL PRESSURE SETPOINT (AS DETERMINED BY THE BALANCE CONTRACTOR).

THE MANUAL OVERRIDE IN THE SYSTEM GRAPHIC TO RUN THE CHILLED WATER SYSTEM SHALL REMAIN UNCHANGED. THIS WILL ALLOW FOR START OF ALL EQUIPMENT REGARDLESS OF THE BUILDINGS 'NEED' FOR CHILLED WATER. ALL RESPECTIVE EQUIPMENT SHALL START IN SEQUENCE IN THE SAME MANNER AS UNDER AUTOMATIC CONTROL.

CHILLED WATER PLANT INITIATION ALSO REQUIRES THE ISOLATION VALVES TO BE OPENED OR CLOSED AS REQUIRED FOR OPERATION OF THE RESPECTIVE PIECES OF EQUIPMENT.

EACH CHILLER'S EVAPORATOR DIFFERENTIAL PRESSURE SHALL BE MONITORED BY THE NEW ROSEMOUNT DIFFERENTIAL PRESSURE TRANSMITTERS. THE FORMULA $(GPM^2/GPM1)^2 = \Delta P2/\Delta P1$ SHALL BE USED TO CALCULATE THE ACTUAL FLOW IN GPM THROUGH THE CHILLER, WHERE

GPM1= ACTUAL FLOW
 GPM2= DESIGN MAXIMUM FLOW
 $\Delta P1$ = ACTUAL DIFFERENTIAL PRESSURE
 $\Delta P2$ = DESIGN DIFFERENTIAL PRESSURE AT DESIGN MAXIMUM FLOW.

EACH CHILLER'S DESIGN SPECIFICATIONS TO SOLVE THE ABOVE FORMULA FOR THE ACTUAL FLOW ARE AS FOLLOWS:

CH-1 MAXIMUM DESIGN FLOW =300 GPM
 CH-1 DIFFERENTIAL PRESSURE AT MAXIMUM DESIGN FLOW = 16.3FT=7.065PSI

CH-2 MAXIMUM DESIGN FLOW =200 GPM
 CH-2 DIFFERENTIAL PRESSURE AT MAXIMUM DESIGN FLOW = 16FT=6.938PSI

THE CONTROL SYSTEM SHALL MODULATE EACH CHILLER'S RESPECTIVE BYPASS VALVES AS REQUIRED TO MAINTAIN THEIR MINIMUM FLOW SETPOINTS OF 225 GPM FOR CH-1 AND 85 GPM FOR CH-2. (CH-1 IS ASSOCIATED WITH THE NEW 2.5" BUTTERFLY VALVE AND CH-2 IS ASSOCIATED WITH THE NEW 1.5" GLOBE VALVE.)

CONDENSER WATER PUMP

CWP-1 SHALL BE DEDICATED FOR CHILLER 1&2 AND CWP-2 SHALL BE DEDICATED FOR HX-1
 WHEN THERE IS A CALL FOR THE CHILLER PLANT, CWP1 AND OR CWP2 SHALL BE STARTED DEPENDING ON WHICH UNIT IS CALLED FOR OPERATION. PUMP ENABLE SHALL BE CONTROLLED BY THE EXISTING CONTROL METHODOLOGY OF THE EXISTING CONTROL SYSTEM. THE PUMP SPEED SHALL BE SET AT A FIXED SPEED SETPOINT TO MAINTAIN THE MINIMUM FLOW REQUIRED THROUGH EACH OPERATING PIECE OF EQUIPMENT (TOTAL FLOW CAN BE CONFIRMED AS SENSED AT THE EXISTING TOTAL TOWER SUPPLY FLOW METER).

THE BALANCE CONTRACTOR SHALL PROVIDE THE CONTROLS CONTRACTOR THE REQUIRED PUMP SPEED TO SATISFY THE FLOW REQUIREMENTS UNDER THE FOLLOWING CONDITIONS:

HX-1 =500GPM =? VFD%
 OMITTED

CH2=240GPM=? VFD%

CH1=1000GPM=? VFD%

CH1/CH2=1240GPM= 100 VFD% (BOTH CHILLERS COMBINED REQUIRED A TOTAL OF 1240 GPM CONDENSER WATER FLOW WHICH EXCEEDS THE DESIGN POTENTIAL FLOW OF EITHER CONDENSER PUMP BY 240 GPM. THE OPERATING PUMP THEREFORE SHALL RUN AT FULL SPEED WHEN THE CHILLERS ARE RUNNING TOGETHER).

THERE WILL NOT BE A TIME WHEN CH-1 AND HX-1 ARE IN OPERATION TOGETHER. THERE MAY BE A TIME WHEN CH-1 & 2 ARE OPERATED TOGETHER AND THE FLOW RATE IF NOT SUFFICIENT SHALL BE PROPORTED TO THE GPM AVAILABLE ON A PERCENTAGE BASIS (ALL BY BALANCE CONTRACTOR).

CHILLERS CH-1 & 2 AND HEAT EXCHANGER HX-1

WHEN THE CHILLER PLANT IS CALLED FOR BY THE OCCUPIED PROGRAM THE CONDENSER WATER PUMP, CHILLED WATER PUMP, COOLING TOWER FANS AND THE APPROPRIATE CHILLER OR HEAT EXCHANGER SHALL START IN THE SEQUENCE PREVIOUSLY DESIGNED. A NEW GRAPHIC SHALL BE DESIGNED FOR THE NEW CHILLER CH-2 LISTING ITS OPERATING SETPOINTS AND LOCKOUT TEMPERATURES. A NEW ADVANCED SET UP GRAPHIC WILL BE DESIGNED FOR THE PARAMETERS OF THE NEW CHILLER.

WHEN THE CHILLER PLANT IS STARTING, THE APPROPRIATE CHILLED WATER EQUIPMENT SHALL BE SELECTED AS FOLLOWS FOR SYSTEM STARTUP.

- WHEN THE OUTSIDE AIR (OSA) WET BULB (WB) IS BELOW THE LOCKOUT TEMPERATURE OF THE HEAT EXCHANGER (50°F WB ADJ) THE SYSTEM SHALL STARTUP WITH ONLY HX-1 IN OPERATION. NOTE(ADD A LOCKOUT TEMP FOR HX-1)
- WHEN THE OSA WB IS ABOVE THE LOCKOUT TEMPERATURE FOR CH-2 (50°F WB ADJ) THE SYSTEM SHALL STARTUP CH-2 AND HX-1 SHALL CONTINUE TO OPERATE
- WHEN THE OSA WB IS ABOVE THE CH-2 LOCKOUT TEMPERATURE 62°F (ADJ), THE SYSTEM SHALL STARTUP WITH ONLY CH-2 IN OPERATION

WHEN THE CHILLER PLANT IS RUNNING, THE APPROPRIATE CHILLED WATER EQUIPMENT SHALL BE SELECTED AS FOLLOWS FOR CHILLER LOADING/UNLOADING.

- WHEN HX-1 IS RUNNING ALONE AND THE OSA WB RISES ABOVE THE LOCKOUT SETPOINT OF 50°F, CH-2 SHALL BE STARTED AND HX-1 SHALL CONTINUE TO RUN
- HX-1 SHALL CONTINUE TO RUN UNTIL THE PERFORMANCE OF THE HEAT EXCHANGER FALLS TO A POINT WHERE THE LEAVING CHILLED WATER TEMPERATURE IS LESS THAN 2°F FROM THE ENTERING CHILLED WATER TEMPERATURE. AT THIS POINT HX-1 SHALL BE STOPPED AND CH-2 SHALL CONTINUE TO RUN. IF THE OSA WB DROPS 2°F BELOW THE RECORDED OSA WB WHEN THE HX-1 WAS STOPPED, THEN IT WILL BE ALLOWED TO RESTART AND OPERATE WITH CH-2. IF CH-2 HAS FAILED AS DETERMINED BY THE ALARM FAILURE CONTACTS ON CH-2, THEN STOP CH-2 AND START CH-1.
- WHEN CH-2 HAS BEEN OPERATING ALONE FOR A MINIMUM OF 30 MINUTES (ADJ), CH-2 SHALL BE STOPPED AND CH-1 STARTED IF THE LEAVING WATER TEMPERATURE IS 5°F (ADJ) ABOVE THE CHILLED WATER SET POINT AND THE WB TEMPERATURE IS ABOVE THE LOCKOUT TEMPERATURE OF CH-1 (OVERLOADED CONDITION)
- WHEN CH-1 IS OPERATING AND THE LOAD AS SEEN ON THE CHILLER KW DEMAND METER DROPS TO 60 KW (ADJ), THEN TURN OFF CH-1 AND TURN ON CH-2
- WHEN CH-2 IS RUNNING AND THE OSA WB DROPS BELOW HX-1'S OSA WB LOCKOUT SETPOINT, STOP CH-2 AND START HX-1.



THE CHILLED WATER SETPOINT SHALL CONTROL FROM 42°F TO 50°F DEPENDING UPON THE REQUIREMENT OF THE VENTILATION UNITS. IF THE VENTILATION UNITS ARE OFF, THE CHILLED WATER SETPOINT WILL BE 50°F (ADJ). THIS WILL REMAIN THE SAME AS CURRENTLY DESIGNED. THE CHILLED WATER SETPOINT SHALL BE RESET COLDER WHEN ANY SPACE HUMIDITY SENSOR IN EITHER BUILDING EXCEEDS THE MAXIMUM HUMIDITY LEVEL OF 55% (ADJ). THE TEMPERATURE SHALL BE RESET COLDER BY 2°F EVERY 60 MIN (ADJ). WHEN ALL SPACE HUMIDITY SENSORS ARE 5% (ADJ) BELOW THE MAXIMUM HUMIDITY SETPOINT, THE CHILLED WATER SETPOINT SHALL BE ADJUSTED WARMER BY 2°F EVERY 60 MIN (ADJ) UNTIL THE SETPOINT HAS REACHED THE 'DESIRED NORMAL SETPOINT' AS DETERMINED AND DESCRIBED PREVIOUSLY.

COOLING TOWERS

CH-2 AND HX-1 WILL USE ONLY ONE COOLING TOWER CELL. CH-1 WILL USE BOTH CELLS.

USE THE SAME CONTROL STRATEGY FOR THE HEAT EXCHANGER THAT IS CURRENTLY BEING USED.

THE COOLING TOWER FANS WHEN OPERATING WITHOUT THE HEAT EXCHANGER WILL CONTROL THE FAN SPEED TO ACHIEVE A LEAVING CONDENSER WATER 5 DEGREES WARMER THAN THE CURRENT WET BULB READING.

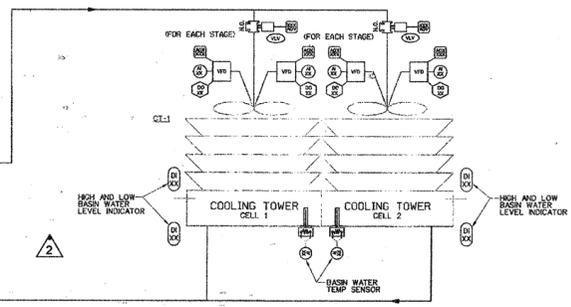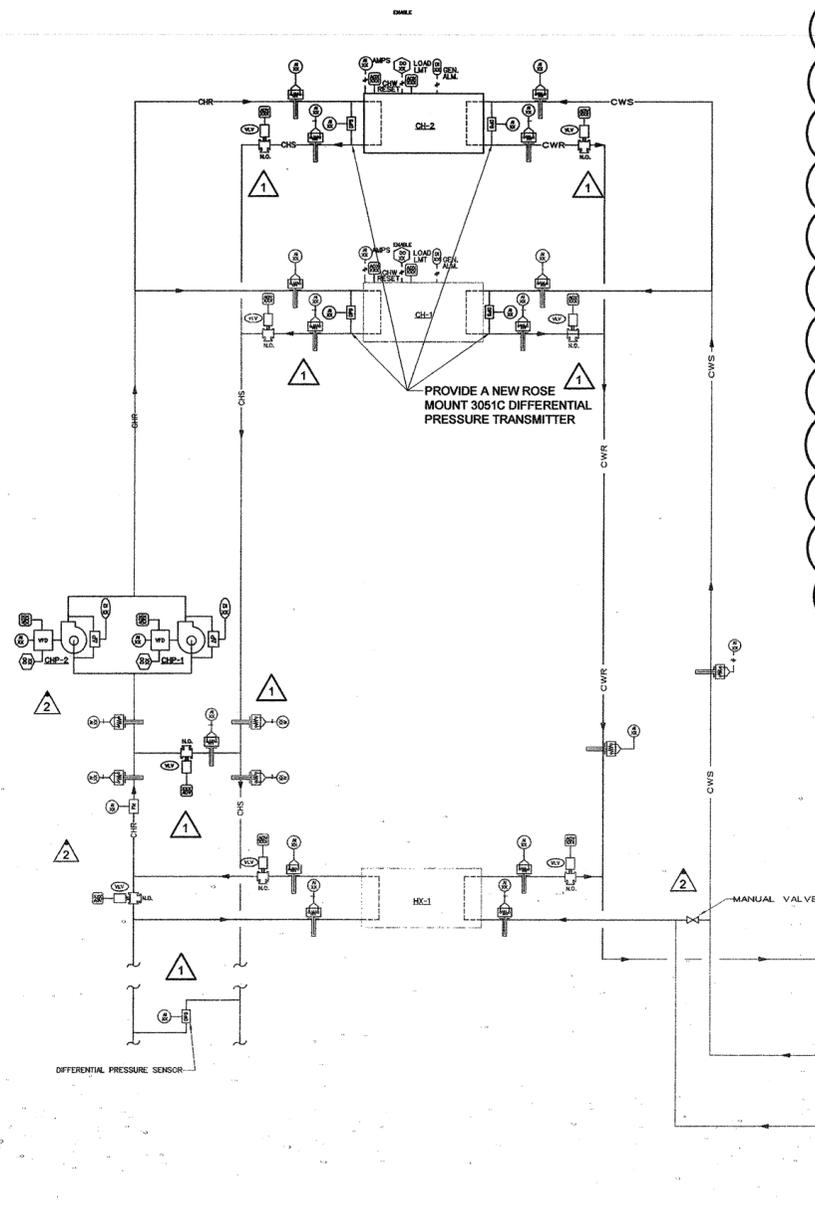

INPUT/OUTPUT SUMMARY: CHILLED/CONDENSER WATER SYSTEM

ANALOG INPUTS (AI)

- Water System Flow
- Water System Supply Temperature
- Water System Return Temperature
- Water System Load - tons
- Individual Remote Differential Pressure Signals
- Chilled Water By-pass Position
- Chiller Supply Temperature
- Condenser Water Return Temperature
- Chilled Water Bypass Temperature
- Outside Air Temperature
- Outside Air Wet Bulb Temperature
- Cooling Tower Basin Temperature (each tower)
- Cooling Tower Return Temperature
- Cooling Tower Supply Temperature
- Chiller Differential Pressure

DIGITAL INPUTS (DI)

- Pump Fail Indication - (each pump)
- Individual H-O-A Switch Position
- Cooling Tower Basin High Level (each tower)
- Cooling Tower Basin Low Level (each tower)
- Condenser Water Chemical Feed Alarm Status
- Chilled Water Chemical Feed Alarm Status
- Cooling Tower Alarm Status (each tower)

ANALOG OUTPUTS (AO)

- Water System Differential Pressure Setpoint
- Water Temperature Setpoint
- Condenser Water By-pass Position
- Free Cooling Bypass Position
- Cooling Tower VFD Speed (each Tower)

DIGITAL OUTPUTS (DO)

- Chiller Start/Stop (each chiller)
- Chiller Isolation Valves (2 per chiller) Provide End Switches.
- Cooling Tower Isolation Valves (3 per tower) Provide End Switches.
- Cooling Tower VFD Start (each Tower)

Note: Dewpoint shall be calculated and displayed for all humidity sensing points, outside the building, inside the building, in the air handlers, and in the dessicant units.

CONTROL LEGEND

SYMBOL	DESCRIPTION	SYMBOL	DESCRIPTION
(AI)	ANALOG INPUT POINT	WFD	VARIABLE FREQUENCY DRIVE
(AO)	ANALOG OUTPUT POINT	AFMS	AIR FLOW MONITOR
(DI)	DIGITAL INPUT POINT	CC	CHILLED WATER COIL
(DO)	DIGITAL OUTPUT POINT	HC	HOT WATER COIL
(DPS)	DIFFERENTIAL PRESSURE SENSOR	HSL	HIGH STATIC LIMIT
SP	STATIC PRESSURE SENSOR	T	ROOM TEMPERATURE SENSOR
SD	SMOKE DETECTOR	H	HUMIDITY SENSOR
DA	DAMPER ACTUATOR	CO2	CO2 SENSOR
FBD	FACE & BYPASS DAMPER	NO	NORMALLY OPEN
SAT	SUPPLY AIR TEMPERATURE SENSOR	NC	NORMALLY CLOSED
PHT	PREHEAT TEMPERATURE	C	COMMON
CCT	COOLING COIL TEMPERATURE	S	SUPPLY
MAT	MIXED AIR TEMPERATURE	R	RETURN
LTD	LOW TEMPERATURE DETECTOR	DM	DAMPER MOTOR
HWV	HOT WATER VALVE	SDM	SMOKE DAMPER MOTOR
CWV	CHILLED WATER VALVE	CWV	CHILLED WATER VALVE
DTS	DISCHARGE AIR TEMPERATURE	CHR	CHILLED WATER RETURN
OSAT	OUTSIDE AIR TEMPERATURE SENSOR	CHS	CHILLED WATER SUPPLY
MAH	MIXED AIR HUMIDITY	HR	HOT WATER RETURN
SAH	SUPPLY AIR HUMIDITY SENSOR	HS	HOT WATER SUPPLY
RAT	RETURN AIR TEMPERATURE SENSOR		

CHILLER, HEAT EXCHANGER, & COOLING TOWER CONTROLS 1
 NO SCALE

POLK STANLEY ROWLAND CURZON PORTER ARCHITECTS, LTD.

700 SOUTH SCHILLER
 LITTLE ROCK, AR 72201
 501.378.0878 office
 501.372.7629 fax

509 W. SPRING STREET,
 SUITE 150
 FAYETTEVILLE, AR 72701
 479.444.0473 office
 473.251.7216 fax

www.polkstanley.com

CONSULTANTS:

CIVIL ENGINEER:
 MCCLELLAND ENGINEERS

LANDSCAPE ARCHITECT:
 LARSON BURNS SMITH

STRUCTURAL ENGINEER:
 CROMWELL ENGINEERS INC.

MECH., ELEC., PLUMB. ENGINEER:
 CROMWELL ENGINEERS INC.

GLOBAL VILLAGE CONSULTANT
 CAMBRIDGE SEVEN ASSOCIATES

INTERIOR DESIGNER:
 POLK STANLEY ROWLAND
 CURZON PORTER ARCHITECTS

GENERAL CONTRACTOR:
 CDI CONTRACTORS, INC.

NOTES:

ISSUE DATE:
 17 SEPTEMBER 2007

REVISIONS:

#	DATE:	DESCRIPTION:
1	09/27/07	ADDENDUM 01
2	03/04/08	ASI #6
3	08/19/08	ASI #16

**MURPHY - KELLER
 EDUCATIONAL CENTER**


**HEIFER
 INTERNATIONAL
 CENTER**

LITTLE ROCK, ARKANSAS

PSRCP JOB NUMBER:
 431E

CONTENTS:
 MECHANICAL CONTROLS

SHEET NUMBER:
 M302

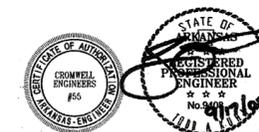

CONSULTANTS:

CIVIL ENGINEER:
MCLELLAND ENGINEERS

LANDSCAPE ARCHITECT:
LARSON BURNS SMITH

STRUCTURAL ENGINEER:
CROMWELL ENGINEERS INC.

MECH., ELEC., PLUMB. ENGINEER
CROMWELL ENGINEERS INC.

GLOBAL VILLAGE CONSULTANT
CAMBRIDGE SEVEN ASSOCIATES

INTERIOR DESIGNER:
POLK STANLEY ROWLAND
CURZON PORTER ARCHITECTS

GENERAL CONTRACTOR:
CDI CONTRACTORS, INC.

NOTES:

ISSUE DATE:
17 SEPTEMBER 2007

REVISIONS:

#	DATE:	DESCRIPTION:
1	09/27/07	ADDENDUM 01
2	01/07/08	ASI #01
3	01/16/08	ASI #02
4	06/18/08	ASI #16
5	09/14/08	ASI #31
6	02/27/09	ASI #37

MURPHY - KELLER
EDUCATIONAL CENTER

HEIFER
INTERNATIONAL
CENTER

LITTLE ROCK, ARKANSAS

PSRCP JOB NUMBER:
431E

CONTENTS:
MECHANICAL SCHEDULE:

SHEET NUMBER:

M401

100% O.S.A. - AIR HANDLING UNIT

MARK	SERVES	LOCATION	COOLING CAPACITY		OAT		FAN					NG MODULE		ELECTRIC HEAT		MOCP	REFERENCE PRODUCT
			TOTAL MBH	SENS. MBH	DB °F	WB °F	CFM	ESP	RPM	HP	VOLTS/Ø	FREE MBH	MAX MBH	KW	VOLTS/Ø		
MAU-1	HOOD	MECH MEZZ	-	-	96"	77"	1840	.5	910	.75	208/1	-	275	-	-	-	CAPTIVEAIRE 10"-L

PROVIDE 2" PLEATED FILTERS, WITH VBI-01 V-BANK FILTER INTAKE, DUCT DISCHARGE TEMPERATURE THERMOSTAT, 18-275 MBH D1.250 DIRECT FIRED HEATING MODULE, 5.4 FLA, 82° LAT DURING HEATING CYCLE, FILTERED AIR ONLY WHEN TEMPERATURE ABOVE 62°

AIR HANDLING UNIT

MARK	SERVES	LOCATION	FAN								COILS			FILTER(S)	REFERENCE PRODUCT	
			CFM	OSA	ESP	TSP	TYPE	RPM	BHP	MHP	VOLTS/Ø	PRE HEAT	CLG			HTG
AHU-1	EXHIBIT	MEZZANINE	18600	4000	2.0	4.0	PLENUM	1095	17.16	25	460/3	HC-1	CC-1	HC-2	20	McQUAY CAH035GDDC
AHU-2	MULTI-PURPOSE	MEZZANINE	10100	3000	2.0	4.0	PLENUM	1485	9.57	15	460/3	HC-3	CC-2	HC-4	12	McQUAY CAH021GDDC
AHU-3	CAFE	MEZZANINE	4500	1215	2.0	3.86	PLENUM	3500	7.82	10	460/3	HC-5	CC-3	HC-6	6	McQUAY CAH010GDGM
AHU-4	GIFT SHOP	MECH. RM.	4000	1045	2.0	3.82	PLENUM	3042	5.74	7.5	460/3	HC-7	CC-4	HC-8	3	McQUAY CAH010GDDC

- ① PROVIDE PLEATED 30% MERV 6 TYPE FILTERS
- ② PROVIDE PRE-WIRED VARIABLE SPEED CONTROLLER FOR ALL FANS
- ③ PROVIDE MOTORIZED OPPOSED BLADE DAMPERS. MECHANICAL CONTRACTOR RESPONSIBLE FOR INSTALLING ALL INTERNAL POWER AND CONTROL WIRING AS REQUIRED TO PROVIDE FULLY OPERATIONAL FAN AND DAMPER.

CHILLED WATER COOLING COIL

MARK	LOCATION	CFM	FACE VEL.	WIDTH	LENGTH	ROWS	FINS/INCH	TOTAL MBH	SENS. MBH	EDB °F	LDB °F	EWB °F	LWB °F	APD	EWT °F	LWT °F	GPM	WPD	REFERENCE PRODUCT
CC-1	AHU-1	18600	502	30	89	8	10	828	578	79.7	51.3	66.1	51.1	1.5	45	57.1	137	11.9	McQUAY 5W51008C
CC-2	AHU-2	10100	502	42	69	8	10	480	326	81.3	51.8	67.3	51.6	1.6	45	56.6	83.0	8.4	McQUAY 5W51008C
CC-3	AHU-3	4500	408	30	45	8	10	205	148	82.6	52.7	67.4	52.5	1.4	45	56.0	37.3	2.7	McQUAY 5W51008C
CC-4	AHU-4	4000	418	27	51	8	10	202	135	81.3	50.1	67.1	50.2	1.2	45	55.2	39.5	7.1	McQUAY 5W51008C

HOT WATER HEATING COIL

MARK	LOCATION	CFM	FACE VEL.	WIDTH	LENGTH	ROWS	FINS/INCH	MBH	EDB °F	LDB °F	APD	EWT °F	LWT °F	GPM	WPD	REFERENCE PRODUCT
HC-1	PRE-HEAT AHU-1	18600	577	27	86	1	10	690	58.0	92	0.21	180	148	43.4	8.1	McQUAY 5WQ1001C
HC-2	RE-HEAT AHU-1	18600	577	27	86	1	6	500	51.3	75.9	0.16	180	148	32.1	4.6	McQUAY 5WQ0601C
HC-3	PRE-HEAT AHU-2	10100	525	42	66	1	10	402	54.1	90.5	0.18	180	149	26.4	6.0	McQUAY 5WQ1001C
HC-4	RE-HEAT AHU-2	10100	525	42	66	1	6	275	51.8	76.7	0.13	180	148	17.1	2.6	McQUAY 5WQ0601C
HC-5	PRE-HEAT AHU-3	4500	514	30	42	1	10	172	54.9	89.8	0.18	180	150	11.5	1.5	McQUAY 5WQ1001C
HC-6	RE-HEAT AHU-3	4500	514	30	42	1	6	118	52.2	76.2	0.13	180	148	7.5	0.7	McQUAY 5WQ0601C
HC-7	PRE-HEAT AHU-4	4000	444	27	48	1	10	158	55.8	92.0	0.14	180	148	10.0	1.4	McQUAY 5WQ1001C
HC-8	RE-HEAT AHU-4	4000	444	27	48	1	6	114	50.4	76.5	0.10	180	148	7.2	0.8	McQUAY 5WQ0601C

CHILLER - WATER COOLED

MARK	LOCATION	CAPACITY (TONS)	EVAPORATOR				CONDENSER				COMPRESSORS				AMB TEMP °F	ELECTRICAL			MAX IPLV	REFERENCE PRODUCTS
			EWT °F	LWT °F	GPM	MAX. P.D.	EWT °F	LWT °F	GPM	MAX. P.D.	25%	50%	75%	100%		MCA	MOCP	VOLTS/Ø		
CH-2	1ST FLOOR MECH RM. HEADQUARTERS	83	54	42	199.4	15.1	83	93	249.3	9.6	0.879	1.759	2.638	3.517	100	111.3	150	460/3	0.523	CARRIER 30HXC086

- ① PROVIDE PRE-WIRED FACTORY MOUNTED INTEGRAL DISCONNECT DEVICE
- ② PROVIDE HOT GAS BY-PASS ON ANY ONE 15 TON CIRCUIT
- ③ PROVIDE 60 MESH BASKET STRAINER
- ④ PROVIDE (1) 30TON MODULE WITH (2) 15TON SCROLL COMPRESSORS AND (1) 50TON MODULE WITH (2) 25TON COMPRESSORS

DUCTLESS SPLIT SYSTEM

MARK	SERVES	COOLING MBH	HEATING MBH	CFM	ELECTRICAL			SEER	REFERENCE PRODUCT	
					FLA	MOCP	VOLTS/Ø			
MAC-1	MHP-1	SERVER RM.	9.0	12.2	200	10.3	20	120/1	16	SANYO INDOOR KHS0671 SANYO OUTDOOR CH0871

- ① MAC-1 AND MCU-1 COMPRISE A SINGLE AIR CONDITIONING SPLIT SYSTEM AND INCLUDES MICROPROCESSOR CONTROLS, WALL MOUNT FOR WIRELESS REMOTE, ON/OFF 24 HOUR TIMER, AND WASHABLE AIR FILTER.

UNIT HEATER - HOT WATER

MARK	LOCATION	CFM	MBH	GPM	WPD FT.	HP	RPM	VOLTS/Ø	REFERENCE PRODUCT
UH-1	WATER ROOM	340	12.8	1.3	0.5	1/60	1550	230/1	McQUAY UH-18
UH-2	MEZZANINE	1120	47	4.7	0.8	1/12	1550	230/1	McQUAY UH-63

- ① PROVIDE PRE-WIRED FACTORY MOUNTED INTEGRAL DISCONNECT DEVICE
- ② PROVIDE FACTORY LINE VOLT, HEAVY DUTY TYPE THERMOSTAT

EXHAUST FAN

MARK	SERVES	CFM	ESP	RPM	HP	VOLTS/Ø	MAX SONES	DRIVE	TYPE	CONTROL	WEIGHT	REMARKS	REFERENCE PRODUCT
EF-1	BATHROOM	700	0.5	1600	327w	120/1	4.2	DIRECT	IN-LINE	BAS	36	b,c	COOK GN-740
EF-2	MECH RM	350	0.25	1050	87.1w	120/1	5.5	DIRECT	CENTRIFUGAL	LINE VOLT T-STAT	30	a,b	COOK 100C100H
EF-3	MECH MEZZ	1400	0.25	1075	167	120/1	8.2	DIRECT	CENTRIFUGAL	LINE VOLT T-STAT	72	a,b	COOK T35C10D
EF-12	HEADQUARTERS	1250	0.50	933	221	460/3	7.0	BELT	IN-LINE	REFRIG. ALARM PANEL	150	b,c	COOK 150SQNB
EF-13	MECH MEZZ	2300	1.0	1120	1.5	208/1	14.5	BELT	CENTRIFUGAL	HOOD MOUNTED SWITCH	195	d	CAPTIVEAIRE NCA18HPFA

- ① PROVIDE PRE-WIRED FACTORY MOUNTED INTEGRAL DISCONNECT DEVICE (NEMA 3R FOR EXTERIOR)
- ② PROVIDE PRE-WIRED VARIABLE SPEED CONTROLLER ON DIRECT DRIVE FANS
- ③ PROVIDE ROOF CURB TO MATCH ROOF TYPE AND SLOPE AT ALL ROOF MOUNTED FANS
- ④ PROVIDE MOTORIZED DAMPER WITH TIME DELAY FAN START. MECHANICAL CONTRACTOR RESPONSIBLE FOR INSTALLING FAN, ROOF CURB, BACK DRAFT DAMPER, AND ALL INTERNAL POWER AND CONTROL WIRING TO PROVIDE FULLY OPERATIONAL FAN AND DAMPER
- ⑤ PROVIDE BIRD SCREEN
- ⑥ PROVIDE BACK DRAFT DAMPER
- ⑦ 700" MAX TEMPERATURE EXHAUST FAN, PROVIDE WITH MINIMUM 16 GAUGE GREASE DUCT CONNECTION TO TYPE 1 HOOD CONNECTION

INTAKE VENTILATOR

MARK	SERVES	CFM	PD	THROAT SIZE IN. x IN.	THROAT VELOCITY	TYPE	WEIGHT	REFERENCE PRODUCT
IV-1	EF-1	700	0.1	16x16	420	TIERED	50	COOK TRE
IV-2	AHU-4	1040	0.1	18x18	500	TIERED	50	COOK TRE

- ① PROVIDE ROOF MOUNTED EQUIPMENT CURB

PUMPS

MARK	SERVES	LOCATION	FLUID	TYPE	GPM	TDH FT.	IMPELLER DIA.	RPM	HP	VOLTS/Ø	MIN EFF.	REFERENCE PRODUCT
CHP-1	CHILLERS	HEADQUARTERS	WATER	CENTRIFUGAL	500	100	10.4	1750	20	460/3	77.2	PACO PUMPS 30127
CHP-2	CHILLERS	HEADQUARTERS	WATER	CENTRIFUGAL	500	100	10.4	1750	20	460/3	77.2	PACO PUMPS 30127

- ① PROVIDE NEW VARIABLE FREQUENCY DRIVE
- ② PROVIDE NEW SUCTION DIFFUSER WITH STRAINER

LOUVERS

MARK	SERVES	DESCRIPTION	SIZE (W/L)	MAX PD (IN W.G.)	MIN FREE AREA (SQFT)	VELOCITY (FT/MIN)	REFERENCE PRODUCT
LV-1	AHU-1 & AHU-2	INTAKE	54/86	0.25	16.96	412	RUSKIN ELF 6375D
LV-2	AHU-3	INTAKE	54/22	0.25	3.00	404	RUSKIN ELF 6375D
LV-3	MECH MEZZ	INTAKE	54/26	0.25	3.54	395	RUSKIN ELF 6375D

AIR DEVICE

MARK	TYPE	DESCRIPTION	SIZE	REFERENCE PRODUCT
A	SUPPLY DIFFUSER	ALUMINUM LINEAR BAR 0" DEFLECTION, 1/8" FIXED BARS, 1/4" SPACING WIDTH WALL MOUNTED	4' x 4"	TITUS CT-480-4-01-N-AG35
B	SUPPLY DIFFUSER	ALUMINUM LINEAR BAR 0" DEFLECTION, 7/32" FIXED BARS, 7/16" SPACING WIDTH FLOOR MOUNTED	4' x 2-1/2"	TITUS CT-PP-0-5-01-A-AG35
C	SUPPLY DIFFUSER	ALUMINUM LINEAR BAR 0" DEFLECTION, 7/32" FIXED BARS, 7/16" SPACING WIDTH FLOOR MOUNTED	3' x 3-1/2"	TITUS CT-PP-0-5-01-A-AG35
D	SUPPLY DIFFUSER	ALUMINUM LINEAR BAR 0" DEFLECTION, 7/32" FIXED BARS, 7/16" SPACING WIDTH FLOOR MOUNTED	4'x5"	TITUS CT-PP-0-5-01-A-AG35
E	SUPPLY DIFFUSER	ALUMINUM LINEAR SLOT 3/4" SLOT WIDTH DUCT MOUNTED	3 SLOT	TITUS ML-38-48-16-3-01-20
F	SUPPLY DIFFUSER	ALUMINUM LINEAR SLOT 3/4" SLOT WIDTH DUCT MOUNTED	2 SLOT	TITUS ML-38-48-16-2-01-12
G	SUPPLY DIFFUSER	ALUMINUM ADJUSTABLE SPOT DIFFUSER	12"	AIR CONCEPTS APLD
H	SUPPLY DIFFUSER	ALUMINUM LAYIN CEILING DIFFUSER	2' x 2'	TITUS "OMNI"
X	EXHAUST GRILLE	LAYIN CEILING EGGRATE GRILLE	2' x 2'	TITUS "50F"
Y	RETURN GRILLE	HEAVY DUTY SIDE WALL RETURN GRILLE 1/2" O.C. SPACING, 38" DEFLECTION BLADES PARALLEL TO LONG DIMENSION	54"x26"	TITUS "33R"
Z	RETURN GRILLE	LAYIN CEILING EGGRATE GRILLE	2' x 2'	TITUS "50F"
J	RETURN GRILLE	SIDEWALL RETURN GRILLE 1/2" SPACING, 0" DEFLECTION BLADES PARALLEL TO LONG DIMENSION	42" x 20"	TITUS "355ZFL"



BASIC PLUMBING PIPING

SYMBOL	DESCRIPTION	ABBREVIATION	SYMBOL	DESCRIPTION	ABBREVIATION
	STORM DRAIN	SD		2-WAY MOTORIZED VALVE	2WMV
	SANITARY SEWER	SS		3-WAY MOTORIZED VALVE	3WMV
	VENT	V		3-WAY VALVE	3WV
	COMBINATION WASTE AND VENT	CWV		ANGLE VALVE	AV
	GREASE WASTE	GW		BALL VALVE	BV
	ACID DRAIN	AD		BUTTERFLY VALVE	BFV
	ACID VENT	AV		CHECK VALVE	CV
	DRAIN	D		CIRCUIT SETTER	CS
	VENTS FOR TANKS OR EQUIPMENT	EV		FIXED FLOW ORIFICE	FFO
	COLD WATER	CW		GAS COCK	GC
	HOT WATER	HW		GATE VALVE	GV
	HOT WATER RETURN	HWR		GLOBE VALVE	GBV
	DOMESTIC HOT WATER SUPPLY (140° F)			NEEDLE VALVE	NV
	(180° F) SANITIZING HOT WATER	180° S		PLUG VALVE	PV
	(180° F) SANITIZING HOT WATER RETURN	180° R		PRESSURE REDUCING VALVE	PRV
	CHILLED DRINKING WATER SUPPLY	DWS		SOLENOID VALVE	SD
	DISTILLED WATER	DWR		SWING CHECK VALVE	SCV
	CHILLED DRINKING WATER RETURN	DI		UNION	UN
	SUMP PUMP DISCHARGE	SPD		FLOW - IN DIRECTION OF ARROW	
	PITCH DOWN IN DIRECTION OF ARROW			CONCENTRIC REDUCER	
	ROOF DRAIN	RD		90° ELBOW	
	AUXILIARY ROOF DRAIN	ARD		45° ELBOW	
	BACKFLOW PREVENTOR	BFP		BRANCH CONNECTION OUT OF SIDE	
	PIPE ANCHOR	AN		BRANCH CONNECTION OUT OF TWO SIDES	
	PIPE GUIDE	GJ		RISER DOWN (ELBOW)	
	EXPANSION JOINT	EJ		RISER UP (ELBOW)	
	FLEXIBLE CONNECTOR (FLEX. CONN.)	FC		RISER UP (ELBOW)	
	STRAINER-WYE TYPE	STR		BRANCH CONNECTION OUT OF TOP	
	STRAINER-VERTICAL BASKET TYPE	STR		BRANCH CONNECTION OUT OF BOTTOM	
	WATER HAMMER ARRESTOR	WHA		BRANCH CONNECTION OUT OF TOP TO 90° ELBOW	
	PRESSURE GAUGE WITH GAUGE COCK	PG		BRANCH CONNECTION OUT OF BOTTOM TO 90° ELBOW	
	THERMOMETER (STRAIGHT SCALE)	TH		RISER DOWN TO 90° ELBOW	
	AUTOMATIC AIR VENT	AAV		CAP ON END OF PIPE	
	AIR CHAMBER	ACH		PLUMBING RISER NUMBER	
	HOSE BIB	HB			
	VALVE IN CAST IRON BOX				
	VACUUM BREAKER (ELEVATION)	VB			
	TRAP, STEAM OR MOISTURE	T			
	SIGHT GLASS	SG			
	TEST PLUG	TP			

ABBREVIATIONS

DESCRIPTION	ABBREVIATION	DESCRIPTION	ABBREVIATION	DESCRIPTION	ABBREVIATION
ABOVE FINISH FLOOR	AFF	EXHAUST	EXH	MOUNTED	MTD
AIR FILTER	AF	EXHAUST FAN	EF	OPPOSED BLADE DAMPER	OBD
AIR COMPRESSOR	AC	FEET PER MINUTE	FPM	OUTSIDE AIR	OSA
AIR COOLED CONDENSER	ACC	FLOOR CLEANOUT	FCO	PACKAGE TERMINAL AIR CONDITIONER	PTAC
AIR HANDLING UNIT	AHU	FLOOR DRAIN	FD	PLUMBING	PLBG
AMBIENT	AMB	FAN	F	POUNDS PER SQUARE INCH	PSI
AREA DRAIN	AD	FAN COIL UNIT	FCU	PLUMBING FIXTURE	P
AUTOMATIC DAMPER	ADPR	FAN	FT	POWER ROOF VENTILATION	PRV
AUXILIARY ROOF DRAIN	ARD	FIRE DAMPER	F.DPR	PRESSURE DROP	PD
BACK DRAFT DAMPER	BD	FIRE/SMOKE DAMPER (COMBINATION)	FS.DPR	REGISTER	REG
BOILER	B	FLEXIBLE CONNECTION	FLEX CONN	RELATIVE HUMIDITY	RH
BOILER FEED UNIT	BFU	FLOOR	FLR	RETURN AIR	RA
BRITISH THERMAL UNITS	BTU	FLY FAN	FF	RETURN AIR GRILLE	RAG
CAPACITY	CAP	FREEZE PROOF WALL HYDRANT	FPWH	REVOLUTIONS PER MINUTE	RPM
CATCH BASIN	CB	FREEZE PROOF BOX HYDRANT	FPBH	ROOM AIR CONDITIONING UNIT	RAC
CAST IRON	CI	FORWARD CURVE	FC	ROOF DRAIN	RD
CEILING DIFFUSER	CD	FURNACE	FU	SATURATED CONDENSING TEMPERATURE	SCT
CHILLER	CH	GALLON	GAL	SATURATED SUCTION TEMPERATURE	SST
CIRCULATING PUMP	CP	GALLONS PER HOUR	GPH	SMOKE DAMPER	S.DPR
CLEAN OUT	CO	GALLONS PER MINUTE	GPM	SPLITTER DAMPER	SD
CLEAN OUT TO GRADE	COTG	GRAVITY ROOF VENTILATOR	GRV	STAINLESS STEEL	SS
CONVERTOR	C	GREASE TRAP	GT	STATIC PRESSURE	SP
CONDENSING UNIT	CU	HEAT RECLAIM WATER HEATER	HRWH	STEAM	STM
CONNECT	CONN	HEATING COIL	HC	SUPPLY AIR	SA
COOLING COIL	CC	HEATING AND VENTILATING UNIT	HV	SUPPLY FAN	SF
COOLING TOWER	CT	HEATING, VENTILATING & COOLING	HVAC	TEMPERATURE	TEMP
CARBON DIOXIDE	CO ₂	HORSE POWER	HP	THERMOSTAT	TSTAT
CUBIC FEET PER MINUTE	CFM	HOT WATER GENERATOR	HWG	THOUSAND BTU/PER HOUR	MBH
COMB. FIRE, SMOKE DAMPER	FSDPR	HOT WATER STORAGE TANK	HWT	THREE WAY MODULATING VALVE	TWMV
CONDENSATE RETURN	CR	HOSE BIB	HB	TOTAL STATIC PRESSURE	TSP
DAMPER	DPR	HOSE STATION	HS	TOTAL DYNAMIC HEAD	TDH
DESICCANT DEHUMIDIFIER	DD	HUMIDIFIER	H	UNIT COOLER	UC
DETAIL	DTL	INTAKE VENTILATOR	IV	UNIT HEATER	UH
DOOR GRILLE	DG	INVERT	INV	UNIT VENTILATOR	UV
DOWN SPOUT	DS	KILOWATTS	KW	URINAL	UR
DRY BULB	DB	LEAVING AIR TEMPERATURE	LAT	VENT THROUGH ROOF	VTR
DRINKING FOUNTAIN	DF	LEAVING DRY BULB	LDB	WATER HEATER	WH
DUCT HEATING COIL	DHC	LEAVING WATER TEMPERATURE	LWT	WALL CLEANOUT	WCO
EFFICIENT	EFF	LEAVING WET BULB	LWB	WATER CLOSET	WC
ELECTRIC HEATING COIL	EHC	LAVATORY	LAV	WATER PRESSURE DROP	WPD
ELECTRIC WATER HEATER	EWH	LINEAR DIFFUSER	LD	WATER TEMPERATURE DIFFERENCE	WTD
ENERGY EFFICIENCY RATIO	EER	MANHOLE	MH	WATER TEMPERING VALVE	WTV
ENTERING AIR TEMPERATURE	EAT	MAKE-UP AIR UNIT	MAU	WET BULB	WB
ENTERING DRY BULB	EDB	MANUAL DAMPER	MD		
ENTERING WATER TEMPERATURE	EWT	MAXIMUM	MAX		
ENTERING WET BULB	EWB	MINIMUM	MIN		
EXTERNAL STATIC PRESSURE	ESP	MOTOR OPERATED DAMPER	MOD		

POLK STANLEY ROWLAND CURZON PORTER ARCHITECTS, LTD.

700 SOUTH SCHILLER
LITTLE ROCK, AR 72701
501.378.0878 office
501.372.7629 fax
509 W. SPRING STREET,
SUITE 150
FAYETTEVILLE, AR 72701
479.444.0473 office
479.251.7216 fax
www.polkstanley.com

CONSULTANTS:
CIVIL ENGINEER: MCCLELLAND ENGINEERS
LANDSCAPE ARCHITECT: LARSON BURNS SMITH
STRUCTURAL ENGINEER: CROMWELL ENGINEERS INC.
MECH., ELEC., PLUMB. ENGINEER: CROMWELL ENGINEERS INC.
GLOBAL VILLAGE CONSULTANT
CAMBRIDGE SEVEN ASSOCIATES
INTERIOR DESIGNER: POLK STANLEY ROWLAND CURZON PORTER ARCHITECTS
GENERAL CONTRACTOR: CDI CONTRACTORS, INC.

NOTES:

HVAC PIPING

SYMBOL	DESCRIPTION	ABBREVIATION
	GAS - LOW PRESSURE	G
	GAS - MEDIUM PRESSURE	MPG
	GAS - HIGH PRESSURE	HPG
	GAS - LIQUIFIED PETROLEUM	LPG
	COMPRESSED AIR	A
	VACUUM	V
	OXYGEN	O
	HOT WATER SUPPLY, HEATING	HS
	HOT WATER RETURN, HEATING	HR
	CHILLED WATER SUPPLY	CHS
	CHILLED WATER RETURN	CHR
	HOT-CHILLED SUPPLY	HCS
	HOT CHILLED RETURN	HCR
	CONDENSER WATER SUPPLY	CWS
	CONDENSER WATER RETURN	CWR
	STEAM (NO. INDICATES PRESSURE)	S 100
	CONDENSATE RETURN (NO. INDICATES PRESSURE OF SUPPLY)	C 100
	CONDENSATE PUMP DISCHARGE	CPD
	BOILER FEED WATER	BFW
	BLOW DOWN	BD
	FUEL OIL SUPPLY	FOS
	FUEL OIL RETURN	FOR
	HEAT TRANSFER SUPPLY	HTS
	HEAT TRANSFER RETURN	HTR
	REFRIGERANT DISCHARGE	RD
	REFRIGERANT SUCTION	RS
	REFRIGERANT LIQUID	RL

HVAC DUCTWORK

SYMBOL	DESCRIPTION	SYMBOL	DESCRIPTION
	SUPPLY UP		FIRE OR SMOKE DAMPER
	RETURN UP		SPLITTER DAMPER AT BRANCH OFF
	SUPPLY DOWN		SPLITTER DAMPER AT TEE
	RETURN DOWN		BULL HEAD TEE W/ TURNING VANES & DAMPERS
	ROUND UP		TAKE OFF W/ EXTRACTOR & MANUAL DAMPER
	ROUND DOWN		RECTANGULAR TRANSITION
	ROUND DUCT BREAK		90° BEND, ROUND DUCT
	RECTANGULAR DUCT BREAK		45° BEND, ROUND DUCT
	DOOR GRILLE		45° RECTANGULAR DUCT
	OPPOSED BLADE DAMPER		90° ELBOW W/ TURNING VANE
	PARALLEL BLADE DAMPER		SUPPLY AIR DEVICE
	MANUAL DAMPER		RETURN OR EXHAUST AIR DEVICE
	FLEXIBLE CONNECTION		
	LINED DUCT		

HVAC CONTROLS

SYMBOL	DESCRIPTION	ABBREVIATION
	THERMOSTAT	---
	HUMIDISTAT	---
	CARBON DIOXIDE SENSOR	---

SYMBOL	DESCRIPTION	ABBREVIATION
	CONNECT TO EXISTING AT THIS POINT	---
	KEYED NOTE	---
	REVISION/ADDENDUM CALL-OUT	---
	DIFFUSER CALL-OUT (SEE SCHEDULE SHEET)	---
	DIFFUSER CALL-OUT (SEE SCHEDULE SHEET)	---
	VAV CALL-OUT (SEE SCHEDULE SHEET)	---
	FIRE DAMPER CALL-OUT	F.DPR
	SMOKE DAMPER CALL-OUT	S.DPR
	COMBINATION FIRE/SMOKE DAMPER CALL-OUT	FS.DPR

NOTE: ALL SYMBOLS MAY NOT BE USED.



ISSUE DATE:
17 SEPTEMBER 2007

REVISIONS:

#	DATE:	DESCRIPTION:

MURPHY - KELLER EDUCATIONAL CENTER

HEIFER INTERNATIONAL CENTER

LITTLE ROCK, ARKANSAS

PSRCP JOB NUMBER:
431E

CONTENTS:
MECHANICAL LEGEND

SHEET NUMBER:
M001

- CONSULTANTS:
- CIVIL ENGINEER:
MCLELLAND ENGINEERS
 - LANDSCAPE ARCHITECT:
LARSON BURNS SMITH
 - STRUCTURAL ENGINEER:
CROMWELL ENGINEERS INC
 - MECH., ELEC., PLUMB. EN
CROMWELL ENGINEERS INC
 - GLOBAL VILLAGE CONSULT.
CAMBRIDGE SEVEN ASSOCI
 - INTERIOR DESIGNER:
POLK STANLEY ROWLAND
CURZON PORTER ARCHITECTS
 - GENERAL CONTRACTOR:
CDI CONTRACTORS, INC.

NOTES:

ISSUE DATE:
17 SEPTEMBER 2

REVISIONS:

#	DATE	DESCRIPTION
1	09/27/07	ADDENDUM 01
2	06/19/08	ASI #16

**MURPHY - KELLEI
EDUCATIONAL CENTER**


**HEIFER
INTERNATIONAL
CENTER**

LITTLE ROCK, ARKANSAS


PSRCP JOB NUMBER:
431E
CONTENTS:

MECHANICAL MEZZAI
FLOOR PLAN
SHEET NUMBER:


M101a

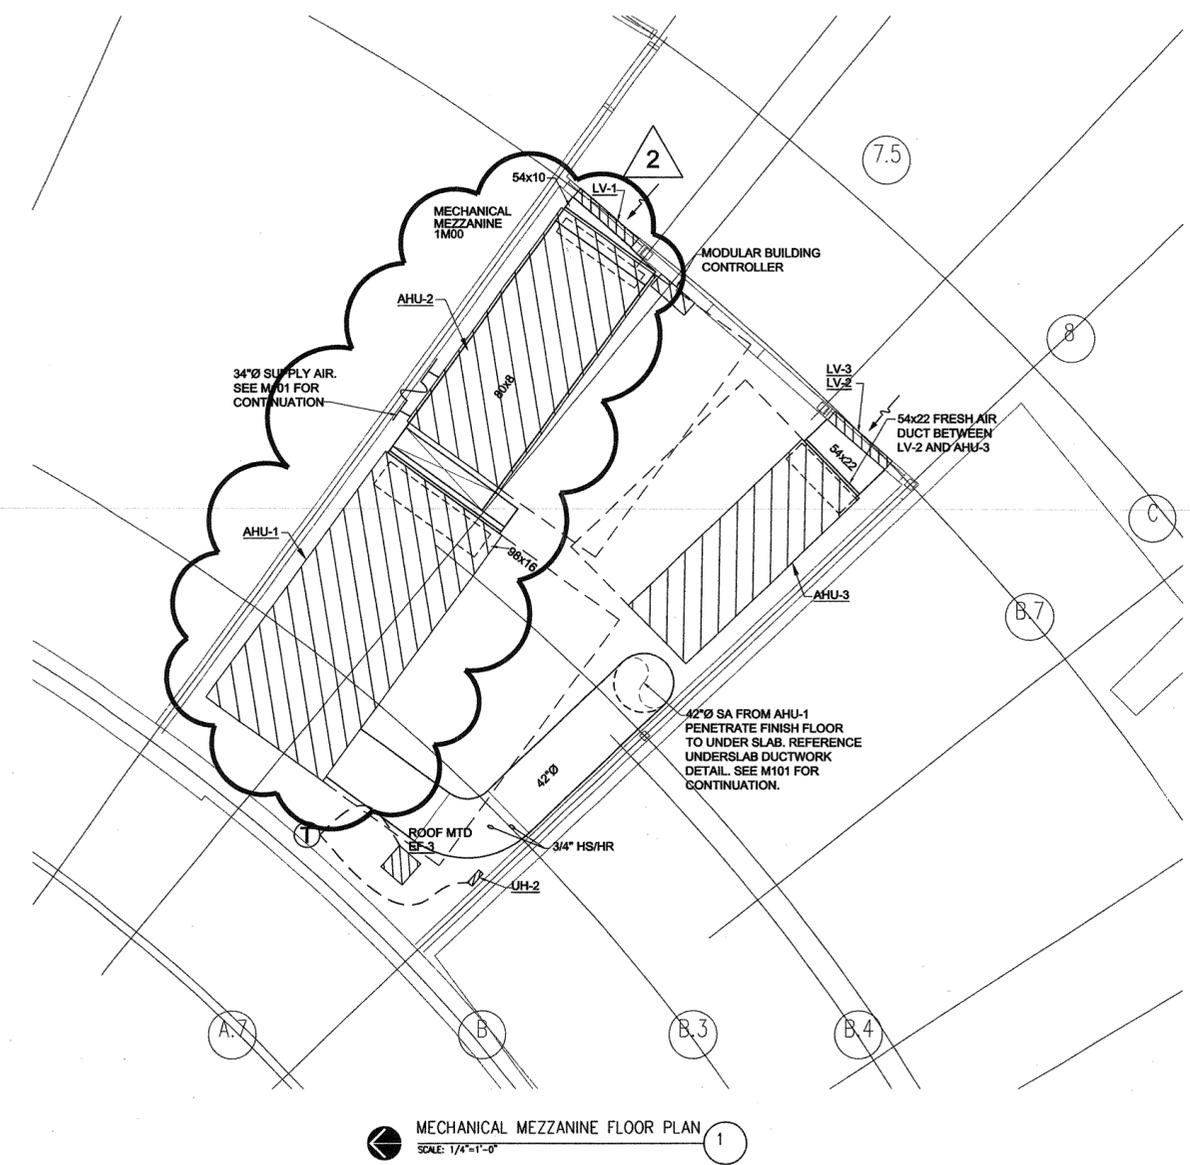

MECHANICAL MEZZANINE FLOOR PLAN
SCALE: 1/4"=1'-0" 1

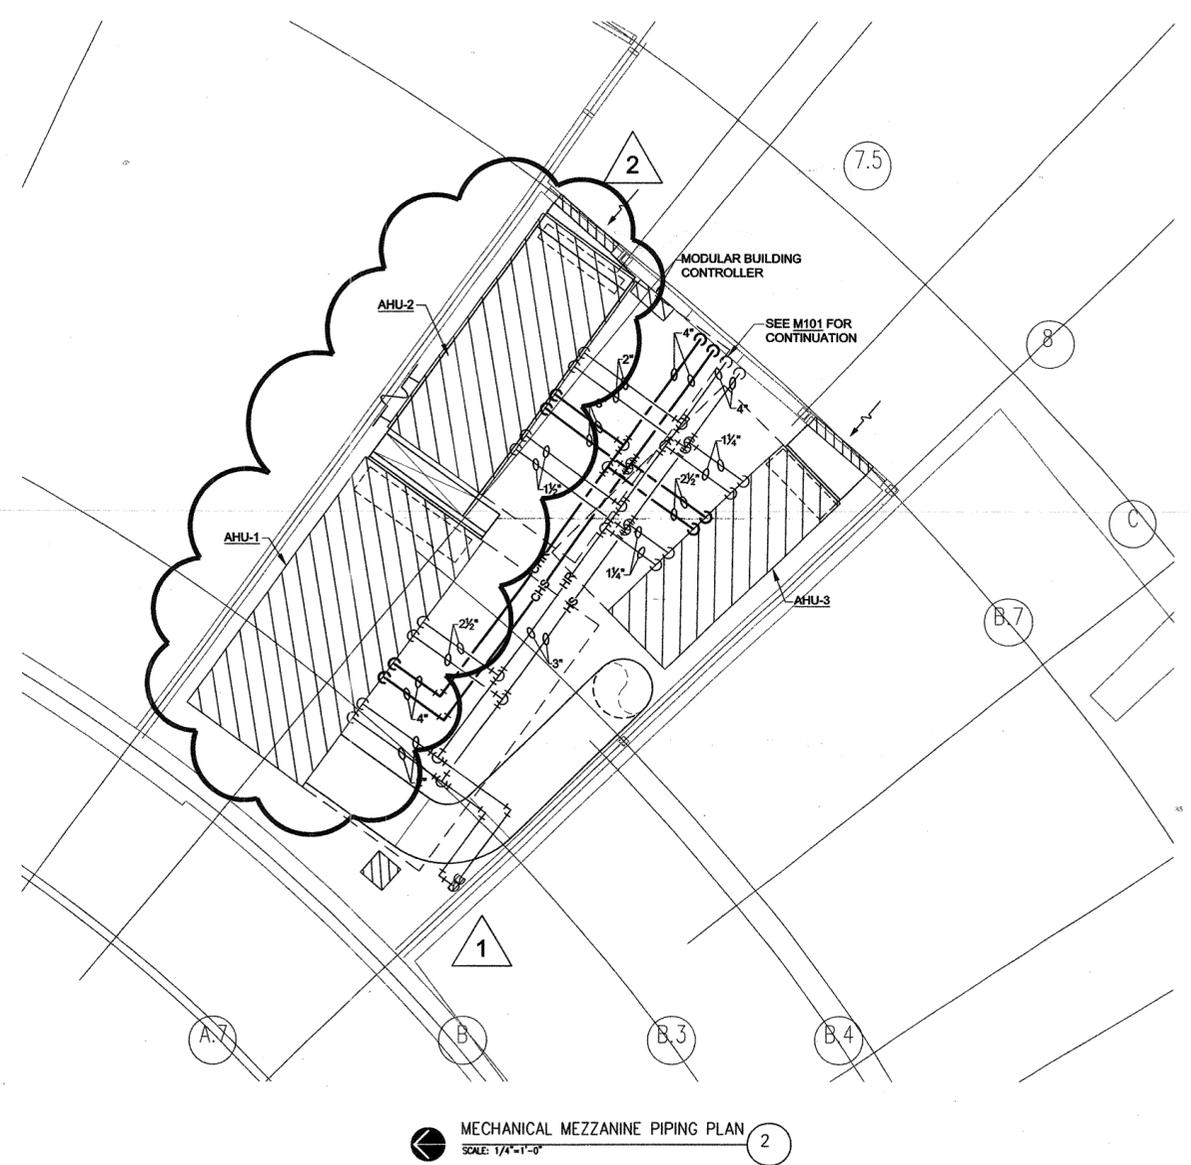

MECHANICAL MEZZANINE PIPING PLAN
SCALE: 1/4"=1'-0" 2

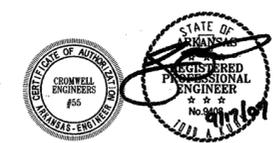

700 SOUTH SCHILLER
LITTLE ROCK, AR 72201
501.378.0878 office
501.372.7629 fax

509 W. SPRING STREET,
SUITE 150
FAYETTEVILLE, AR 72701
479.444.0473 office
473.251.7216 fax

www.polkstanley.com

CONSULTANTS:

CIVIL ENGINEER:
MCCELLAND ENGINEERS

LANDSCAPE ARCHITECT:
LARSON BURNS SMITH

STRUCTURAL ENGINEER:
CROMWELL ENGINEERS INC.

MECH., ELEC., PLUMB. ENGINEER:
CROMWELL ENGINEERS INC.

GLOBAL VILLAGE CONSULTANT
CAMBRIDGE SEVEN ASSOCIATES

INTERIOR DESIGNER:
POLK STANLEY ROWLAND
CURZON PORTER ARCHITECTS

GENERAL CONTRACTOR:
CDI CONTRACTORS, INC.

NOTES:

ISSUE DATE:
17 SEPTEMBER 2007

REVISIONS:

#	DATE	DESCRIPTION
Δ	02/27/09	ASI #37

MURPHY - KELLER
EDUCATIONAL CENTER

HEIFER
INTERNATIONAL
CENTER

LITTLE ROCK, ARKANSAS

PSRCP JOB NUMBER:


431E

CONTENTS:

ENLARGED PLAN

SHEET NUMBER:

M101K

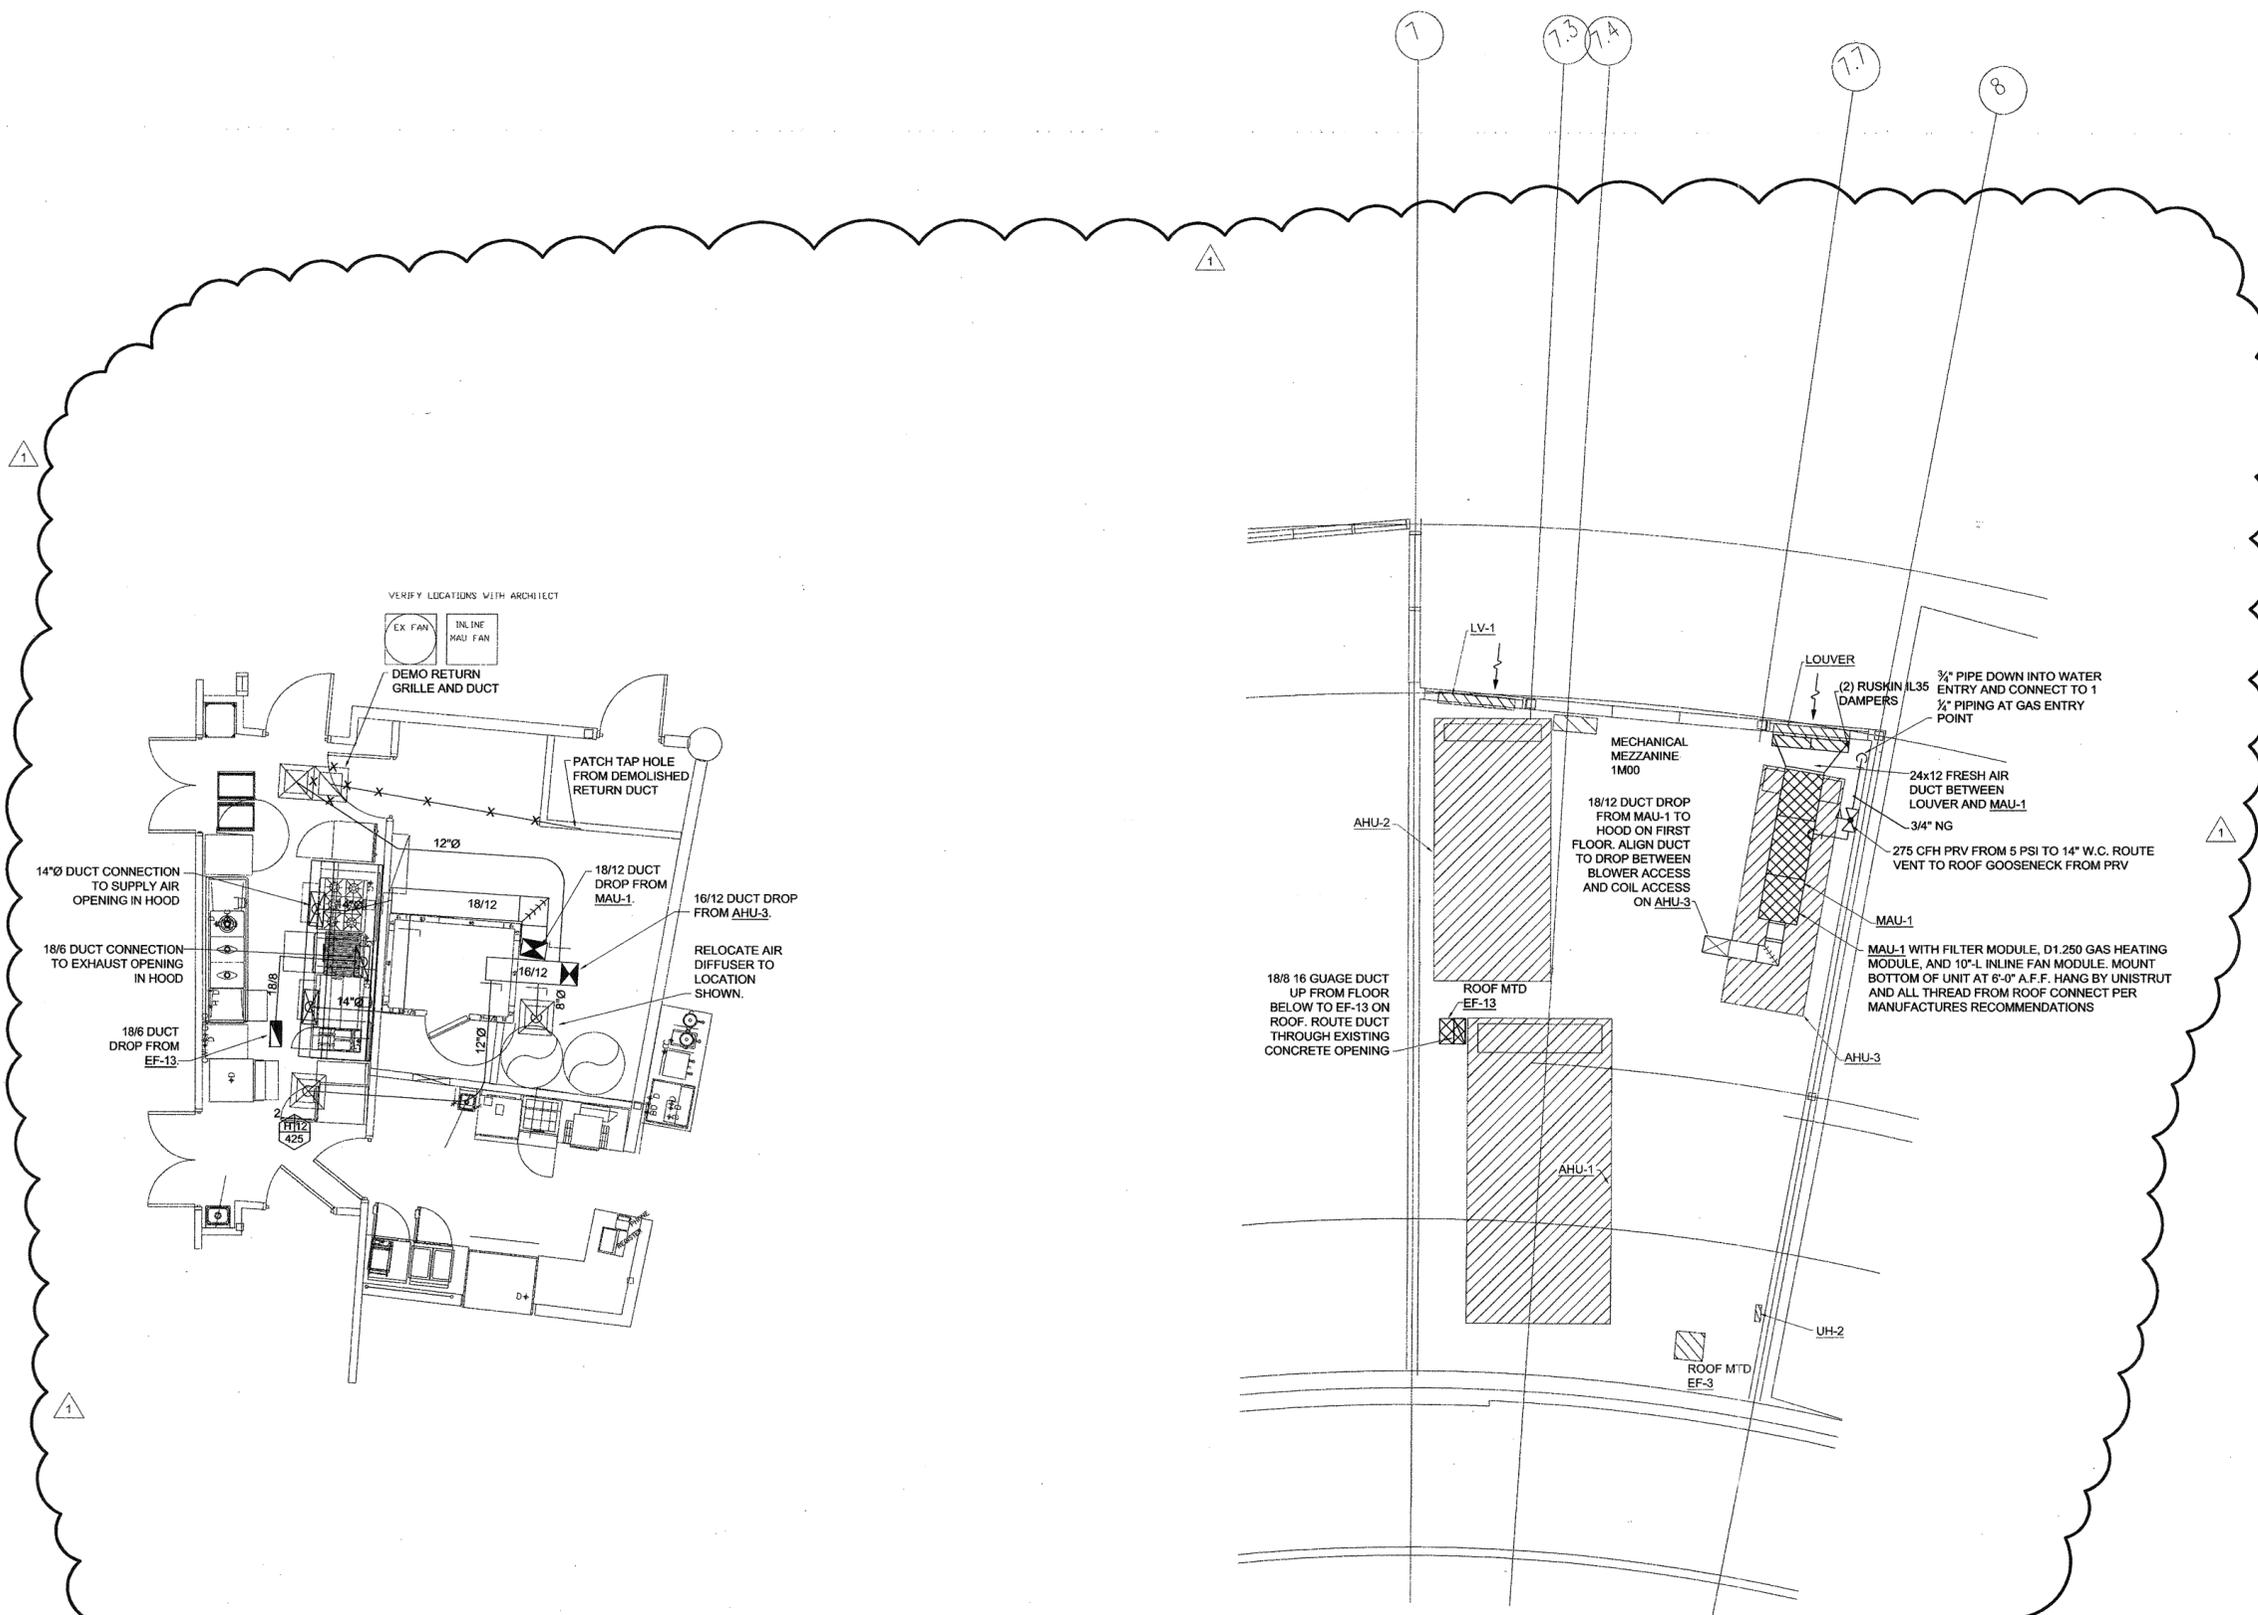

ENLARGED KITCHEN EQUIPMENT HVAC FIRST FLOOR PLAN


SCALE: 1/4"=1'-0"

2

ENLARGED KITCHEN EQUIPMENT HVAC MEZZANINE FLOOR PLAN

SCALE: 1/4"=1'-0"

1

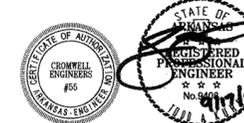

CONSULTANTS:

CIVIL ENGINEER:
MCLELLAND ENGINEERS

LANDSCAPE ARCHITECT:
LARSON BURNS SMITH

STRUCTURAL ENGINEER:
CROMWELL ENGINEERS INC.

MECH., ELEC., PLUMB. ENGINEER:
CROMWELL ENGINEERS INC.

GLOBAL VILLAGE CONSULTANT:
CAMBRIDGE SEVEN ASSOCIATES

INTERIOR DESIGNER:
POLK STANLEY ROWLAND
CURZON PORTER ARCHITECTS

GENERAL CONTRACTOR:
CDI CONTRACTORS, INC.

NOTES:

ISSUE DATE:

17 SEPTEMBER 2007

REVISIONS:

#	DATE	DESCRIPTION

Revision
#4 3/4/08
AS1 #06
loose in file
drawer

**INTERNATIONAL
CENTER**

LITTLE ROCK, ARKANSAS

PSRCP JOB NUMBER:


431E

CONTENTS:

MECHANICAL DETAILS

SHEET NUMBER:

M102

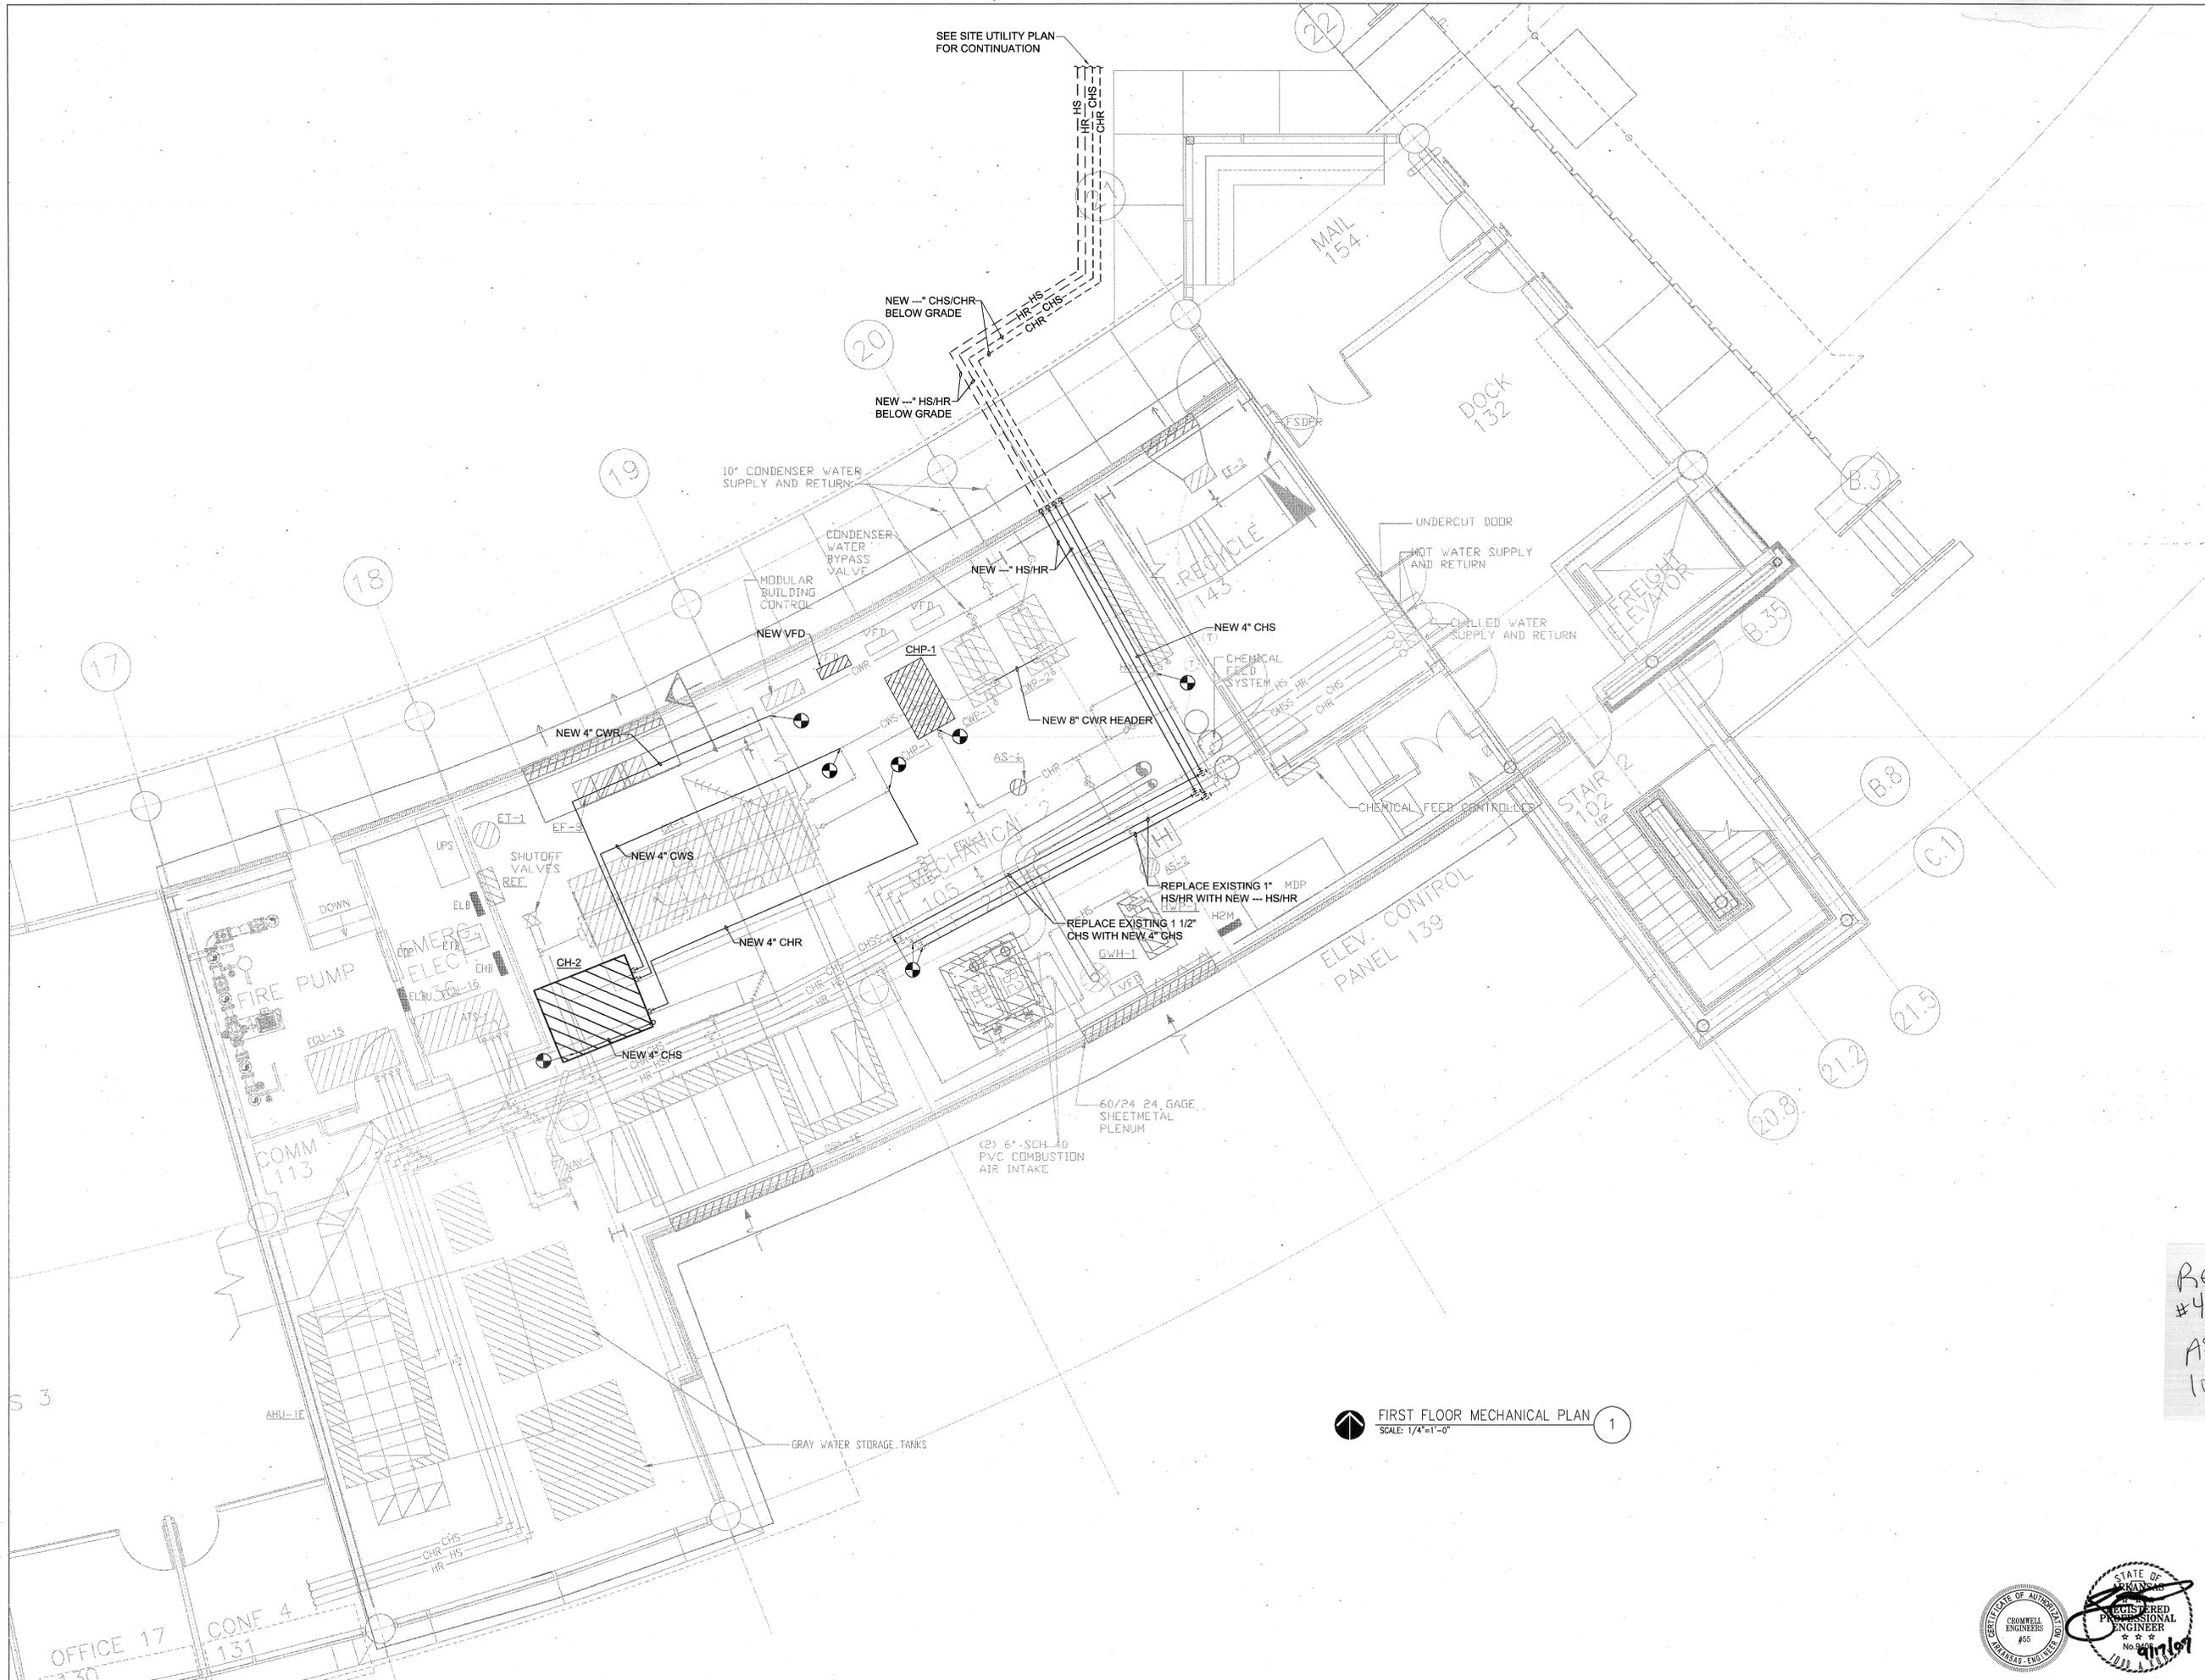

FIRST FLOOR MECHANICAL PLAN
SCALE: 1/4"=1'-0" **1**



CONSULTANTS:

CIVIL ENGINEER:
MCLELLAND ENGINEERS

LANDSCAPE ARCHITECT:
LARSON BURNS SMITH

STRUCTURAL ENGINEER:
CROMWELL ENGINEERS INC.

MECH., ELEC., PLUMB. ENGINEER:
CROMWELL ENGINEERS INC.

GLOBAL VILLAGE CONSULTANT
CAMBRIDGE SEVEN ASSOCIATES

INTERIOR DESIGNER:
POLK STANLEY ROWLAND
CURZON PORTER ARCHITECTS

GENERAL CONTRACTOR:
CDI CONTRACTORS, INC.

NOTES:

ISSUE DATE:
17 SEPTEMBER 2007

REVISIONS:

#	DATE	DESCRIPTION

MURPHY - KELLER
EDUCATIONAL CENTER

HEIFER
INTERNATIONAL
CENTER

LITTLE ROCK, ARKANSAS

PSRCP JOB NUMBER:


431E

CONTENTS:

MECHANICAL DETAILS


SHEET NUMBER:

M201

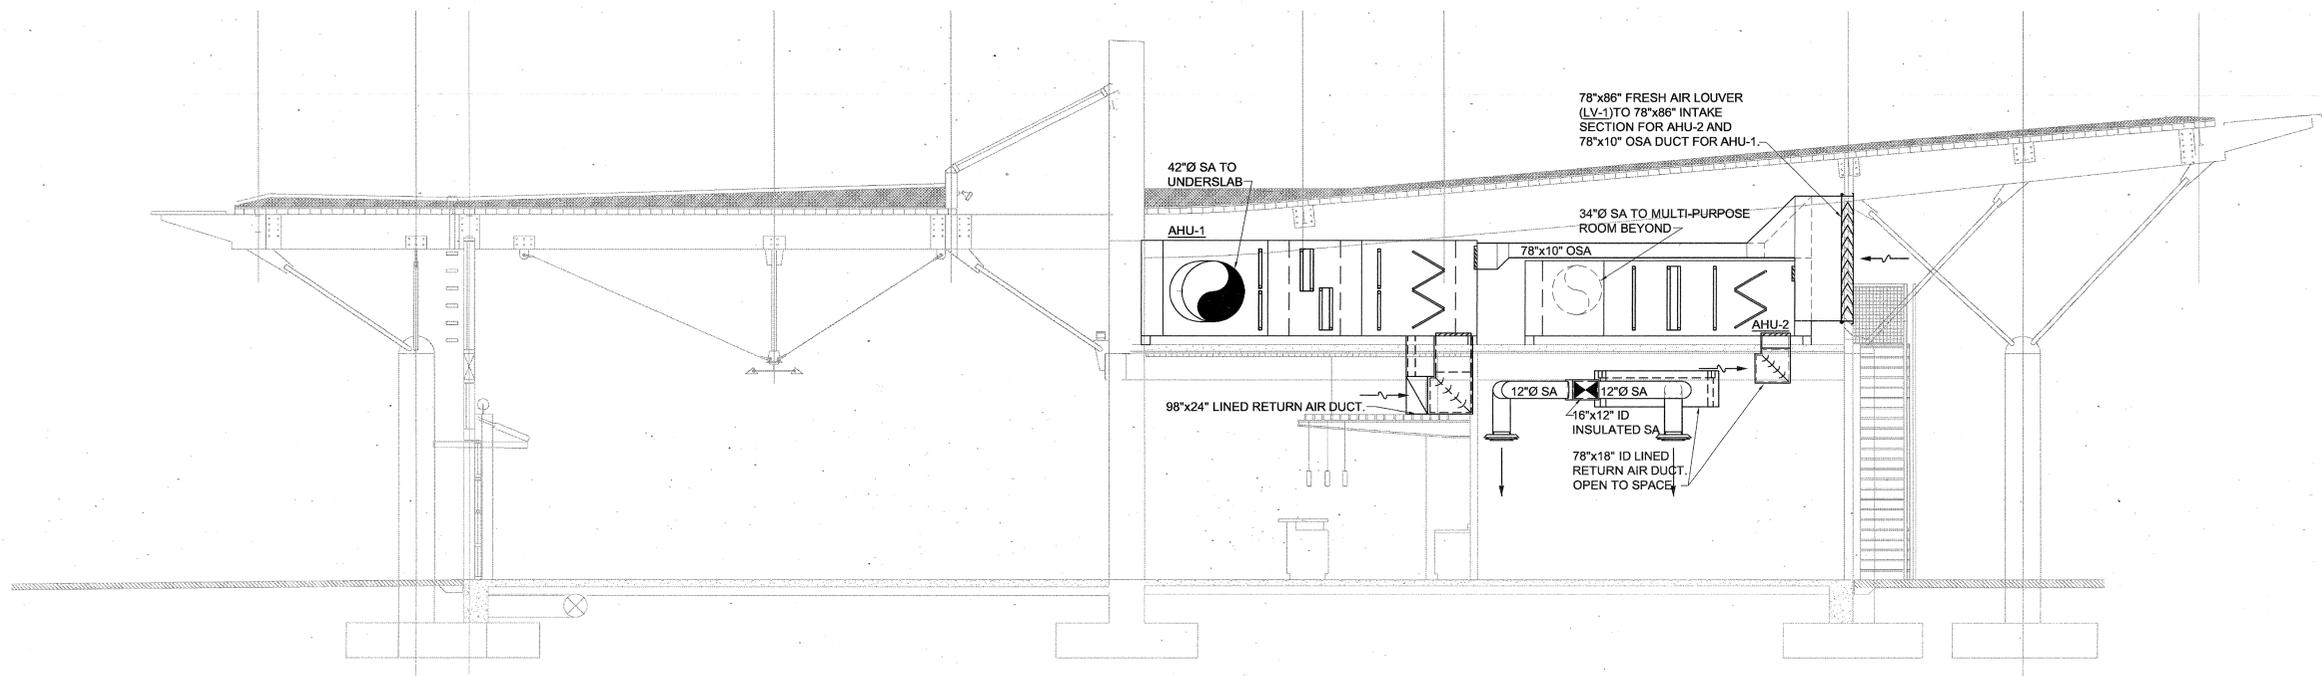

MECHANICAL SECTION THRU MEZZANINE 2


SCALE: 1/4"=1'-0"

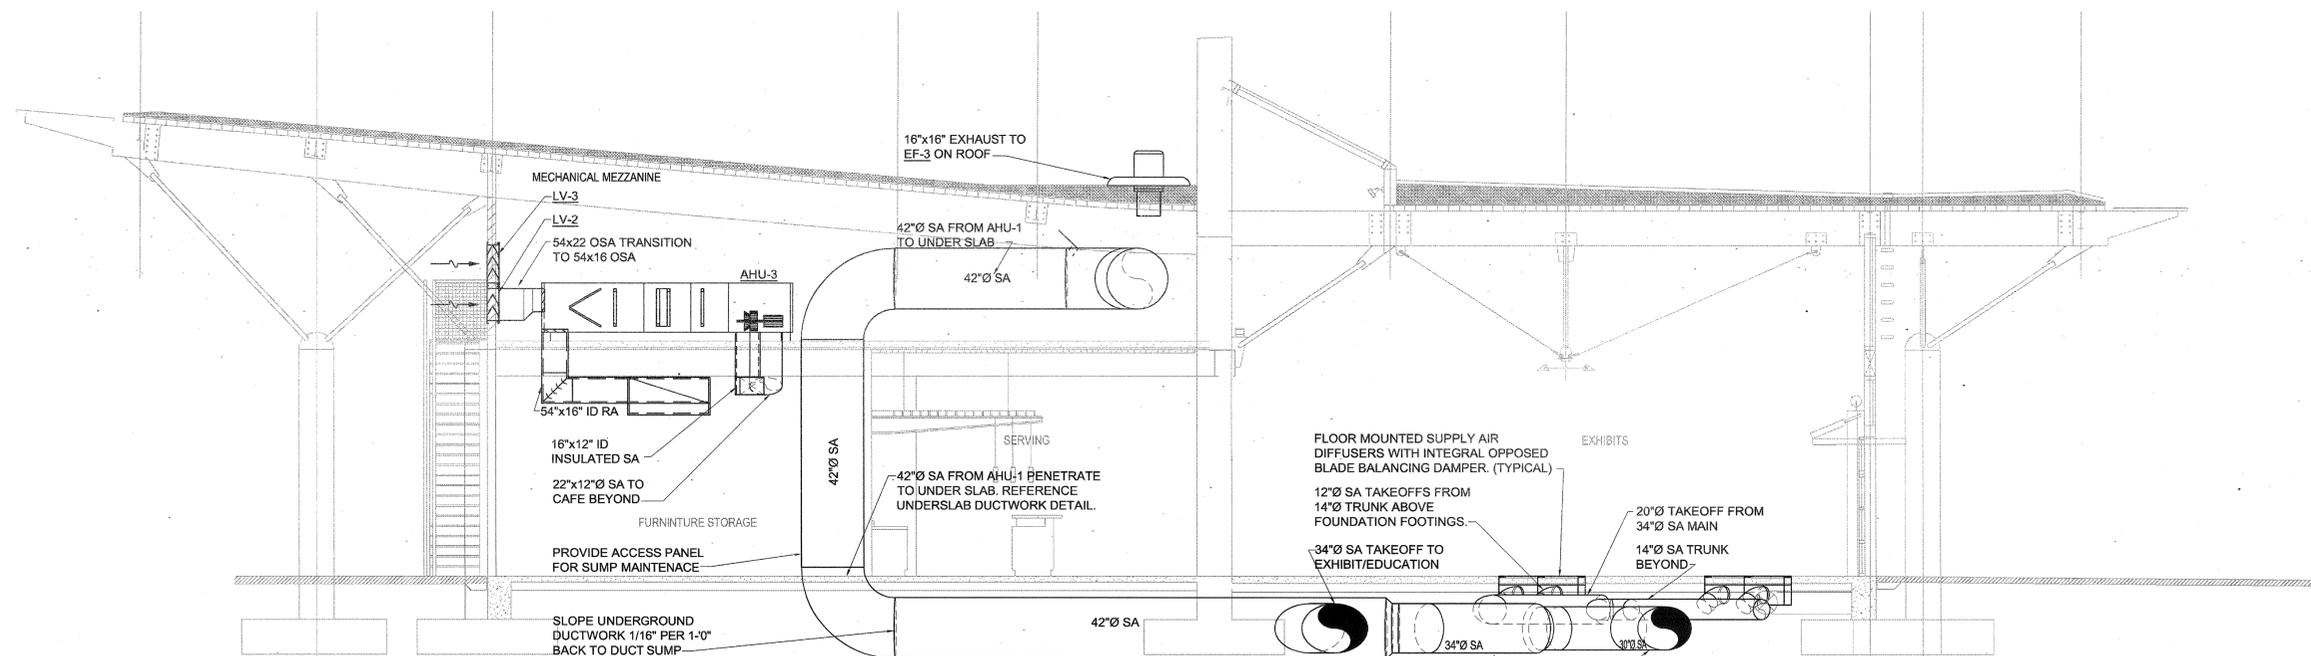

MECHANICAL SECTION THRU MEZZANINE 1

SCALE: 1/4"=1'-0"

 NOTE: ELEVATION MAY BE EXAGGERATED. COORDINATE LOCATION OF UNDERGROUND DUCTWORK WITH STRUCTURAL. LOCATE 14"Ø TRUNKS, TAKEOFFS, AND SUPPLY DIFFUSERS ABOVE FOUNDATION FOOTINGS.



CONSULTANTS:

CIVIL ENGINEER:
MCCLELLAND ENGINEERS

LANDSCAPE ARCHITECT:
LARSON BURNS SMITH

STRUCTURAL ENGINEER:
CROMWELL ENGINEERS INC.

MECH., ELEC., PLUMB. ENGINEER:
CROMWELL ENGINEERS INC.

GLOBAL VILLAGE CONSULTANT
CAMBRIDGE SEVEN ASSOCIATES

INTERIOR DESIGNER:
POLK STANLEY ROWLAND
CURZON PORTER ARCHITECTS

GENERAL CONTRACTOR:
CDI CONTRACTORS, INC.

NOTES:

ISSUE DATE:
17 SEPTEMBER 2007

REVISIONS:

#	DATE	DESCRIPTION
1	09/27/07	ADDENDUM 01
2	06/19/08	ASI #16
3	02/27/09	ASI #37

MURPHY - KELLER
EDUCATIONAL CENTER

HEIFER
INTERNATIONAL
CENTER



LITTLE ROCK, ARKANSAS

PSRCP JOB NUMBER:
431E


CONTENTS:
MECHANICAL DETAILS

SHEET NUMBER:

M201

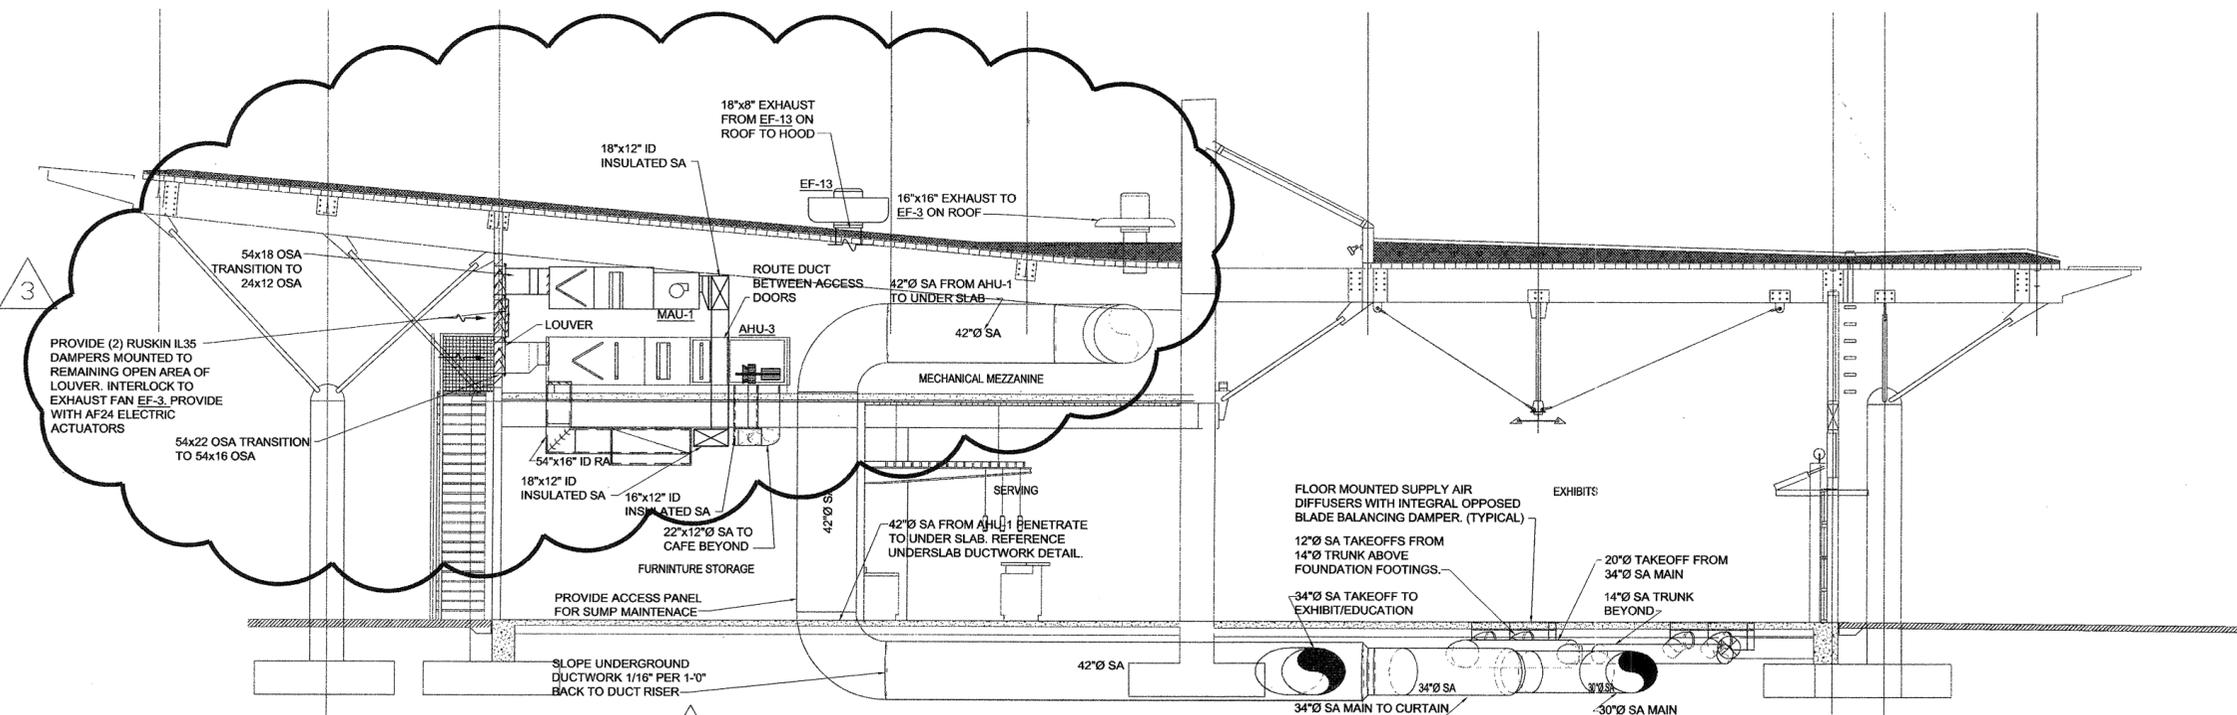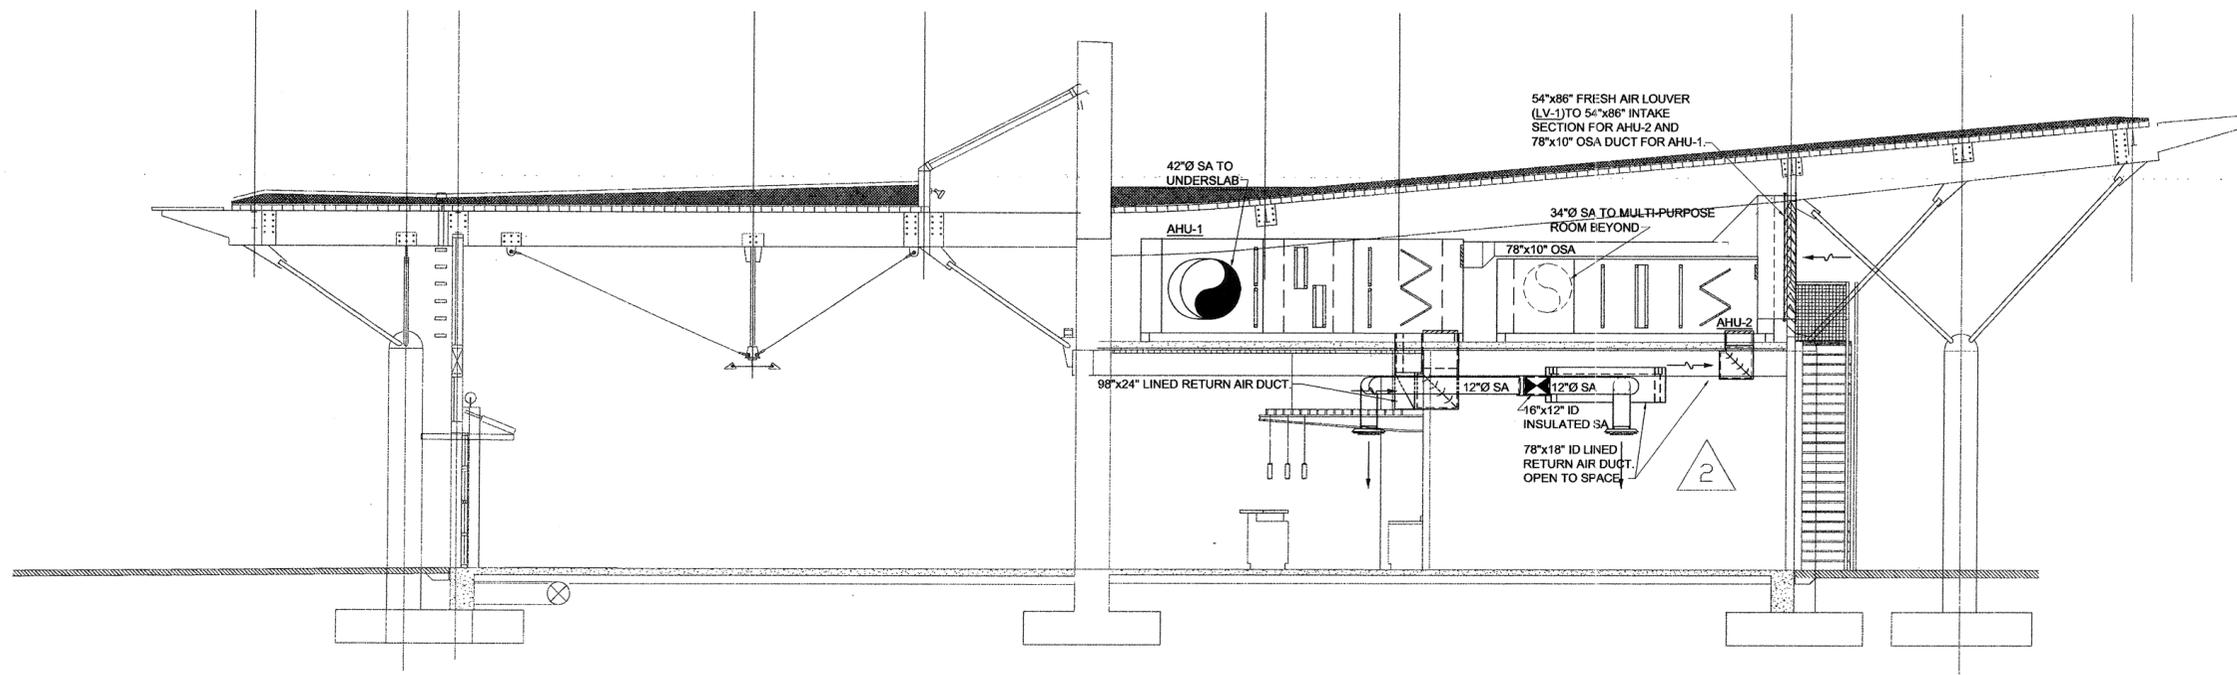

NOTE: ELEVATION MAY BE EXAGGERATED. COORDINATE LOCATION OF UNDERGROUND DUCTWORK WITH STRUCTURAL. LOCATE 14"Ø TRUNKS, TAKEOFFS, AND SUPPLY DIFFUSERS ABOVE FOUNDATION FOOTINGS.

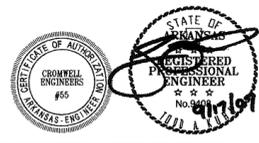

CONSULTANTS:

CIVIL ENGINEER:
MCLELLAND ENGINEERS

LANDSCAPE ARCHITECT:
LARSON BURNS SMITH

STRUCTURAL ENGINEER:
CROMWELL ENGINEERS INC.

MECH., ELEC., PLUMB. ENGINEER:
CROMWELL ENGINEERS INC.

GLOBAL VILLAGE CONSULTANT
CAMBRIDGE SEVEN ASSOCIATES

INTERIOR DESIGNER:
POLK STANLEY ROWLAND
CURZON PORTER ARCHITECTS

GENERAL CONTRACTOR:
CDI CONTRACTORS, INC.

NOTES:

ISSUE DATE:
17 SEPTEMBER 2007

REVISIONS:

#	DATE	DESCRIPTION
1	09/27/07	ADDENDUM 01
2	06/19/08	ASI #16
3	02/27/09	ASI #37

MURPHY - KELLER
EDUCATIONAL CENTER

HEIFER
INTERNATIONAL
CENTER

LITTLE ROCK, ARKANSAS

PSRCP JOB NUMBER:
431E

CONTENTS:
MECHANICAL DETAILS

SHEET NUMBER:
M201

