

CONSULTANTS:

CIVIL ENGINEER:
MCLELLAND CONSULTING
ENGINEERS INC.

LANDSCAPE ARCHITECT:
LARSON BURNS AND SMITH, INC.

STRUCTURAL ENGINEER:
CROMWELL ENGINEERS INC.

MECH., ELEC., PLUMB. ENGINEER:
CROMWELL ENGINEERS INC.

GLOBAL VILLAGE CONSULTANT:
CAMBRIDGE SEVEN ASSOCIATES

INTERIOR DESIGNER:
POLK STANLEY ROWLAND
CURZON PORTER ARCHITECTS

GENERAL CONTRACTOR:
CDI CONTRACTORS, INC.

NOTES:

- _____
- _____
- _____
- _____
- _____
- _____
- _____
- _____



ISSUE DATE:
17 SEPTEMBER 2007

REVISIONS:

#	DATE	DESCRIPTION

MURPHY KELLER
EDUCATION CENTER

HEIFER
INTERNATIONAL
CENTER


LITTLE ROCK, ARKANSAS

PSRCP JOB NUMBER:
431E


CONTENTS:
NORTH WETLAND SITE
AND LAYOUT PLAN

SHEET NUMBER:

L102

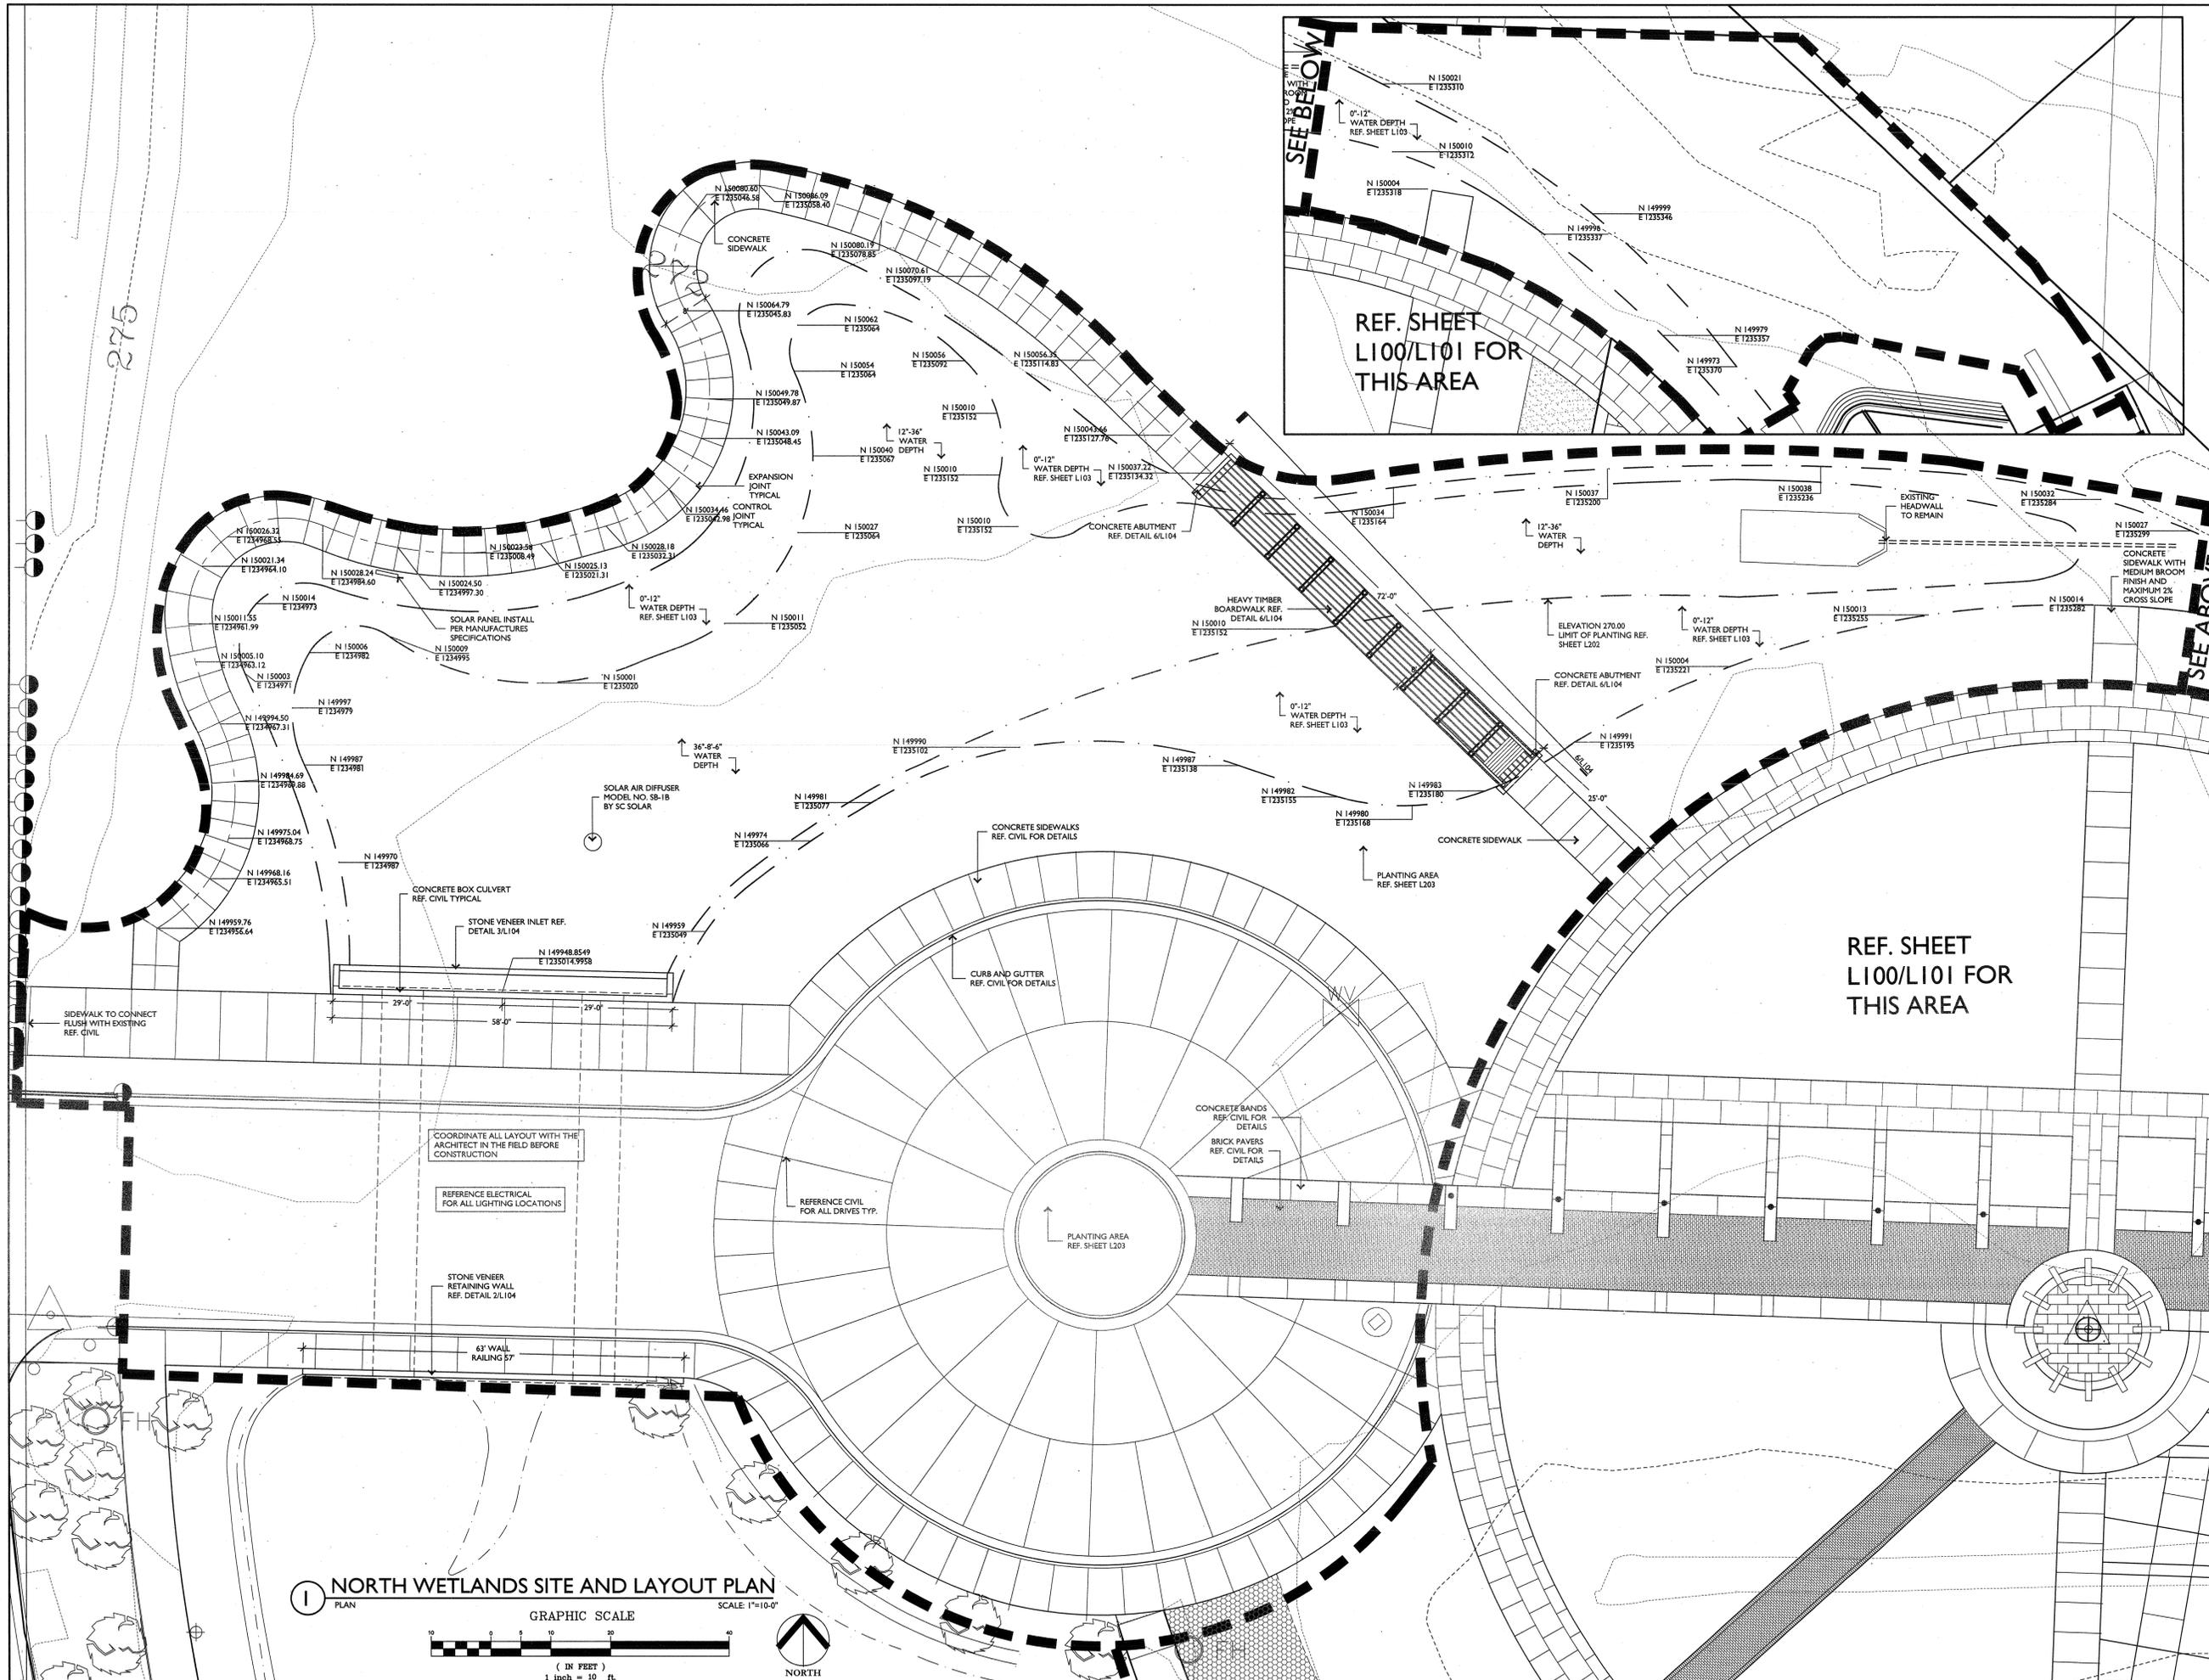

 1 NORTH WETLANDS SITE AND LAYOUT PLAN
PLAN



275

SEE BELOW

REF. SHEET
L100/L101 FOR
THIS AREA

REF. SHEET
L100/L101 FOR
THIS AREA

SEE ABOVE

CONSULTANTS:

CIVIL ENGINEER:
MCLELLAND CONSULTING
ENGINEERS INC.

LANDSCAPE ARCHITECTS:
LARSON BURNS AND SMITH, INC.

STRUCTURAL ENGINEER:
CROMWELL ENGINEERS INC.

MECH., ELEC., PLUMB. ENGINEER:
CROMWELL ENGINEERS INC.

GLOBAL VILLAGE CONSULTANT:
CAMBRIDGE SEVEN ASSOCIATES

INTERIOR DESIGNER:
POLK STANLEY ROWLAND
CURZON PORTER ARCHITECTS

GENERAL CONTRACTOR:
CDI CONTRACTORS, INC.

NOTES:

- _____
- _____
- _____
- _____
- _____
- _____
- _____
- _____



ISSUE DATE:
17 SEPTEMBER 2007

REVISIONS:

#	DATE	DESCRIPTION

**MURPHY KELLER
EDUCATION CENTER**


**HEIFER
INTERNATIONAL
CENTER**

LITTLE ROCK, ARKANSAS

PSRCP JOB NUMBER:
431E


CONTENTS:
NORTH WETLANDS
GRADING PLAN

SHEET NUMBER:
L103

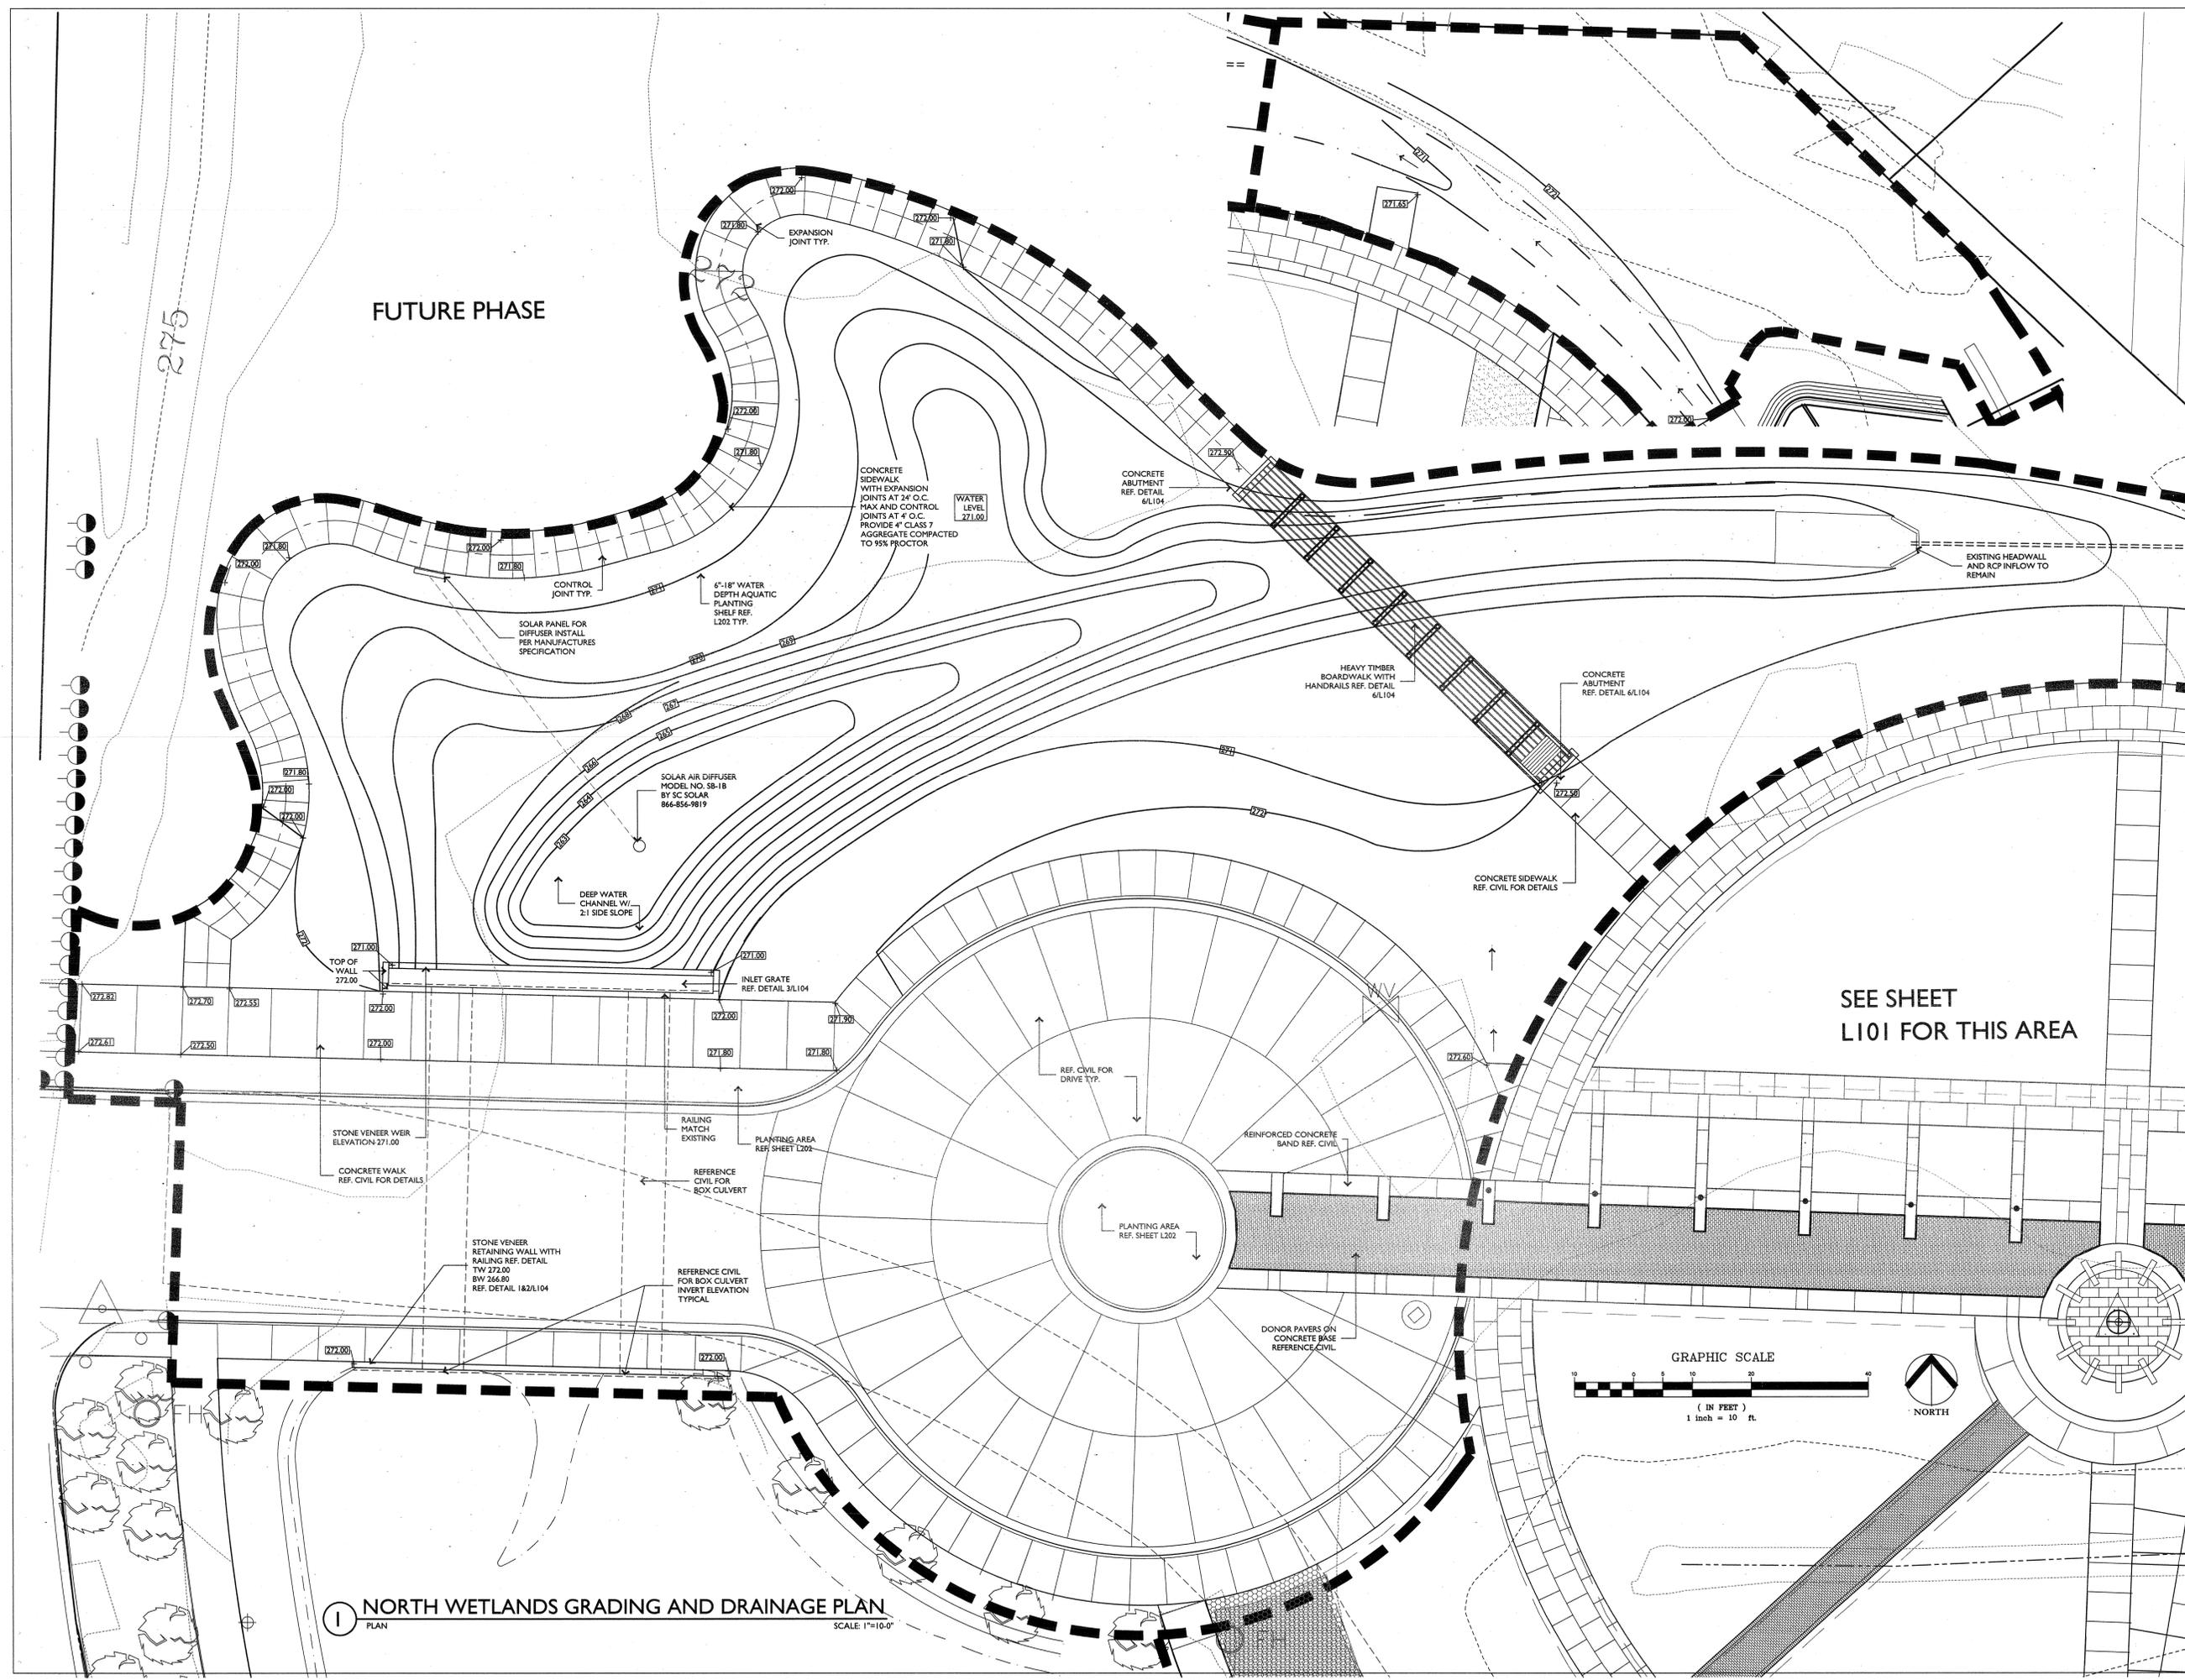

1 NORTH WETLANDS GRADING AND DRAINAGE PLAN
SCALE: 1"=10'-0"

 SEE SHEET
L101 FOR THIS AREA



700 SOUTH SCHILLER
LITTLE ROCK, AR 72201
501.378.0878 office
501.372.7629 fax

509W. SPRING STREET, SUITE 150
FAYETTEVILLE, AR 72701
479.444.0473 office
479.251.7216 fax

www.polkstanley.com

CONSULTANTS:

CIVIL ENGINEER:
MCCLELLAND CONSULTING
ENGINEERS INC.

LANDSCAPE ARCHITECT:
LARSON BURNS AND SMITH, INC.

STRUCTURAL ENGINEER:
CROMWELL ENGINEERS INC.

MECH., ELEC., PLUMB. ENGINEER:
CROMWELL ENGINEERS INC.

GLOBAL VILLAGE CONSULTANT:
CAMBRIDGE SEVEN ASSOCIATES

INTERIOR DESIGNER:
POLK STANLEY ROWLAND
CURZON PORTER ARCHITECTS

GENERAL CONTRACTOR:
CDI CONTRACTORS, INC.

NOTES:

- _____
- _____
ISSUE DATE:
17 SEPTEMBER 2007

REVISIONS:

#	DATE	DESCRIPTION

**MURPHY KELLER
EDUCATION CENTER**


**HEIFER
INTERNATIONAL
CENTER**

LITTLE ROCK, ARKANSAS


PSRCP JOB NUMBER:
431E

CONTENTS:
SITEWORK DETAILS

SHEET NUMBER:
L104

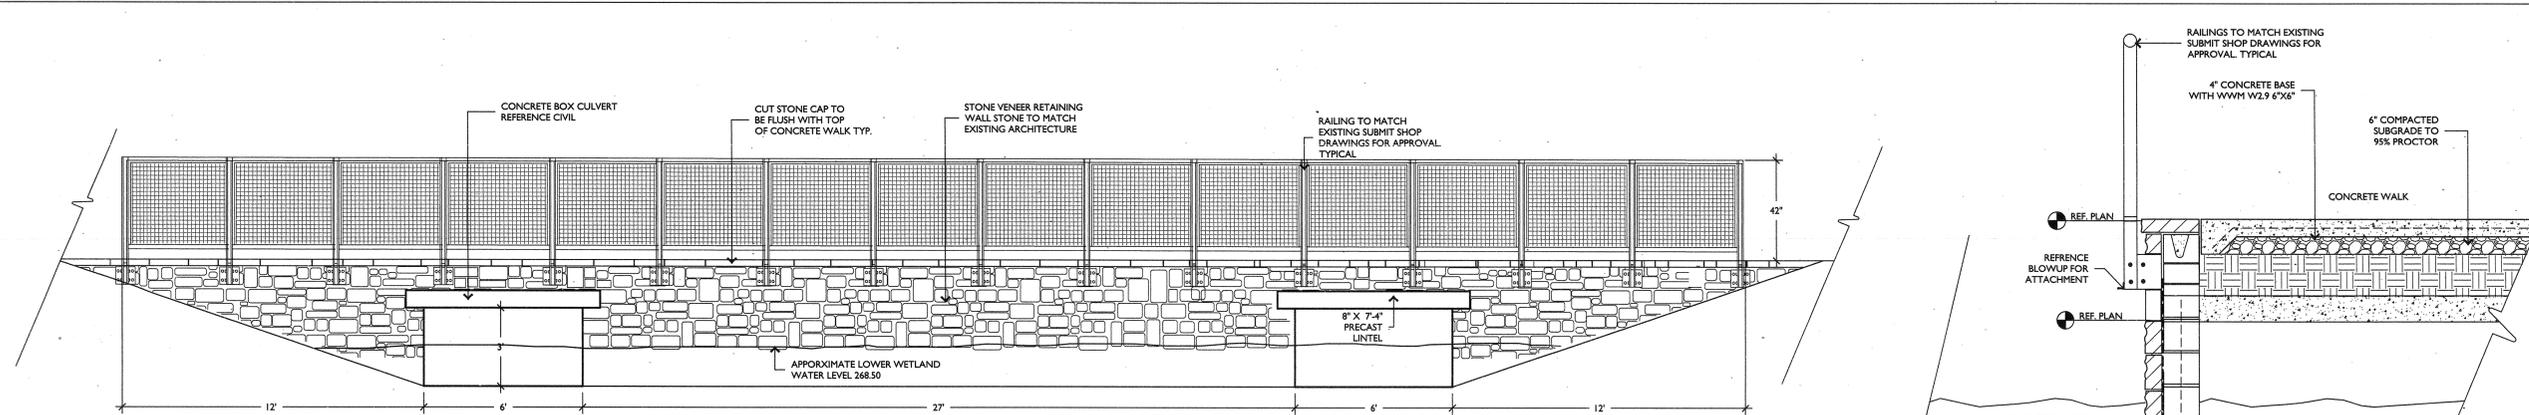


1 THIRD STREET EXTENSION SOUTH ELEVATION OF RETAINING WALL/RAILING AND CONCRETE BOX CULVERTS
ELEVATION SCALE: 3/8"=1'-0"

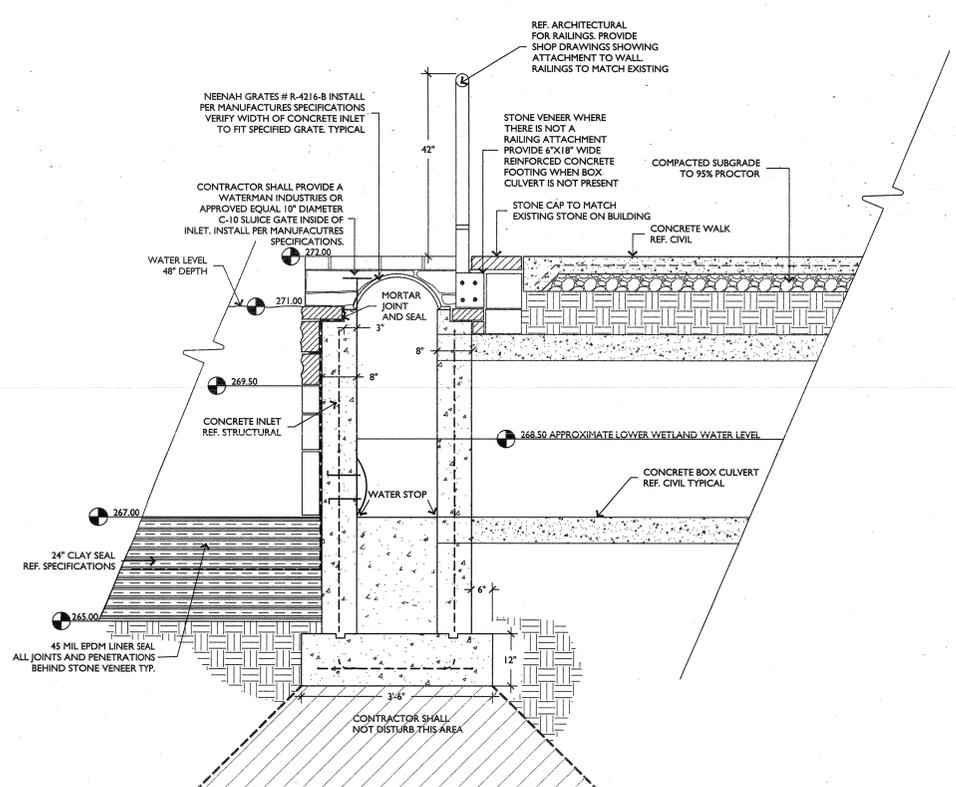


3 NORTH THIRD STREET WETLAND INLET/RAILING AND BOX CULVERT
SECTION SCALE: 3/4"=1'-0"


- SPECIFICATIONS:**
1. THE CRUSHED BRICK SHALL MEET THE FOLLOWING GRADATION:
RETAINED ON A 5/8" SIEVE = 0%
RETAINED ON A 3/8" SIEVE = 12% TO 25%
RETAINED ON A #4 SIEVE = 40% TO 55%
RETAINED ON A #10 SIEVE = 20% TO 35%
 2. THE SUBBASE MATERIAL SHALL BE 4" ROAD BASE

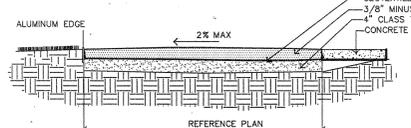


5 CRUSHED BRICK ON BASE
SECTION SCALE: NTS

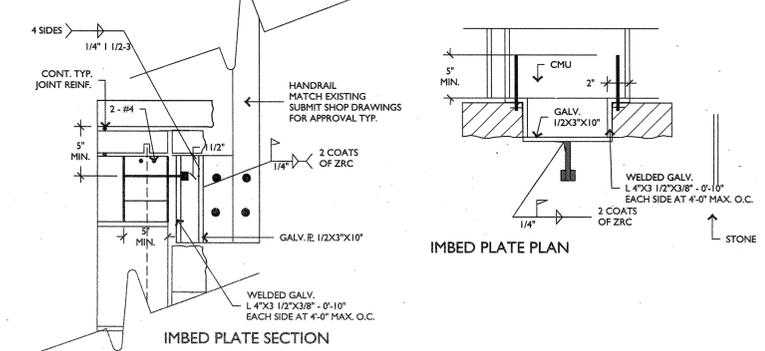


RAILING ATTACHMENT DETAILS
PLAN/SECTION SCALE: NTS

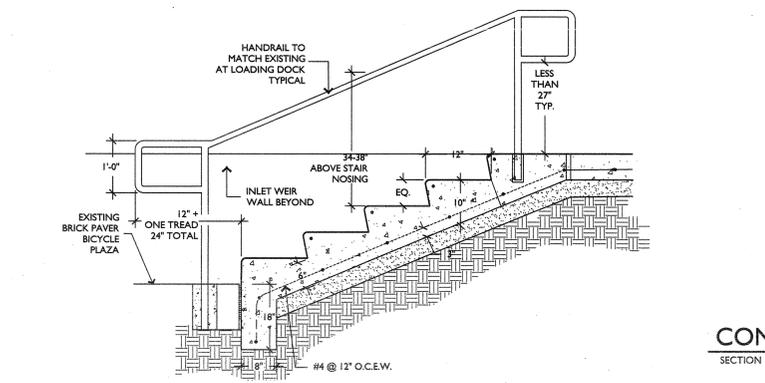


7 CONCRETE STEPS WITH HANDRAIL
SECTION SCALE: NTS

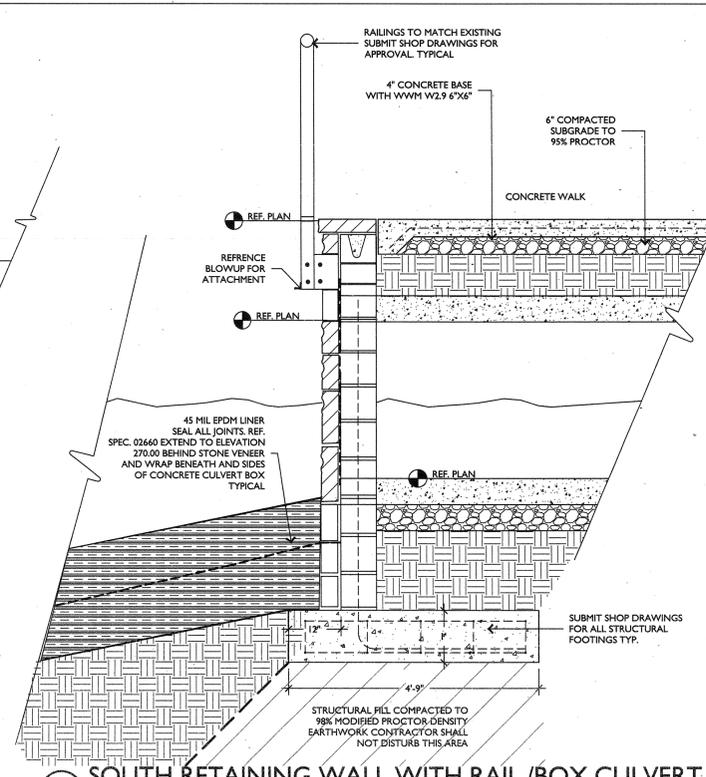


2 SOUTH RETAINING WALL WITH RAIL /BOX CULVERT
SECTION SCALE: 3/4"=1'-0"

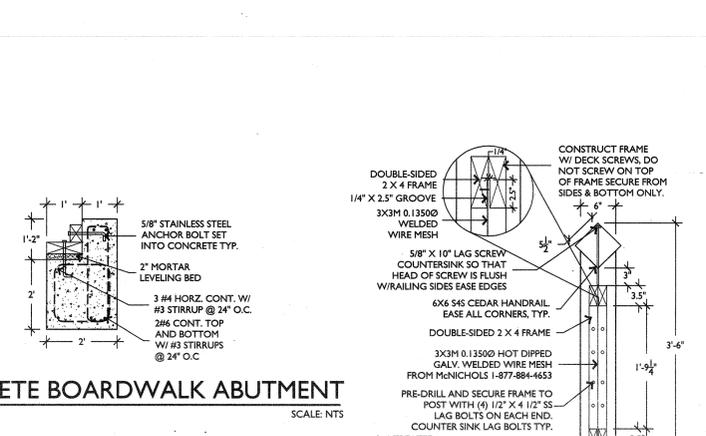

CONCRETE BOARDWALK ABUTMENT
SECTION SCALE: NTS

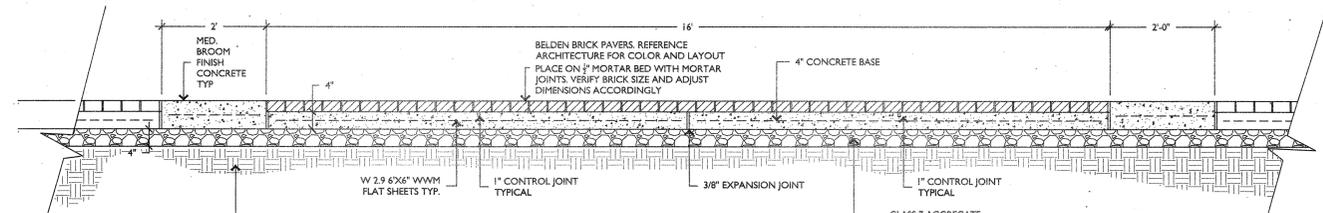

4 CONCRETE BANDS AND BRICK PAVERS ON CONCRETE BASE
SECTION SCALE: NTS

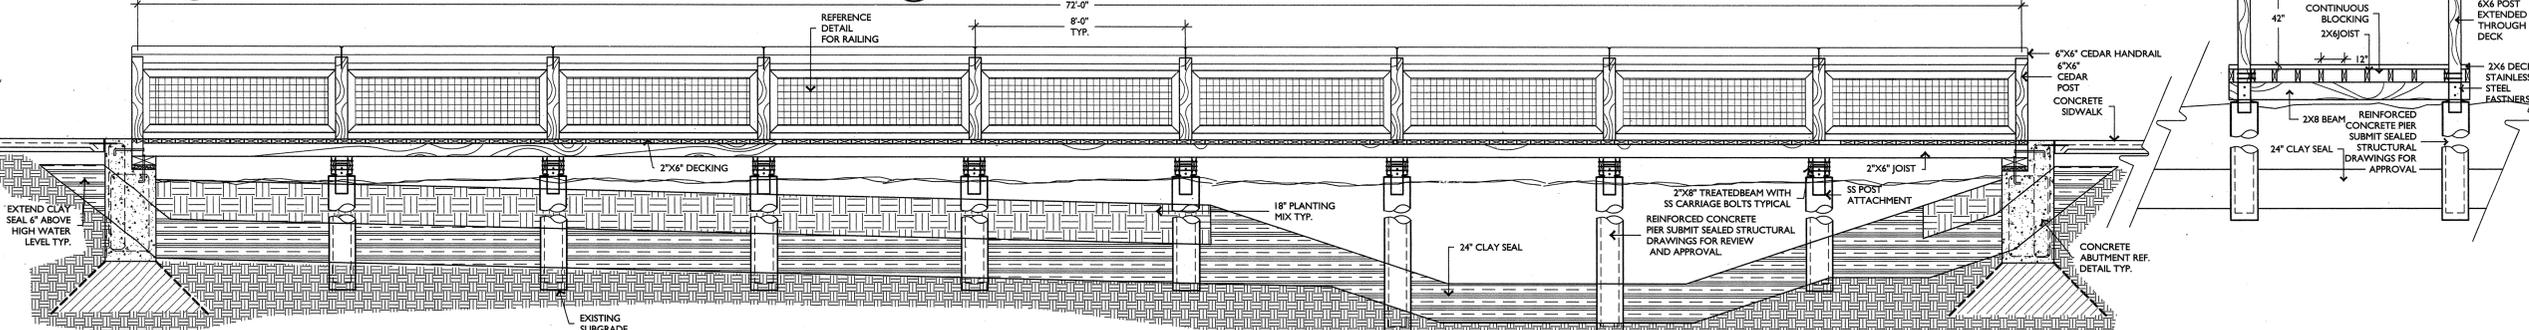

6 NORTH WETLAND SECTION AND BOARDWALK DETAILS
ELEVATION SCALE: 1/2"=1'-0"

700 SOUTH SCHILLER
LITTLE ROCK, AR 72201
501.378.0878 office
501.372.7629 fax

509W. SPRING STREET, SUITE 150
FAYETTEVILLE, AR 72701
479.444.0473 office
479.251.7216 fax

www.polkstanley.com

CONSULTANTS:

CIVIL ENGINEER:
McCLELLAND CONSULTING
ENGINEERS INC.

LANDSCAPE ARCHITECT:
LARSON BURNS AND SMITH, INC.

STRUCTURAL ENGINEER:
CROMWELL ENGINEERS INC.

MECH., ELEC., PLUMB. ENGINEER:
CROMWELL ENGINEERS INC.

GLOBAL VILLAGE CONSULTANT:
CAMBRIDGE SEVEN ASSOCIATES

INTERIOR DESIGNER:
POLK STANLEY ROWLAND
CURZON PORTER ARCHITECTS

GENERAL CONTRACTOR:
CDI CONTRACTORS, INC.

NOTES:

- _____
- _____
- _____
- _____
- _____
- _____
- _____
- _____



ISSUE DATE:
17 SEPTEMBER 2007

REVISIONS:

#	DATE	DESCRIPTION

**MURPHY KELLER
EDUCATION CENTER**

**HEIFER
INTERNATIONAL
CENTER**


LITTLE ROCK, ARKANSAS

PSRCP JOB NUMBER:
431E

CONTENTS:
SITEWORK DETAILS


SHEET NUMBER:

L105

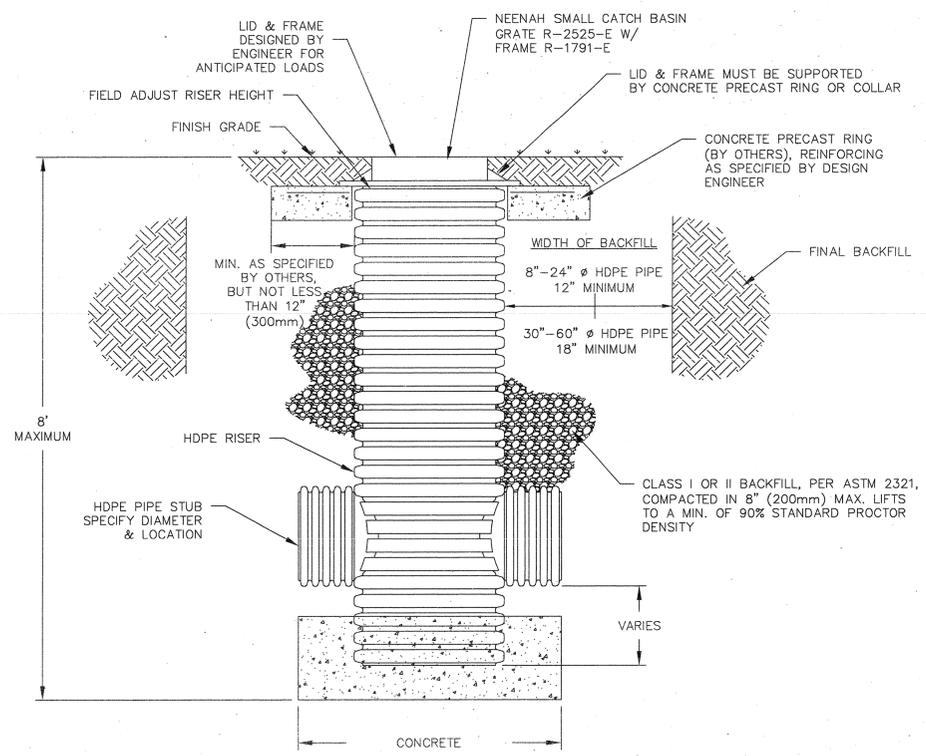

ADS CATCH BASIN


SECTION SCALE: NTS

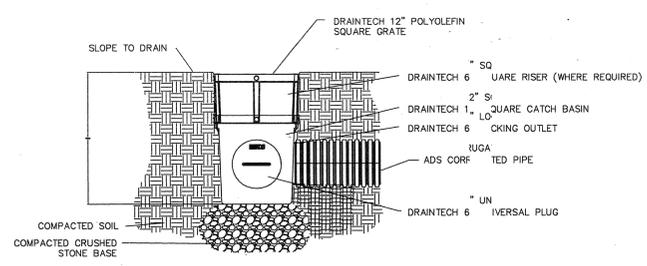

NOTES:
1. MAX. COVER OVER TOP OF PIPE IS 4FT. CONTACT ADS IF OTHERWISE GREATER.
2. GRATE OR LID MUST BE INSTALLED PRIOR TO POURING CONCRETE OR BACKFILLING

ADS AREA DRAINS

SECTION SCALE: NTS

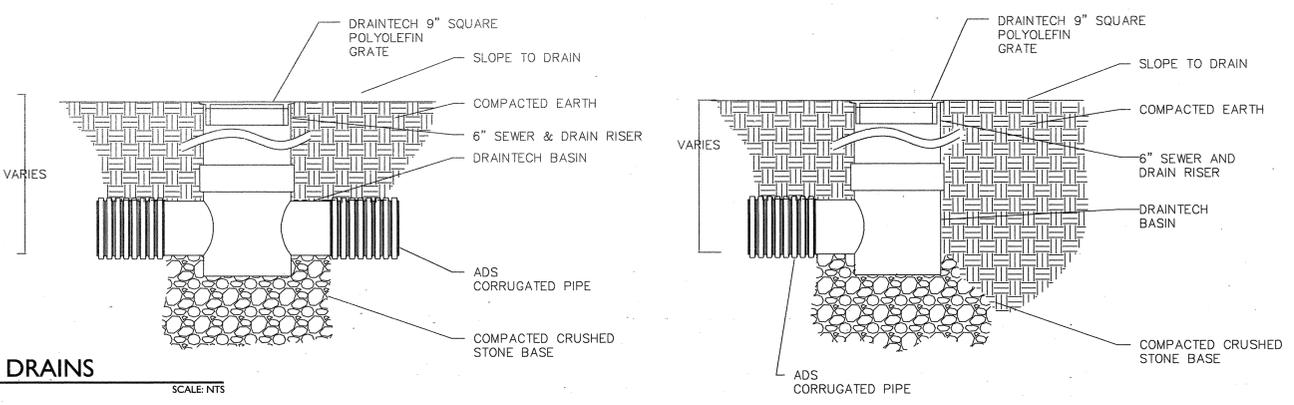






REFERENCE SHEET L103 FOR THIS AREA

THIRD STREET

MATCHLINE

WORLD AVENUE

 1 PARKING LOT PLANTING PLAN
SCALE: 1"=20'-0"

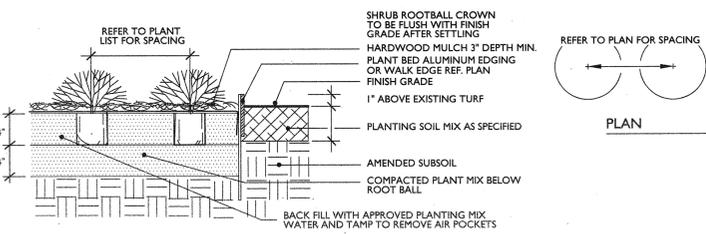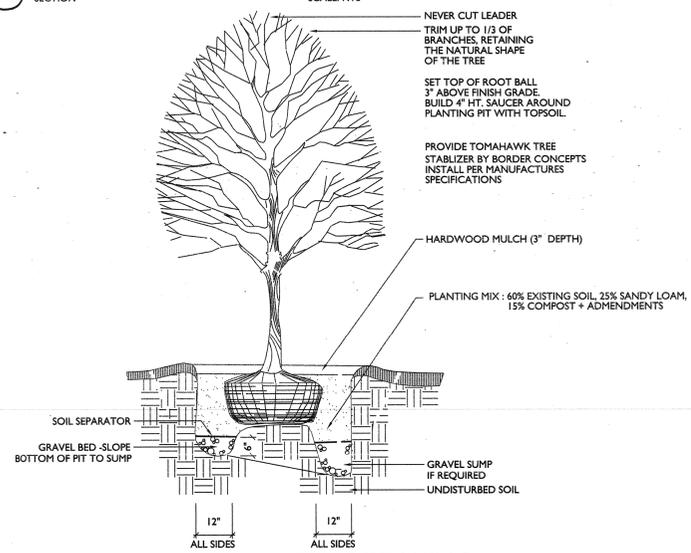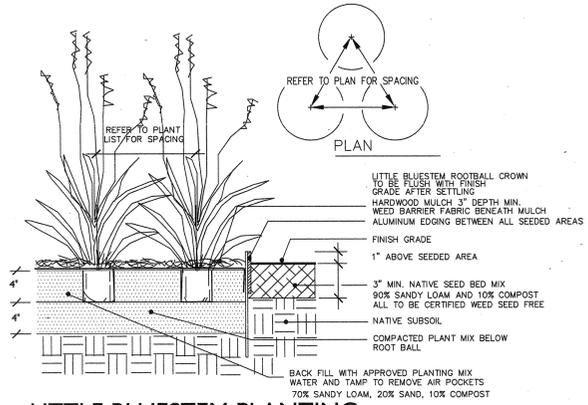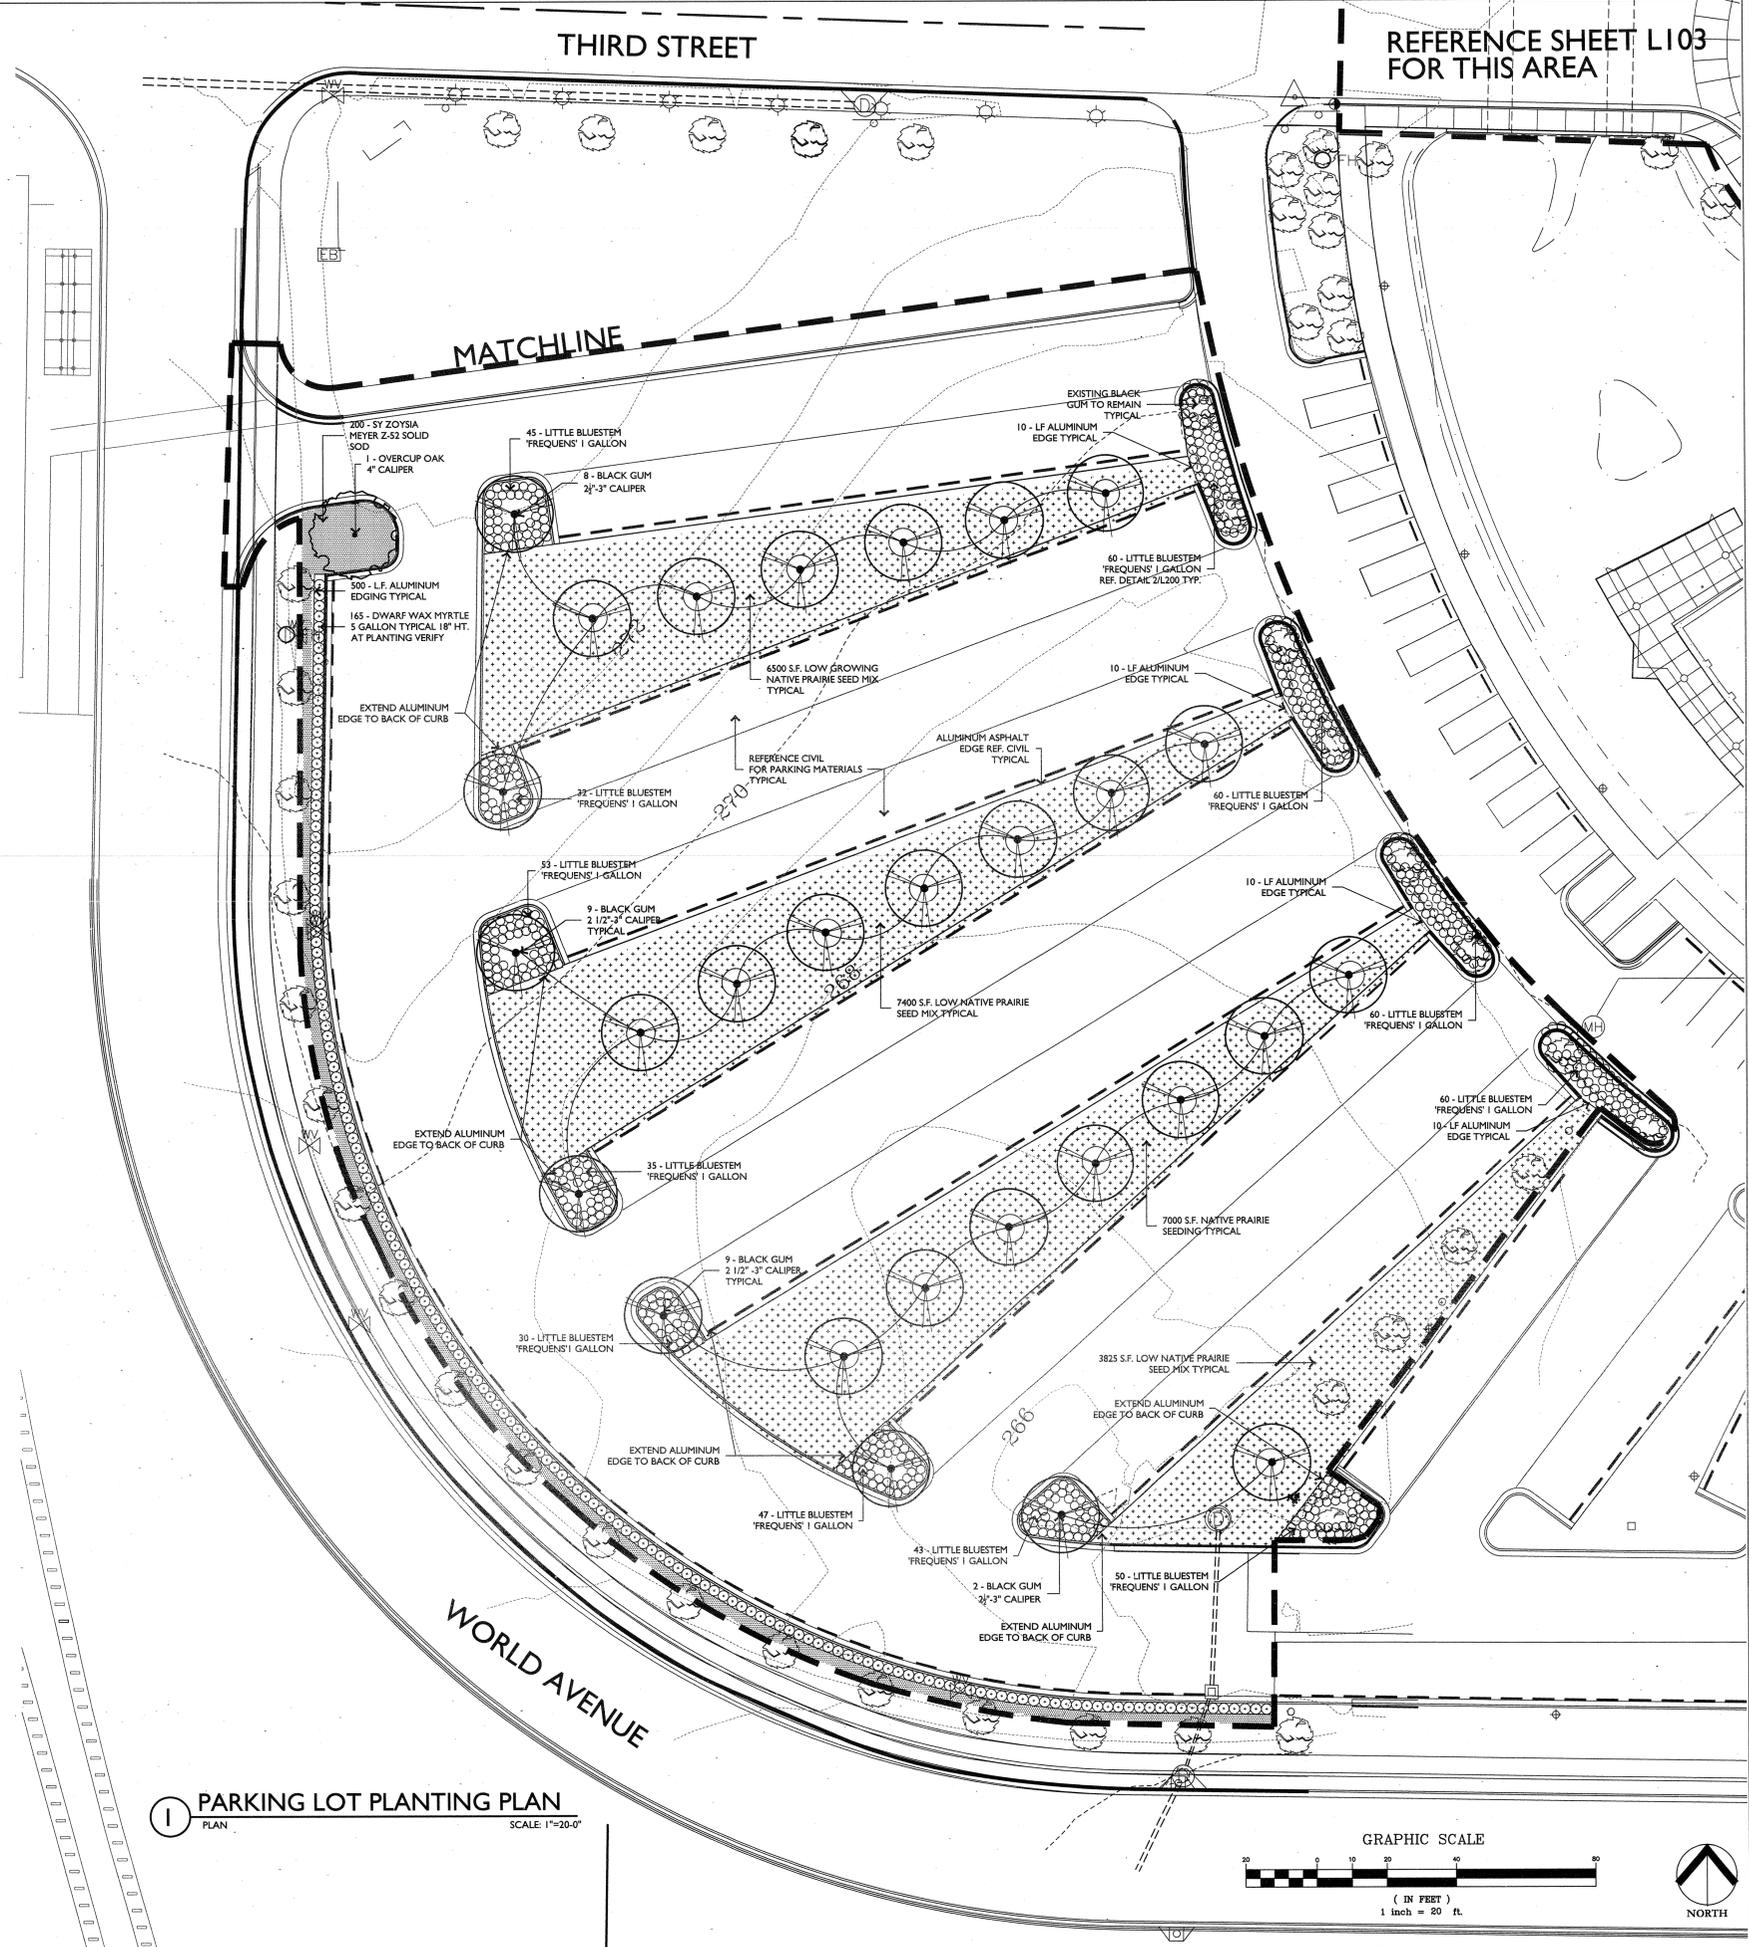

PLANT LIST: VISITOR PARKING LOT All numbers to be verified by landscape contractor

NATIVE TREES				
QTY.	COMMON NAME	SCIENTIFIC NAME	SIZE AND CONDITION	SPACING
1	Overcup Oak	Quercus lyrata 'Highbeam'	2 1/2\"-3\" caliper, 12\"-16\" Ht. 4\"-6\" Spread	As Shown
33	Black Gum	Nyssa sylvatica	2 1/2\"-3\" caliper, 12\"-16\" Ht. 4\"-6\" Spread	As Shown
NATIVE SHRUBS				
QTY.	COMMON NAME	SCIENTIFIC NAME	SIZE AND CONDITION	SPACING
165	Dwarf Wax Myrtle	Myrica cerifera 'Don's Dwarf'	5 gallon, 18\" Ht. 18\" spread	3' O.C.
NATIVE GRASS AND NON NATIVE GRASS				
QTY.	COMMON NAME	SCIENTIFIC NAME	SIZE AND CONDITION	SPACING
575	Little Bluestem	Schizachyrium scoparium 'Frequens'	1 gallon, 8\" Ht., 6\" Spread	2.5' O.C.
200 5Y	Zoysia Meyer Z-52	Solid Sod free of weeds from Quail Valley Farms or Equal		
NATIVE GRASS SEED				
COMMON NAME	SCIENTIFIC NAME	QTY/LBS	SOURCE	
Little Bluestem	Schizachyrium scoparium	5	WILDSEED FARMS 800.848.0078	
Sideoats Grama	Bouteloua curtipendula	5		
Buffalo Grass	Buchloe dactyloides	12	NATIVE AMERICAN SEED 800.728.4043	
Indian Grass	Sorghastrum nutans	2		
NATIVE WILDFLOWER SEED				
COMMON NAME	SCIENTIFIC NAME	QTY/LBS	SOURCE	
Black-eyed Susan	Rudbeckia hirta	2	WILDSEED FARMS 800.848.0078	
Ox-eyed Daisy	Chrysanthemum leucanthemum	2		
Gayfeather	Liatris pycnostachya	10		
Drummond Philox	Phlox drummondii	10	NATIVE AMERICAN SEED 800.728.4043	
Lance-leaved Coreopsis	Coreopsis lanceolata	10		
Lemon Mint	Morandia citriodora	3		
Winged Fringe Mix # 1807		10		
Butterfly Weed	Asclepias tuberosa	5		
Pitcher Sage	Stavia azurea	3		
Pink Evening Primrose	Oenothera speciosa	1		
Miscellaneous				
750 LF.	Aluminum Edging	3/16\"x4\" Mill Finish Available from Permaloc 800-356-9660		

- CONSULTANTS:**
- CIVIL ENGINEER:
MCCLELLAND CONSULTING
ENGINEERS INC.
 - LANDSCAPE ARCHITECT:
LARSON BURNS AND SMITH, INC.
 - STRUCTURAL ENGINEER:
CROMWELL ENGINEERS INC.
 - MECH., ELEC., PLUMB. ENGINEER:
CROMWELL ENGINEERS INC.
 - GLOBAL VILLAGE CONSULTANT:
CAMBRIDGE SEVEN ASSOCIATES
 - INTERIOR DESIGNER:
POLK STANLEY ROWLAND
CURZON PORTER ARCHITECTS
 - GENERAL CONTRACTOR:
CDI CONTRACTORS, INC.

NOTES:



ISSUE DATE:
17 SEPTEMBER 2007

REVISIONS:

#	DATE	DESCRIPTION

**MURPHY KELLER
EDUCATION CENTER**

**HEIFER
INTERNATIONAL
CENTER**

LITTLE ROCK, ARKANSAS

 

PSRCP JOB NUMBER:
431E

CONTENTS:
**COMMONS PLANTING
PLAN**

SHEET NUMBER:
L201

REF. SHEET
L202 FOR
THIS AREA

REF. SHEET
L202 FOR
THIS AREA

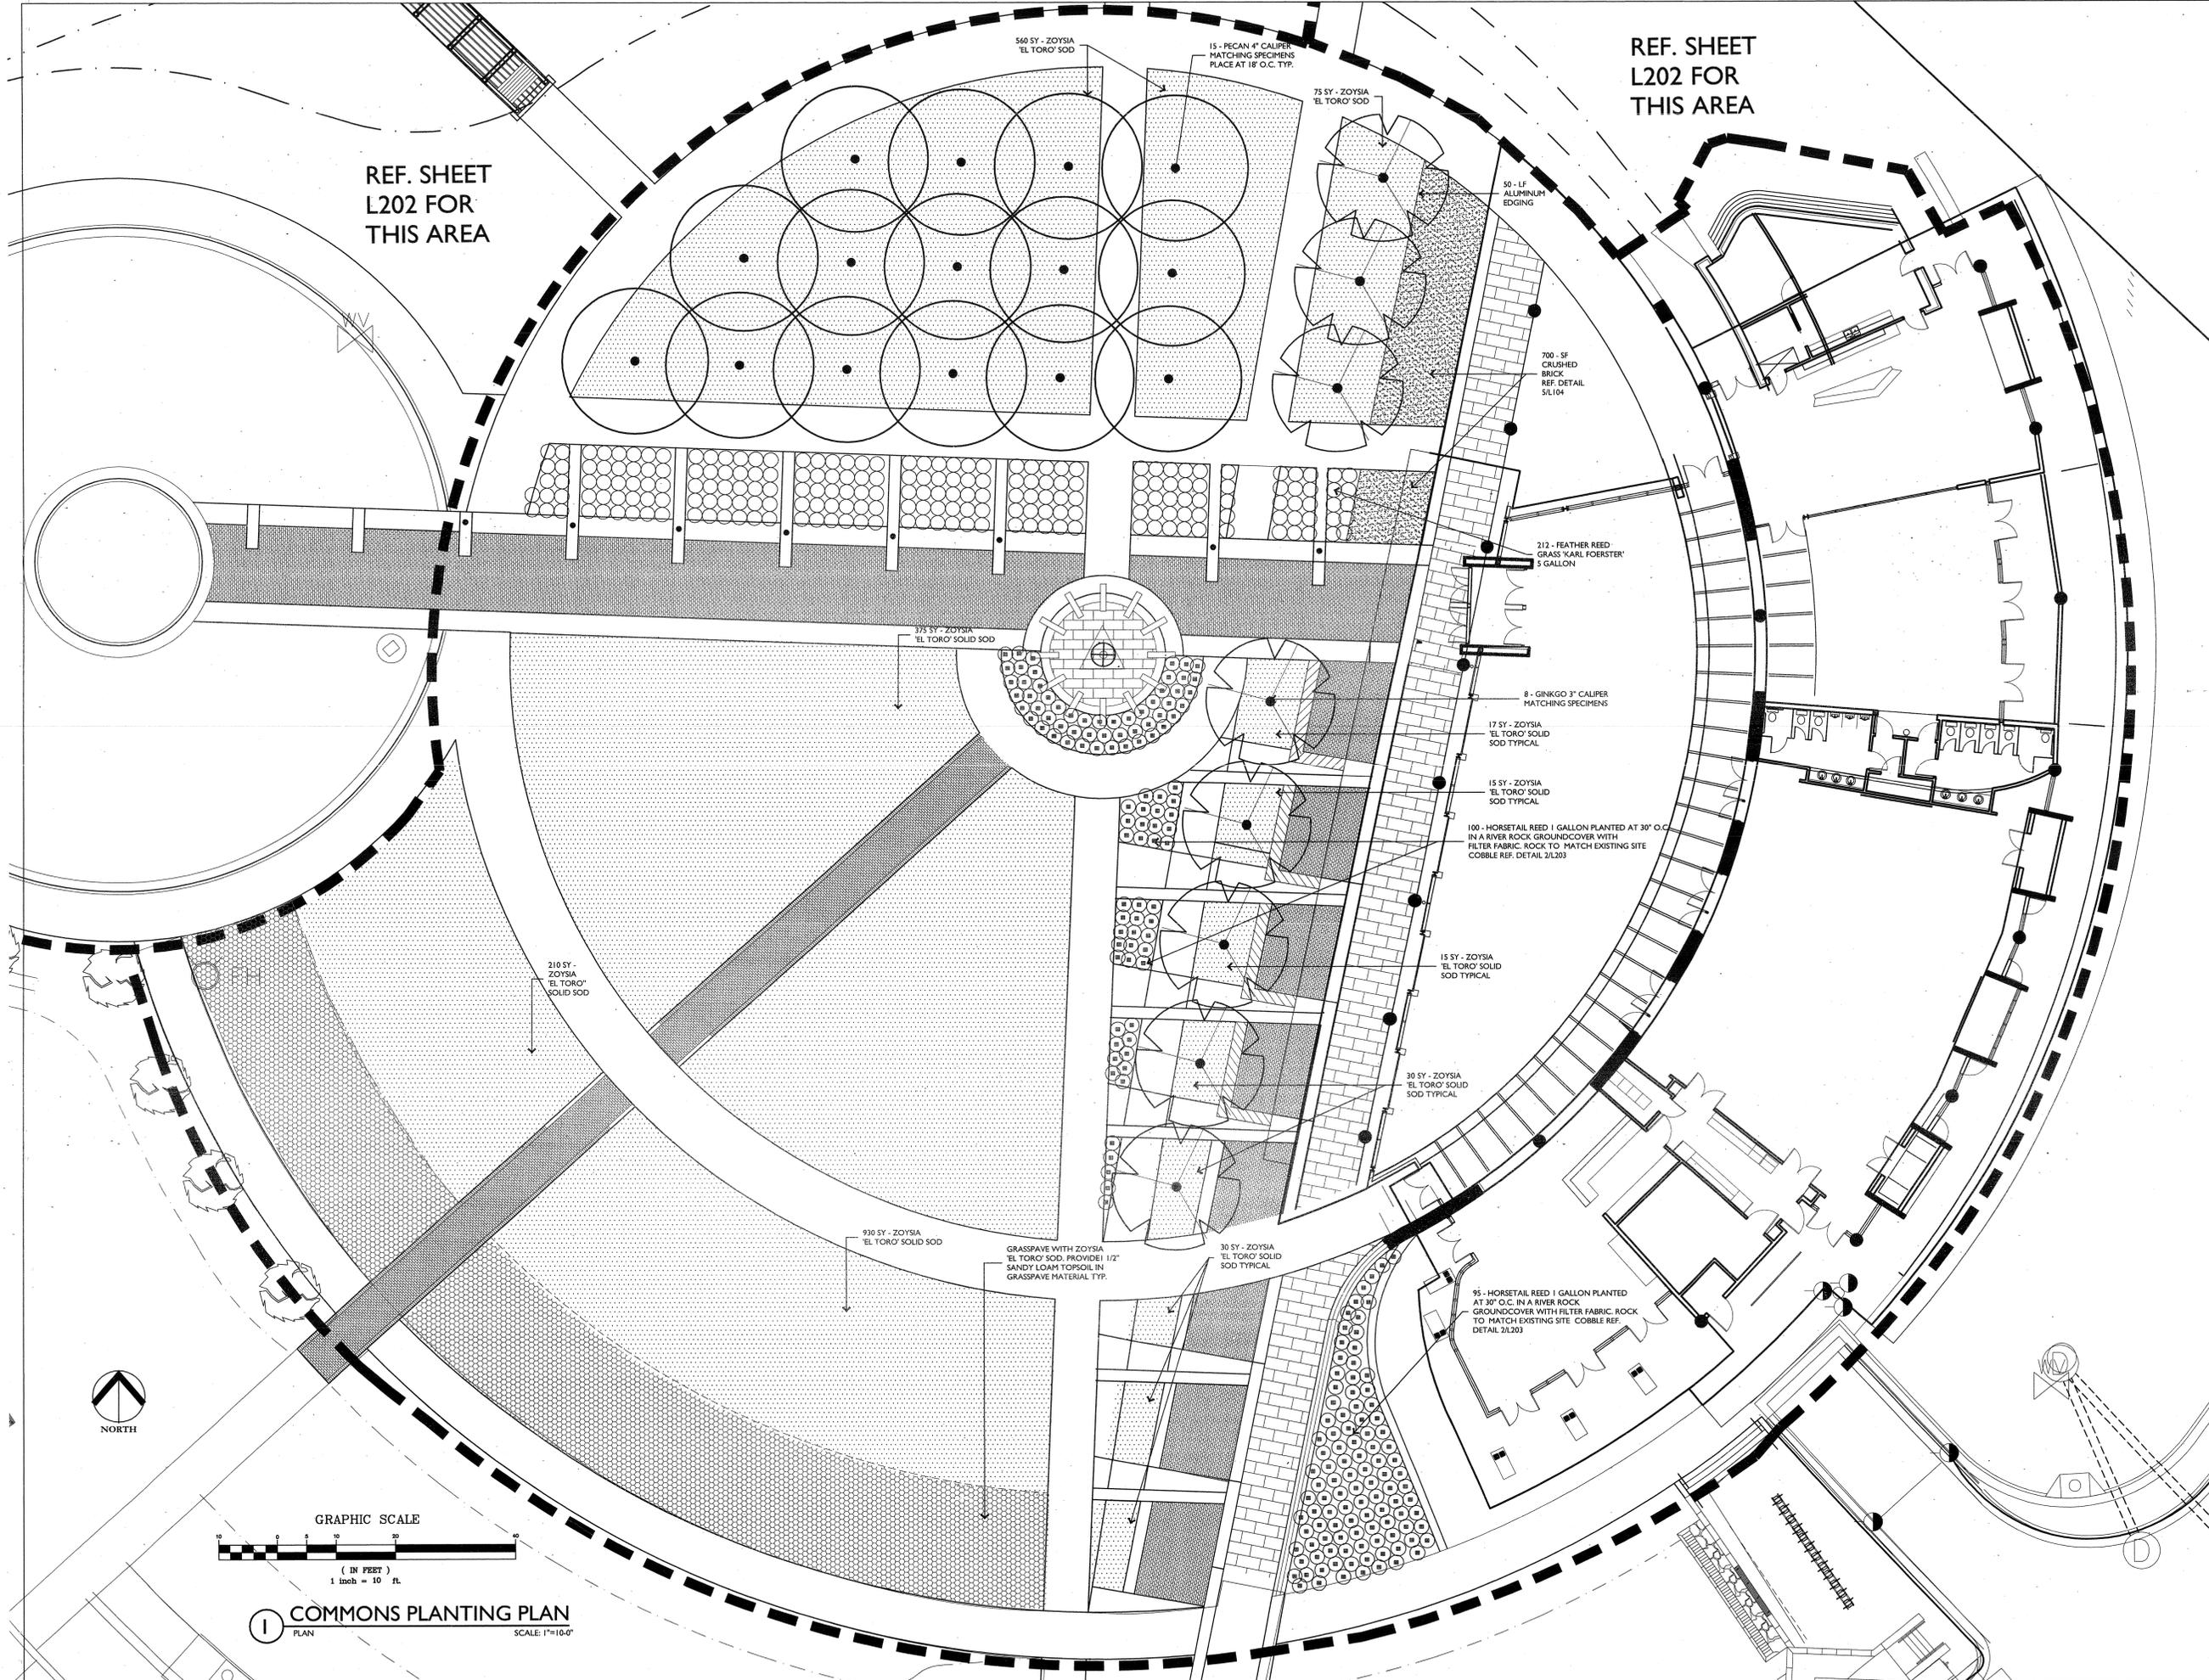

1 COMMONS PLANTING PLAN
SCALE: 1"=10'-0"



FUTURE PHASE

REFERENCE SHEET L201

REF. SHEET L201 FOR THIS AREA

NORTH WETLANDS PLANTING PLAN
SCALE: 1"=10'-0"

POLK STANLEY ROWLAND CURZON PORTER ARCHITECTS, LTD.

700 SOUTH SCHILLER
LITTLE ROCK, AR 72201
501.378.0878 office
501.372.7629 fax

509W. SPRING STREET, SUITE 150
FAYETTEVILLE, AR 72701
479.444.0473 office
479.251.7216 fax

www.polkstanley.com

CONSULTANTS:

CIVIL ENGINEER:
McCLELLAND CONSULTING ENGINEERS INC.

LANDSCAPE ARCHITECT:
LARSON BURNS AND SMITH, INC.

STRUCTURAL ENGINEER:
CROMWELL ENGINEERS INC.

MECH., ELEC., PLUMB. ENGINEER:
CROMWELL ENGINEERS INC.

GLOBAL VILLAGE CONSULTANT:
CAMBRIDGE SEVEN ASSOCIATES

INTERIOR DESIGNER:
POLK STANLEY ROWLAND CURZON PORTER ARCHITECTS

GENERAL CONTRACTOR:
CDI CONTRACTORS, INC.

NOTES:



ISSUE DATE:
17 SEPTEMBER 2007

REVISIONS:

#	DATE	DESCRIPTION

MURPHY KELLER EDUCATION CENTER


HEIFER INTERNATIONAL CENTER


LITTLE ROCK, ARKANSAS

PSRCP JOB NUMBER:
431E


CONTENTS:
NORTH WETLANDS PLANTING PLAN

SHEET NUMBER:
L202

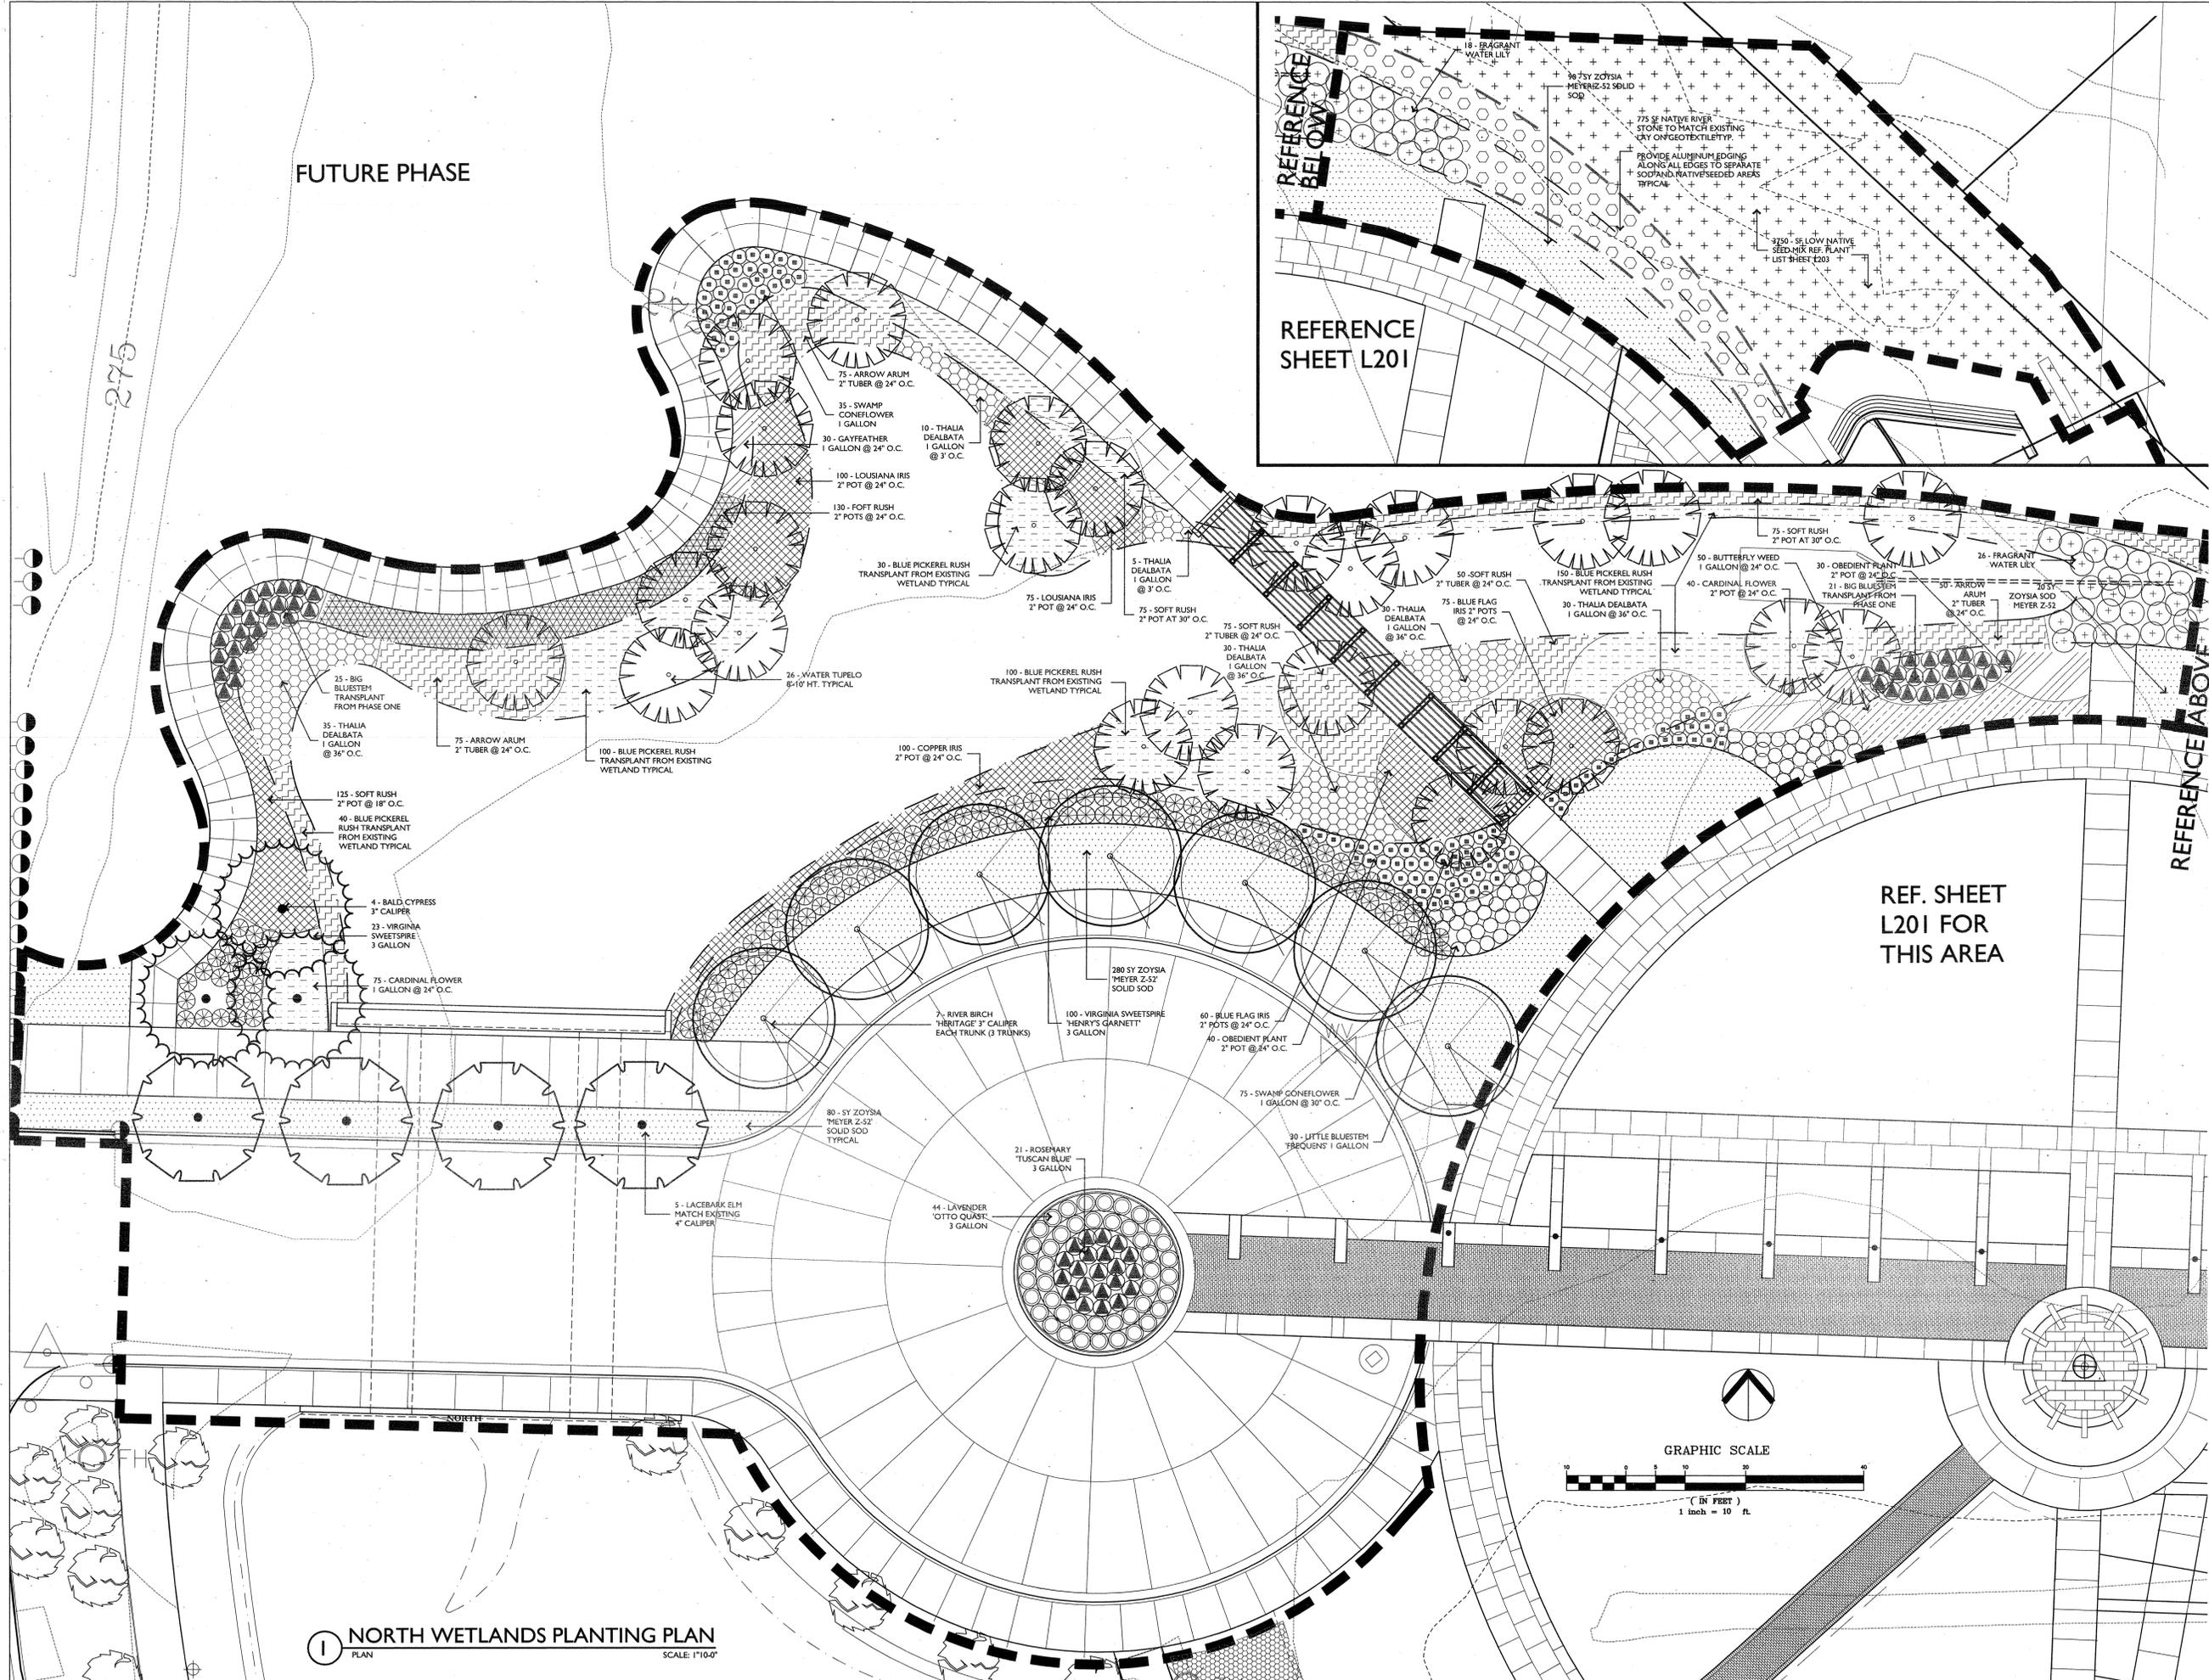


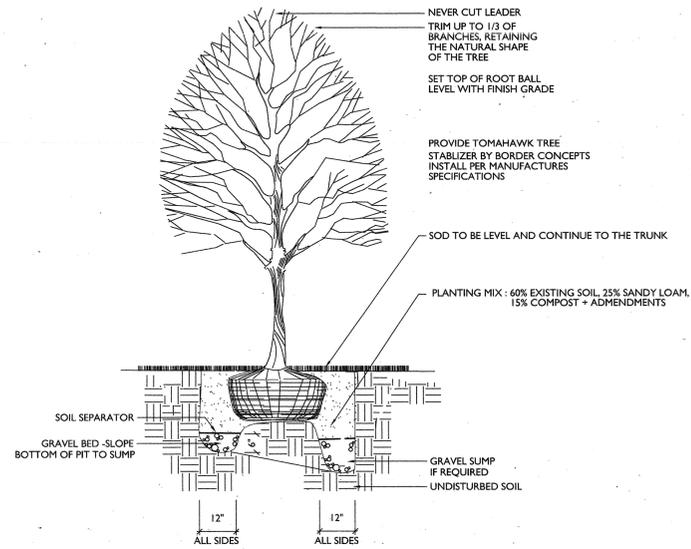


1 CANOPY TREE PLANTING/STAKING IN SODDED AREAS NTS

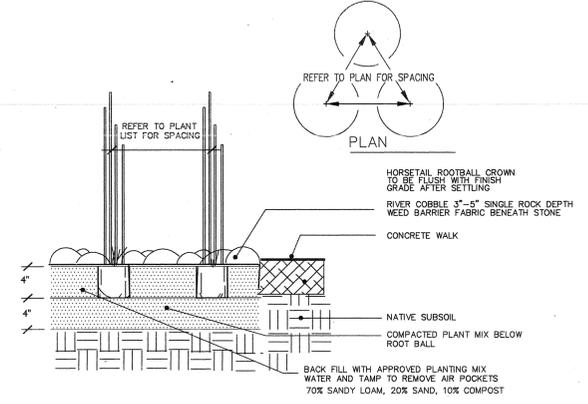

2 HORSETAIL REED AND COBBLE STONE PLANTING DETAIL SCALE: NTS

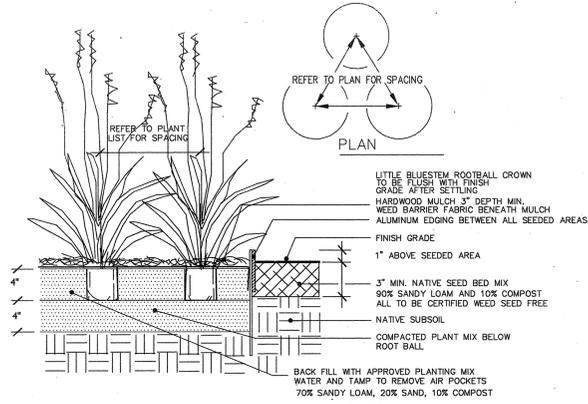

3 NATIVE GRASSES AND PERENNIALS PLANTING SCALE: NTS

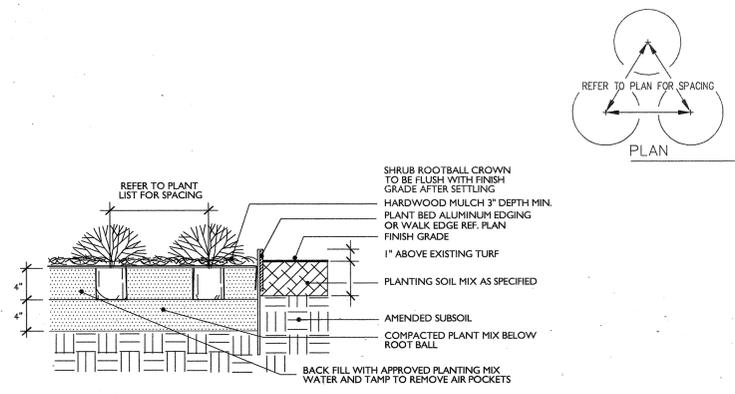

4 NATIVE SHRUB PLANTING NTS

PLANT LIST

All numbers to be verified by landscape contractor

TREES				
QTY.	COMMON NAME	SCIENTIFIC NAME	SIZE AND CONDITION	SPACING
6	Pond Cypress	Taxodium ascendens	3" caliper, 14' Ht., 3'-4" Spread, Standard trunk w/ branches trimmed up 6' Matching Specimens From Deep Fork Tree Farm 405-233-2000	As Shown
7	River Birch	Betula nigra 'Heritage'	Multi-trunk, 16'-18' Ht., 4'-6' Spread, 3'-3" cal. trunks w/ branches trimmed up 6'	As Shown
6	Sweetbay Magnolia	Magnolia virginiana 'Australis'	3" caliper, 14' Ht., 4'-5' Spread Standard trunk w/ branches trimmed up 6'	As Shown
26	Aquatic Tupelo	Nyssa aquatica	8'-10' Ht. Single Straight Trunk- Container Grown	As Shown
5	Allee Lacebark Elm	Ulmus parvifolia 'Emer II'	4" caliper, 16' Ht., 6'-8" Spread Standard trunk w/ branches trimmed up 6' Matching Specimens	As Shown
15	Pecan	Carya illinoensis	4" caliper, 16' Ht., 4'-6" Spread, Standard trunk w/ branches trimmed up 6' Matching Specimens	
8	Ginkgo	Ginkgo biloba 'Autumn Gold'	3" caliper, 14' Ht., 4'-6' Spread, Standard trunk w/ branches trimmed up 6'	

All numbers to be verified by landscape contractor

SHRUBS - AQUATICS - GRASSES				
QTY.	COMMON NAME	SCIENTIFIC NAME	SIZE AND CONDITION	SPACING
123	Virginia Sweetspire	Itea virginica 'Henry's Garnet'	3 gallon, 18" Ht. 16" spread	3' O.C.
135	Blue Flag Iris	Iris virginica	5 gallon, 24" Ht. 18" spread	24" O.C.
100	Copper Iris	Iris fulva	1 gallon, 8" Ht. 8" spread	24" O.C.
175	Louiana Iris	Iris giganticaerulea	2" plug	24" O.C.
200	Arrow Arum	Peltandra virginica	2" plug	24" O.C.
46	Big Bluestem	Andropogon gerardii	transplant from existing site consult with landscape architect	36" O.C.
530	Soft Rush	Juncus effusus	2" plug	24" O.C.
140	Thalia dealbata	Thalia dealbata	1 gallon	36" O.C.
150	Blue Pickerel Rush	Potamogeton nodosus	transplant from existing wetland consult with landscape architect	24" O.C.
110	Swamp Coneflower	Rudbeckia maxima	1 gallon	30" O.C.
115	Cardinal Flower	Lobelia cardinalis	1 gallon	24" O.C.
30	Gayfeather	Liatris spicata	1 gallon	24" O.C.
50	Butterfly Weed	Asclepias tuberosa	1 gallon	24" O.C.
61	Little Bluestem	Schizachyrium scoparium 'Frequens'	1 gallon	30" O.C.
70	Obedient Plant	Physostegia virginiana	2" pot	24" O.C.
21	Rosemary	Rosmarinus officinalis 'Tuscan Blue'	3 gallon	Ref. Plan
44	Lavender	Lavandula stoechas 'Otto Quast'	3 gallon	Ref. Plan
235	Feather Reed Grass	Calamagrostis x acutiflora 'Karl Foerster'	5 gallon	Ref. Plan
195	Horsetail Reed	Equisetum hyemale	1 gallon	Ref. Plan
42	Fragrant Water Lily	Nymphaea odorata	1 gallon	Ref. Plan

NATIVE GRASS SEED

COMMON NAME	SCIENTIFIC NAME	QTY/LBS	SOURCE
Little Bluestem	Schizachyrium scoparium	1	WILDSEED FARMS 800-848-0078
Sideoats Grama	Bouteloua curtipendula	1	WILDSEED FARMS 800-848-0078
Buffalo Grass	Buchloe dactyloides	2	NATIVE AMERICAN SEED 800-728-4043
Indian Grass	Sorghastrum nutans	.5	800-728-4043

NATIVE WILDFLOWER SEED

COMMON NAME	SCIENTIFIC NAME	QTY/LBS	SOURCE
Black-Eyed Susan	Rudbeckia hirta	1	WILDSEED FARMS 800-848-0078
Ox-eyed Daisy	Chrysanthemum leucanthemum	1	WILDSEED FARMS 800-848-0078
Gayfeather	Liatris pycnostachya	2	NATIVE AMERICAN SEED 800-728-4043
Drummond Phlox	Phlox drummondii	2	NATIVE AMERICAN SEED 800-728-4043
Lance-leaved Coreopsis	Coreopsis lanceolata	2	NATIVE AMERICAN SEED 800-728-4043
Lemon Mint	Monarda citriodora	1	800-728-4043
Wetland Fringe Mix	# 1807	1	
Butterfly Weed	Asclepias tuberosa	.5	
Pitcher Sage	Stavia aurea	.5	
Pink Evening Primrose	Oenothera speciosa	.5	

Miscellaneous

Ref. Plan	Aluminum Edging	3/16"x4" mill finish - Available from Permaloc 800-356-9660
375 SY	ZOYSIA MEYER Z-52 SOLID SOD	- Weed Free from Quail Valley Farms or equal
2275	ZOYSIA 'EL TORO' SOLID SOD	- Weed Free from Quail Valley Farms or equal
775 SF Verdy	Native River Cobble	to match existing site wetland stone - submit samples of all sizes for approval.
700 SF Verdy	Crushed Brick 3/8"	minus apply Soil Stabilizer as recommended by the manufacturer. Submit samples of crushed brick

POLK STANLEY ROWLAND CURZON PORTER ARCHITECTS, LTD.

700 SOUTH SCHILLER
LITTLE ROCK, AR 72201
501.378.0878 office
501.372.7629 fax

509W. SPRING STREET, SUITE 150
FAYETTEVILLE, AR 72701
479.444.0473 office
479.251.7216 fax

www.polkstanley.com

CONSULTANTS:

CIVIL ENGINEER:
McCLELLAND CONSULTING ENGINEERS INC.

LANDSCAPE ARCHITECT:
LARSON BURNS AND SMITH, INC.

STRUCTURAL ENGINEER:
CROMWELL ENGINEERS INC.

MECH., ELEC., PLUMB. ENGINEER:
CROMWELL ENGINEERS INC.

GLOBAL VILLAGE CONSULTANT:
CAMBRIDGE SEVEN ASSOCIATES

INTERIOR DESIGNER:
POLK STANLEY ROWLAND CURZON PORTER ARCHITECTS

GENERAL CONTRACTOR:
CDI CONTRACTORS, INC.

NOTES:



ISSUE DATE:
17 SEPTEMBER 2007

REVISIONS:

#	DATE	DESCRIPTION

MURPHY KELLER EDUCATION CENTER

HEIFER INTERNATIONAL CENTER

LITTLE ROCK, ARKANSAS
PSRCP JOB NUMBER:
431E

CONTENTS:
NORTH WETLANDS AND COMMONS PLANTING LIST AND DETAILS

SHEET NUMBER:
L203

CONSULTANTS:

CIVIL ENGINEER:
McCLELLAND CONSULTING
ENGINEERS INC.

LANDSCAPE ARCHITECT:
LARSON BURNS AND SMITH, INC.

STRUCTURAL ENGINEER:
CROMWELL ENGINEERS INC.

MECH. ELEC., PLUMB. ENGINEER:
CROMWELL ENGINEERS INC.

GLOBAL VILLAGE CONSULTANT:
CAMBRIDGE SEVEN ASSOCIATES

INTERIOR DESIGNER:
POLK STANLEY ROWLAND
CURZON PORTER ARCHITECTS

GENERAL CONTRACTOR:
CDI CONTRACTORS, INC.

NOTES:

ISSUE DATE:
17 SEPTEMBER 2007

REVISIONS:

#	DATE	DESCRIPTION

**MURPHY KELLER
EDUCATION CENTER**


**HEIFER
INTERNATIONAL
CENTER**

LITTLE ROCK, ARKANSAS

PSRCP JOB NUMBER:
431E

CONTENTS:
**PARKING LOT
IRRIGATION PLAN**

SHEET NUMBER:
L300

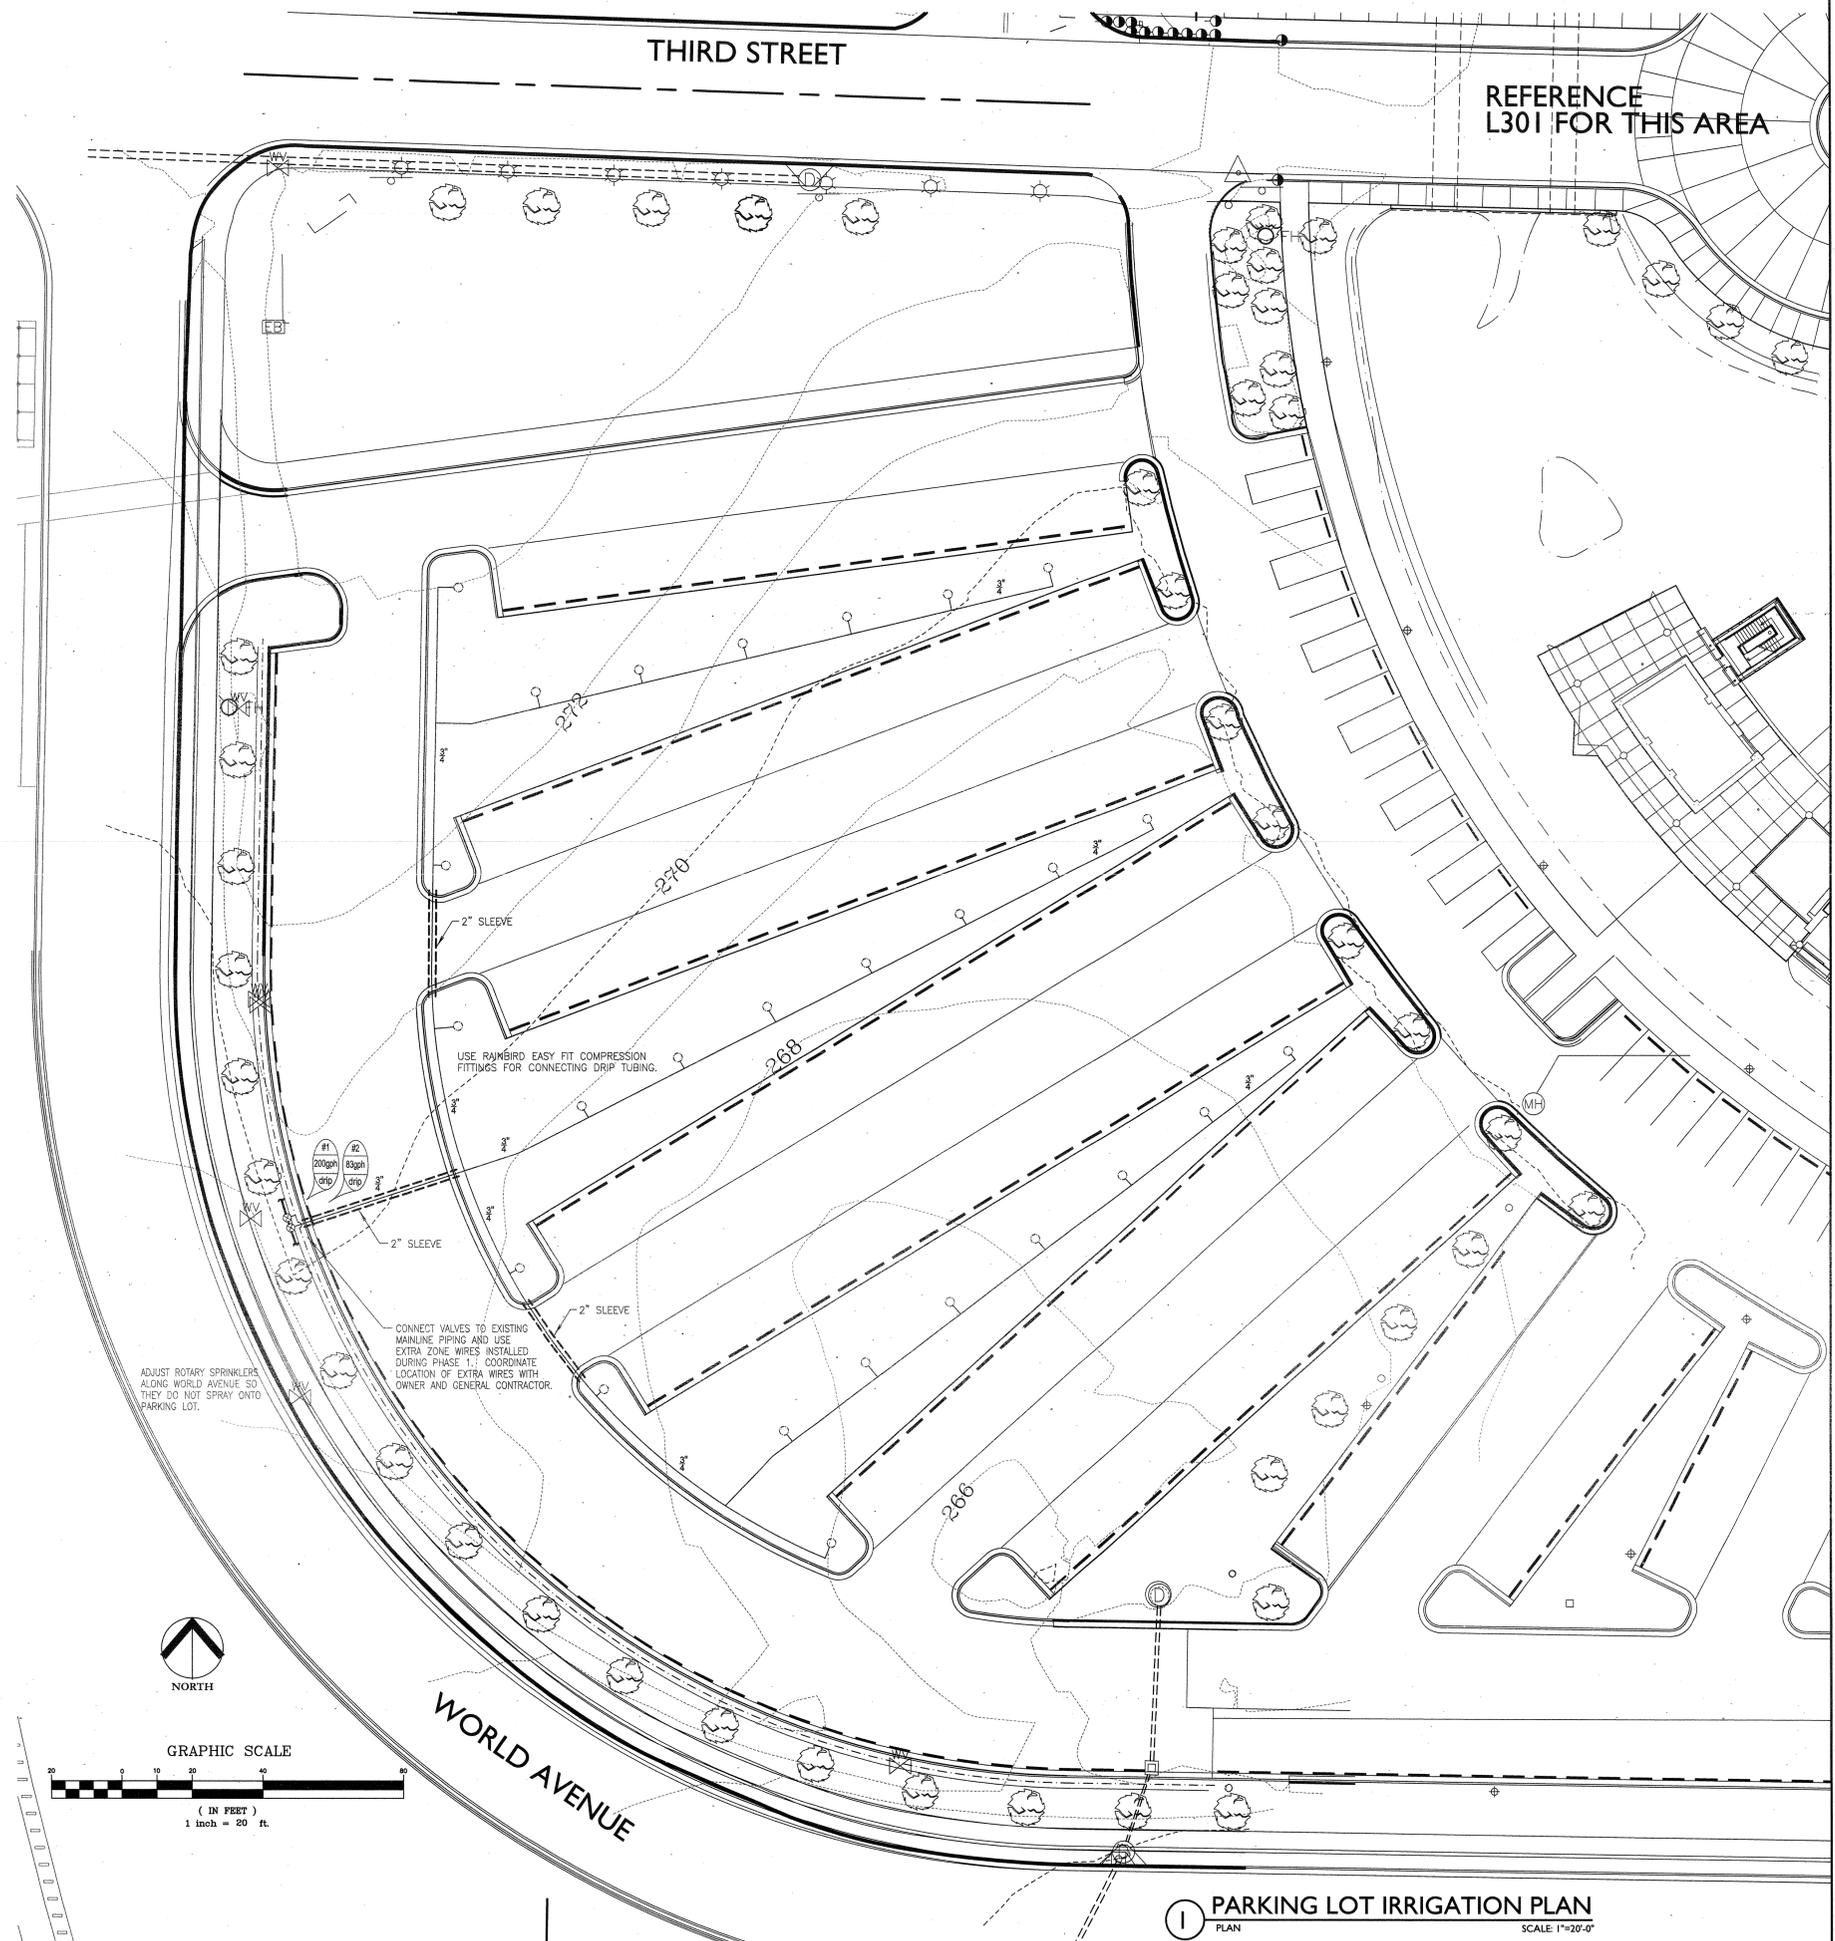

IRRIGATION LEGEND

 
- ⊗ RAINBIRD XCZ-10000M 1" DRIP ZONE VALVE ASSY.
- SCH40 PVC MAINLINE PIPING
- CLASS 200 PVC LATERAL PIPING
- - - POLYETHYLENE DRIP TUBING (RAINBIRD LD-06-18)
- - - SLEEVING (2" - 4" = SCH40 PVC)

GENERAL NOTES

1. IRRIGATION CONTRACTOR SHALL INSTALL ALL EQUIPMENT AS PER MANUFACTURER'S CURRENT SPECIFICATIONS AND RECOMMENDATIONS.
2. COORDINATE EXACT LOCATION OF POINT-OF-CONNECTION WITH THE ARCHITECT AND GENERAL CONTRACTOR.
3. COORDINATE EXACT LOCATION OF EXTRA VALVE WIRES INSTALLED DURING PHASE 1 WITH THE OWNER AND GENERAL CONTRACTOR.
4. WHEN TRENCHING UNDER THE DRIPLINE OF EXISTING TREES EXTREME CARE MUST BE GIVEN TO AVOID ROOT DAMAGE. IF AT ALL POSSIBLE AVOID TRENCHING INSIDE THE DRIPLINE BY GOING AROUND THE TREE RATHER THAN UNDER IT. IF TRENCHING MUST OCCUR UNDER THE DRIPLINE, USE EITHER TUNNELING OR HAND-DIGGING METHODS RATHER THAN A MECHANICAL TRENCHER. MINIMIZE THE IMPACT OF ROOT SEVERING BY AVOIDING CONSTRUCTION DURING HOT, DRY WEATHER, KEEPING TREES WELL WATERED BEFORE AND AFTER DIGGING AND COVERING ROOTS WITH SOIL OR MULCH AS SOON AS POSSIBLE.
5. IRRIGATION CONTRACTOR SHALL BE RESPONSIBLE FOR DAMAGES CAUSED TO ALL UTILITIES (BOTH OVERHEAD AND BELOW GROUND) DURING THE IRRIGATION INSTALLATION. IRRIGATION CONTRACTOR SHALL SEEK THE ASSISTANCE OF LOCAL UTILITIES AND THE OWNER IN THE LOCATION OF THE UTILITIES PRIOR TO PERFORMING TRENCHING OPERATIONS IN THE WORK AREA.
6. THE IRRIGATION DESIGN IS DIAGRAMMATIC. THE INTENT OF THE DRAWINGS IS TO SHOW THE GENERAL LAYOUT AND LOGIC OF THE SYSTEM. SCALED MEASUREMENTS MAY NOT BE ACCURATE. ACTUAL LOCATIONS AND QUANTITIES OF PIPE AND FITTINGS MAY VARY DUE TO FIELD ADJUSTMENTS FOR EXISTING CONDITIONS AND OTHER OBSTRUCTIONS TO PROVIDE THE PROPER AND INTENDED COVERAGE.
7. ALL MAINLINE SHALL BE SCH40 PVC. ALL LATERAL PIPING SHALL BE CLASS 200 PVC PIPING. ALL PVC FITTINGS SHALL BE PVC TYPE 1 AND MUST BE OF DOMESTIC MANUFACTURE. PVC SOLVENT CEMENT AND PRIMER SHALL BE AS RECOMMENDED / APPROVED BY THE MANUFACTURER OF THE PIPE.

SLEEVING NOTES

1. ALL SLEEVING SHALL BE PROVIDED BY THE GENERAL CONTRACTOR.
2. ALL SLEEVING PROVIDED FOR THE IRRIGATION SYSTEM TO BE SIZED AS NOTED ON THE PLAN.
3. ALL SLEEVING TO BE BURIED A MIN. OF 18" AND A MAX. OF 24" BELOW THE FINISHED GRADE. ENDS OF SLEEVES SHALL EXTEND 12" PAST THE EDGES OF ALL PAVING AND CURBS AND BE CLEARLY MARKED FOR FUTURE USE BY THE SPRINKLER SYSTEM CONTRACTOR.



CONSULTANTS:

CIVIL ENGINEER:
McCLELLAND CONSULTING
ENGINEERS INC.

LANDSCAPE ARCHITECT:
LARSON BURNS AND SMITH, INC.

STRUCTURAL ENGINEER:
CROMWELL ENGINEERS INC.

MECH., ELEC., PLUMB. ENGINEER:
CROMWELL ENGINEERS INC.

GLOBAL VILLAGE CONSULTANT:
CAMBRIDGE SEVEN ASSOCIATES

INTERIOR DESIGNER:
POLK STANLEY ROWLAND
CURZON PORTER ARCHITECTS

GENERAL CONTRACTOR:
CDI CONTRACTORS, INC.

NOTES:

- _____
- _____
- _____
- _____
- _____
- _____
- _____
- _____

ISSUE DATE:
17 SEPTEMBER 2007

REVISIONS:

#	DATE	DESCRIPTION

**MURPHY KELLER
EDUCATION CENTER**

**HEIFER
INTERNATIONAL
CENTER**

LITTLE ROCK, ARKANSAS

PSRCP JOB NUMBER:
431E

CONTENTS:
COMMONS AND THIRD
STREET EXTENSION
IRRIGATION PLAN
SHEET NUMBER:

L301

QUANTITIES ARE SHOWN FOR CONVENIENCE ONLY. IT SHALL BE THE IRRIGATION CONTRACTOR'S RESPONSIBILITY TO CALCULATE ALL MATERIALS NECESSARY FOR A COMPLETE IRRIGATION SYSTEM.

IRRIGATION LEGEND

- 2 ⊙ RAINBIRD XCZ-100COM 1" DRIP ZONE VALVE ASSY.
- 10 ⊙ RAINBIRD 100PEB 1" ZONE VALVE W/FLO CONTROL
- 1 ⊙ RAINBIRD LXM-DTC-PR SATELLITE CONTROLLER FOR IQ - CENTRAL CONTROL SYSTEM
- 2 ⊙ RAINBIRD 3RC QUICK COUPLING VALVE (PROVIDE 2 KEYS)
- 31 ⊙ RAINBIRD 1804-PRS POP-UP TURF SPRAY W/8Q NOZZLE
- 14 ⊙ RAINBIRD 1804-PRS POP-UP TURF SPRAY W/8H NOZZLE
- 43 ⊙ RAINBIRD 1804-PRS POP-UP TURF SPRAY W/12VAN NOZZLE
- 5 ⊙ RAINBIRD 1804-PRS POP-UP TURF SPRAY W/15VAN NOZZLE
- 5 ⊙ RAINBIRD 1804-PRS POP-UP TURF SPRAY W/18VAN NOZZLE
- 11 ⊙ RAINBIRD 1804-PRS POP-UP TURF SPRAY W/15SST NOZZLE
- 2 ⊙ RAINBIRD 1804-PRS POP-UP TURF SPRAY W/15LCS NOZZLE

- 2 ▷ RAINBIRD 3504 POP-UP TURF ROTOR W/75 NOZZLE
- 4 ▷ RAINBIRD 3504 POP-UP TURF ROTOR W/1.5 NOZZLE
- 17 ▷ RAINBIRD 5004 POP-UP TURF ROTOR W/1.0LA NOZZLE
- 27 ▷ RAINBIRD 5004 POP-UP TURF ROTOR W/2.0LA NOZZLE
- 7 ▷ RAINBIRD 5004 POP-UP TURF ROTOR W/3.0LA NOZZLE

- _____ SCH40 PVC MAINLINE PIPING
- _____ CLASS 200 PVC LATERAL PIPING
- _____ POLYETHYLENE DRIP TUBING (RAINBIRD LD-06-18)
- _____ SLEEVING (2" - 4" = SCH40 PVC)


GENERAL NOTES

1. IRRIGATION CONTRACTOR SHALL INSTALL ALL EQUIPMENT AS PER MANUFACTURER'S CURRENT SPECIFICATIONS AND RECOMMENDATIONS.
2. IRRIGATION CONTRACTOR SHALL VERIFY A MINIMUM DYNAMIC WATER PRESSURE OF 50psi WITH A FLOW RATE OF 20gpm AT THE POINT-OF-CONNECTION PRIOR TO INSTALLATION. IRRIGATION CONTRACTOR SHALL NOTIFY ARCHITECT IF WATER PRESSURE IS LESS THAN OR SIGNIFICANTLY HIGHER THAN NOTED.
3. COORDINATE EXACT LOCATION OF POINT-OF-CONNECTION WITH THE ARCHITECT AND GENERAL CONTRACTOR.
4. COORDINATE EXACT LOCATION OF CONTROLLER WITH THE ARCHITECT AND GENERAL CONTRACTOR.
5. WHEN TRENCHING UNDER THE DRIPLINE OF EXISTING TREES EXTREME CARE MUST BE GIVEN TO AVOID ROOT DAMAGE. IF AT ALL POSSIBLE AVOID TRENCHING INSIDE THE DRIPLINE BY GOING AROUND THE TREE RATHER THAN UNDER IT. IF TRENCHING MUST OCCUR UNDER THE DRIPLINE, USE EITHER TUNNELING OR HAND-DIGGING METHODS RATHER THAN A MECHANICAL TRENCHER. MINIMIZE THE IMPACT OF ROOT SEVERING BY AVOIDING CONSTRUCTION DURING HOT, DRY WEATHER, KEEPING TREES WELL WATERED BEFORE AND AFTER DIGGING AND COVERING ROOTS WITH SOIL OR MULCH AS SOON AS POSSIBLE.
6. IRRIGATION CONTRACTOR SHALL BE RESPONSIBLE FOR DAMAGES CAUSED TO ALL UTILITIES (BOTH OVERHEAD AND BELOW GROUND) DURING THE IRRIGATION INSTALLATION. IRRIGATION CONTRACTOR SHALL SEEK THE ASSISTANCE OF LOCAL UTILITIES AND THE OWNER IN THE LOCATION OF THE UTILITIES PRIOR TO PERFORMING TRENCHING OPERATIONS IN THE WORK AREA.
7. THE IRRIGATION DESIGN IS DIAGRAMMATIC. THE INTENT OF THE DRAWINGS IS TO SHOW THE GENERAL LAYOUT AND LOGIC OF THE SYSTEM. SCALED MEASUREMENTS MAY NOT BE ACCURATE. ACTUAL LOCATIONS AND QUANTITIES OF PIPE AND FITTINGS MAY VARY DUE TO FIELD ADJUSTMENTS FOR EXISTING CONDITIONS AND OTHER OBSTRUCTIONS TO PROVIDE THE PROPER AND INTENDED COVERAGE.
8. ALL MAINLINE SHALL BE SCH40 PVC. ALL LATERAL PIPING SHALL BE CLASS 200 PVC PIPING. ALL PVC FITTINGS SHALL BE PVC TYPE 1 AND MUST BE OF DOMESTIC MANUFACTURE. PVC SOLVENT CEMENT AND PRIMER SHALL BE AS RECOMMENDED / APPROVED BY THE MANUFACTURER OF THE PIPE.


SLEEVING NOTES

1. ALL SLEEVING SHALL BE PROVIDED BY THE GENERAL CONTRACTOR.
2. ALL SLEEVING PROVIDED FOR THE IRRIGATION SYSTEM TO BE SIZED AS NOTED ON THE PLAN.
3. ALL SLEEVING TO BE BURIED A MIN. OF 18" AND A MAX. OF 24" BELOW THE FINISHED GRADE. ENDS OF SLEEVES SHALL EXTEND 12" PAST THE EDGES OF ALL PAVING AND CURBS AND BE CLEARLY MARKED FOR FUTURE USE BY THE SPRINKLER SYSTEM CONTRACTOR.

REF. SHEET
L301 FOR
THIS AREA

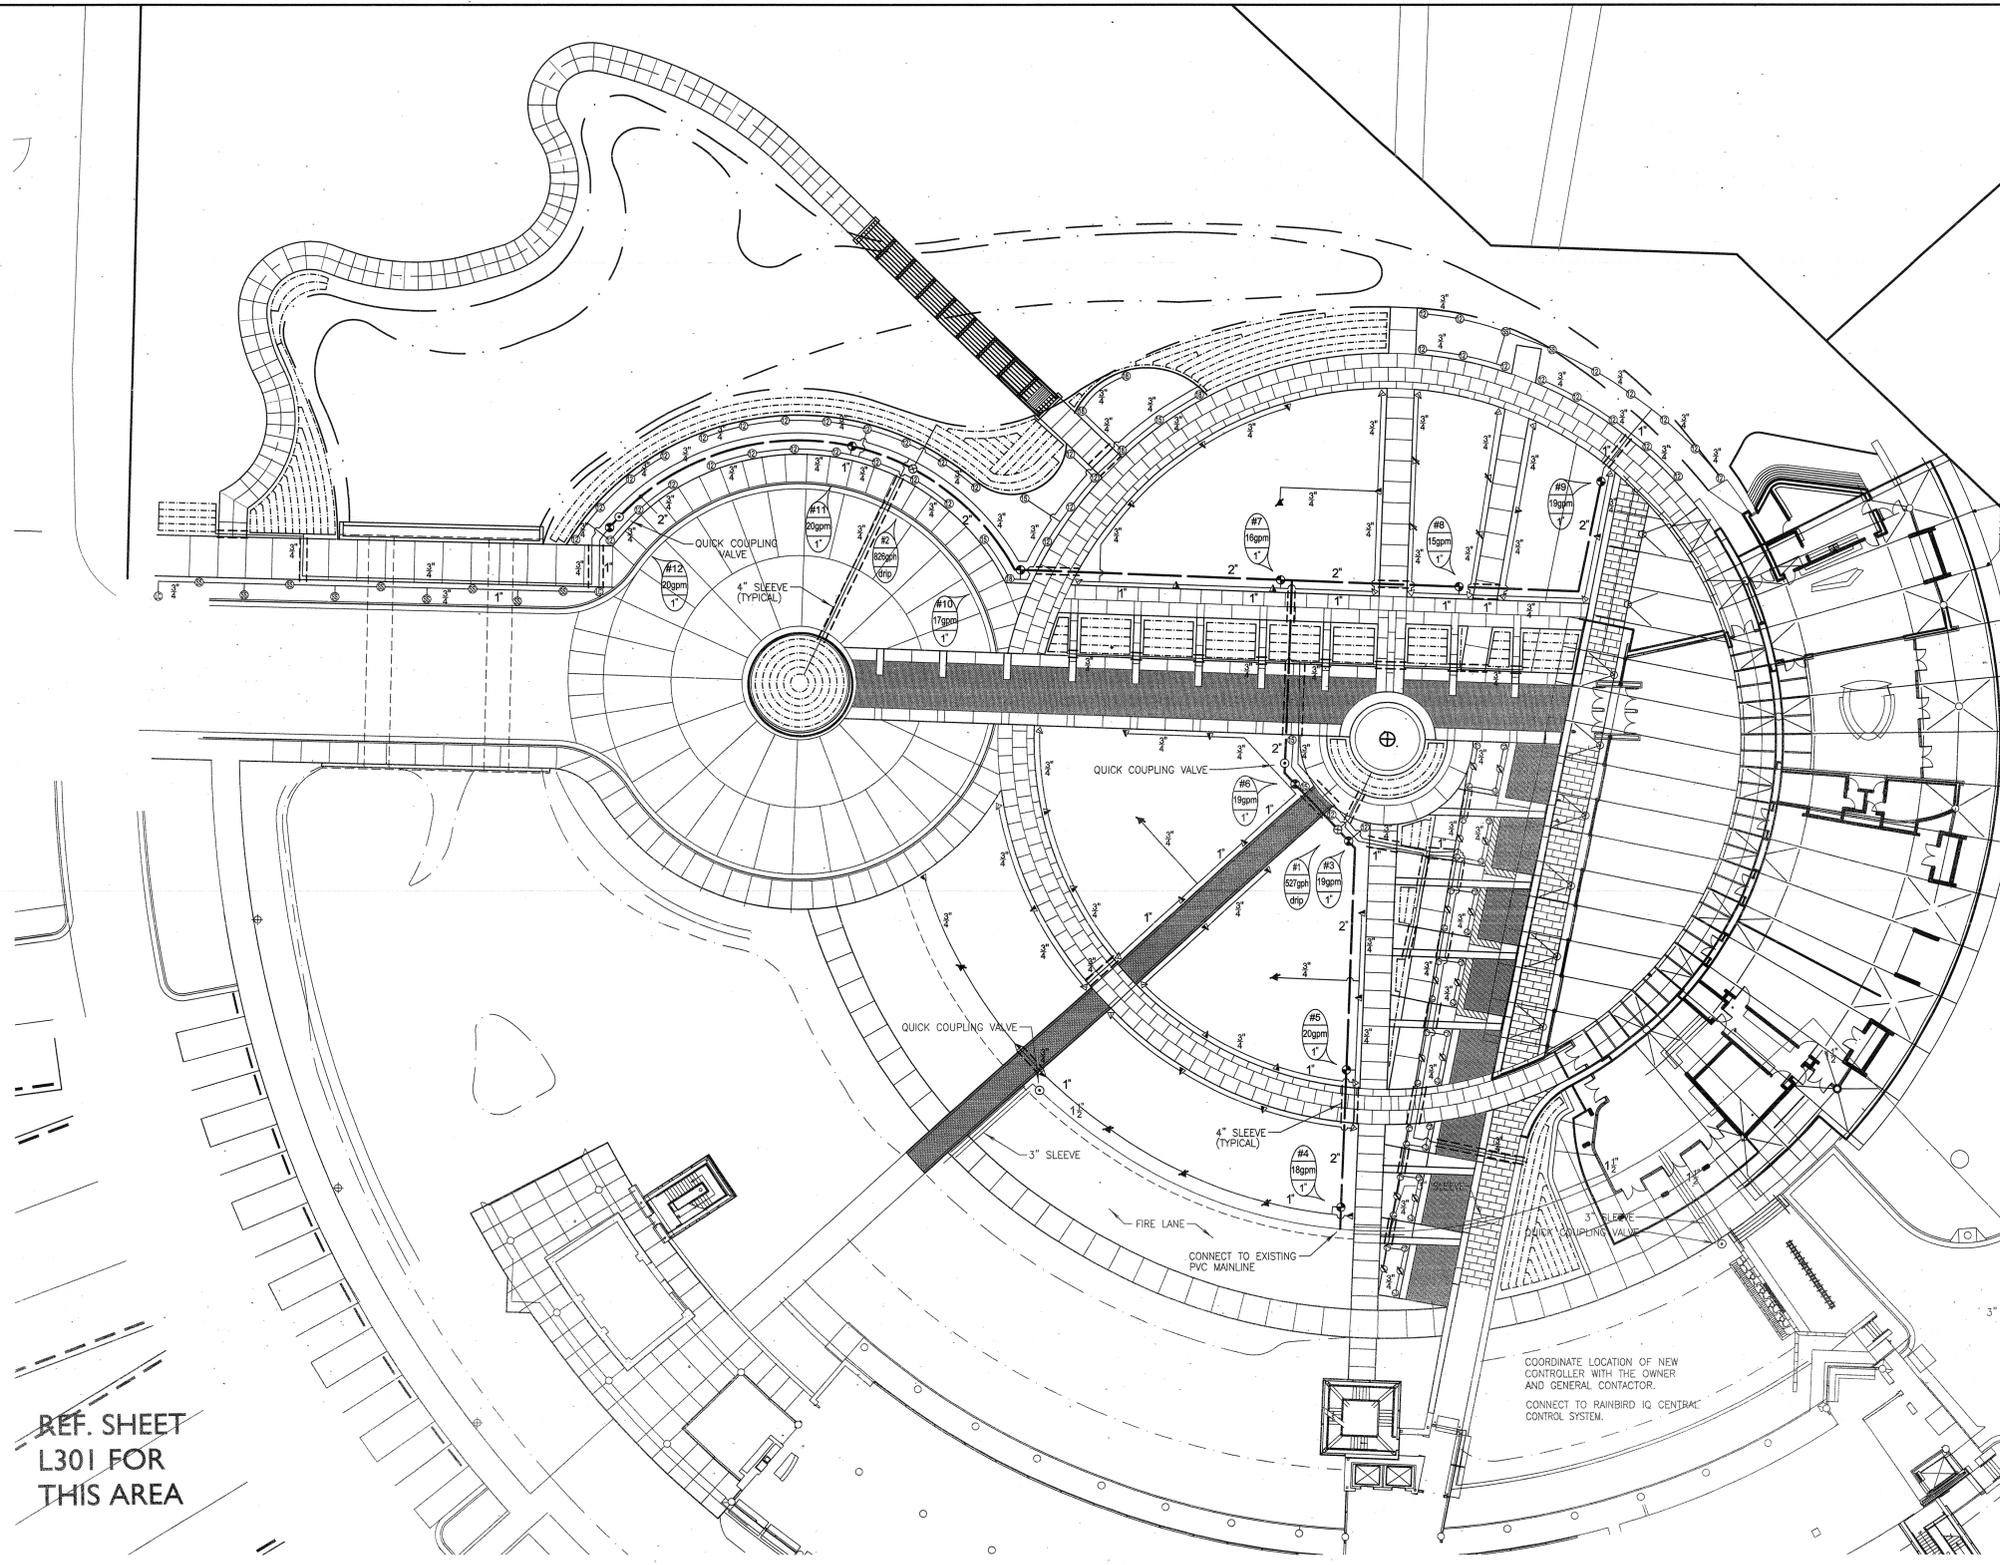

 COMMONS - THIRD STREET EXTENSION IRRIGATION PLAN
SCALE: 1"=20'-0"



700 SOUTH SCHILLER
LITTLE ROCK, AR 72201
501.378.0878 office
501.372.7629 fax

509W. SPRING STREET, SUITE 150
FAYETTEVILLE, AR 72701
479.444.0473 office
479.251.7216 fax

www.polkstanley.com

CONSULTANTS:

CIVIL ENGINEER:
McCLELLAND CONSULTING
ENGINEERS INC.

LANDSCAPE ARCHITECT:
LARSON BURNS AND SMITH, INC.

STRUCTURAL ENGINEER:
CROMWELL ENGINEERS INC.

MECH., ELEC., PLUMB. ENGINEER:
CROMWELL ENGINEERS INC.

GLOBAL VILLAGE CONSULTANT:
CAMBRIDGE SEVEN ASSOCIATES

INTERIOR DESIGNER:
POLK STANLEY ROWLAND
CURZON PORTER ARCHITECTS

GENERAL CONTRACTOR:
CDI CONTRACTORS, INC.

NOTES:

ISSUE DATE:
17 SEPTEMBER 2007

REVISIONS:

#	DATE	DESCRIPTION

**MURPHY KELLER
EDUCATION CENTER**

**HEIFER
INTERNATIONAL
CENTER**

LITTLE ROCK, ARKANSAS

PSRCP JOB NUMBER:
431E

CONTENTS:
IRRIGATION DETAILS

SHEET NUMBER:
L302

