

CONSULTANTS:

CIVIL ENGINEER:
MCLELLAND CONSULTING
ENGINEERS INC.

LANDSCAPE ARCHITECTS:
LARSON BURNS AND SMITH, INC.

STRUCTURAL ENGINEER:
CROMWELL ENGINEERS INC.

MECH., ELEC., PLUMB. ENGINEER:
CROMWELL ENGINEERS INC.

GLOBAL VILLAGE CONSULTANT:
CAMBRIDGE SEVEN ASSOCIATES

INTERIOR DESIGNER:
POLK STANLEY ROWLAND
CURZON PORTER ARCHITECTS

GENERAL CONTRACTOR:
CDI CONTRACTORS, INC.

NOTES:

- _____
- _____
ISSUE DATE:
17 SEPTEMBER 2007

REVISIONS:

#	DATE	DESCRIPTION

**MURPHY KELLER
EDUCATION CENTER**


**HEIFER
INTERNATIONAL
CENTER**

LITTLE ROCK, ARKANSAS

PSRCP JOB NUMBER:
431E

CONTENTS:
NORTH WETLANDS
GRADING PLAN

SHEET NUMBER:
L103

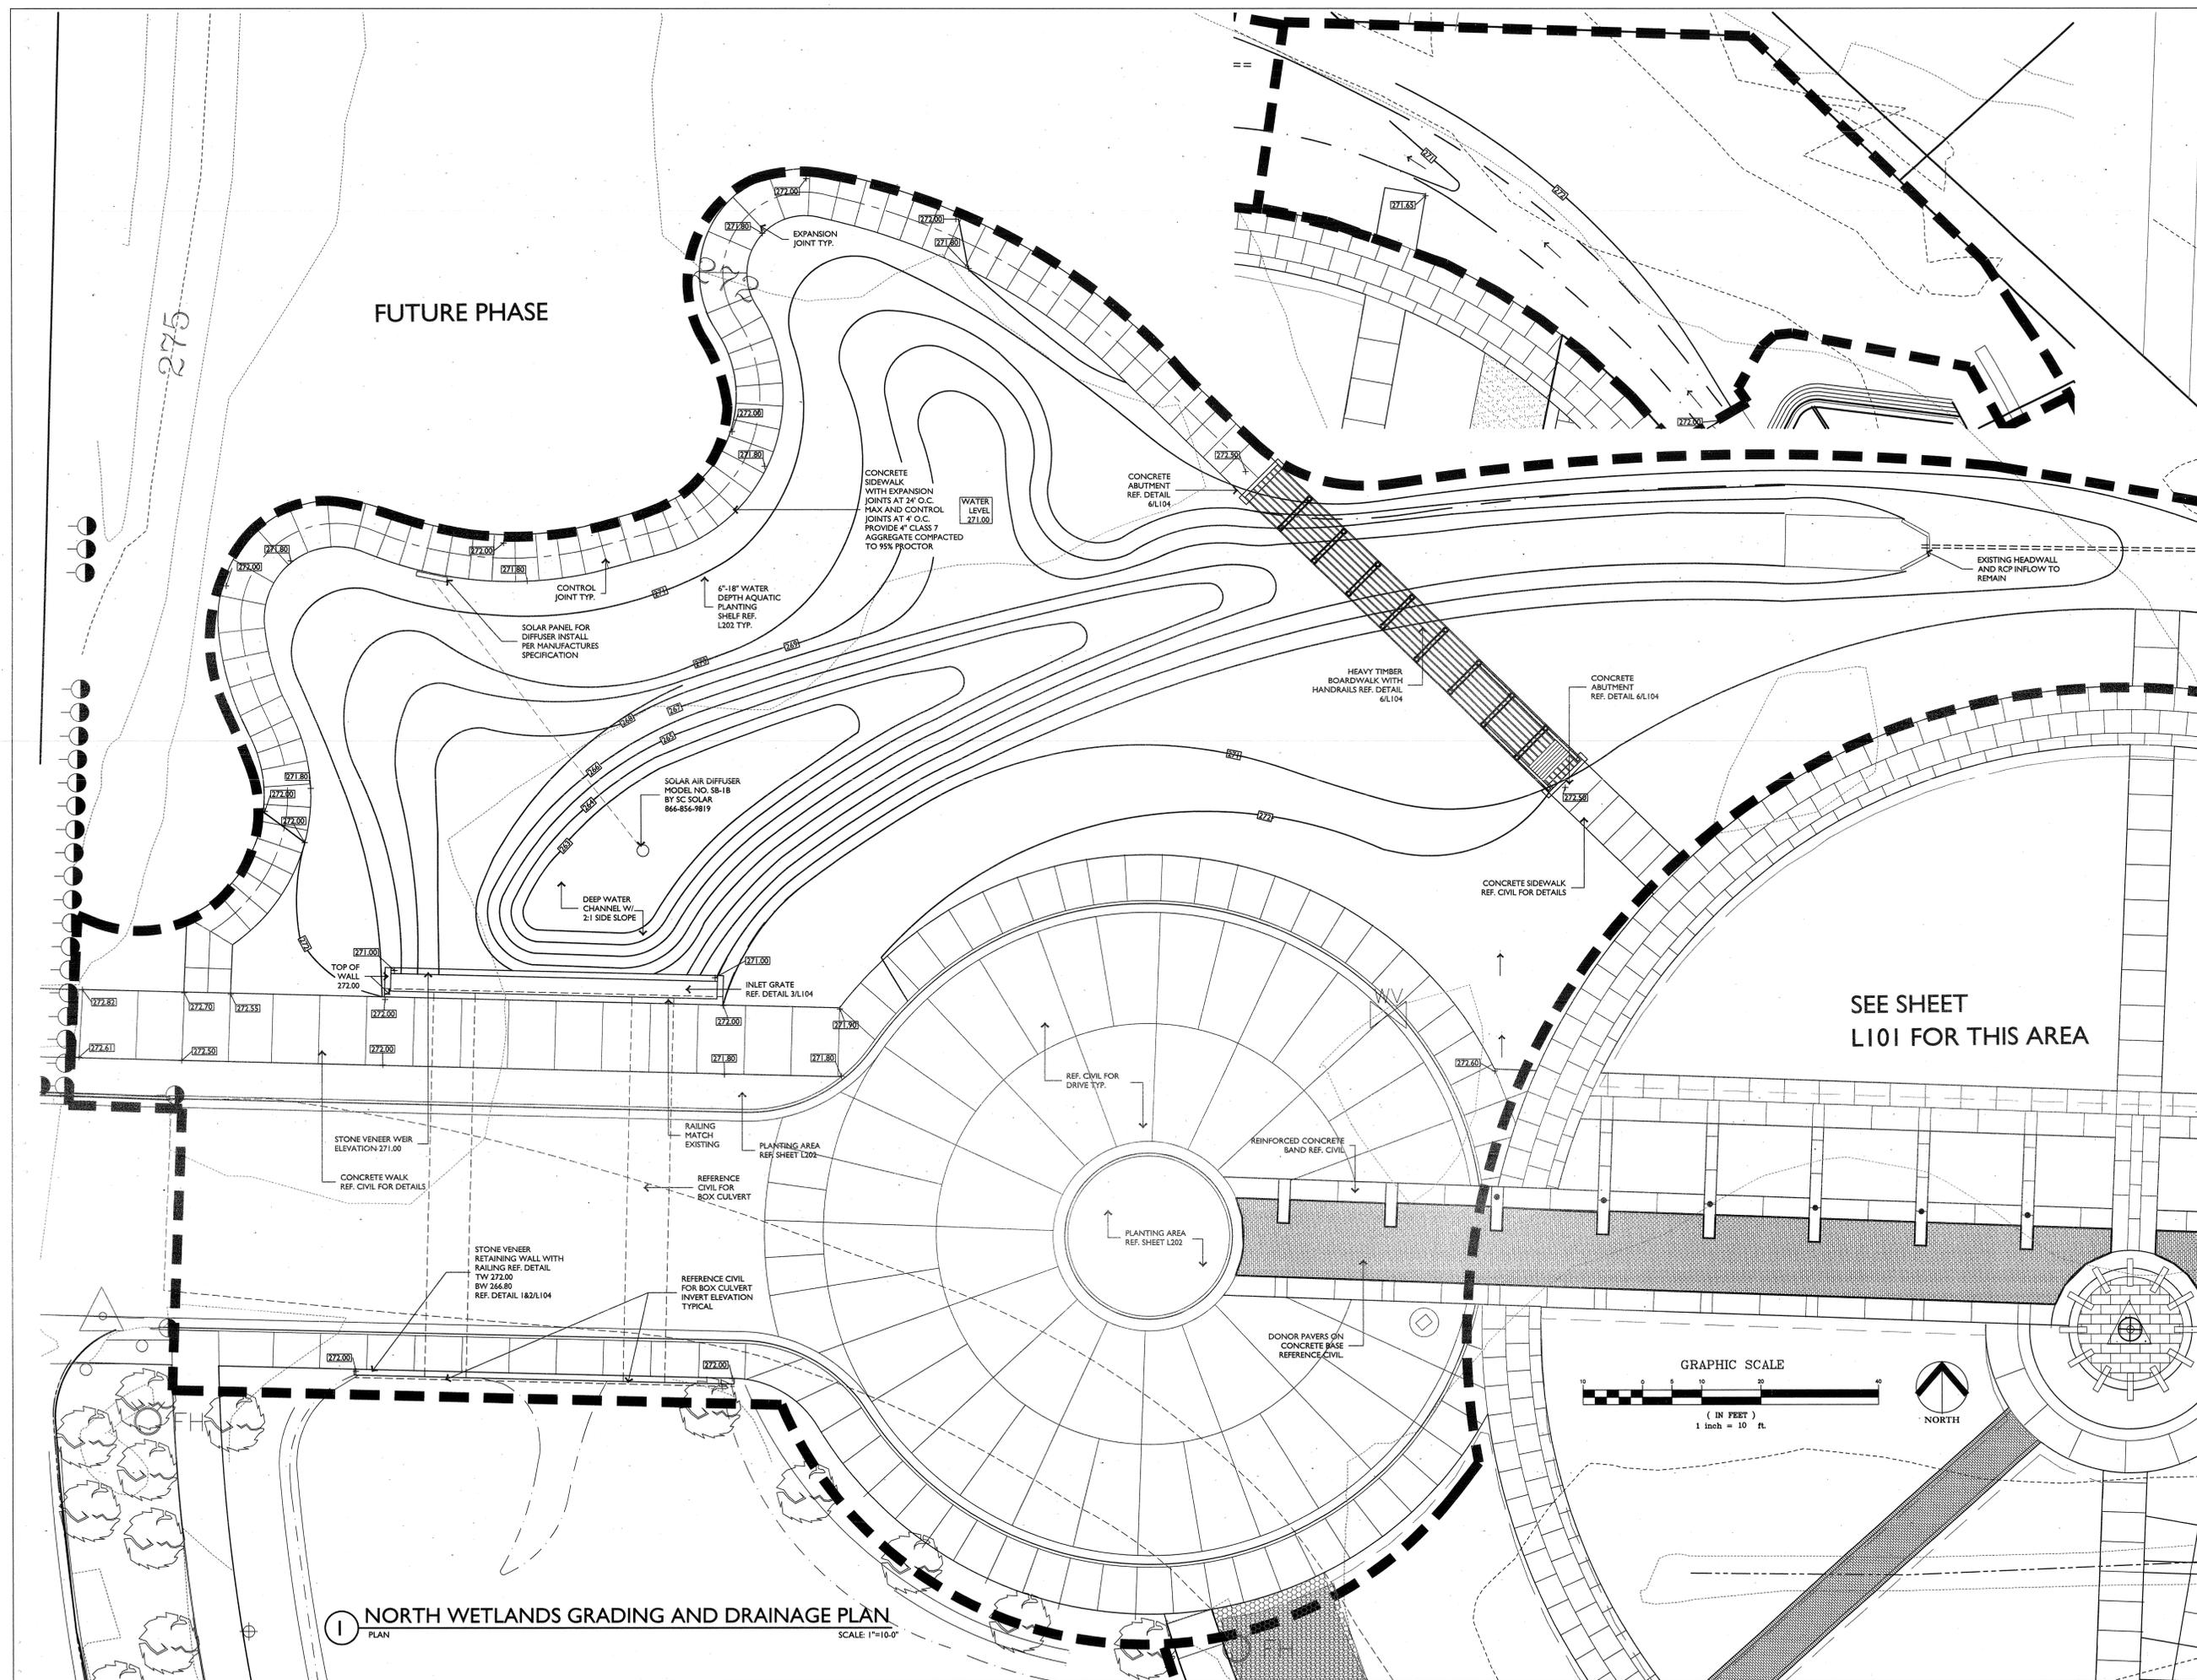

1 NORTH WETLANDS GRADING AND DRAINAGE PLAN
SCALE: 1"=10'-0"

SEE SHEET
L101 FOR THIS AREA